


SHEET RENOVATION KEY NOTES:	
①	ELECTRICAL BOX MOUNTED TRANSFORMER FOR FLUSH VALVES. TO POWER A MAXIMUM OF 6 FLUSH VALVES.
②	ELECTRICAL BOX MOUNTED TRANSFORMER FOR LAVATORY FAUCETS. TO POWER A MAXIMUM OF 8 FAUCETS.
③	16"x16" 14 GAUGE STAINLESS STEEL ACCESS PANEL. TO BE MOUNTED TO PROVIDE ACCESS TO ELECTRICAL BOX MOUNTED TRANSFORMER IN CHASE. SECURE WITH VANDAL PROOF STAINLESS STEEL SCREWS.
④	16"x16" 14 GAUGE STAINLESS STEEL ACCESS PANEL MOUNTED ABOVE SOAP DISPENSER. TO BE MOUNTED TO PROVIDE ACCESS TO ELECTRICAL BOX MOUNTED TRANSFORMER IN CHASE. SECURE WITH VANDAL PROOF STAINLESS STEEL SCREWS.

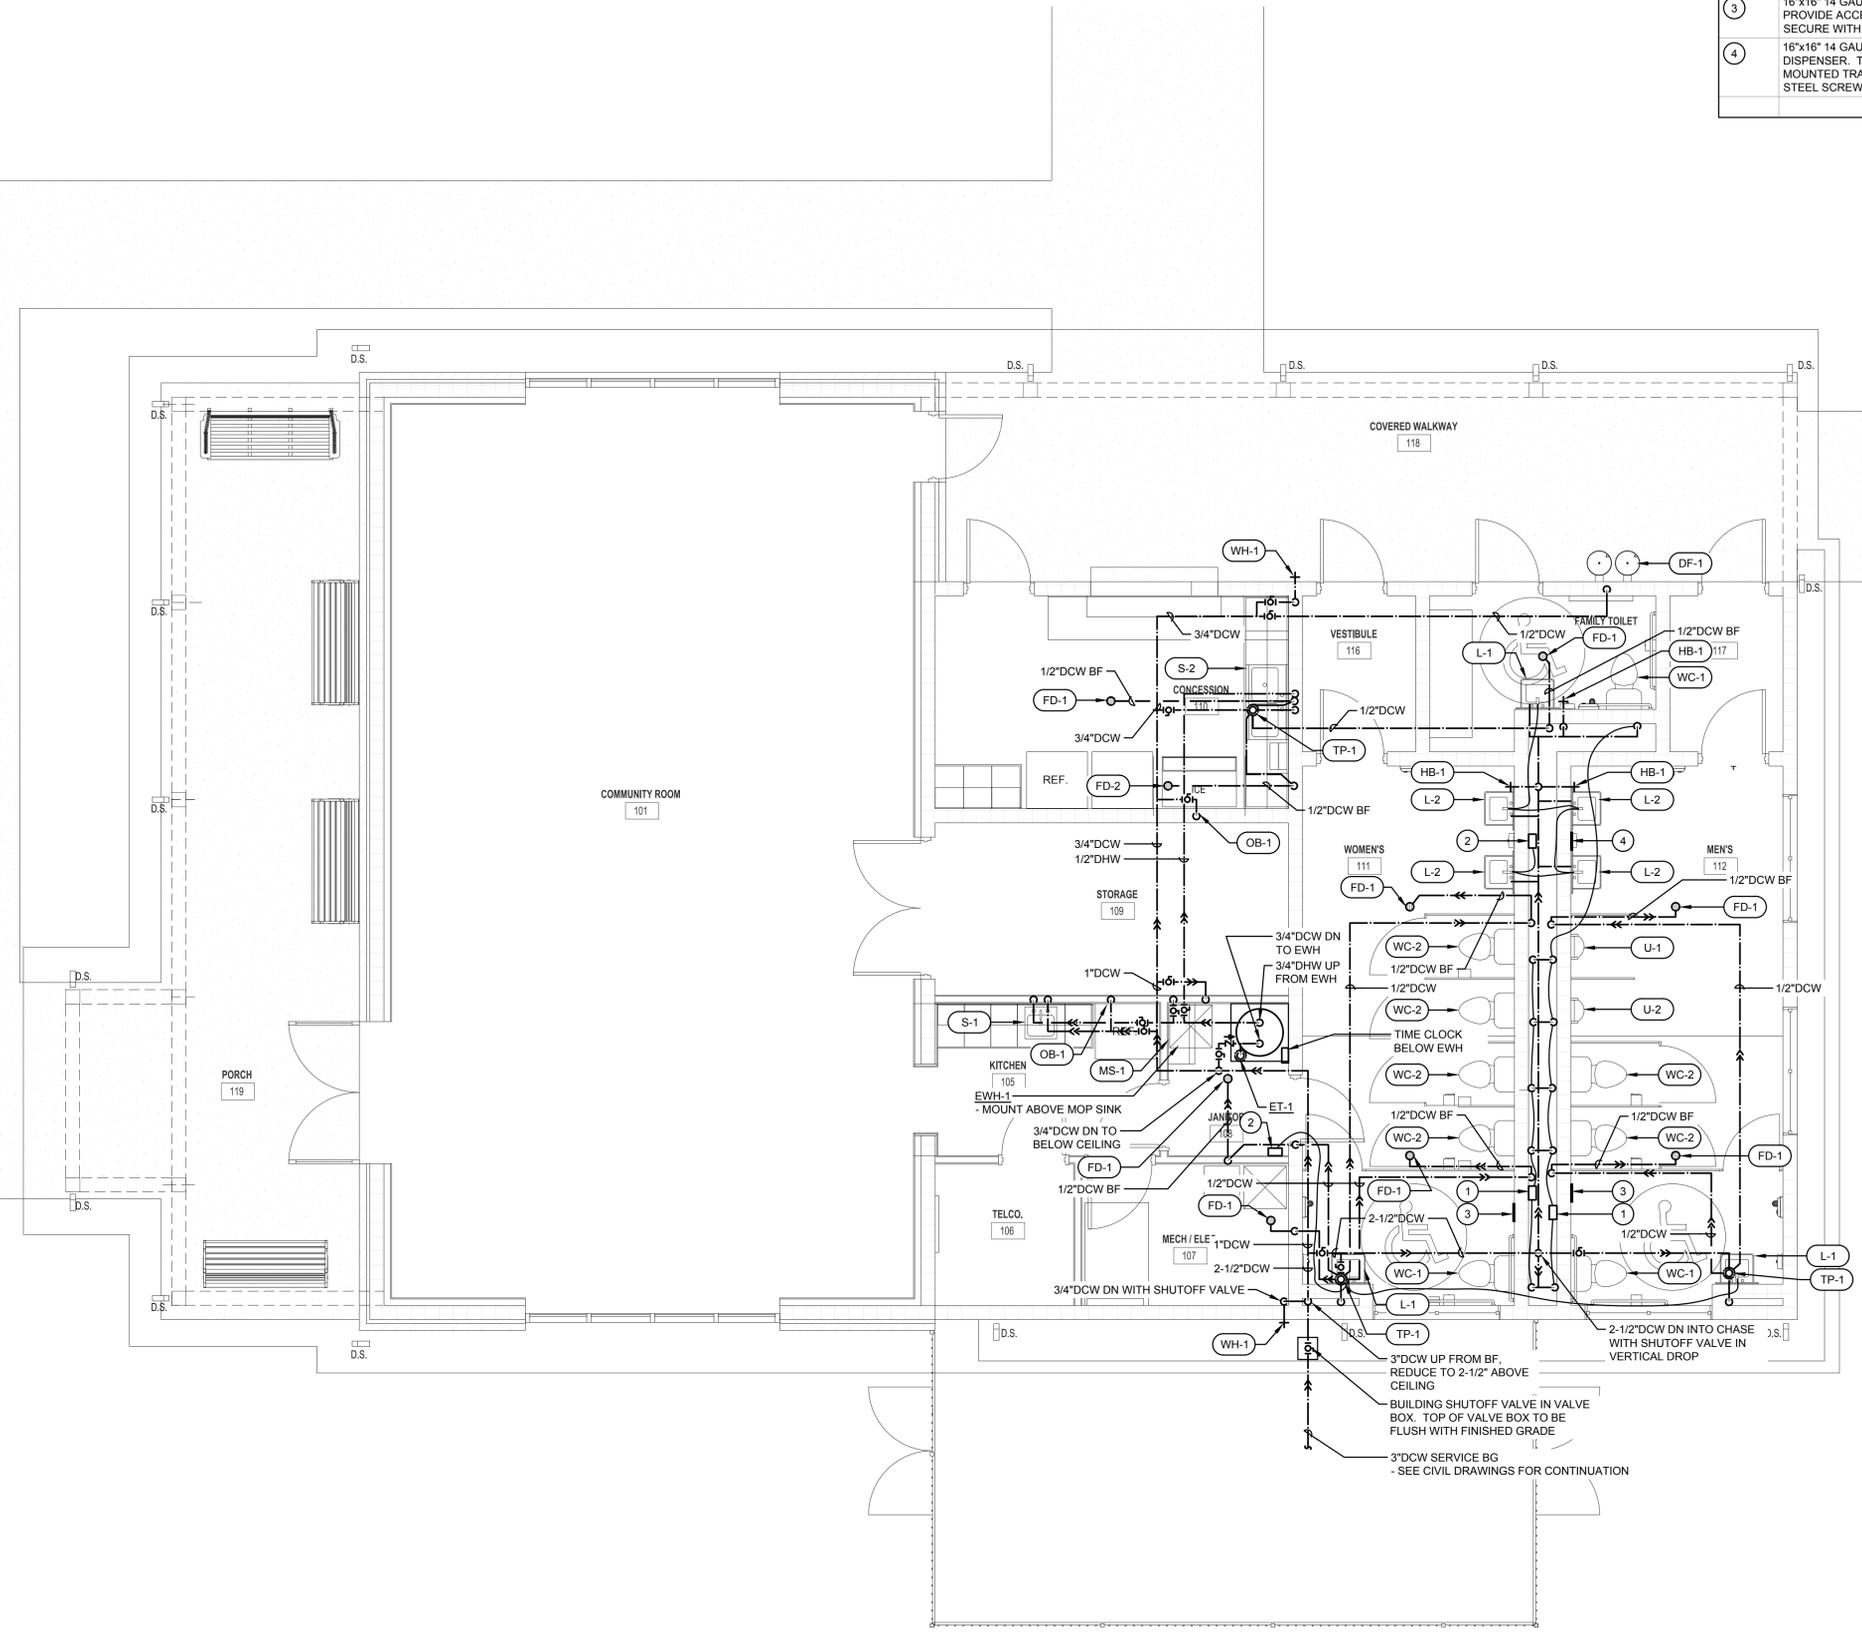

1940 Buford Blvd. - Tallahassee, FL 32302
 Phone: 850-402-3040
 Fax: 850-402-9659
 Certificate of Authorization #: 29709
 Tomahawk Project #: 24049

RICHARD LINDBURG
 PE#: 62829
 WESLEY THIGPEN, JR.
 PE#: 65705



THIS ITEM HAS BEEN ELECTRONICALLY SIGNED AND SEALED BY THE ENGINEER INDICATED HEREIN WITH THE DATE AS INDICATED IN THE TIME STAMP BEING AN SIA CODE.
 PRINTED COPIES OF THIS DOCUMENT ARE NOT CONSIDERED SIGNED AND SEALED AND THE SIA AUTHENTICATION CODE MUST BE VERIFIED ON ANY ELECTRONIC COPIES.



LEON CO. NE PARK

19580 Drawn By: TKE
 Project Code Checked By: WHT

06 NOVEMBER, 2024
 Date
BID DOCUMENTS

Revisions
 ▲
 ▲
 ▲
 ▲
 ▲
 ▲
 ▲

**FLOOR PLAN -
 PRESSURE PLUMBING**


Tallahassee Florida

P2.1


1 FLOOR PLAN - PRESSURE PLUMBING

P2.1 1/4" = 1'-0"




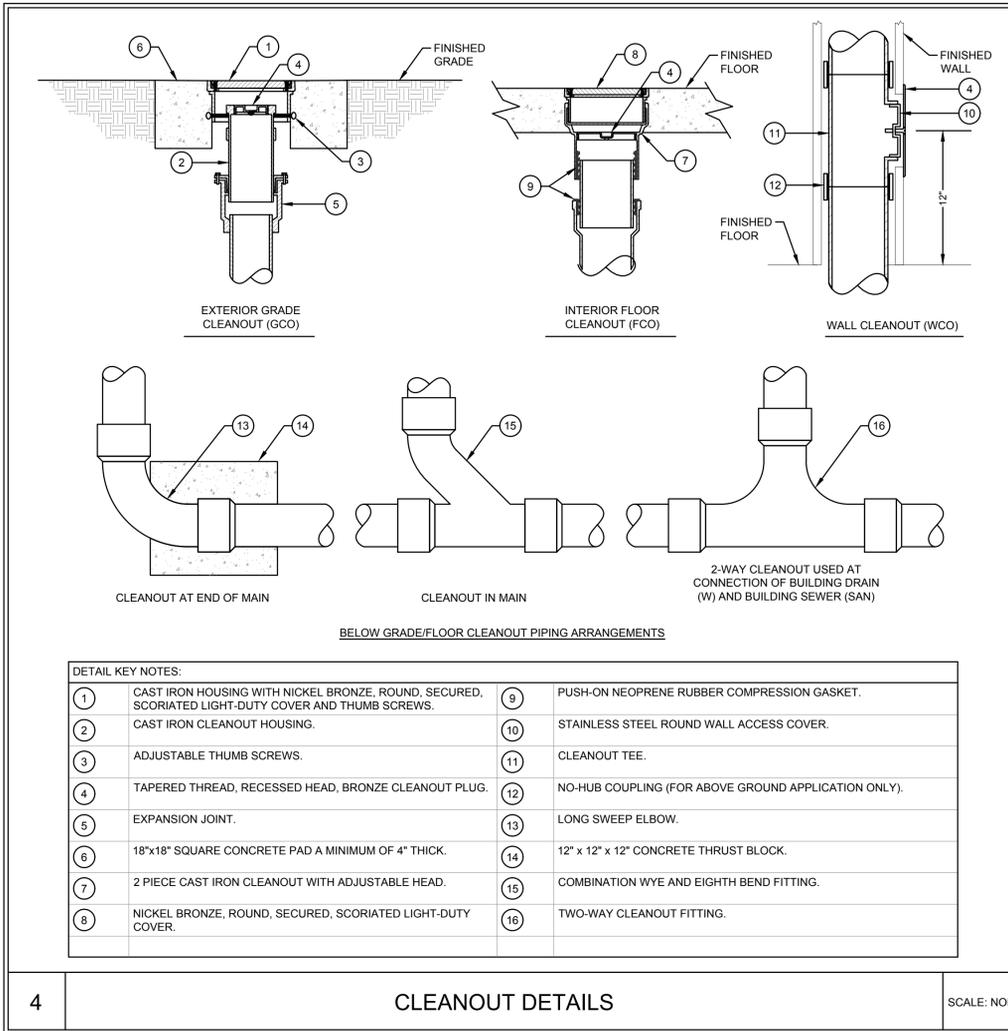


4 CLEANOUT DETAILS SCALE: NONE

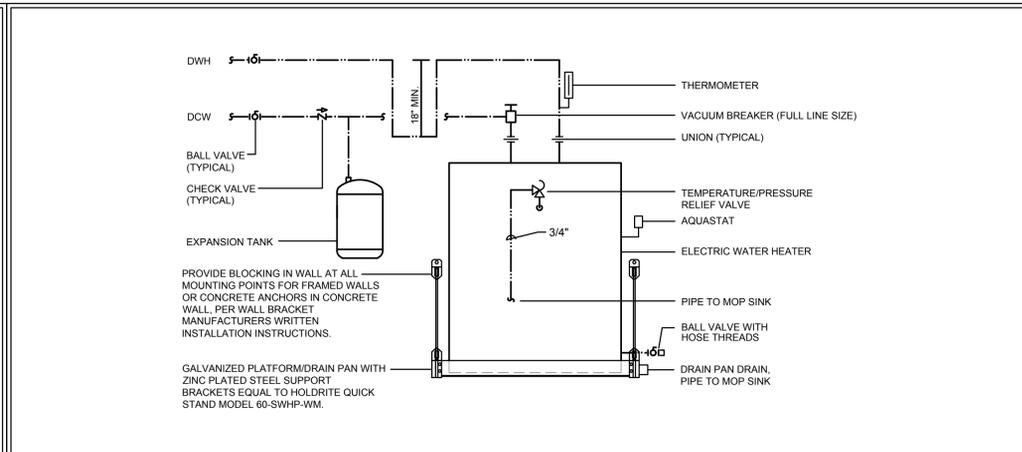

1 WALL HUNG WATER HEATER DETAIL SCALE: NONE

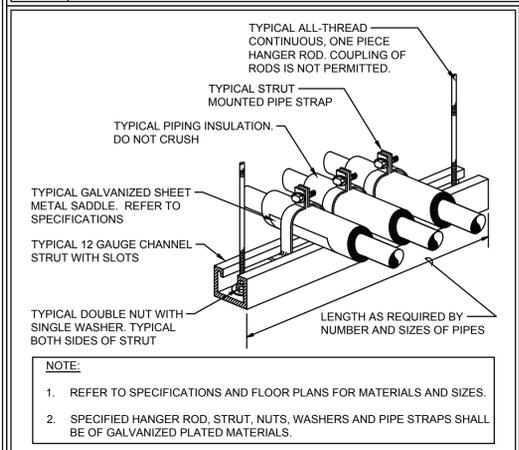

3 INSULATED PIPE TRAPEZE HANGER DETAIL SCALE: NONE

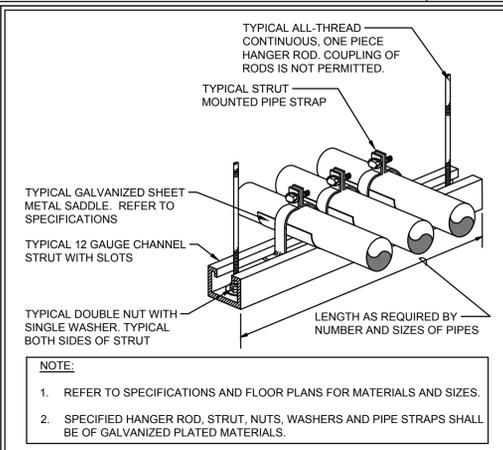


2 NON INSULATED PIPE TRAPEZE HANGER DETAIL SCALE: NONE



1940 Buford Blvd. - Tallahassee, FL 32302
 Phone: 850-402-3040
 Fax: 850-402-9659
 Certificate of Authorization #: 29709
 Tomahawk Project #: 24049

RICHARD LINDBURG
 PE#: 62829
 WESLEY THIGPEN, JR
 PE#: 65705

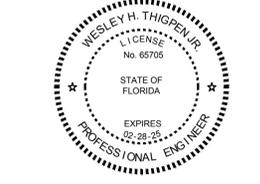

THIS ITEM HAS BEEN ELECTRONICALLY SIGNED AND SEALED BY THE ENGINEER INDICATED HEREIN WITH THE DATE AS INDICATED IN THE STAMP USING AN SPS CODE.
 PRINTED COPIES OF THIS DOCUMENT ARE NOT CONSIDERED SIGNED AND SEALED AND THE SPS AUTHENTICATION CODE MUST BE VERIFIED ON ANY ELECTRONIC COPIES.



LEON CO. NE PARK

19580 Drawn By: TKE
 Project Code Checked By: WHT

06 NOVEMBER, 2024
 Date
BID DOCUMENTS

Revisions

▲	
▲	
▲	
▲	
▲	
▲	
▲	

DETAILS - PLUMBING

Tallahassee Florida

P5.1

FIXTURE PIPE CONNECTION SIZES					
FIXTURE TYPE	DESCRIPTION	COLD WATER	HOT WATER 120°F	WASTE	VENT
WC-1	WATER CLOSET	1"	-	4"	2"
WC-2	WATER CLOSET	1"	-	4"	2"
U-1	URINAL	3/4"	-	2"	2"
U-2	URINAL	3/4"	-	2"	2"
L-1	LAVATORY	1/2"	-	2"	2"
L-2	LAVATORY	1/2"	-	2"	2"
S-1	SINK	1/2"	1/2"	2"	2"
S-2	SINK	1/2"	1/2"	2"	2"
MS-1	MOP SINK	3/4"	3/4"	3"	2"
DF-1	DRINKING FOUNTAIN	1/2"	-	2"	2"
OB-1	OUTLET BOX	1/2"	-	-	-
HB-1	HOSE BIBS	3/4"	-	-	-
WH-1	WALL HYDRANT	3/4"	-	-	-
FD-1	FLOOR DRAIN	1/2"	-	2"	2"
FD-2	FLOOR DRAIN	1/2"	-	2"	2"
TP-1	TRAP PRIMER	1/2"	-	-	-
EWH-1	ELECTRIC WATER HEATER	3/4" (INLET)	3/4" (OUTLET)	-	-



1940 Buford Blvd. - Tallahassee, FL 32302
 Phone: 850-402-3040
 Fax: 850-402-9659
 Certificate of Authorization #: 29709
 Tomahawk Project #: 24049

RICHARD LINDBURG
 PE# 62829
 WESLEY THIGPEN, JR.
 PE# 65705



THIS ITEM HAS BEEN ELECTRONICALLY SIGNED AND SEALED BY THE ENGINEER INDICATED HEREIN WITH THE DATE AS INDICATED IN THE TIME STAMP USING AN SPS CODE.
 PRINTED COPIES OF THIS DOCUMENT ARE NOT CONSIDERED SIGNED AND SEALED AND THE SPS AUTHENTICATION CODE MUST BE VERIFIED ON ANY ELECTRONIC COPIES.



LEON CO. NE PARK


19580 Drawn By: TKE
 Project Code Checked By: WHT
 Date
 06 NOVEMBER, 2024
 BID DOCUMENTS

- Revisions
- ▲
 - ▲
 - ▲
 - ▲
 - ▲
 - ▲
 - ▲
 - ▲


ISOMETRICS - PLUMBING

Tallahassee Florida

P6.1

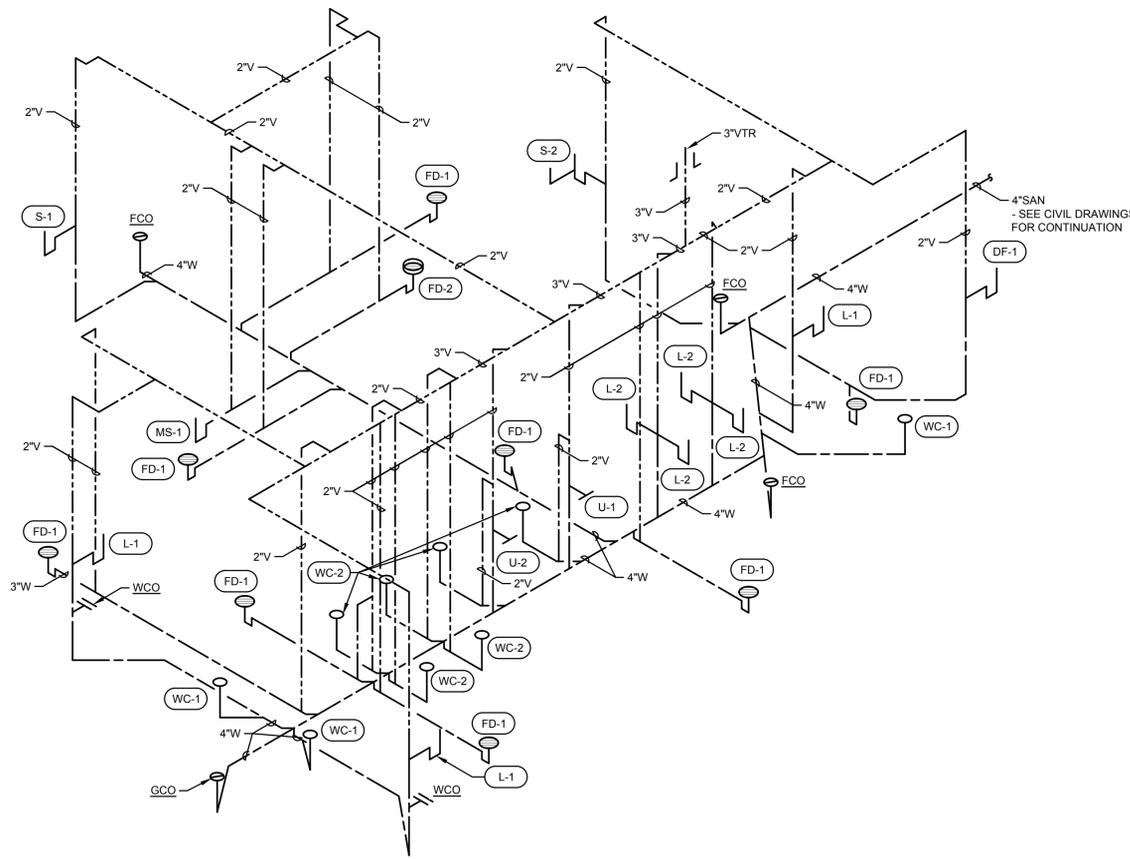

1 ISOMETRIC - GRAVITY PLUMBING
 P6.1 NO SCALE

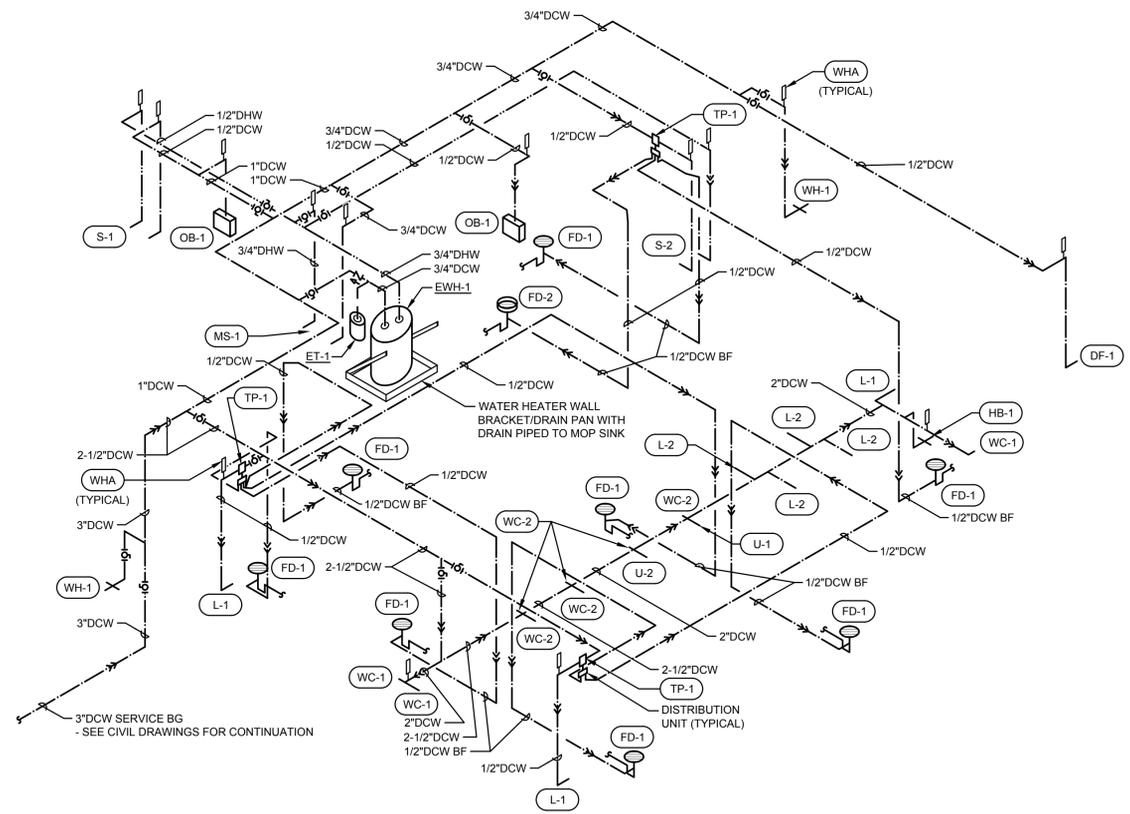

2 ISOMETRIC - PRESSURE PLUMBING
 P6.1 NO SCALE