


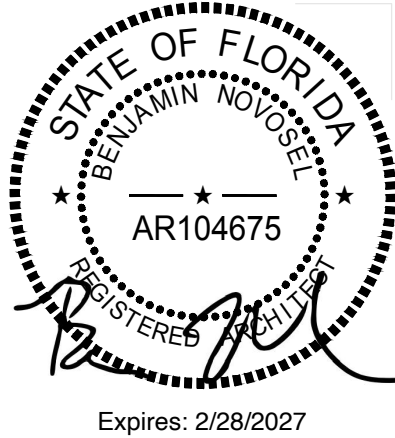

GENERAL CONDITIONS

THE GENERAL CONDITION OF THE CONTRACT FOR CONSTRUCTION ARE CONTAINED IN AIA DOCUMENT A201-2007
GENERAL CONDITIONS OF THE CONTRACT FOR CONSTRUCTION AND ARE HEREBY MADE A PART OF THIS
SPECIFICATION AS IF FULLY INCLUDED HEREIN. COPIES OF THIS DOCUMENT ARE AVAILABLE FROM THE ARCHITECT.

BUILDING CODE COMPLIANCE:
THE COMPLETED PROJECT IS TO MEET OR EXCEED THE REQUIREMENTS FOR A COMMERCIAL INTERIOR RENOVATION
USING FRAMING AND GYPSUM WALLBOARD ASSEMBLIES AS SPECIFIED. ALL MATERIALS, ASSEMBLIES AND
FABRICATIONS SUPPLIED AND/OR INCLUDED IN THE PROJECT, AND ALL PROCEDURES, ASSEMBLY, SEQUENCES ETC.
PERFORMED AS A PART OF THE WORK OF THE PROJECT SHALL COMPLY FULLY WITH ALL REQUIREMENTS OF THE
CODE, INCLUDING ALL REFERENCED CODES, STANDARDS, GUIDELINES, STATE AND FEDERAL LAWS.

CONSTRUCTION SAFETY:
IN ACCORDANCE WITH THE GENERALLY ACCEPTED CONSTRUCTION PRACTICES, THE CONTRACTOR SHALL BE
COMPLETELY & SOLELY RESPONSIBLE FOR CONDITIONS OF THE JOB SITE, INCLUDING THE SAFETY OF ALL THE
PERSONS & PROPERTY DURING THE PERFORMANCE OF THE WORK. THIS REQUIREMENT SHALL APPLY CONTINUOUSLY
AND NOT BE LIMITED TO NORMAL HOURS. WHEN ON SITE, THE ARCHITECT IS RESPONSIBLE FOR HIS OWN SAFETY BUT
HAS NO RESPONSIBILITY FOR THE SAFETY OF OTHER PERSONNEL OR SAFETY CONDITIONS AT THE SITE.

THE ARCHITECT SHALL NOT BE RESPONSIBLE FOR THE MEANS, METHODS, TECHNIQUES, SEQUENCES, OR
PROCEDURES OF CONSTRUCTION SELECTED BY THE CONTRACTOR.

THE CONTRACTOR SHALL BRACE THE ENTIRE STRUCTURE AS REQUIRED TO MAINTAIN STABILITY UNTIL COMPLETE
AND FUNCTIONING AS THE DESIGNED UNIT.

DEMOLITION AND SALVAGE:
ITEMS OF SALVAGEABLE VALUE TO THE OWNER SHALL BE REMOVED FROM THE WORK AREA AND STORED AT A
LOCATION MUTUALLY AGREED UPON BY BOTH THE OWNER AND CONTRACTOR. CONTRACTOR SHALL VERIFY ALL
ITEMS OF SALVAGE WITH THE OWNER PRIOR TO ANY DEMOTION.
REMOVE FROM SITE ALL DEBRIS, RUBBISH, AND OTHER MATERIALS RESULTING FROM DEMOLITION OPERATIONS.

EXISTING SITE CONDITIONS:
THE CONTRACTOR AND HIS AGENT(S) SHALL VERIFY ALL INFORMATION, PLAN LAYOUT, AND DIMENSIONS CONTAINED
WITHIN THESE CONSTRUCTION DOCUMENTS. THE CONTRACTOR SHALL VERIFY ALL EXISTING CONDITIONS, INCLUDING
SITE CONDITIONS AND SOIL BEARING PRESSURE. ALL ERRORS, OMISSIONS, INCONSISTENCIES, AND DISCREPANCIES
ARE TO BE REPORTED TO THE ARCHITECT BEFORE PROCEEDING WITH THE WORK. FAILURE TO DO SO WILL RELEASE
THE ARCHITECT FROM ALL RESPONSIBILITY.

DUE TO THE NATURE OF REMODELING AN EXISTING STRUCTURE, CERTAIN ASSUMPTIONS MUST BE MADE BY THE
ARCHITECT REGARDING EXISTING CONDITIONS WHICH MAY NOT BE VERIFIABLE WITHOUT EXPENDING ADDITIONAL
SUMS OF MONEY OR DESTROYING OTHERWISE ADEQUATE PORTIONS OF THE BUILDING. IN THE EVENT THAT
DISCREPANCIES ARISE WHICH CONFLICT WITH THE INTENT OF THESE DOCUMENTS, THE CONTRACTOR SHALL NOTIFY
THE ARCHITECT PRIOR TO CONTINUING WITH THAT PORTION OF THE WORK.






PROPERTY PROTECTION:
THE AREAS OF MAJOR CONSTRUCTION WORK AND RENOVATION ARE DEPICTED ON THE DRAWINGS. THE REMAINING
AREAS OF THE FACILITY AND SITE ARE TO BE SECURED AND PROTECTED FROM WEATHER AND DAMAGE. THE
CONTRACTOR AND SUBCONTRACTORS SHALL BE RESPONSIBLE FOR THE ERECTION AND MAINTENANCE OF
PROTECTIVE MEASURES SUCH AS BARRICADES, DUST PROTECTION, FLOOR COVERING, TENTING, FENCING OR
HOARDING OF LANDSCAPING ETC. SUCH PROTECTION SHALL REMAIN IN PLACE FOR THE DURATION OF THE WORK.

THE CONTRACTOR SHALL ENDEAVOR TO UTILIZE THE SMALLEST OR LIGHTEST EQUIPMENT OR METHODS CONSISTENT
WITH THE TASK TO MINIMIZE DISTURBANCE TO THE SITE. THIS SHALL APPLY TO ALL OPERATIONS INCLUDING
EXCAVATION, HAULING, DEMOLITION, DELIVERY AND MATERIAL STORAGE.

DRAWINGS AND DIMENSIONS:
ALL EXTERIOR FRAME WALLS ARE DIMENSIONED FROM THE EXTERIOR FACE OF SHEATHING TO INTERIOR FACE OF
STUD. ALL INTERIOR WALLS ARE DIMENSIONED TO FACE OF STUD. DO NOT SCALE DRAWINGS. IF INSUFFICIENT
INFORMATION EXISTS, CONTACT THE ARCHITECT FOR CLARIFICATION BEFORE PROCEEDING WITH THE WORK.

WHEN +/- DIMENSIONS ARE GIVEN THEY SHOULD BE CONSIDERED VARIABLE TO ALLOW FOR EXISTING CONDITIONS.
ALL OTHER DIMENSIONS SHOULD BE CONSIDERED FIXED UNLESS APPROVED BY THE ARCHITECT.

RESPONSIBILITY MATRIX			SUPPLIED BY	RECEIVED BY	INSTALLED BY
#	ITEM	COMMENTS			
1	DINING ROOM FURNITURE		OWNER	G.C.	G.C.
2	KITCHEN EQUIPMENT		OWNER	VENDOR	VENDOR
3	KITCHEN HOOD PACKAGE		OWNER	G.C.	G.C.
4	HVAC UNITS	* HOOD & MAU UNIT ARE OWNER SUPPLIED, ALL OTHERS BY G.C.	OWNER*	G.C.	G.C.
5	LIGHTING PACKAGE		OWNER	G.C.	G.C.
6	FLOOR & WALL TILE		G.C.	G.C.	G.C.
7	MILLWORK		G.C.	G.C.	G.C.
8	CABINETS & COUNTERTOPS	* SODA CABINET SUPPLIED BY OWNER, CUTOUT FOR TRASH BY G.C.	G.C.*	G.C.	G.C.
9	INTERIOR ARTWORK		OWNER	G.C.	G.C.
10	EXTERIOR SIGNAGE		OWNER	VENDOR	VENDOR
11	POS SYSTEM		OWNER	OWNER	VENDOR
12	DATA CABLE & TERMINATION	* CABLE RUNS MUST BE PROVIDED BOTH TO AND WITHIN EXPO ISLAND	G.C.	G.C.	G.C.*
13	STAINLESS STEEL CORNER GUARDS		G.C.	G.C.	G.C.
14	PATIO FURNITURE		OWNER	G.C.	G.C.
#	ITEM	COMMENTS	SUPPLIED BY	RECEIVED BY	INSTALLED BY

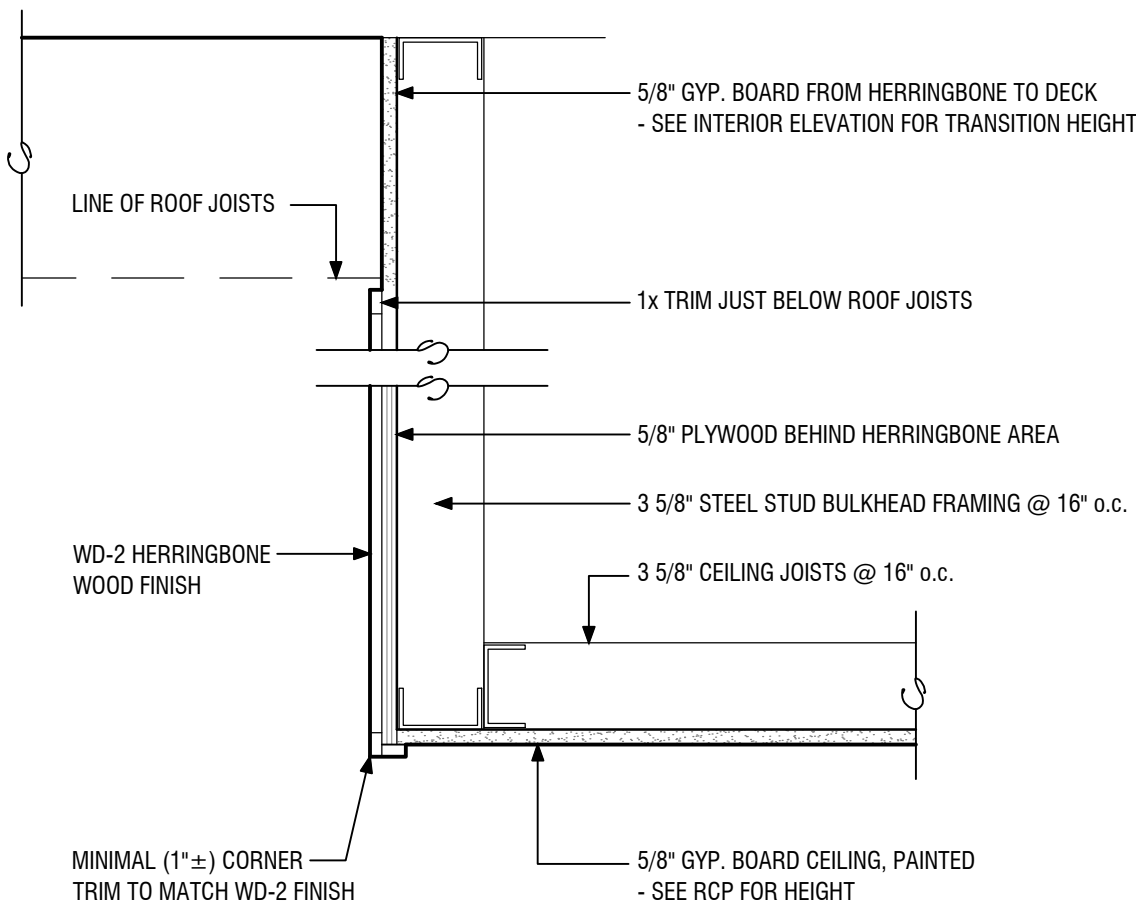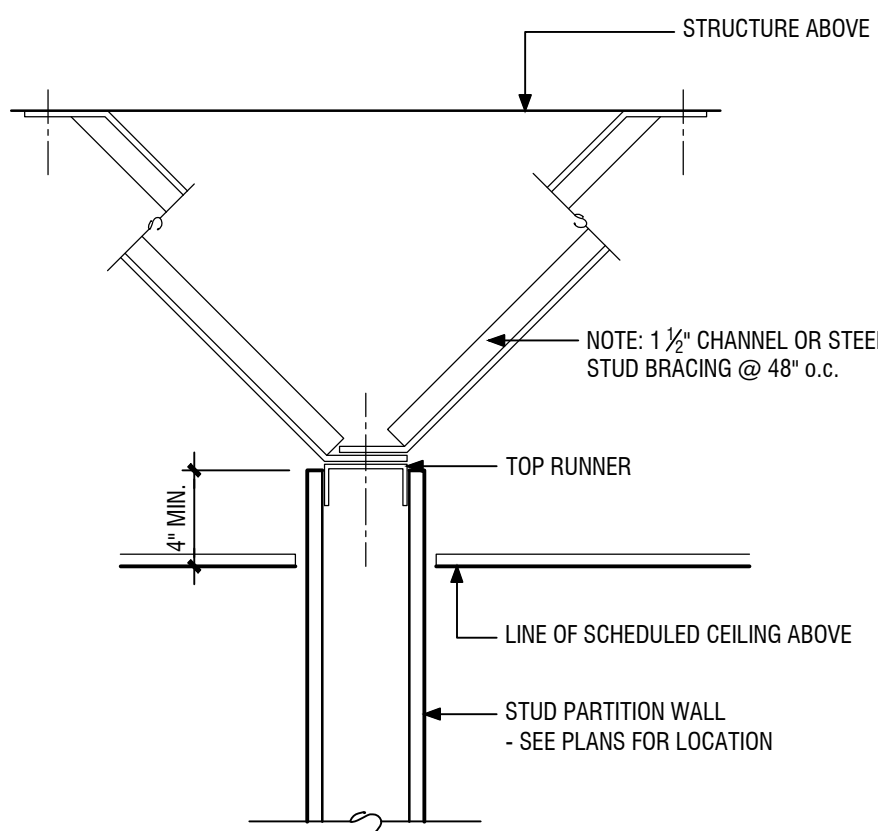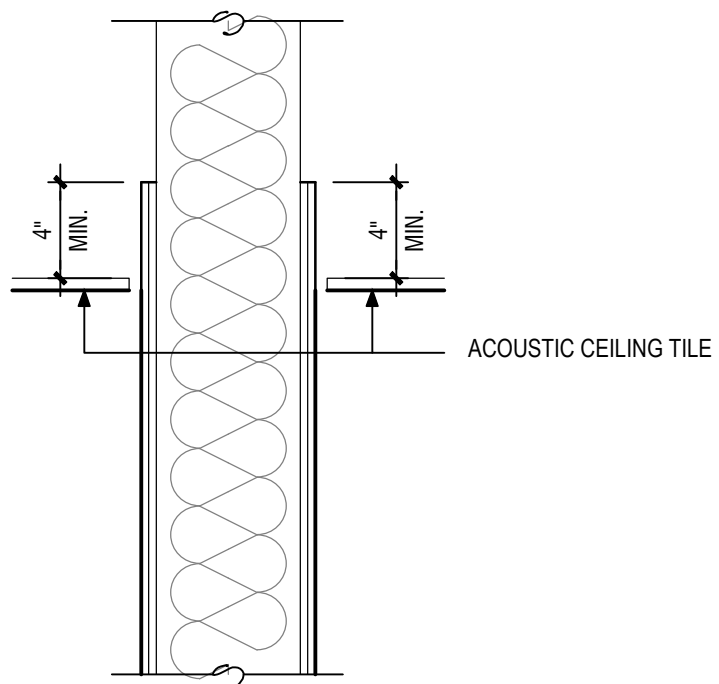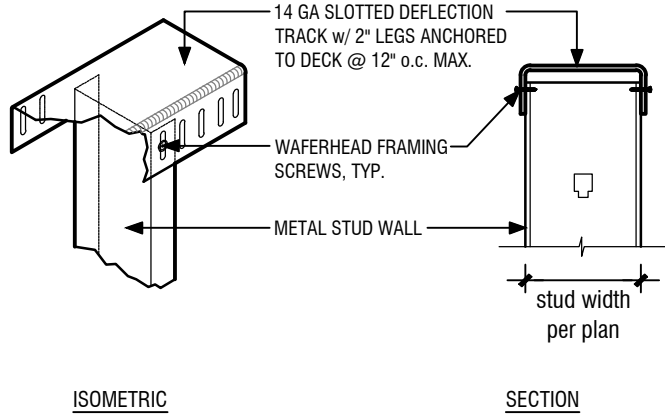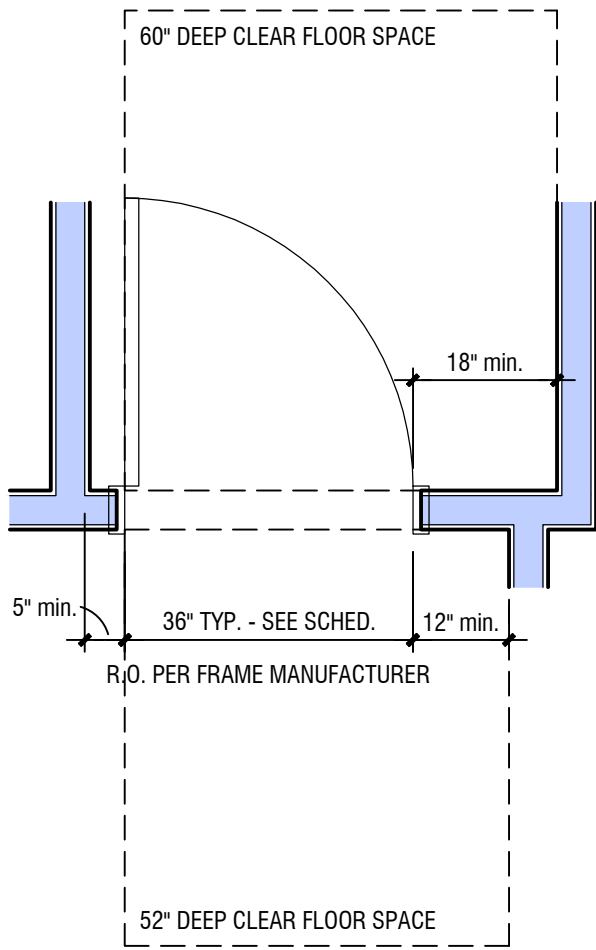







1
A0.1
Typ. Door Framing
scale: 1/2" = 1'-0"

2
A0.1
Deflection track Detail
not to scale

3
A0.1
Partition w/ ACT
scale: 1-1/2" = 1'-0"

4
A0.1
Wall Bracing Detail
scale: 1-1/2" = 1'-0" REQUIRED FOR ALL WALLS WHICH DO NOT EXTEND TO STRUCTURE ABOVE

5
A0.1
Bulkhead Framing Detail
scale: 1-1/2" = 1'-0"

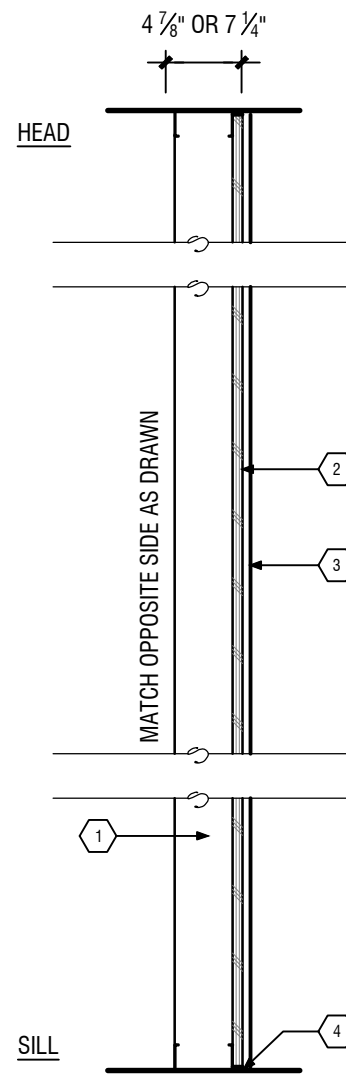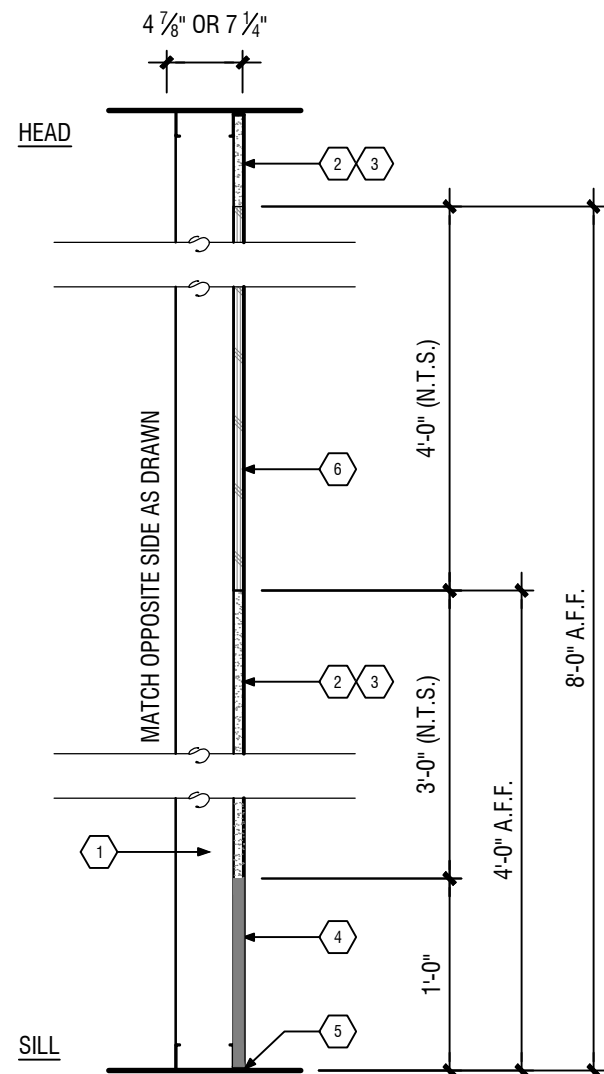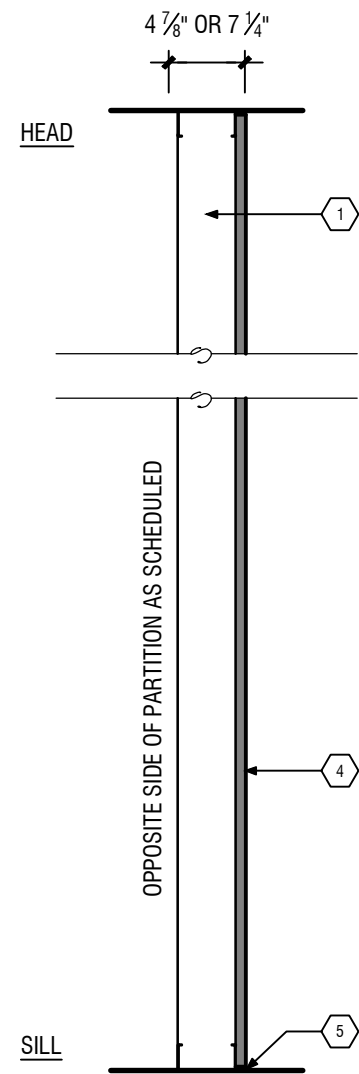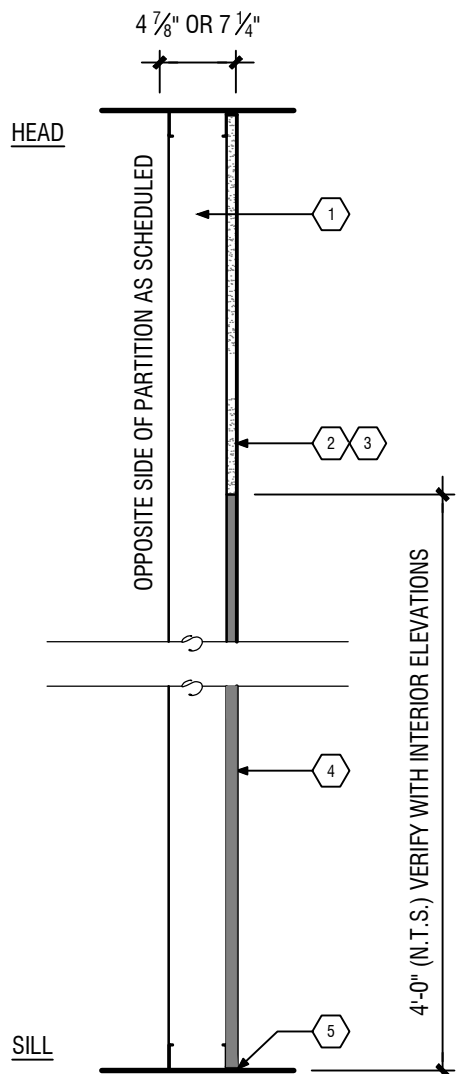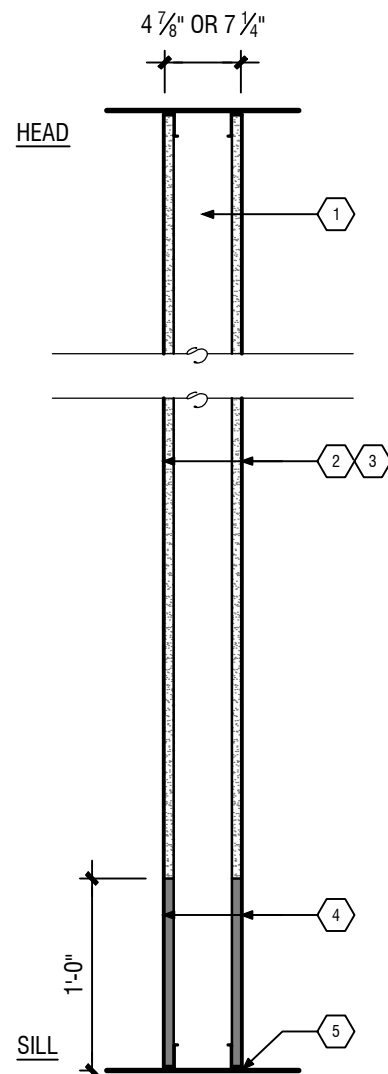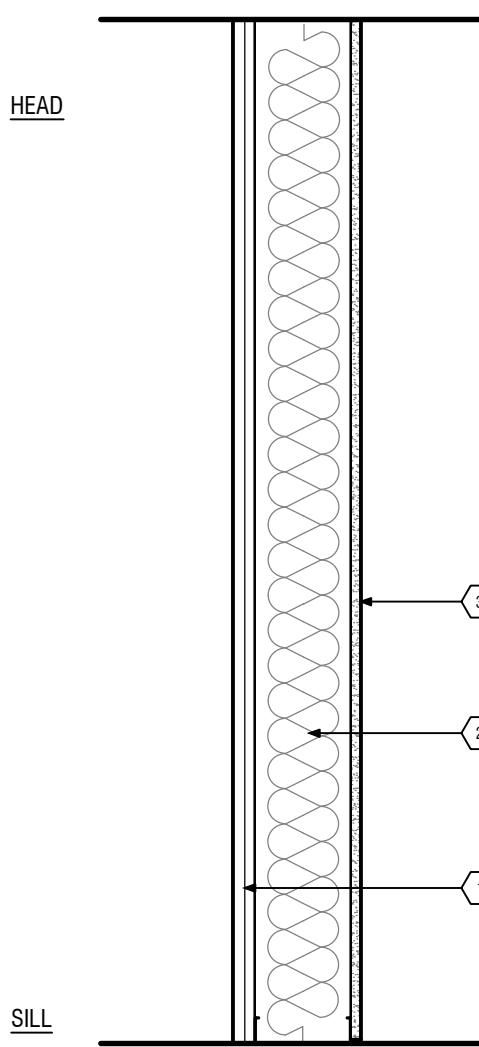

A
A0.1
Existing Exterior Wall
scale: 1" = 1'-0"

B
A0.1
Partition Detail (2 sides*)
scale: 1" = 1'-0"

B2
A0.1
Partition Detail
scale: 1" = 1'-0"

B3
A0.1
Partition Detail
scale: 1" = 1'-0"

C
A0.1
Partition Detail (2 sides*)
scale: 1" = 1'-0"

D
A0.1
Partition Detail (2 sides*)
scale: 1" = 1'-0"

- EXISTING EXTERIOR FINISH TO REMAIN
- EXISTING METAL STUDS W/ INSULATION TO REMAIN
- EXISTING GYPSUM WALL BOARD FINISH TO REMAIN

- METAL STUDS — 20 GAUGE SPACED @ 16 IN. O.C. MAX. FRAME ABOVE SCHEDULED FINISH CEILING AND BRACE TO STRUCTURE ABOVE @ 48" O.C. MAX. -OR- FRAME FULL HEIGHT TO STRUCTURE ABOVE
- GYPSUM BOARD — ONE LAYER 5/8" THICK GYPSUM WALLBOARD APPLIED PARALLEL OR AT RIGHT ANGLES TO EACH SIDE OF 3 3/8" OR 6" STUDS WITH 1" TYPE S DRYWALL SCREWS 8" O.C. AT VERTICAL JOINTS AND 12" O.C. AT TOP AND BOTTOM PLATES AND INTERMEDIATE STUDS. REFER TO PLAN.
- JOINT TAPE AND COMPOUND — (NOT SHOWN) VINYL, DRY OR PREMIXED JOINT COMPOUND, APPLIED TO JOINTS, SCREW HEADS, AND NAIL HEADS (TWO APPLICATIONS); PAPER TAPE EMBEDDED IN FIRST LAYER OF COMPOUND OVER ALL JOINTS.
- CEMENTITIOUS BACKER PANEL BASE — 3/4" THICKNESS TO MATCH GYPSUM BOARD, USE SCREWS COMPATIBLE WITH PRODUCT PER MANUFACTURER'S INSTALLATION INSTRUCTIONS
- CAULKING AND SEALANTS — A BEAD OF ACOUSTICAL SEALANT APPLIED AROUND THE PARTITION PERIMETER FOR SOUND CONTROL

- METAL STUDS — 20 GAUGE SPACED @ 16 IN. O.C. MAX. FRAME ABOVE SCHEDULED FINISH CEILING AND BRACE TO STRUCTURE ABOVE @ 48" O.C. MAX. -OR- FRAME FULL HEIGHT TO STRUCTURE ABOVE
- GYPSUM BOARD — ONE LAYER 5/8" THICK GYPSUM WALLBOARD APPLIED PARALLEL OR AT RIGHT ANGLES TO EACH SIDE OF 3 3/8" OR 6" STUDS WITH 1" TYPE S DRYWALL SCREWS 8" O.C. AT VERTICAL JOINTS AND 12" O.C. AT TOP AND BOTTOM PLATES AND INTERMEDIATE STUDS. REFER TO PLAN.
- JOINT TAPE AND COMPOUND — (NOT SHOWN) VINYL, DRY OR PREMIXED JOINT COMPOUND, APPLIED TO JOINTS, SCREW HEADS, AND NAIL HEADS (TWO APPLICATIONS); PAPER TAPE EMBEDDED IN FIRST LAYER OF COMPOUND OVER ALL JOINTS.
- CEMENTITIOUS BACKER PANEL BASE — 3/4" THICKNESS TO MATCH GYPSUM BOARD, USE SCREWS COMPATIBLE WITH PRODUCT PER MANUFACTURER'S INSTALLATION INSTRUCTIONS
- CAULKING AND SEALANTS — A BEAD OF ACOUSTICAL SEALANT APPLIED AROUND THE PARTITION PERIMETER FOR SOUND CONTROL

- METAL STUDS — 20 GAUGE SPACED @ 16 IN. O.C. MAX. FRAME ABOVE SCHEDULED FINISH CEILING AND BRACE TO STRUCTURE ABOVE @ 48" O.C. MAX. -OR- FRAME FULL HEIGHT TO STRUCTURE ABOVE
- not used
- JOINT TAPE AND COMPOUND — (NOT SHOWN) VINYL, DRY OR PREMIXED JOINT COMPOUND, APPLIED TO JOINTS, SCREW HEADS, AND NAIL HEADS (TWO APPLICATIONS); PAPER TAPE EMBEDDED IN FIRST LAYER OF COMPOUND OVER ALL JOINTS.
- CEMENTITIOUS BACKER PANEL — 3/4" THICKNESS TO MATCH GYPSUM BOARD, USE SCREWS COMPATIBLE W/ PRODUCT PER MANUFACTURER'S INSTALLATION INSTRUCTIONS
- CAULKING AND SEALANTS — A BEAD OF ACOUSTICAL SEALANT APPLIED AROUND THE PARTITION PERIMETER FOR SOUND CONTROL

- METAL STUDS — 20 GAUGE SPACED @ 16 IN. O.C. MAX. FRAME ABOVE SCHEDULED FINISH CEILING AND BRACE TO STRUCTURE ABOVE @ 48" O.C. MAX. -OR- FRAME FULL HEIGHT TO STRUCTURE ABOVE
- GYPSUM BOARD — ONE LAYER 5/8" THICK GYPSUM WALLBOARD APPLIED PARALLEL OR AT RIGHT ANGLES TO EACH SIDE OF 3 3/8" OR 6" STUDS WITH 1" TYPE S DRYWALL SCREWS 8" O.C. AT VERTICAL JOINTS AND 12" O.C. AT TOP AND BOTTOM PLATES AND INTERMEDIATE STUDS. REFER TO PLAN.
- JOINT TAPE AND COMPOUND — (NOT SHOWN) VINYL, DRY OR PREMIXED JOINT COMPOUND, APPLIED TO JOINTS, SCREW HEADS, AND NAIL HEADS (TWO APPLICATIONS); PAPER TAPE EMBEDDED IN FIRST LAYER OF COMPOUND OVER ALL JOINTS.
- CEMENTITIOUS BACKER PANEL BASE — 3/4" THICKNESS TO MATCH GYPSUM BOARD, USE SCREWS COMPATIBLE WITH PRODUCT PER MANUFACTURER'S INSTALLATION INSTRUCTIONS
- CAULKING AND SEALANTS — A BEAD OF ACOUSTICAL SEALANT APPLIED AROUND THE PARTITION PERIMETER FOR SOUND CONTROL
- PLYWOOD SHEATHING — 5/8" THICKNESS (FRT NOT REQUIRED PER CONSTRUCTION TYPE).

- METAL STUDS — 20 GAUGE SPACED @ 16 IN. O.C. MAX. FRAME ABOVE SCHEDULED FINISH CEILING AND BRACE TO STRUCTURE ABOVE @ 48" O.C. MAX. -OR- FRAME FULL HEIGHT TO STRUCTURE ABOVE
- PLYWOOD SHEATHING — 5/8" THICKNESS (FRT NOT REQUIRED PER CONSTRUCTION TYPE).
- FINISH MATERIAL PER PLANS
- CAULKING AND SEALANTS — A BEAD OF ACOUSTICAL SEALANT APPLIED AROUND THE PARTITION PERIMETER FOR SOUND CONTROL

15 September 2026
permit


general details & info

A0.1

Biscuit Belly

15483 Panama City Beach Pkwy Ste B
Panama City Beach, FL 32413

insomnia DESIGN

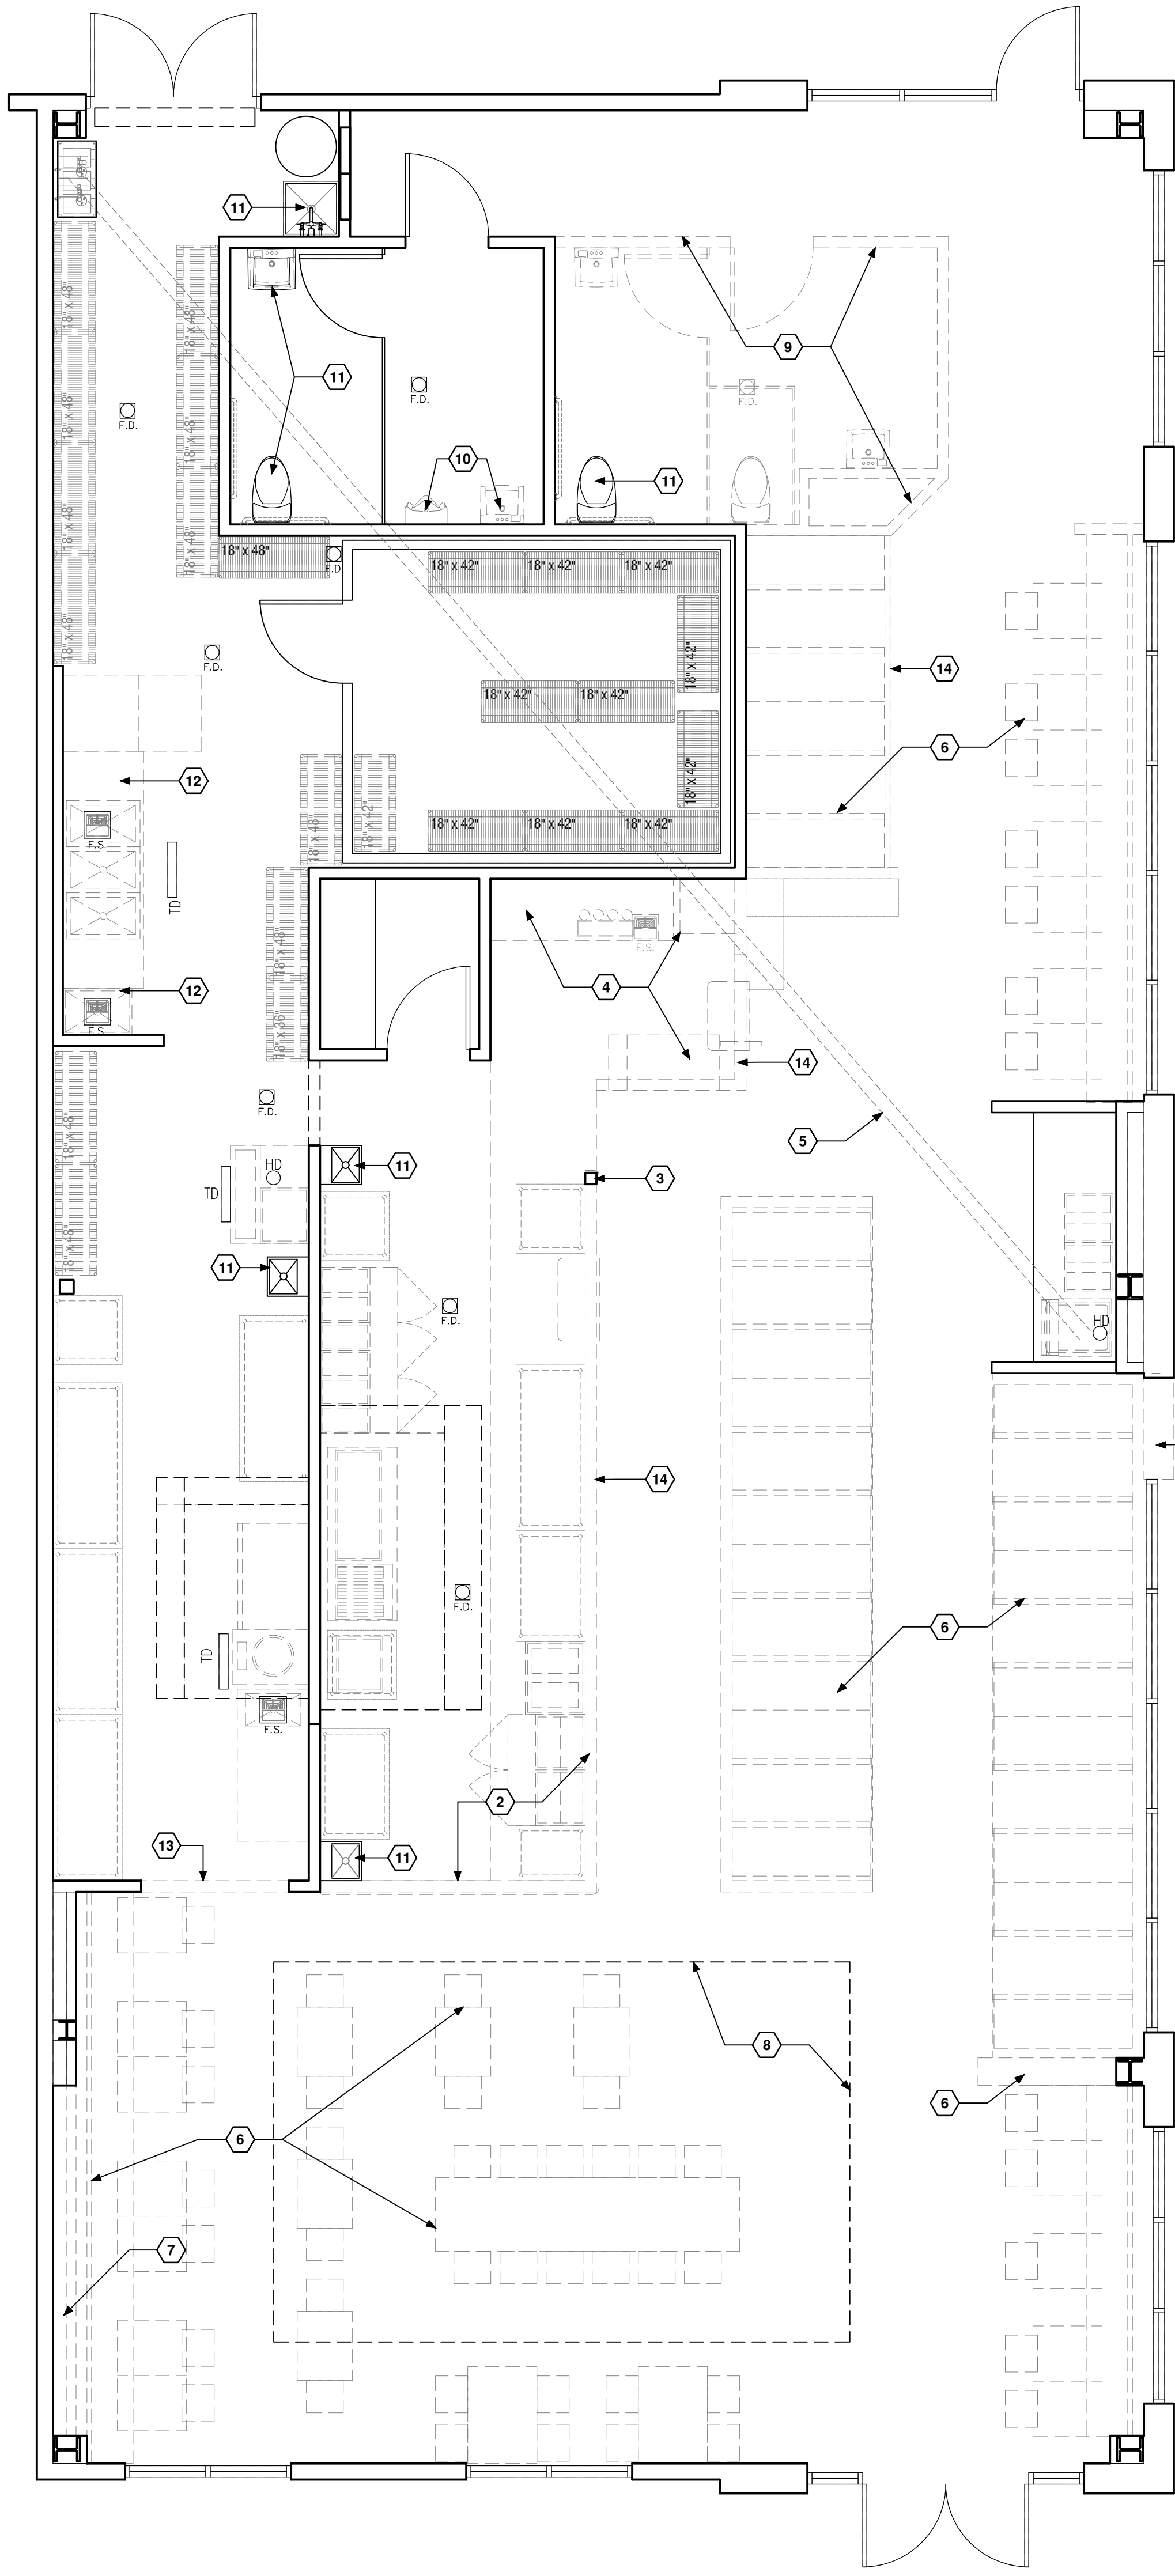


DEMOLITION CODED NOTES

- REMOVE EXISTING STOREFRONT PANEL FOR NEW PLANNED PATIO DOOR. FIELD VERIFY DIMENSIONS OF NEW WORK PLAN PRIOR TO DEMOLITION. WALL IS EXPECTED TO BE NON-STRUCTURAL BASED ON VISIBLE EXPOSED STRUCTURE. CONTACT ARCHITECT IF BEARING WALL CONDITIONS ARE DISCOVERED.
- REMOVE HALF WALL AROUND EXISTING OPEN KITCHEN AREA.
- EXISTING "COLUMN" IS SCHEDULED FOR DEMOLITION. EXPECTATION IS THAT THIS ELEMENT IS A CHASE FOR RUNNING ELECTRIC AND/OR PLUMBING AND IS NOT STRUCTURAL. G.C. SHALL CONFIRM THE PURPOSE OF THE COLUMN IN THE FIELD PRIOR TO REMOVAL. REPORT FINDINGS TO ARCHITECT IF COLUMN IS ACTUALLY STRUCTURAL.
- REMOVE CASEWORK AND HALF WALLS FROM EXISTING SERVICE STATION AREA. REMOVE ANY FLOOR SINKS, PLUMBING, KEG LINES, ETC. AS NEEDED FOR NEW DINING ROOM IN THIS AREA.
- DIAGRAMMATIC LOCATION OF EXISTING SODA LINE CHASE. NOTE THAT BIB, SODA MACHINE, AND CHASE LOCATIONS ARE ALL INTENDED TO BE REUSED AND SHALL BE PROTECTED DURING CONSTRUCTION.
- REMOVE ALL EXISTING FURNITURE, BOOTHS, SEATING PLATFORMS, ETC. AS REQUIRED FOR NEW WORK.
- REMOVE DECORATIVE STONE WALL AND REDUNDANT FRAMING BACK TO EXISTING DEMISING WALL. NOTE THAT ANY DAMAGE TO DEMISING WALL GYP. BOARD SURFACE MUST BE REPAIRED TO MATCH EXISTING CONDITIONS FROM FLOOR TO DECK.
- REMOVE EXISTING SUSPENDED CEILING CLOUD.
- REMOVE INDICATED PORTIONS OF EXISTING RESTROOM IN PREPARATION FOR NEW CONFIGURATION.
- REMOVE EXISTING PLUMBING FIXTURE LOCATION IN PREPARATION FOR NEW CONFIGURATION. NOTE THAT NEW FIXTURES ARE BEING REINSTALLED IN SOME EXISTING LOCATIONS WITH REUSE OF LINES TO GREATEST EXTENT POSSIBLE.
- EXISTING PLUMBING FIXTURE TO REMAIN
- REMOVE EXISTING DISH AREA EQUIPMENT, FLOOR SINKS AND WATER LINES TO REMAIN FOR NEW CONFIGURATION (COORDINATE WITH PLUMBING DRAWINGS).
- REMOVE INDICATED PORTION OF EXISTING WALL FOR NEW INTERIOR WINDOW.
- REMOVE BULKHEAD AND/OR OVERHEAD CEILING FRAMING IN PREPARATION FOR NEW CONFIGURATION.

GENERAL DEMOLITION PLAN NOTES

- ALL ITEMS SHOWN DASHED ARE TO BE REMOVED OR MODIFIED.
- ALL ITEMS SHOWN SOLID ARE EXISTING TO REMAIN UNLESS NOTED OTHERWISE.
- ALL DIMENSIONS SHOWN ON THESE DRAWINGS ARE BASED ON FIELD REVIEWS. DIMENSIONS ARE TO FINISH FACE UNLESS OTHERWISE NOTED. CONTRACTOR TO VERIFY ALL DIMENSIONS.
- ALL EXTERIOR WALLS, DOORS, WINDOWS & ROOF TO REMAIN AS-IS, UNLESS NOTED OTHERWISE
- PROTECT ALL ITEMS TO REMAIN FROM DEMOLITION and CONSTRUCTION
- REMOVE ALL WASTE & DEBRIS FROM SITE & DISPOSE OF IN RESPONSIBLE MANNER
- REMOVE ALL GAS/WATER PIPING ASSOCIATED WITH FIXTURES/DEVICES TO BE REMOVED BACK TO NEAREST JUNCTION and CAP, UNLESS NOTED OTHERWISE
- REMOVE ALL CONDUIT & WIRE ASSOCIATED WITH FIXTURES/DEVICES TO BE REMOVED - COORDINATE w/ ELECTRICAL DRAWINGS FOR MORE INFORMATION
- REQUIRED MEANS OF EGRESS PATH & LIGHTING, 1 MIN. FOOTCANDLE, SHALL BE MAINTAINED AT ALL TIMES DURING THE COURSE OF DEMOLITION and CONSTRUCTION, UNLESS A TEMPORARY MEANS HAS BEEN APPROVED
- CONTRACTOR SHALL ENSURE THAT AT LEAST (1) LIGHTED STAIRWAY IS PROVIDED THROUGH THE COURSE OF CONSTRUCTION.
- ANY TEMPORARY STAIRCASE SHALL BE 36" WIDE MINIMUM, RISERS SHALL BE 4" MIN AND 7" MAX, AND TREADS SHALL BE 11" DEEP MIN.
- 42" h. CONSTRUCTION GUARDS SHALL BE PROVIDED ALONG OPEN-SIDED WALKING SURFACES THAT ARE LOCATED MORE THAN 30" MEASURED VERTICALLY TO THE FLOOR OR GRADE BELOW AT ANY POINT WITHIN 36" HORIZ. TO THE EDGE OF THE OPEN SIDE. GUARDS SHALL BE SUFFICIENT TO DIRECT WORKERS AROUND CONSTRUCTION AREAS.
- COORDINATE REMOVAL OF ROOFING WITH INSTALLATION OF NEW ROOFING IN ALL AREAS. COORDINATE NEW ROOFING TYPES AND INSULATION WITH ARCHITECT.

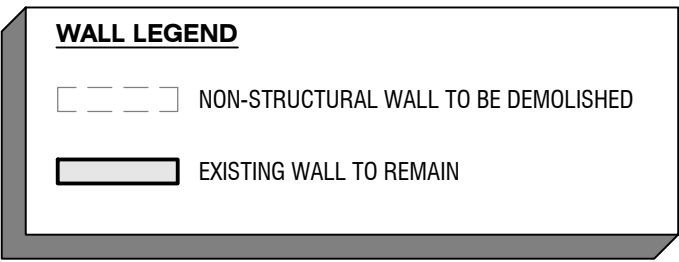

1
A2.0
Existing/Demo Plan
scale: 1/4" = 1'-0"



GENERAL CONSTRUCTION NOTES

- ALL DIMENSIONS ARE ROUGH FRAMING PER SCHEDULED PARTITION U.N.O.
- ALL DIMENSIONS NOTED AS "CLEAR" ARE TO FINISH FACE OF SCHEDULED PARTITION.
- SCHEDULED PARTITION TYPE APPLIES TO ONE SIDE OF WALL ONLY. IF BOTH SIDES OF PARTITION ARE NOT INDICATED, CONTACT ARCHITECT FOR CLARIFICATION.
- DO NOT SCALE DRAWINGS - WRITTEN DIMENSIONS GOVERN. CONSULT THE ARCHITECT IN CASE OF CONFLICT.
- CONTRACTOR SHALL REMEDY, WITHOUT COST TO TENANT, ANY DEFECTS DUE TO FAULTY WORKMANSHIP.
- COORDINATE ALL WORK w/ MEP & SPECIALTY CONSULTANT DRAWINGS.
- CONTRACTOR SHALL COORDINATE WORK OF VARIOUS TRADES IN INSTALLATION OF INTERRELATED WORK. BEFORE INSTALLATION OR WORK BY ANY TRADE BEGINS, MAKE PROPER PROVISIONS TO AVOID INTERFERENCES.
- WORK ASSOCIATED w/ INDEPENDENT PERMIT PACKAGES SHALL BE SCHEDULED & COORDINATED BY CONTRACTOR.
- CONTRACTOR SHALL SUBMIT SHOP DRAWINGS TO ARCHITECT FOR REVIEW.
- CONTRACTOR SHALL SUBMIT PRODUCT & FINISH SELECTION INFORMATION TO ARCHITECT FOR REVIEW.
- USE TYPE-X GYPSUM BOARD ON ALL PARTITIONS UNLESS NOTED OTHERWISE.
- CONTRACTOR SHALL VISIT THE JOB SITE AND VERIFY ALL EXISTING CONDITIONS PRIOR TO ORDERING MATERIALS OR BEGINNING WORK. ANY DISCREPANCIES SHALL BE BROUGHT TO THE ATTENTION OF THE ARCHITECT FOR RESOLUTION.
- FLOOR SURFACES SHALL BE LEVEL TO ASSURE SMOOTH SURFACE FOR FINISHED FLOOR INSTALLATION.
- SUBMIT REQUESTS FOR SUBSTITUTIONS, REVISIONS, OR CHANGES TO ARCHITECT FOR REVIEW PRIOR TO PURCHASE, FABRICATION, OR INSTALLATION.
- ALL MATERIALS, PRODUCTS AND SYSTEMS SHALL BE INSTALLED IN ACCORDANCE WITH THE MANUFACTURER'S REQUIREMENTS, RECOMMENDATIONS AND SPECIFICATIONS.
- CONTRACTOR SHALL COORDINATE AND PROVIDE SOLID WOOD BLOCKING IN STUD WALLS AS REQUIRED TO SUPPORT WALL-MOUNTED CABINETRY, SHELVING, COUNTERS, HANDRAILS, WINDOW/DOOR FRAMES, TRIM, AND ALL OTHER MILLWORK.
- ALL CEILINGS AND SOFFITS ARE INTENDED TO BE FRAMED WITH METAL FRAMING SUCH AS USG SUSPENDED DRYWALL CEILING SYSTEM OR OTHER METAL SYSTEMS - COORDINATE w/ ARCHITECT.
- PROVIDE SOUND ATTENUATING BATT INSULATION AT ALL WALLS AROUND MECHANICAL CLOSETS, PLUMBING STACKS, DISHTANK & RESTROOMS AS INDICATED ON PLAN.
- INSULATING MATERIALS SHALL HAVE A FLAME SPREAD INDEX NOT MORE THAN 25 AND A SMOKE DEVELOPMENT INDEX NOT MORE THAN 450.
- CONTRACTOR IS RESPONSIBLE FOR ALL FLOOR AND WALL PENETRATIONS FOR ELECTRICAL AND MECHANICAL WORK. SUCH OPENINGS SHALL BE FRAMED AND REINFORCED.
- THE CONTRACTOR SHALL SUPPLY ALL MATERIALS, LABOR AND COORDINATION REQUIRED FOR THE INSTALLATION OF ALL OWNER SUPPLIED ITEMS (FURNITURE, LIGHTING AND ARTWORK) UNLESS OTHERWISE NOTED.
- PROVIDE PORTABLE FIRE EXTINGUISHERS WITHIN 30 FEET OF COMMERCIAL EQUIPMENT AND ELSEWHERE AS REQUIRED BY ICC SECTION 906 AND THE INTERNATIONAL FIRE CODE - LOCATE IN THE FIELD WITH FIRE MARSHALL.
- JAMBS AT HINGE SIDE OF DOOR OCCUR 4" FROM INSIDE CORNER, UNLESS DIMENSIONED OTHERWISE.
- REFER TO ELECTRICAL PLANS FOR EXIT SIGNAGE, EMERGENCY LIGHTING, AND EGRESS LIGHTING.
- ALL EXTERIOR WALLS, WINDOWS, AND DOORS ARE EXISTING TO REMAIN U.N.O.

DOOR SCHEDULE

	LOCATION	SIZE	TYPE	DOOR MATERIAL	DOOR FINISH	FRAME MATERIAL	FRAME FINISH	HARDWARE	CLOSER	RATING	COMMENT	
101-A	DINING ROOM	(2) 3'-0" x 8'-0"	A	EXISTING STOREFRONT DOOR w/ KEYPED CYLINDER LOCK AND PUSH/PULL BARS TO REMAIN					YES	---	PROVIDE SIGN INDICATING "THIS DOOR TO REMAIN UNLOCKED WHEN THIS SPACE IS OCCUPIED" IN 1" TALL LETTERS ON CONTRASTING BACKGROUND PER 1010.2.4.3	
101-B	DINING ROOM	3'-0 x 8'-0"	A	STOREFRONT	ANODIZED (T.M.E.)	STOREFRONT	ANODIZED (T.M.E.)	PANIC	YES	---	NEW DOOR TO MATCH EXISTING STOREFRONT FINISH AND DOOR HEIGHT	
101-C	DINING ROOM	3'-0 x 8'-0"	A	EXISTING STOREFRONT DOOR TO REMAIN					PANIC	YES	---	G.C. TO EVALUATE EXISTING DOOR HARDWARE AND REPLACE w/ PANIC IF NOT EXISTING
106-A	BACK DOOR	6'-0" x 7'-0"	A	EXISTING STEEL DOORS WITH PANIC HARDWARE TO REMAIN					YES	---		
107-A	OFFICE	3'-0" x 7'-0"	A	EXISTING WOOD	PAINT P-2	EXISTING STEEL	PAINT P-6	CLASSROOM	---	---	REPLACE EXISTING HARDWARE WITH NEW KEYPED LEVER HANDLE SET	
109-A	RESTROOM	3'-0" x 7'-0"	B	WOOD	PLASTIC LAMINATE	2" KNOCK DOWN STEEL	PAINTED P-6	SET 2	YES	---	NEVAMAR WM2640T, PLANETREE MAPLE LAMINATE	
110-A	RESTROOM	3'-0" x 7'-0"	B	WOOD	PLASTIC LAMINATE	EXISTING STEEL	PAINTED P-6	SET 2	YES	---	NEVAMAR WM2640T, PLANETREE MAPLE LAMINATE	

STEEL DOOR FRAMES

- SERIES DU KNOCK DOWN STEEL FRAMES AS MANUFACTURED BY CECO DOOR, IN STYLES AND PROFILES AS SHOWN, USING CONCEALED FASTENERS.
 - MINIMUM THICKNESS: 16 GAUGE.
 - CONSTRUCTION: KNOCK DOWN.
 - HINGE REINFORCEMENT: 7 GAUGE.
 - STRIKE REINFORCEMENT: 16 GAUGE.
 - SURFACE CLOSER REINFORCEMENT: 14 GAUGE.
- DOOR SILENCERS: DRILL STOPS TO RECEIVE SILENCERS, B.H.M.A. L03011; INSERT TYPE SIMILAR TO GLYNN-JOHNSON GJ64. PROVIDE 3 SILENCERS ON STRIKE JAMBS OF SINGLE SWING FRAMES.
- VERIFY ALL LOCAL CODES REQUIREMENTS AND PROVIDE FIRE RATED DOORS & FRAMES AS REQD.
- CONFORM TO NFPA 80, UL-108 AT FIRE RATED DOOR AND FRAME ASSEMBLIES.
- 18 GAUGE, GRADE II, HEAVY DUTY, MODEL 2, STEEL STIFFENED FULL FLUSH DOORS ASTM A366 OR A568 COLD-ROLLED GALVANIZED STEEL. VOID AREAS BETWEEN STIFFENERS ARE TO BE FILLED WITH FIBERGLASS AT EXTERIOR DOOR CONDITIONS.
- PRIME ALL HOLLOW METAL DOORS & COAT BACKSIDE OF FRAMES w/ BITUMINOUS PAINT WHEN IN POTENTIAL CONTACT w/ CEMENTITIOUS MATERIALS.
- PROVIDE METAL PLATE REINFORCEMENT AS REQUIRED FOR HARDWARE.

WOOD DOORS

- INDUSTRY STANDARD FOR WOOD DOORS NWMA 1.5.1.
- PROVIDE 1 3/4", SOLID CORE, LAMINATE FINISH.
- ALL DOORS SHALL RECEIVE PLASTIC LAMINATE AS SPECIFIED.
- CORE: PARTICLEBOARD BONDED TO STILES AND RAILS, SANDED.
- ACCEPTABLE MANUFACTURERS INCLUDE: ALGOMA, HARDWOODS, EGGERS INDUSTRIES, FINESTRA CORPORATION, WEYERHAEUSER COMPANY OR EQUAL.
- AT TOILET ROOMS, UNDERCUT DOOR(S) 1/2" ABOVE FINISH FLOOR.


HARDWARE SETS

SET 1: STOREFRONT (STOREFRONT MANUFACTURERS STANDARD)

- | | | | | |
|---|---|-------------------------|--|--|
| 1 | WEATHER STRIPPING | | | |
| 1 | THRESHOLD (SET IN SOLID GROUT), 324 | NATIONAL GUARD PRODUCTS | | |
| 1 | FULL WIDTH PUSH BAR (PANIC) | | | |
| 1 | ADA COMPLIANT PULL HANDLE | | | |
| 1 | CLOSER PER DOOR (COORDINATE WITH STOREFRONT MANUFACTURER) | | | |

SET 2: RESTROOM (PRIVACY)

- | | | | | |
|---|---------------|-------|-------------------------|-------|
| 3 | HINGE | HAGER | 6B1279 4-1/2" x 4-1/2" | US26D |
| 3 | DOOR SILENCER | HAGER | 307D | |
| 1 | DEADLOCK | HAGER | 3216 | US26D |
| 1 | DOOR PULL | HAGER | 336 - 4"x16" CFC 2 1/2" | US26D |
| 1 | PUSH PLATE | HAGER | 305 - 4"x16" | US26D |
| 1 | CLOSER | HAGER | 5100 MLT ALM FC | ALM |
| 1 | WALL STOP | HAGER | 236W | US26D |
- NOTE THAT RESTROOM LOCK IS AN ADA COMPLIANT THUMBTURN DEADBOLT WITH AN OCCUPANCY INDICATOR. THERE IS TO BE NO LATCH ON THESE DOORS.

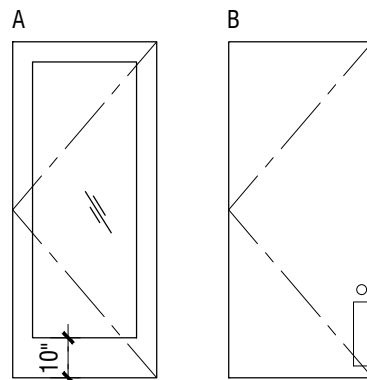

CONSTRUCTION CODED NOTES

- EXISTING WALK-IN REFRIGERATOR TO REMAIN: DOORS SHALL BE READILY OPENABLE FROM THE EGRESS SIDE WITHOUT THE USE OF A KEY OR SPECIAL KNOWLEDGE OR EFFORT. G.C. TO EVALUATE CONDITION OF ALL COMPONENTS DURING CONSTRUCTION TO ENSURE PROPER OPERATION BY SCHEDULED STORE TRAINING.
- EXISTING TYPE-I HOOD VENTED TO EXTERIOR - NO COMBUSTIBLES WITHIN 18" IN PLAN OR ELEVATION, INCLUDING DUCTWORK, SEE REFLECTED CEILING PLAN AND MECHANICAL DRAWINGS FOR MORE INFO.
- EXTERIOR DOOR WITH LEVEL LANDING TO REMAIN.
- SELF-SERVE SODA STATION: PROVIDE WATER & DRAIN LINE TO BEVERAGE EQUIPMENT - COORDINATE w/ GREASE TRAP REQUIREMENTS AND PLUMBING DRAWINGS. PROVIDE CLOSED WALL FRAMING AT OPEN END NEAR STOREFRONT. SEE INTERIOR ELEVATION/DETAIL FOR MORE INFORMATION.
- CARRY-OUT ORDER SHELF, REFER TO EQUIPMENT & FURNITURE PLAN.
- BABY CHANGING TABLE, REFER TO ENLARGED RESTROOM PLAN.
- BENCH FASTENED TO FLOOR PER MANUFACTURER'S INSTALLATION INSTRUCTIONS. SEE DETAIL ON SHEET A3.3 AND EQUIPMENT PLAN FOR LAYOUT AND ORDERING INFORMATION.
- G.C. TO INCLUDE WALK-IN COOLER EQUIPMENT STARTUP IN THEIR SCOPE.
- ACCESSIBLE SIGNAGE FOR UNISEX RESTROOMS SHALL BE PROVIDED @ RESTROOMS ON THE WALL NEXT TO THE LATCH SIDE OF DOOR. THE RAISED CHARACTERS SHALL BE 48" MIN. ABOVE THE FLOOR, MEASURED TO THE BASELINE OF THE LOWEST RAISED CHARACTER & 60" MAX. ABOVE THE FLOOR, MEASURED TO THE BASELINE OF THE HIGHEST RAISED CHARACTER.
- FRAMED HALF WALL - SEE INTERIOR ELEVATIONS & DETAILS FOR MORE INFO.
- NEW DOOR IN EXTERIOR WALL THAT IS ANTICIPATED TO BE NON-STRUCTURAL. COORDINATE WITH ARCHITECT IF BEARING WALL CONDITIONS ARE DISCOVERED. EXTERIOR TRIM TO MATCH EXISTING. PROVIDE ADA THRESHOLD WITH LEVEL LANDING ON EACH SIDE.
- EXISTING SIDEWALK AND PATIO TO REMAIN - SEE A2.6 FOR PATIO FURNITURE PLAN

WALL LEGEND

- EXISTING WALL TO REMAIN
- NEW WALL FRAMING - SEE PARTITION SCHEDULE FOR CONSTRUCTION

 
- X SEE A0.2 FOR PARTITION TYPE INFORMATION


ADDITIONAL FRAMING NOTES:

- MOISTURE RESISTANT GYP. BOARD TO BE USED AT WET AREAS
- SEE SHEET A0.1 FOR FRAMING DETAILS
- P.T. WOOD SHALL BE USED WHEN IN CONTACT WITH CONCRETE
- SEE FOOD SERVICE DRAWINGS FOR WALL BLOCKING REQUIREMENTS AND LOCATIONS

1 Ground Floor Plan

scale: 1/4" = 1'-0"



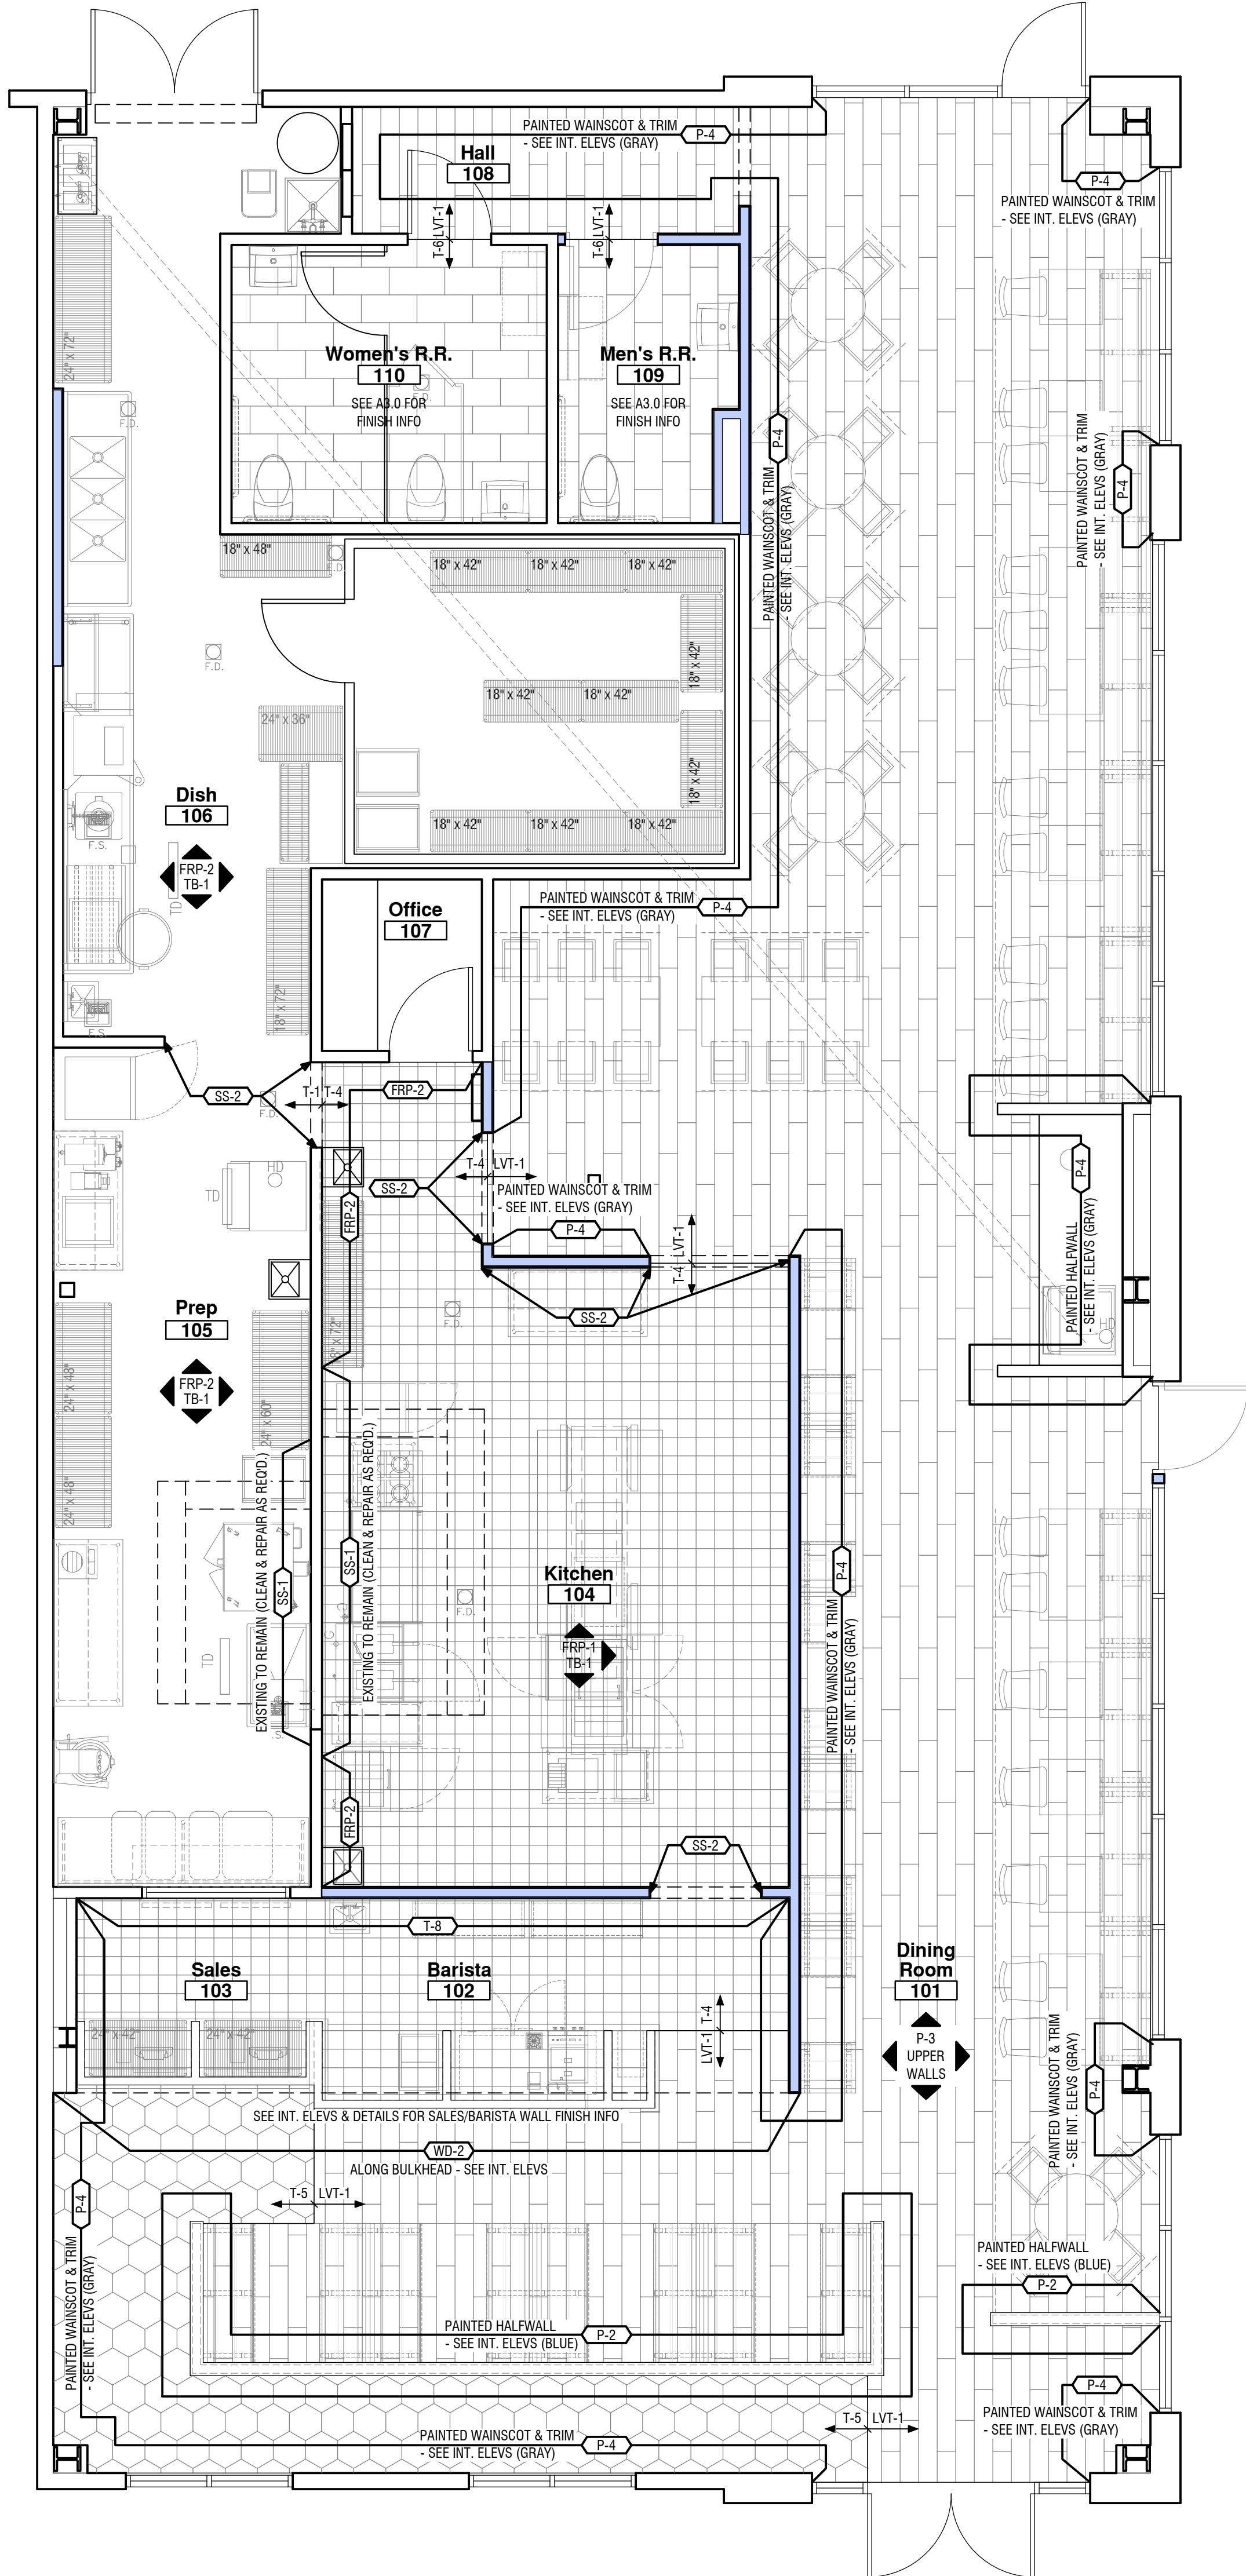

INTERIOR FINISH NOTES

- a. TYPICAL FINISHES INDICATED WITHIN ROOM U.N.O. - REFER TO FINISH SCHEDULE FOR SPECIFICATION INFORMATION. REFER TO INTERIOR ELEVATIONS FOR SPECIFIC FINISH LOCATIONS, MATERIAL ORIENTATION, PATTERNS, LAYOUTS, ETC.
- b. ALL WALL SURFACES TO BE PAINTED TYPE "X" GYP. BOARD U.N.O.
- c. ALL INTERIOR WALL CEILING FINISHES SPECIFIED SHALL NOT BE LESS THAN CLASS "C"
- d. ALL JOINTS BETWEEN MATERIALS TO BE TIGHT AND CONSTRUCTED IN A NEAT, WORKPERSON-LIKE MANNER.
- e. ABSOLUTELY NO SUBSTITUTIONS WILL BE PERMITTED FOR SPECIFIED MATERIALS UNLESS WRITTEN APPROVAL IS OBTAINED FROM OWNER OR ARCHITECT PRIOR TO ORDERING.
- f. CONTRACTOR SHALL BE RESPONSIBLE FOR PROPER PREPARATION OF ALL NEW AND EXISTING SURFACES IN A SATISFACTORY MANNER TO RECEIVE NEW FINISHES. THIS INCLUDES THE DEMOLITION & REMOVAL OF NECESSARY ITEMS. TOUCH-UP and/or REFINISH OF SURFACES DAMAGED BY SUBSEQUENT WORK SHALL BE THE RESPONSIBILITY OF THE GENERAL CONTRACTOR. ALL WORK SHALL BE PERFORMED IN CONFORMANCE WITH THE MANUFACTURER'S RECOMMENDED INSTALLATION METHODS. THE GENERAL CONTRACTOR SHALL PREPARE THE EXISTING FLOOR PRIOR TO THE APPLICATION OF FINISH FLOORING.
- g. THE FLOORING SUB-CONTRACTOR IS RESPONSIBLE FOR VERIFYING THAT THE CONDITION OF THE BASE FLOOR MEETS THE INSTALLATION SPECIFICATIONS PRIOR TO THE INSTALLATION OF NEW FLOORING MATERIAL.
- h. ALL FLOOR COVERING MATERIALS TO BE INSTALLED PER MANUFACTURER'S STANDARD DETAILS AND SPECIFICATIONS. VERIFY W/ MANUFACTURER PRIOR TO INSTALLATION.
- i. FINISH FLOORING APPLICATION SHALL BE IN CONFORMANCE WITH MANUFACTURER'S RECOMMENDED INSTALLATION GUIDELINES.
- j. ALL FLOOR MATERIAL TRANSITIONS AT DOOR THRESHOLDS TO TAKE PLACE AT DOOR CENTERLINE.
- k. THE G.C. IS RESPONSIBLE FOR PROVIDING A SMOOTH LEVEL FLOOR SURFACE THAT MEETS THE MANUFACTURER'S INSTALLATION SPECIFICATIONS PRIOR TO THE INSTALLATION OF ALL FLOORING MATERIALS. USE LEVELING COMPOUND UNDER TILE AND CARPET AREAS. PATCH/SHIM ALL AREAS AS NECESSARY SO THAT NEW FLOORING MEETS LEVEL WITH ALL OTHER FLOORING SURFACES MAX SLOPE OF 1:20.
- l. GENERAL CONTRACTOR TO MAINTAIN EXISTING FINISH OF ALL EXPOSED STRUCTURE THAT WILL NOT HAVE AN ENCLOSED CEILING CONSTRUCTED.
- m. ALL JOINTS IN GYPSUM BOARD WALLS SHALL BE FINISHED WITH PAPER TAPE 2" WIDE AND THREE COATS OF JOINT COMPOUND. ALL OUTSIDE CORNERS SHALL BE FINISHED WITH METAL CORNER BEADS, TAPED AND SPACKLED. ALL AREAS TO BE PAINTED SHALL BE SANDED SMOOTH. JUST PRIOR TO THE APPLICATION OF PAINT, WIPE SANDED SURFACES WITH A DAMP CLOTH IN ORDER TO LAY FLAT ANY NAP WHICH MAY HAVE FORMED IN SANDING.
- n. GYPSUM WALLBOARD: INDICATED THICKNESS(ES) BY 48 or 60 IN. WIDTH BY LENGTHS AS REQUIRED, TAPERED EDGE. PAPER FINISH, CONFORMING TO ASTM C86. TYPE "X" FIRE RESISTANT BOARD SHALL BE USED UNLESS OTHERWISE SPECIFIED FOR RATED ASSEMBLY. MOISTURE RESISTANT GYPSUM WALL BOARD SHALL BE USED AT TOILET ROOMS AND KITCHEN AREAS AS INDICATED ON DRAWINGS.
- o. ALL FINISHES SHALL BE TOUCHED UP TO CORRECT ANY IMPERFECTIONS AFTER INSTALLATION.
- p. THE PAINT CONTRACTOR SHALL REMOVE ALL HARDWARE, SWITCH COVERS, ETC. PRIOR TO PAINTING AND BE RESPONSIBLE FOR THE REINSTALLATION AFTER PAINTING IS COMPLETED.
- q. ALL SURFACES WHICH ARE TO RECEIVE A PAINT FINISH SHALL BE PRIMED.
- r. PAINT TO BE AS SPECIFIED PER NATIONAL ACCOUNT INCLUDING SHEEN, NO EXCEPTIONS.
- s. INSTALL CLEAR SEALANT AROUND ALL FOOD SERVICE EQUIPMENT AND AT ANY MISCELLANEOUS GAPS TO MEET HEALTH DEPARTMENT INSPECTION.
- t. WOOD BLOCKING FOR SUPPORT OF FIXTURES, ACCESSORIES ETC. SHALL BE CONSTRUCTION AND/OR STANDARD GRADE SPF.
- u. CONTRACTOR TO COORDINATE ALL EQUIPMENT RELATED PLUMBING AND FLOOR DRAIN LOCATIONS WITH CABINERY DESIGN AND EQUIPMENT REQUIREMENTS.
- v. PROVIDE WOOD BASE IN ALL AREAS VISIBLE TO CUSTOMERS. REVIEW EXTENT OF WOOD BASE w/ ARCHITECT AND TENANT IF QUESTIONS ARISE.
- w. PROVIDE SUBMITTAL FOR BASE MATERIAL WHERE WALL FINISH IS FRP.
- x. AREAS WITH STAINLESS STEEL WALL PANELS SHALL BE INSTALLED/SEALED TIGHT TO FINISH FLOOR SURFACE
- y. AREAS WITH WALL TILE SHALL BE INSTALLED/SEALED TIGHT TO FINISH FLOOR SURFACE WITH SCHLUTER DILEX-AHK COVE TRIM TO MATCH GROUT COLOR
- z. REFER TO REFLECTED CEILING PLAN FOR CEILING AND OVERHEAD FINISHES.

CONTACT INFO

1

TILE
LOUISVILLE TILE
NATIONAL ACCOUNTS
4520 BISHOP LANE
LOUISVILLE, KY 40218
(502) 664-9230
nationalaccounts@loutile.com

2

LVT FLOORING
AMY CAPPEL
COMMERCIAL BUSINESS MANAGER
KARNDEN COMMERCIAL
1100 PONTIAC COURT
EXPORT, PA 15632
(614) 563-6256
amy.cappel@karndean.com

3

HERRINGBONE PANELING
JOSH PETERS
OPEN GRAIN WOODWORK
(502) 639-5916
josh@opengrain.com

- FINISH LEGEND
- ACT = ACOUSTIC CEILING TILE
 - BA = BASE
 - BR = BRICK
 - CA = CASING
 - CH = CHAIR
 - CNT = COUNTERTOP
 - CON = CONCRETE
 - F = FABRIC
 - FRP = FIBERGLASS REINFORCED PANEL
 - GL = GLASS
 - GR = GROUT
 - LVT = LUXURY VINYL TILE
 - M = METAL
 - MIR = MIRROR
 - P = PAINT
 - QT = QUARRY TILE
 - SS = STAINLESS STEEL
 - SSU = SOLID SURFACE
 - ST = STONE
 - TBL = TABLE
 - T = TILE
 - TB = TILE BASE
 - VB = VINYL OR RUBBER BASE
 - WD = WOOD

MATERIAL LEGEND (AREAS BELOW ARE ACTUAL & DON'T INCLUDE WASTE FACTOR)

T-4 TB-1 581 SQ. FT.
QUARRY TILE FLOORING w/ COORDINATING COVE BASE
- SEE SCHEDULE FOR MORE INFORMATION

LVT-1 1488 SQ. FT.
DINING ROOM FLOORING
- 7"x40" PLANK, 1/3 OFFSET RUNNING
BOND IN DIRECTION SHOWN

T-5 175 SQ. FT.
QUEUE TILE FLOORING
- SEE PATTERN DEPICTION BELOW

T-6 114 SQ. FT. + .62 SQ. FT.
BATHROOM TILE FLOORING
- RUNNING BOND PATTERN

FINISH SCHEDULE (see cover sheet for fire class requirements)		
	KEY	DESCRIPTION
	WC-1	CUSTOM VINYL WALL COVERING WITH ROLLING PIN GRAPHIC - PROVIDE LEVEL 4 GYP BOARD FINISH. COORDINATE SOURCE WITH OWNER.
	WC-2	CUSTOM SHIMMER WALL PAVING BY OWNER - PROVIDE BLOCKING FOR MOUNTING
	WC-3	CUSTOM VINYL WALL COVERING TBD - PROVIDE LEVEL 4 GYP BOARD FINISH. COORDINATE SOURCE WITH OWNER.
ACT	ACT-1	USG SIZE: 24" x 24" x 1/2"; SCRUBBABLE. SHEETROCK LAY-IN CEILING PANEL CLIMAPLUS #3270, FLAT WHITE 050, USG DX/DXL ALUMINUM 15/16" SUSPENSION GRID, FLAT WHITE 050 (CLEANABLE AND SCRUBBABLE)
	ACT-2	USG SIZE: 24" x 24" x 5/8"; WHITE. RADAR CLIMAPLUS CEILING PANEL #2210, 15/16" SUSPENSION GRID, GRID COLOR TO MATCH TILE COLOR, USG DX/DXL ALUMINUM
	ACT-3	T.B.O. DECORATIVE 24" x 24" CEILING TILE TO BE SELECTED
BASE	BA-1	1x6 WOOD BASE. PAINTED FINISH AS SCHEDULE -AND- PRE-FINISHED 3/4" QUARTER ROUND WHITE OAK SHOW MOLDING
	TB-1	TILE BASE TO BE SELECTED
	VB-1	4" RUBBER COVE BASE, BLACK
FRP	FRP-1	MARLITE CLASS III/C. SMOOTH FINISH, COLOR P-100 WHITE or EQUAL - INSTALL FULL HEIGHT WHERE APPLIED TO WALLS
	FRP-2	existing THROUGHOUT EXISTING KITCHEN SPACES TO REMAIN. CLEAN AND REPAIR OF EXISTING FRP IS THE INTENT. G.C. REVIEW SPECIFICS WITH OWNER IN FIELD. IF REPLACEMENT IS NEEDED, USE FRP-1 SPEC
METAL	SS-1	STAINLESS STEEL WALL PANELS
	SS-2	STAINLESS STEEL CORNER GUARDS @ ALL OUTSIDE EMPLOYEE AREA CORNERS, TYP., 8FT A.F.F. 16GA MINIMUM
PAINT	P-1	not used
	P-2	SHERWIN WILLIAMS BISCUIT BELLY PATRIOT BLUE (BLUE) CUSTOM COLOR PER NATIONAL ACCOUNT, EMERALD URETHANE TRIM ENAMEL CABINET PAINT
	P-3	SHERWIN WILLIAMS BISCUIT BELLY CHANTILLY LACE (WHITE) CUSTOM COLOR PER NATIONAL ACCOUNT, PROMAR 200 ZERO VOC INTERIOR LATEX EG-SHEL
	P-4	SHERWIN WILLIAMS BISCUIT BELLY INTELLECTUAL GRAY (GRAY) CUSTOM COLOR PER NATIONAL ACCOUNT, EMERALD URETHANE TRIM ENAMEL CABINET PAINT
	P-5	SHERWIN WILLIAMS BISCUIT BELLY MATCH TO BEHR WATERMELON SLICE #P180-5 (CORAL) CUSTOM COLOR PER NATIONAL ACCOUNT, PROMAR 200 ZERO VOC INTERIOR LATEX EG-SHEL
	P-6	SHERWIN WILLIAMS BISCUIT BELLY POOLSIDE BLUE (TEAL), CUSTOM COLOR PER NATIONAL ACCOUNT, PROMAR 200 ZERO VOC INTERIOR LATEX EG-SHEL
	P-7	SHERWIN WILLIAMS #SW6991 BLACK MAGIC SEMI-GLOSS FINISH
	P-8	SHERWIN WILLIAMS BISCUIT BELLY MIMOSA (YELLOW) CUSTOM COLOR PER NATIONAL ACCOUNT, PROMAR 200 ZERO VOC INTERIOR LATEX EG-SHEL
	P-9	SHERWIN WILLIAMS BISCUIT BELLY MIMOSA (YELLOW) CUSTOM COLOR PER NATIONAL ACCOUNT, PROMAR 200 ZERO VOC INTERIOR LATEX SEMI-GLOSS FINISH
TILE & FLOORING	LVT-1	KARNDEN VAN GOUGH NATURAL PRIM OAK SCB115, STYLE # VGV115T, GLUE DOWN INSTALLATION PER MANUFACTURER'S INSTRUCTIONS
	T-1	existing to remain EXISTING QUARRY TILE TO REMAIN - PATCH AND REPAIR ANY DAMAGED TILES AND GROUT AS NEEDED
	T-2A	LOUISVILLE TILE URBSPLIT60WH: MANUFACTURER: WOW, SHAPE: 6in X 6in (15cm X 15cm), COLOR: TURQUOISE, PATTERN: MIXED ORIENTATION, BLENDED w/ T-2B PER INTERIOR ELEVATIONS & SUPPLIER EXAMPLE IMAGE, GROUT: TEC POWER GROUT OPTIC WHITE 912
	T-2B	LOUISVILLE TILE URBSPLIT60WH: MANUFACTURER: WOW, SHAPE: 6in X 6in (15cm X 15cm), COLOR: WHITE, PATTERN: MIXED ORIENTATION, BLENDED w/ T-2A PER INTERIOR ELEVATIONS & SUPPLIER EXAMPLE IMAGE, GROUT: TEC POWER GROUT OPTIC WHITE 912
	T-3A	LOUISVILLE TILE URBTREND51IND: SIZE: 3x12 WALL TILE, COLOR: INDIGO, FINISH: GLOSS, PATTERN: VERTICAL STACK BOND BLENDED w/ T-3B, GROUT: TEC POWER GROUT SILVERADO 949
	T-3B	LOUISVILLE TILE URBTREND51IND: SIZE: 3x12 WALL TILE, COLOR: INDIGO, FINISH: GLOSS, PATTERN: VERTICAL STACK BOND BLENDED w/ T-3B, GROUT: TEC POWER GROUT SILVERADO 949
	T-4	LOUISVILLE TILE CRVHMIR001-BCT: SIZE: 8x8 QUARRY TILE, COLOR: GRAY, PATTERN: CROSSTREAD, GROUT: LATICRETE SPECTRALOCK 2000 IG BLACK #22 (PART A & B), LATICRETE MIDNIGHT BLACK #22 GROUT COLORANT PART C, AND LATICRETE 4XLT THINSET MORTAR
	T-5	LOUISVILLE TILE MANUFACTURER: RAGNO, COLLECTION: STRATFORD, SIZE: 8.25x7.25 HEXAGON, COLOR: DECORO TRATTO BEIGE (RBYM), FINISH: MATTE, GROUT: TEC POWER GROUT URBAN BRONZE 966
	T-6	LOUISVILLE TILE URBESSENTIALVEL: SIZE: 12x24, COLOR: ESSENTIAL YELLOW, GROUT: TEC POWER GROUT MIST 939 PROVIDE SCHLUTER DILEX COVE BASE TRANSITION BETWEEN WALL AND FLOOR TILE, TYP.
STONE	T-7	LOUISVILLE TILE URBTIDALWAVEASP: SIZE: 10x30, COLOR: TIDAL WAVE, FINISH: GLOSS, PATTERN: VERTICAL STACK BOND PER ELEVATIONS, GROUT: TEC POWER GROUT OPTIC WHITE 912
	T-8	LOUISVILLE TILE (WOW) MANUFACTURER: WOW, COLLECTION: GRACE O, COLOR: WHITE, FINISH: GLOSS, PATTERN: VERTICAL RUNNING BOND PER ELEVATIONS, GROUT: TEC POWER GROUT URBAN BRONZE
	TB-1	PER CONTRACTOR 6"x6" COVE TILE BASE TO MATCH T-4 WITH RIGHT AND LEFT CORNERS AS REQUIRED
	CNT-1	DALTILE "ONE" QUARTZ COUNTERTOP, 3cm THICKNESS, COLOR: SIMPLY WHITE
WOOD	WD-1	WALL PANELING 5.25" PRIMED SHIP LAP WAINSCOT INSTALLED HORIZONTALLY WITH PAINTED FINISH AS SCHEDULED - NOTE THAT MATERIAL IS INTENDED TO BE PRE-PRIMED, SMOOTH FINISH PINE OR SIMILAR WOOD STOCK FROM LOCAL HOME CENTER OR LUMBER YARD. FULL 1x THICKNESS IS NOT REQUIRED OR INTENDED. ENGINEERED PRODUCTS MAY BE ACCEPTABLE IF SUBMITTED FOR APPROVAL PRIOR TO PURCHASE WITH DOCUMENTED TESTING RESULTS FOR FLAME SPREAD AND SMOKE-DEVELOPED INDEXES.
	WD-2	WALL PANELING MAPLE PLYWOOD PANELS CUT FROM PRE-FINISHED UV COATED SHEETS - PREP TO 23.75" x 5.75" x 0.5" FACE DIMENSION w/ 0.125" ROUND OVER AT FACE PERIMETER. SET PANELS IN HERRINGBONE PATTERN PER DRAWINGS.
	WD-3	THROUGHOUT HARDWOOD MAPLE w/ CLEAR FINISH FOR VARIOUS TRIM & MOLDING PIECES- SEE INTERIOR ELEVATIONS AND DETAILS FOR SIZES, PROFILES, AND ADDITIONAL INFORMATION


NOTE THAT ALL FINISHES SHALL BE CLASS C RATED MINIMUM PER ASTM E84 OR UL 723 (FLAME SPREAD INDEX NO GREATER THAN 200 AND SMOKE DEVELOPED INDEX 0-450)

1

A2.2

Finish Floor Plan

scale: 1/4" = 1'-0"

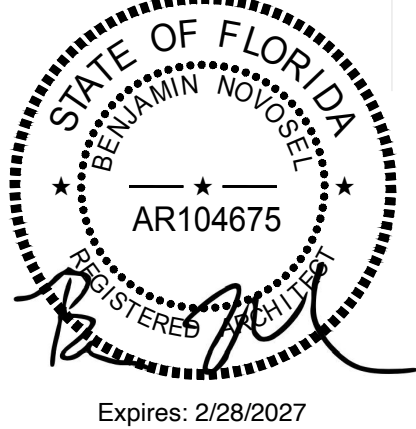


15 September 2026
permit

finish plan



Equipment & Furniture Plan

scale: 1/4" = 1'-0"


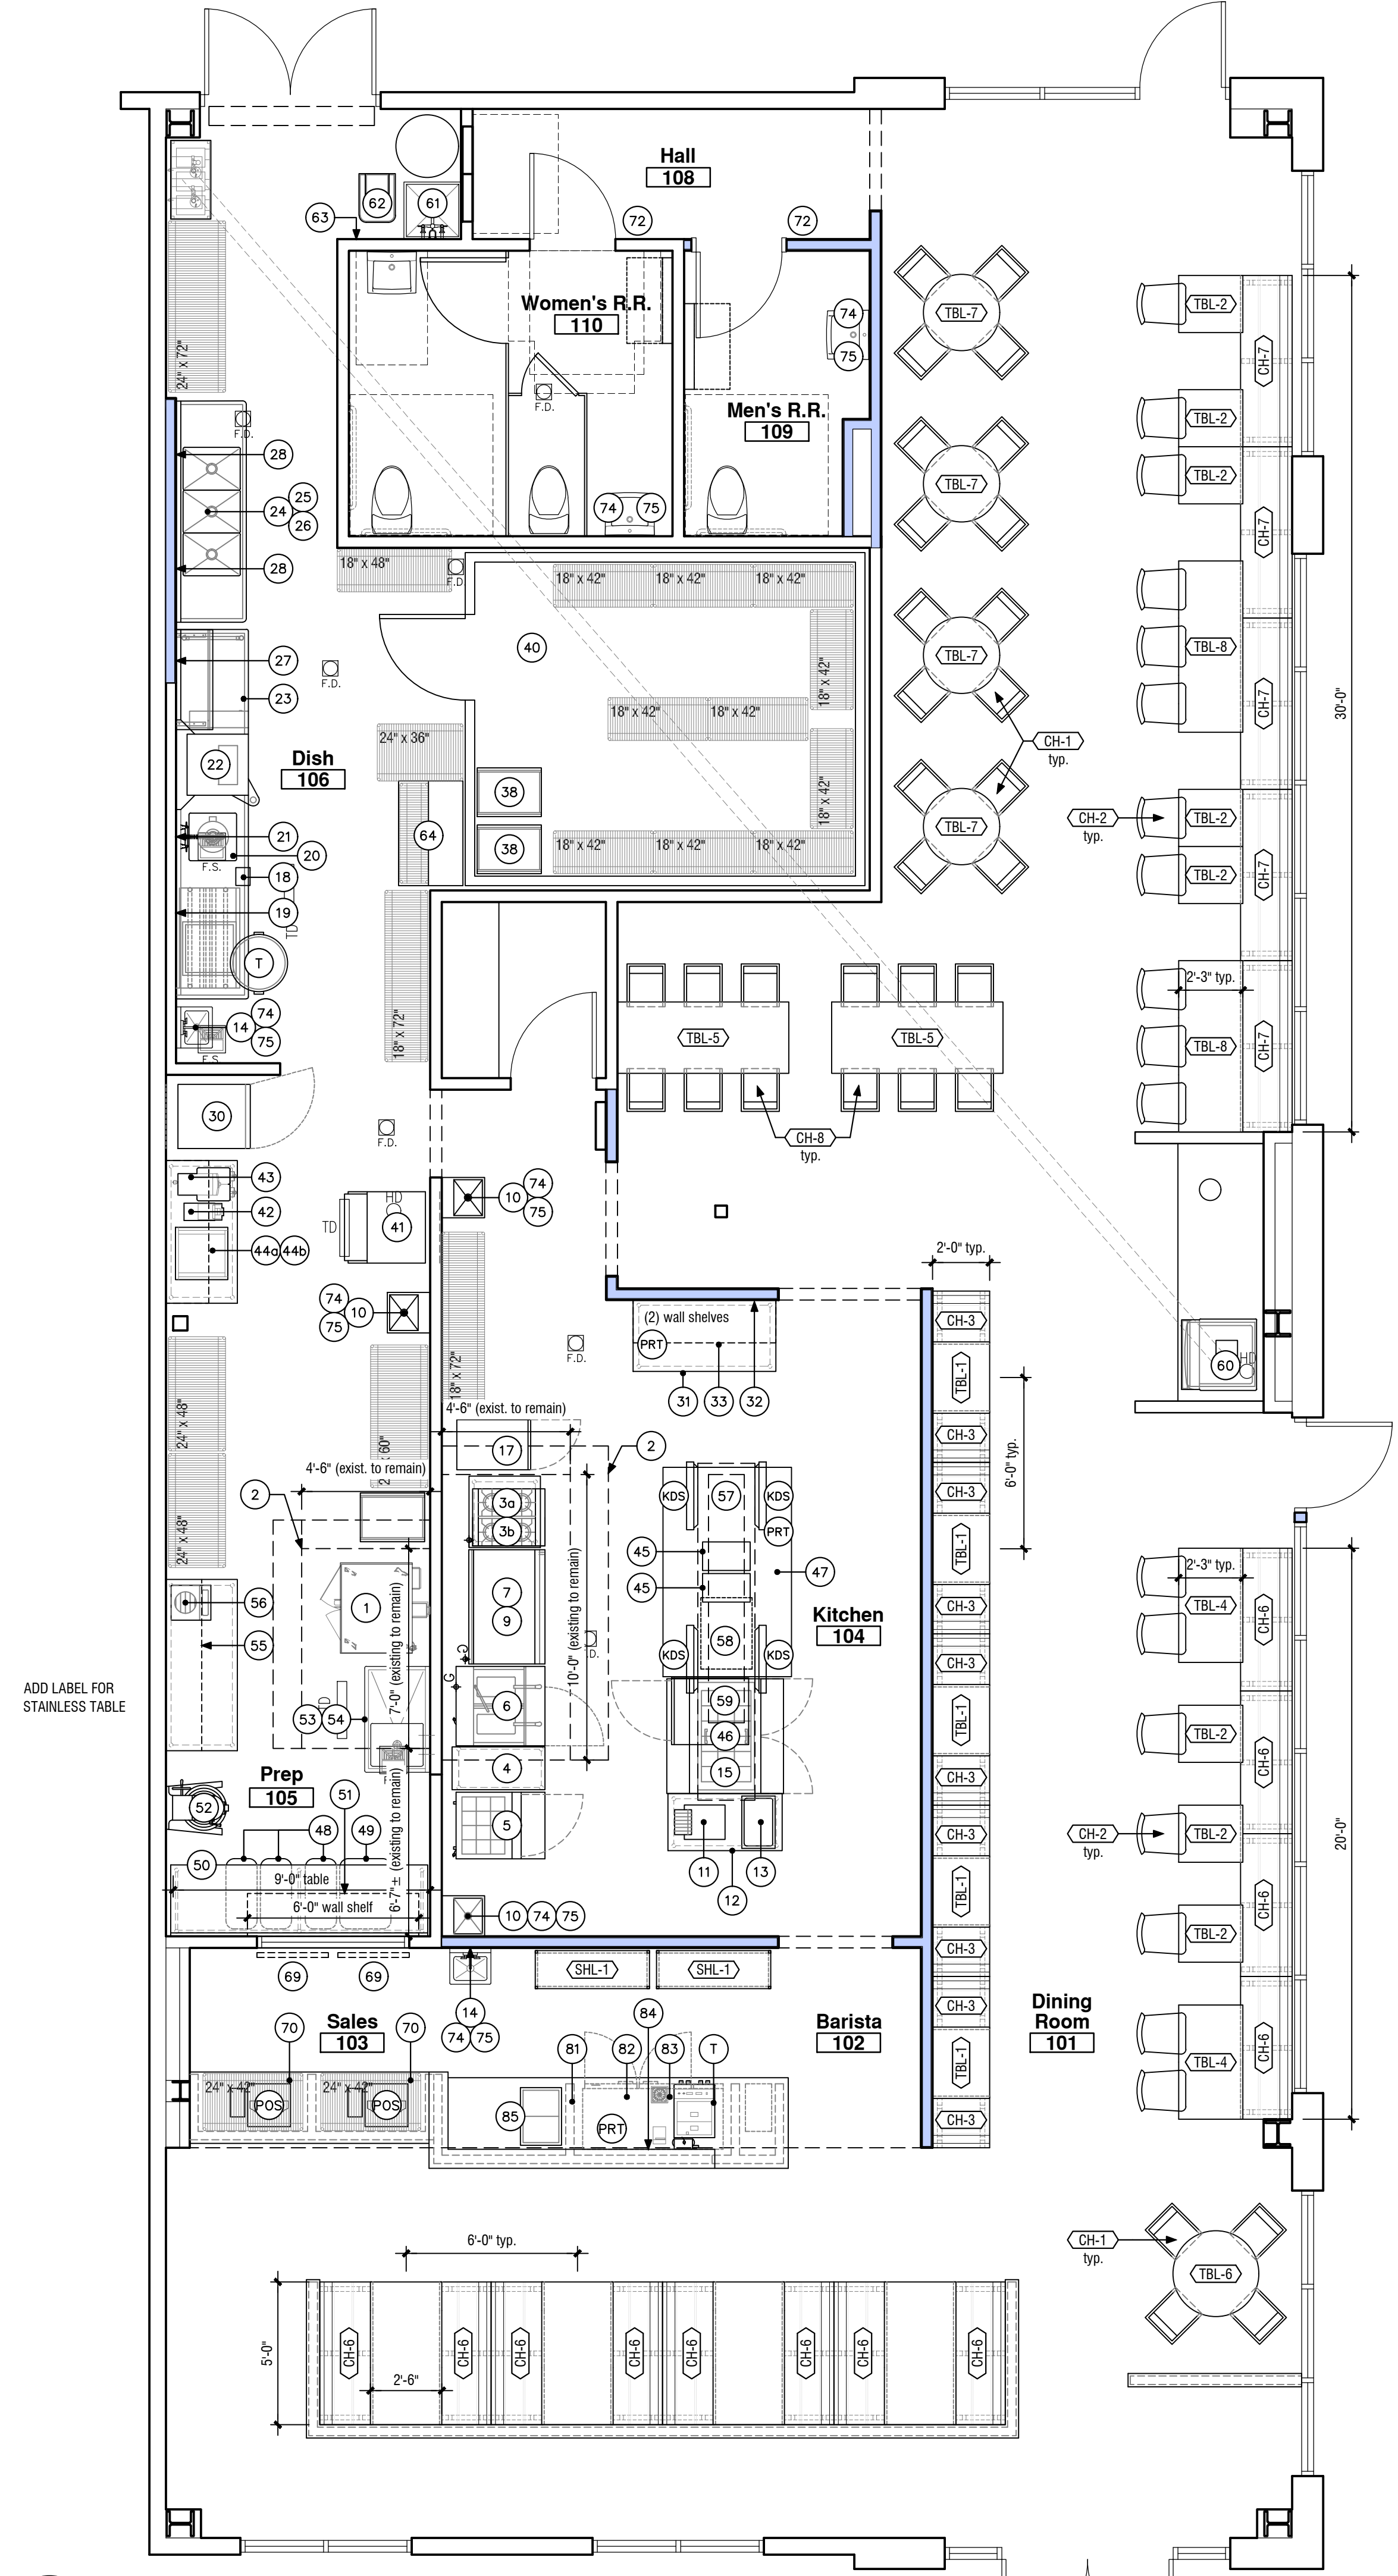


EQUIPMENT KEY		
#	ITEM	
1	DOUBLE CONVECTION OVEN, GAS	
2	EXHAUST HOOD	
3a	HOT PLATE, GAS	
3b	STAINLESS STEEL TABLE	
4	STAINLESS STEEL BREADING TABLE	
5	REFRIGERATED SANDWICH/SALAD PREP	
6	FRYER BATTERY, GAS w/ FILTER	
7	CHEF BASE	
8	not used	
9	GRIDDLE, GAS	
10	EXISTING HAND SINK	
11	CONVEYOR TOASTER	
12	24" x 48" STAINLESS TABLE	
13	ELECTRIC COUNTERTOP FOOD WARMER	
14	HAND SINK, WALL MOUNT	
15	HEAT LAMP	
16	not used	
17	HOT HOLD CABINET, MOBILE, PASS-THRU	
18	DISH TABLE, DIRTY	
19	DISH SHELF, TUBULAR SORTING	
20	PRE-RINSE SINK	
21	PRE-RINSE FAUCET/SPRAYER, WALL MOUNT	
22	DISH MACHINE (LOW-TEMP)	
23	DISH TABLE, CLEAN	
24	SINK, SCULLERY, 3 COMPARTMENTS	
25	PRE-RINSE FAUCET/SPRAYER, WALL MOUNT	
26	WASTE DRAIN VALVE	
27	DISH SHELF, SOLID SORTING	
28	WALL SHELVING	
29	not used	
30	REACH-IN FREEZER	
31	TO GO STATION S.S. TABLE - 30" X 60"	
32	WIRE WALL MOUNT SHELVES	
33	TICKET RAIL	
34-37	not used	
38	PAN RACK	
39	not used	
40a	WALK-IN COOLER LIGHTS	
40b	WALK-IN COOLER EVAPORATOR	
40c	WALK-IN COOLER CONDENSER	
41a	ICE MACHINE	
41b	ICE MACHINE BIN	
42	COFFEE GRINDER	
43	TEA BREWER	
44a	COFFEE MAKER	
44b	WATER FILTER	
45	DROP-IN HOT WELLS	
46	DOUBLE-SIDED REFRIGERATED PREP TABLE	
47	CUSTOM STAINLESS EXPO STATION	
48	INGREDIENT BIN, SMALL	
49	INGREDIENT BIN, LARGE	
50	STAINLESS STEEL TABLE w/ OPEN BASE	
51	STAINLESS WALL SHELVING	
52	FLOOR MIXER	
53	STAINLESS PREP TABLE w/ SINK	
54	FAUCET, WALL MOUNT	
55	SHELVING, WALL MOUNT	
56	COUNTERTOP WARMER	
57	HEAT LAMP	
58	HEAT LAMP	
59	HEAT LAMP	
60	COUNTERTOP SODA DISPENSER MACHINE	
61	MOP SINK	
62	MOP BUCKET	
63	CLEANING CHEMICALS WALL SHELF	
64	SPACE SAVER OIL STORAGE/SHELVING	
65-68	not used	
69	WALL MOUNTED MONITOR DISPLAY	
70	UNDERCOUNTER METRO SHELVING	
71	not used	
72	ADA RESTROOM SIGN	
73	BABY CHANGING TABLE	
74	SOAP DISPENSER	
75	PAPER TOWEL DISPENSER	
76-79	not used	
80	METRO RACK GLASS STORAGE	
81	REFRIGERATOR, UNDERCOUNTER	
82	PITCHER RINSER	
83	ESPRESSO (FUTURE - WIRING ONLY)	
84	WATER FILTER FOR ESPRESSO MACHINE	
85	DROP-IN ICE BIN	
86	DROP-IN HAND SINK	
87	GLASS RACK DOLLY	
BIB	BAG IN BOX SODA SYSTEM	
CO2	BULK CO2 TANK	
HOT	HOT WATER TANK	
KDS	KITCHEN DISPLAY SYSTEM (MONITOR)	
PRT	PRINTER	
POS	POINT OF SALE	
T	TRASH CAN	

NOTE: SCHEDULE THIS SHEET PROVIDED FOR REFERENCE ONLY. SEE SHEET A2.5 FOR KITCHEN EQUIPMENT SCHEDULE AND CONNECTION INFO

NOTE: G.C. SHALL VERIFY THAT SCOPE & COST IS INCLUDED FOR PULLING ALL DATA CABLES & TERMINATIONS, AND INSTALLATION OF ALL POS EQUIPMENT

NOTE: G.C. SHALL INCLUDE COST TO RECEIVE, UNPACK, ASSEMBLE & INSTALL ALL FURNITURE SPECIFIED (INCLUDE FASTENING BENCHES TO FLOOR)

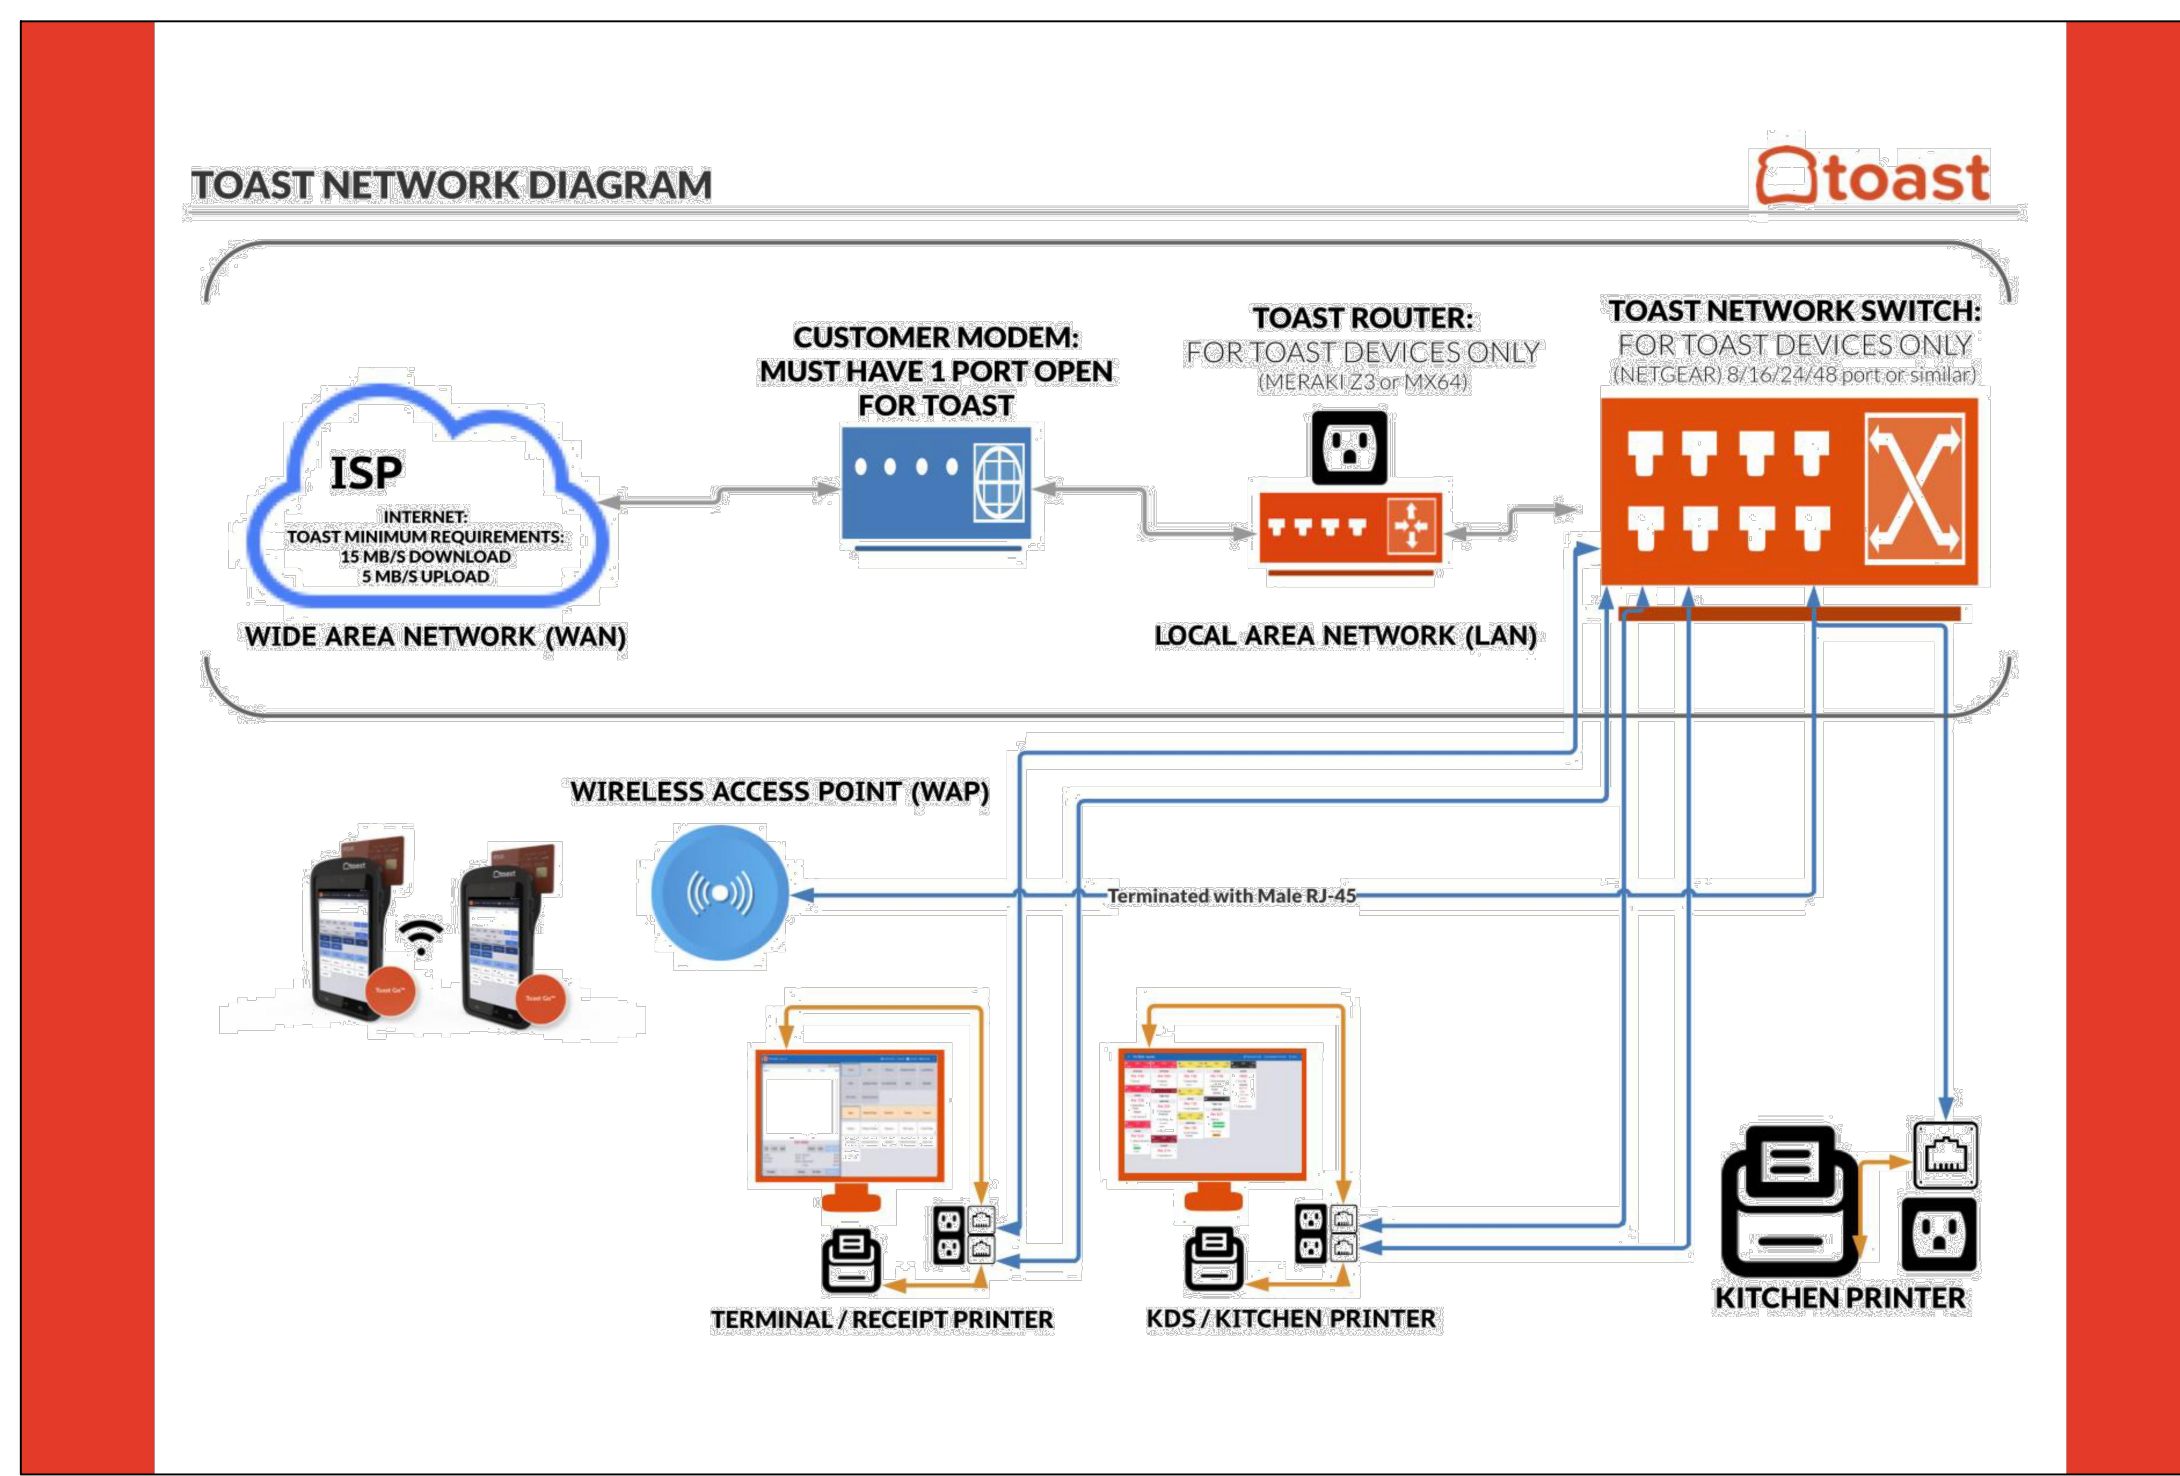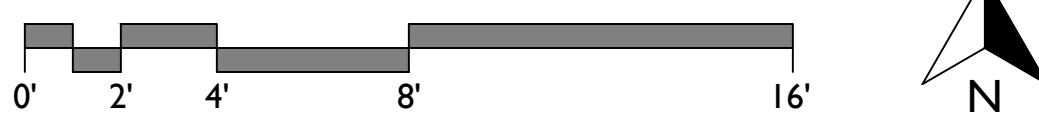


Site Readiness Checklist


You're site is ready for a successful Toast install when the following is true:

- You've procured a broadband internet connection. For most restaurants this will be a landline internet service (Cable or Fiber. DSL is not recommended). For mobile restaurants, this may be a 4G modem.
- Internet speeds are at least 15 megabits per second (Mbps) for download and 5 Mbps for upload.
- The internet modem has a designated port for Toast (single port modems are not recommended). This is where the Toast router and switch will be located if Toast will monitor your network.
- Network cabling (cat5e or better) is run and terminated to each place where a Toast terminal, printer, kitchen display screen, access point (ceiling), or kiosk will be located.
- The above networking cabling should be home run back to the area near the internet modem (ex: cabling from your bar to your kitchen isn't recommended. Cable should go from modem to kitchen and modem to bar).
- Power is available within 6 ft of each place where a Toast terminal, printer, kitchen display screen, and kiosk will be located. Access points are installed (or ready to be installed) in the ceilings or on the outside of the building. If you've purchased onsite installation, please be advised that our technicians cannot install above 10 ft and don't carry ladders.
- Wall mounts are installed (or ready to be installed). If you've purchased onsite installation, please be advised that our technicians can't always mount Toast hardware for you. Depending on the surface, special tools may be required.
- The restaurant is NOT in active construction. All heavy construction is complete and no addition construction will be necessary that could compromise the hardware being installed or cause it to be moved.
- The bar(s)/counter(s) are finished and holes are cut to accommodate the terminals' cabling. If applicable, all counter tops are installed at service stations.



CHECK OUT TOAST CENTRAL FOR MORE INFORMATION @centraltoasttab.com

FURNITURE SCHEDULE (all furniture to be purchased by owner and assembled/installed by G.C.)				
KEY	DESCRIPTION	QTY	MAKE	PRODUCT INFORMATION
CH-1	DINING CHAIR (indoor, white)	20	CROW WORKS	WARREN DINING CHAIR - FINISH: SEA SALT FRAME (WHITE), NATURAL WHITE OAK SEAT
CH-2	DINING CHAIR (indoor, yellow)	18	CROW WORKS	WARREN DINING CHAIR - FINISH: RAL 1028 MELON YELLOW FRAME, NATURAL WHITE OAK SEAT
CH-3	DINING BENCH (24")	10	CROW WORKS	24" QUINCY BANQUETTE - FINISH: RAL 1028 MELON YELLOW FRAME, NATURAL WHITE OAK SEAT
CH-4	DINING BENCH (30")	---	CROW WORKS	30" QUINCY BANQUETTE - FINISH: RAL 1028 MELON YELLOW FRAME, NATURAL WHITE OAK SEAT
CH-5	DINING BENCH (48")	---	CROW WORKS	48" QUINCY BANQUETTE - FINISH: RAL 1028 MELON YELLOW FRAME, NATURAL WHITE OAK SEAT
CH-6	DINING BENCH (60")	12	CROW WORKS	60" QUINCY BANQUETTE - FINISH: RAL 1028 MELON YELLOW FRAME, NATURAL WHITE OAK SEAT
CH-7	DINING BENCH (72")	5	CROW WORKS	72" QUINCY BANQUETTE - FINISH: RAL 1028 MELON YELLOW FRAME, NATURAL WHITE OAK SEAT
CH-8	COUNTER HEIGHT CHAIR	12	CROW WORKS	UNION BAR STOOL - FINISH: SEA SALT FRAME (WHITE), NATURAL OAK SEAT
TBL-1	DINING TABLE (2-TOP)	5	CROW WORKS	SIZE 28"th. BASE + 1.25"th. X 24"w. X 30"l. TOP
TBL-2	DINING TABLE (2-TOP)	8	CROW WORKS	SIZE 28"th. BASE + 1.25"th. X 24"w. X 27"l. TOP
TBL-3	DINING TABLE (4-TOP)	---	CROW WORKS	SIZE 28"th. BASE + 1.25"th. X 48"w. X 30"l. TOP
TBL-4	DINING TABLE (4-TOP)	2	CROW WORKS	SIZE 28"th. BASE + 1.25"th. X 48"w. X 27"l. TOP
TBL-5	COUNTER TABLE (6-TOP)	2	CROW WORKS	SIZE 34"th. BASE + 1.25"th. X 30"w. X 72"l. TOP
TBL-6	DINING TABLE (4-TOP)	1	CROW WORKS	SIZE 28"th. BASE + 1.25"th. X 38" dia. TOP
TBL-7	DINING TABLE (4-TOP)	4	CROW WORKS	SIZE 28"th. BASE + 1.25"th. X 32" dia. TOP
TBL-8	DINING TABLE (4-TOP)	2	CROW WORKS	SIZE 28"th. BASE + 1.25"th. X 72"w. X 27"l. TOP
SHL-1	CARRY-OUT SHELVES	2	CROW WORKS	CARRY-OUT SHELVES: 48"w X 16"d. X 80"th. RAL 1028 MELON YELLOW PAINTED FRAME FINISH w/ CASK WOOD SHELVES.

 [illegible]

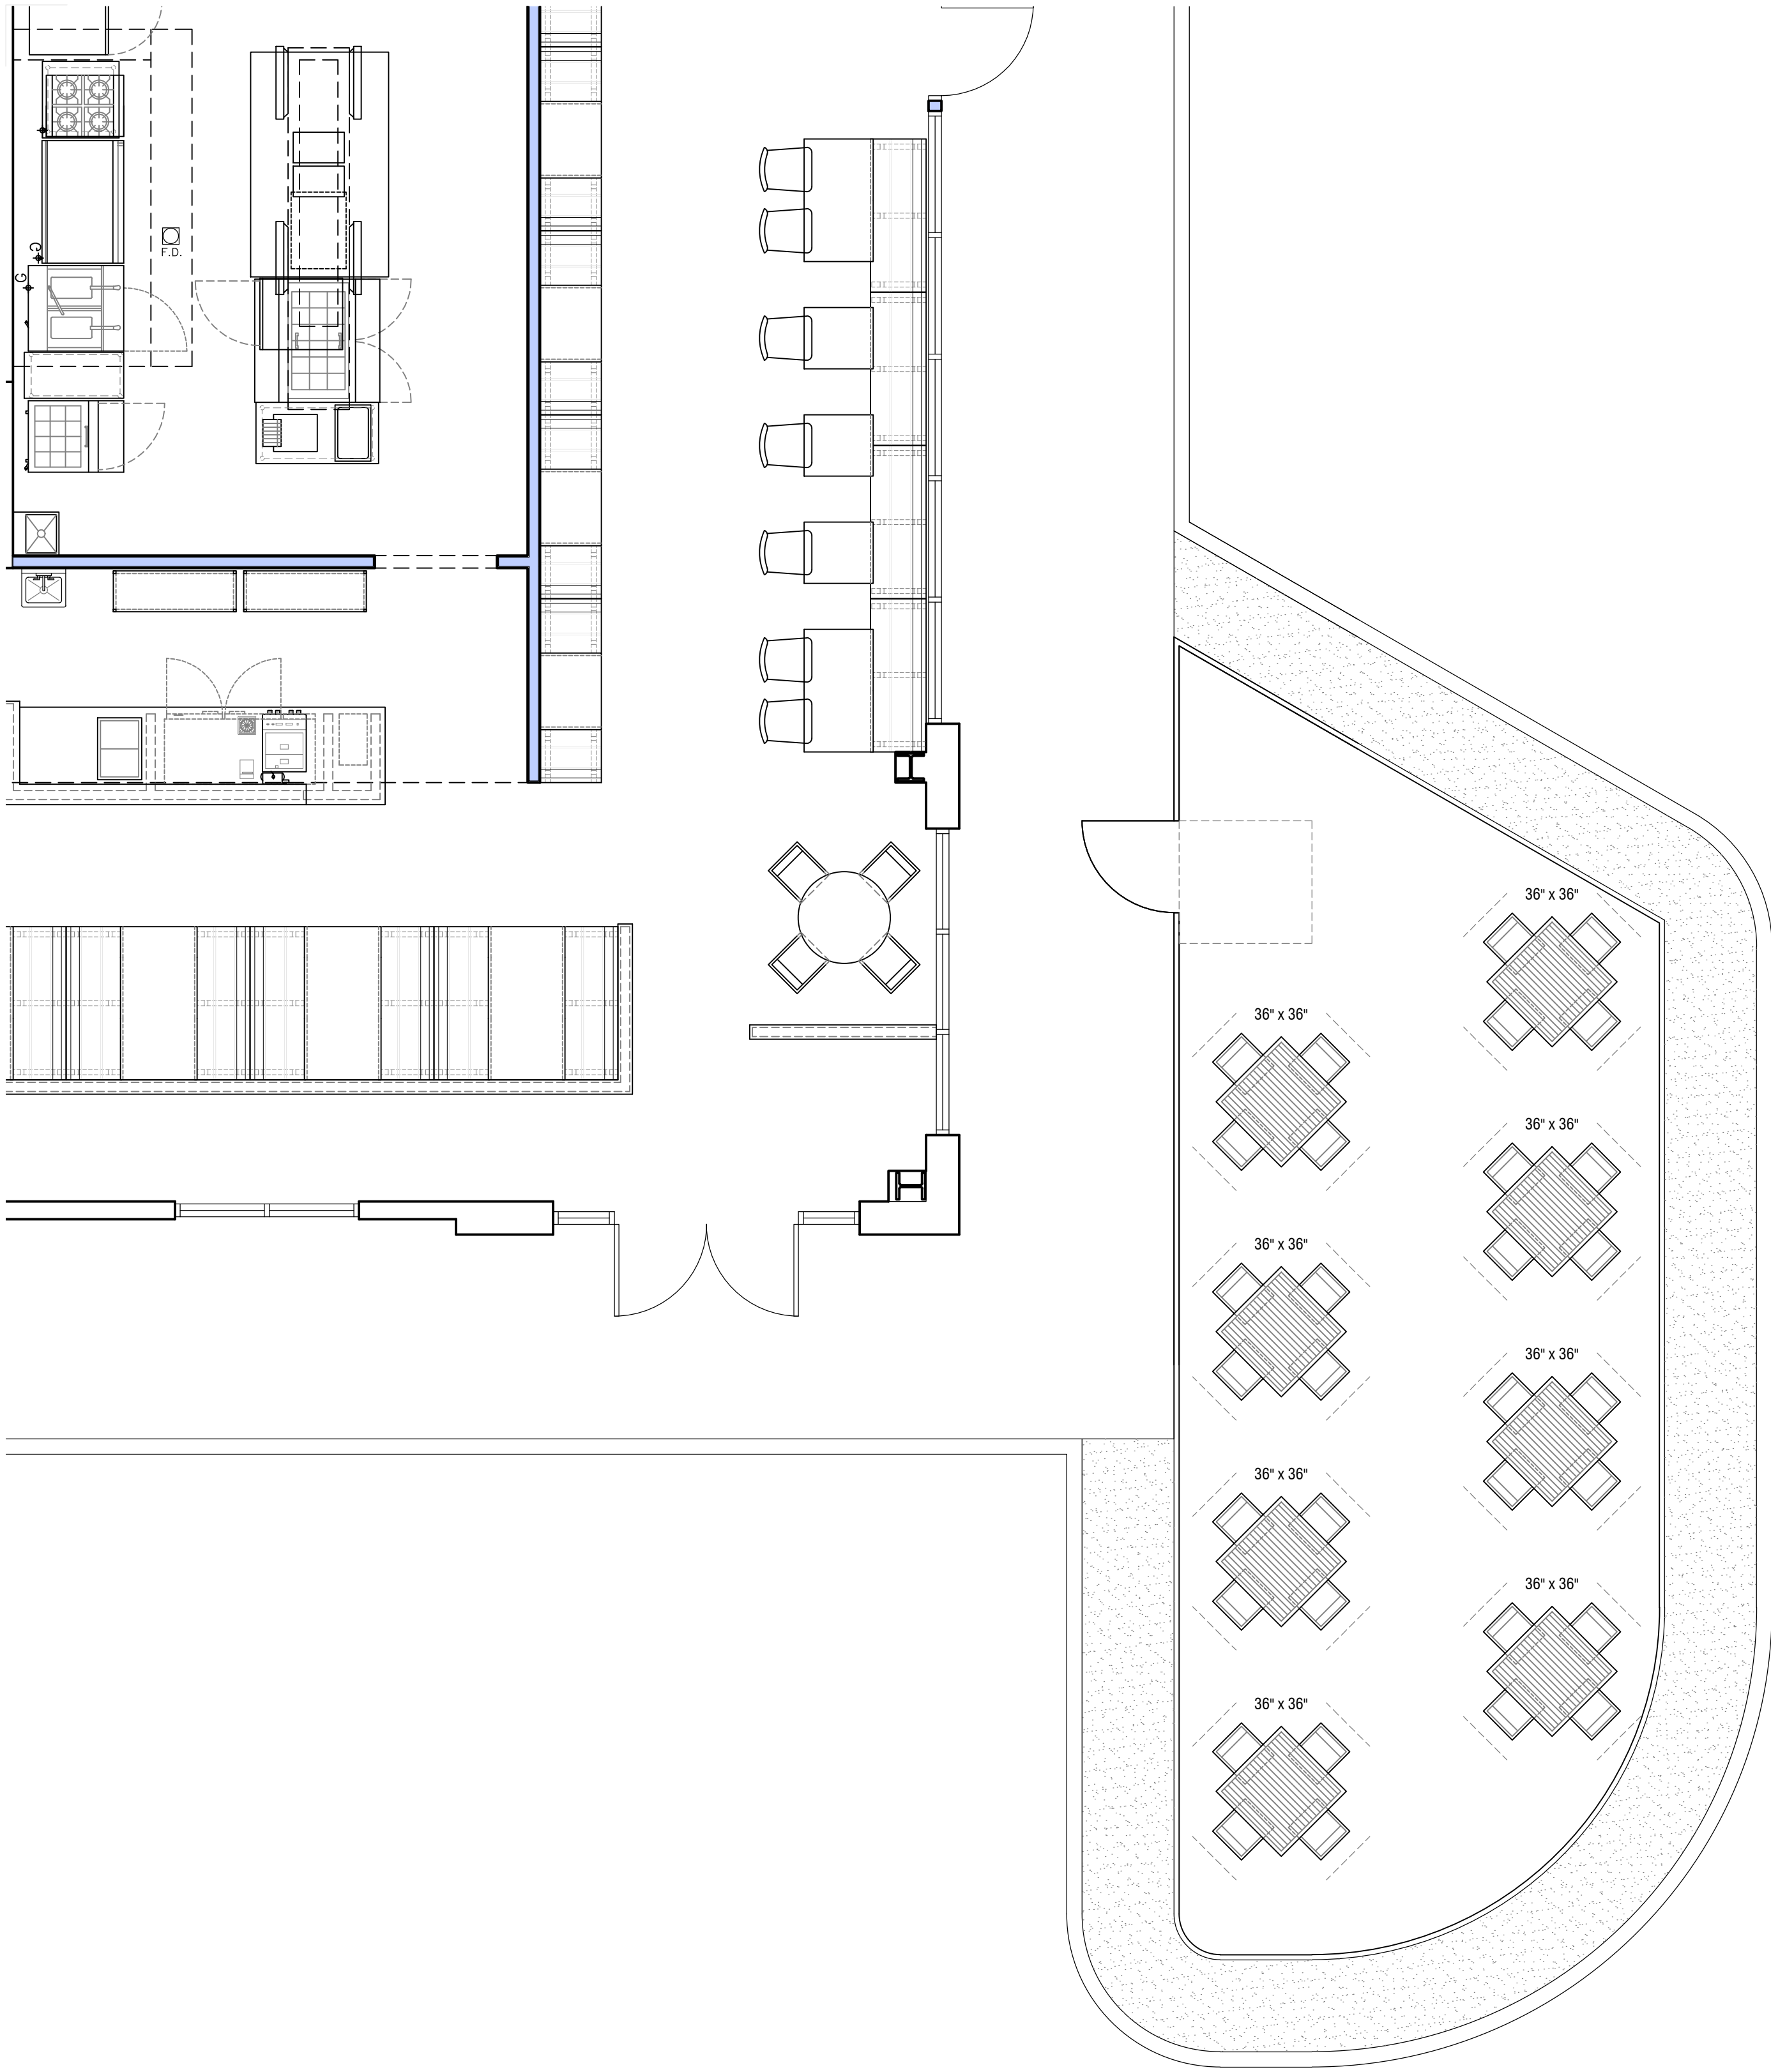

 1
A2.6 **Patio Furniture Plan**
scale: 1/4" = 1'-0"

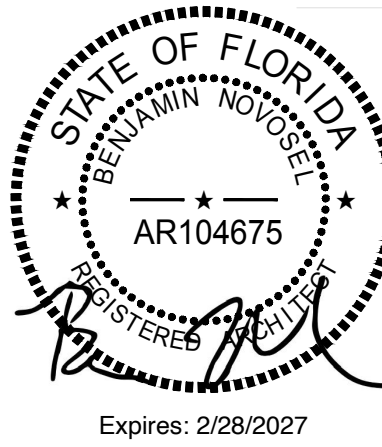


Biscuit Belly
15463 Panama City Beach Pkwy Ste B
Panama City Beach, FL 32413

insomnia DESIGN
© insomnia design 2024

15 September 2026
permit

patio furniture plan



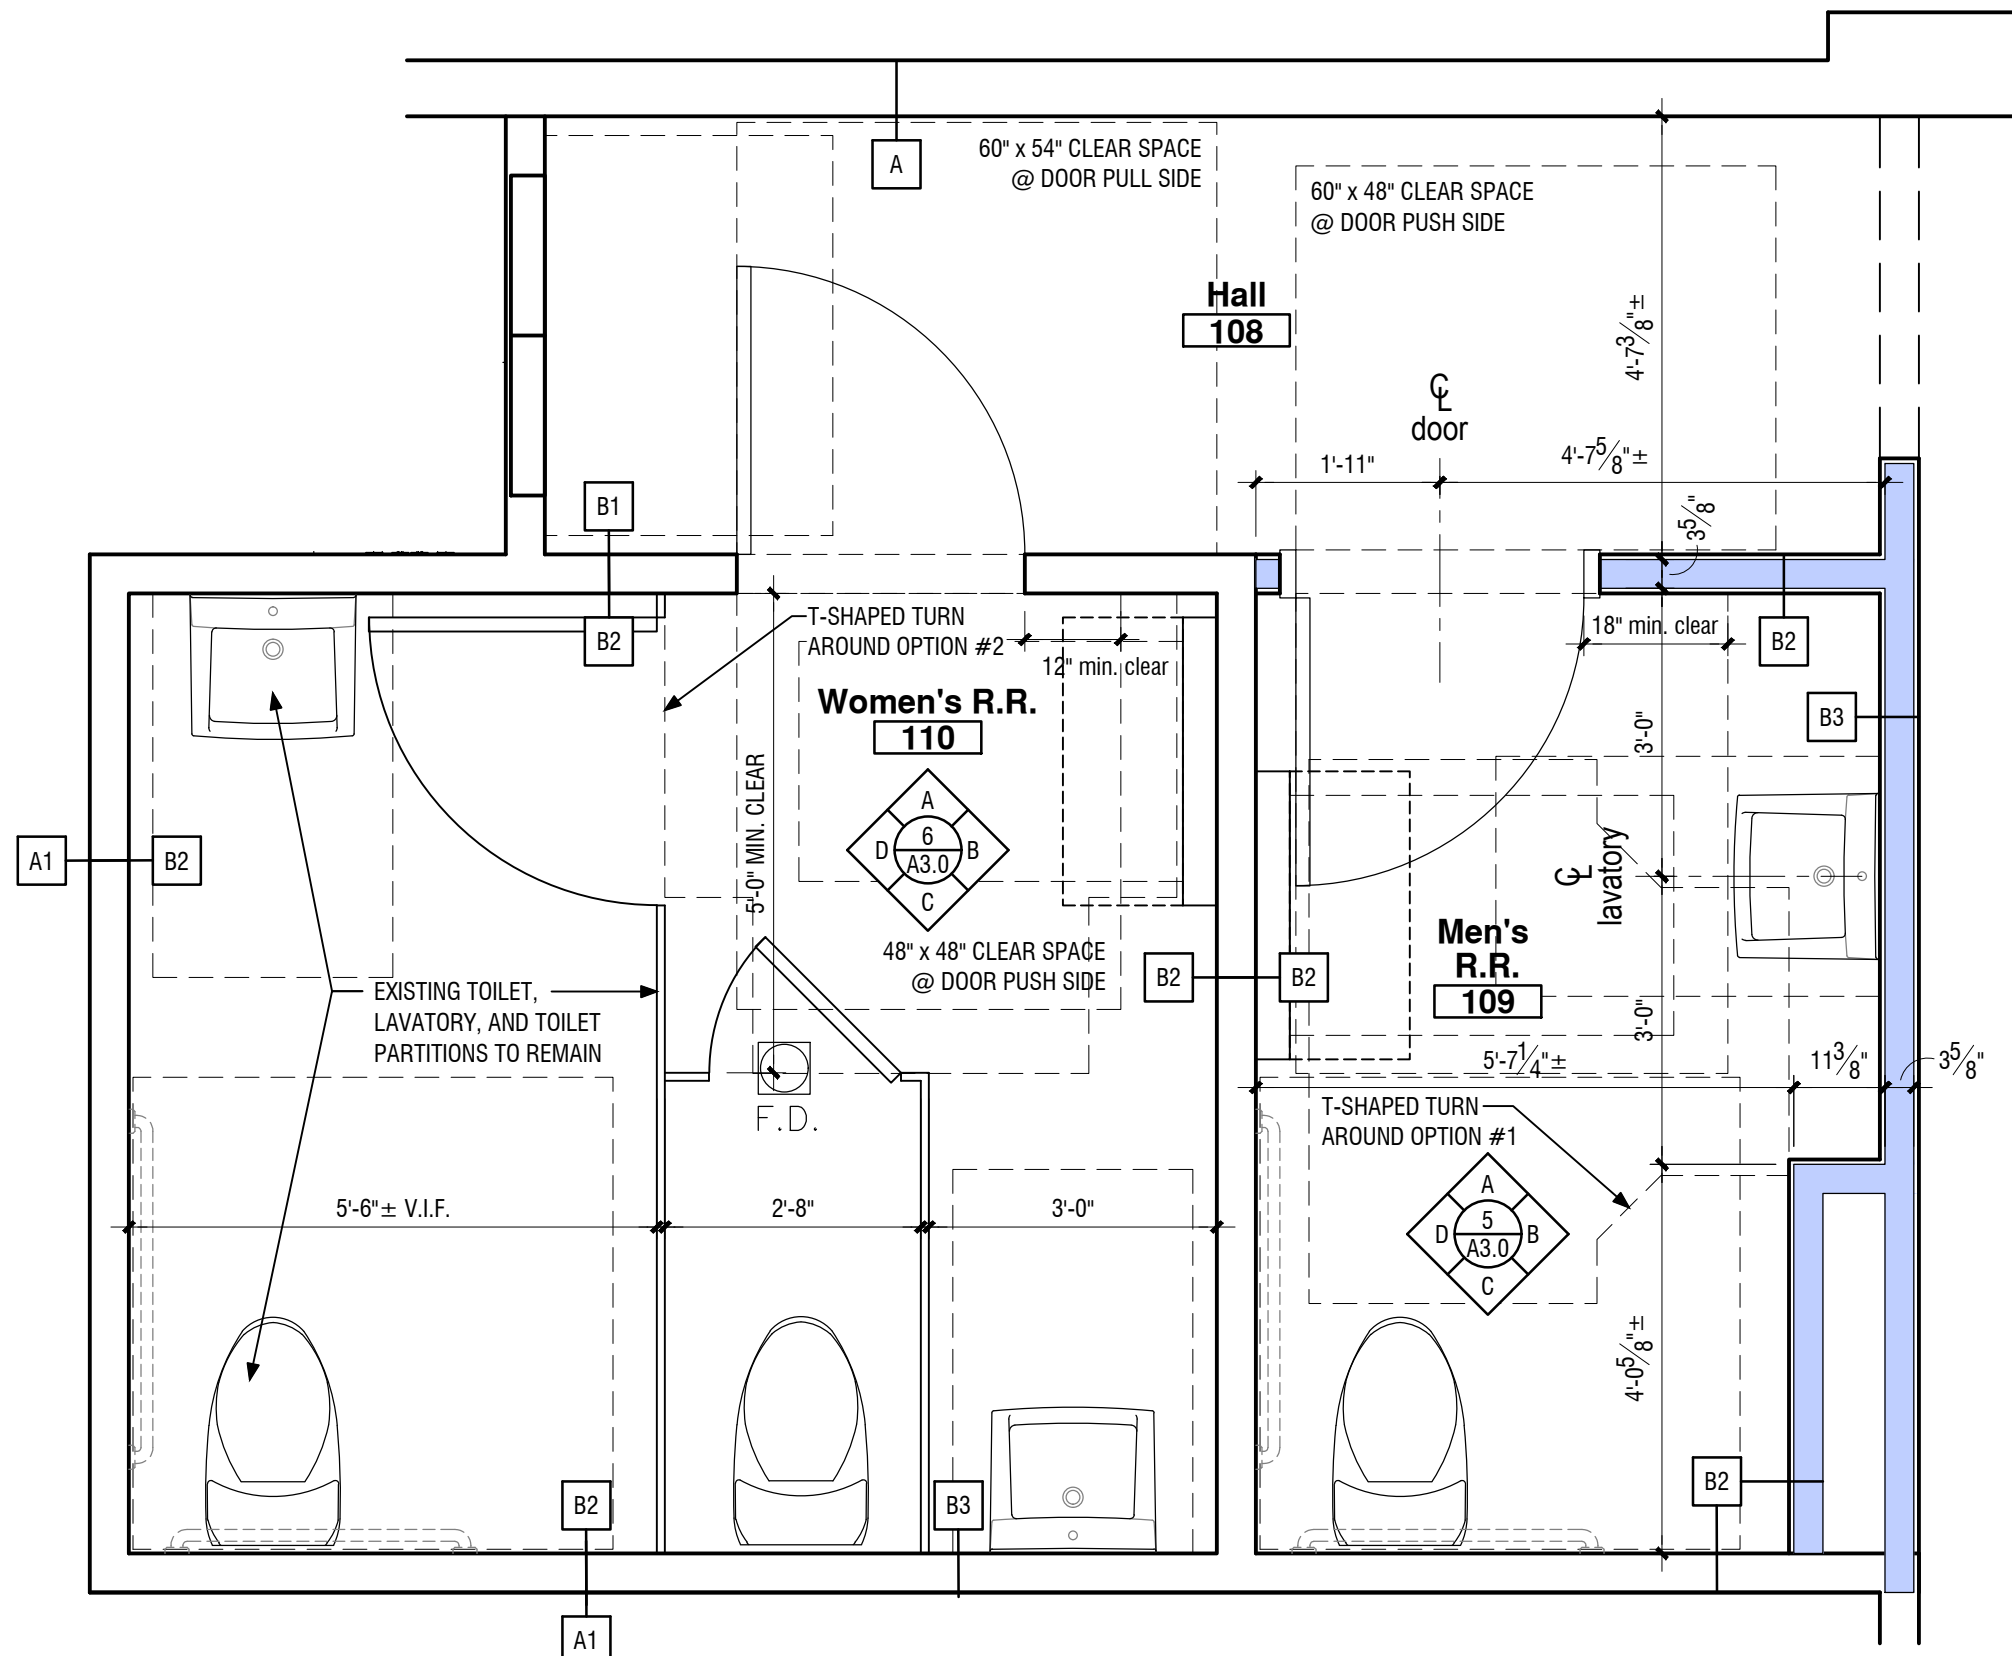

ACCESSIBLE RESTROOM NOTES

1. PROVIDE GRAB BARS ON SIDE AND BACK OF WATER CLOSET:
A. GRAB BARS TO BE PARALLEL TO THE FLOOR
B. SIDE BARS TO BE 42" LONG MIN. & PROJECT 24" MIN. IN FRONT OF WATER CLOSET STOOL. GRAB BAR @ BACK TO BE 36" MIN. LONG.
C. DIAMETER OF GRAB BARS TO BE 1-1/4"
D. PROVIDE 1-1/2" CLEARANCE BETWEEN GRAB BARS AND WALL
E. GRAB BARS (INCLUDING CONNECTORS, FASTENERS, SUPPORT BACKING, ETC.) SHALL SUPPORT A 250 POUND LOAD
F. GRAB BARS TO BE SATIN CHROME FINISH w/ KNURLED GRIP U.N.O.
2. SEE DOOR SCHEDULE FOR ACCESSIBILITY NOTES PERTAINING TO DOORS & HARDWARE.
3. MOUNT LAVATORIES w/ 27" MIN. CLEARANCE FROM THE FLOOR TO THE BOTTOM OF THE APRON. PROVIDE KNEE CLEARANCE UNDER THE FRONT EXTENDING 30" MIN. WIDE BY 8" MIN. HIGH AT FRONT OF APRON, AND 9" MIN. HIGH FROM THE FLOOR NO LESS THAN 17" DEEP FROM THE FRONT OF THE LAVATORY.
4. FAUCET CONTROLS AND OPERATING MECHANISMS SHALL BE OPERABLE WITH ONE HAND AND SHALL NOT REQUIRE TIGHT GRASPING, PINCHING OR TWISTING OF THE WRIST. THE FORCE REQUIRED TO ACTIVATE CONTROLS SHALL BE NO GREATER THAN 5 POUNDS. LEVER OPERATED, PUSH TYPE AND ELECTRONICALLY CONTROLLED MECHANISMS ARE EXAMPLES OF ACCEPTABLE DESIGNS.
5. INSULATE OR OTHERWISE COVER HOT WATER AND DRAIN PIPES UNDER LAVATORIES.
6. PROVIDE SIGNAGE USING THE INTERNATIONAL SYMBOL OF ACCESSIBILITY AT ACCESSIBLE BATHROOM. INCLUDE THE REQUIRED GRADE II BRAILLE ON THE PICTOGRAM PER THE ADAAG RECOMMENDATIONS.
7. ALL ELECTRICAL AND MECHANICAL DEVICES, INCLUDING BUT NOT LIMITED TO THERMOSTATS, LIGHT SWITCHES, OUTLETS, AND OTHER DEVICES SHALL BE MOUNTED BETWEEN 9" AND 54" ABOVE THE FINISHED FLOOR.
8. FLUSH HANDLE SHALL BE LOCATED ON THE OPEN SIDE OF THE WATER CLOSET (OPPOSITE OF WALL) EXCEPT IN AMBULATORY ACCESSIBLE COMPARTMENTS COMPLYING WITH SECTION 604.8.2.

2 Hall 108
A3.0 scale: 1/2" = 1'-0"

3 Hall 108 Interior Elevation
A3.0 scale: 1/2" = 1'-0"

4 Hall 108
A3.0 scale: 1/2" = 1'-0"

1 Enlarged Restroom Plan
A3.0 scale: 1/2" = 1'-0"

GENERAL BATHROOM NOTES


1. FLOOR SURFACE IN RESTROOMS TO BE TILE OR SIMILAR SMOOTH, HARD, NONABSORBENT MATERIAL w/ 4" MIN. BASE TURNED UP AT FLOOR AND WALL INTERSECTION, U.N.O.
2. MOISTURE RESISTANT GYP. BOARD AND EPOXY PAINT TO BE USED w/in 2'-0" MIN. HORIZONTALLY AND 4'-0" MIN. VERTICALLY FROM ALL WATER CLOSETS AND URINALS OR SIMILAR SMOOTH, HARD, NONABSORBENT MATERIAL, U.N.O.
3. PROVIDE COVE TILE TRANSITION PROFILE BETWEEN ALL WALL & FLOOR TILE, TYP. (SEE FINISH SCHEDULE FOR SELECTION)

RESTROOM FIXTURES


SOAP: PROVIDED BY OWNER, INSTALLED BY G.C.
PAPER TOWEL: PROVIDED BY OWNER, INSTALLED BY G.C.
TOILET PAPER: PROVIDED BY OWNER, INSTALLED BY G.C.
TRASH CAN: OWNER/DISTRIBUTOR SUPPLIED

ALL ITEMS BELOW TO BE PROVIDED AND INSTALLED BY G.C.


TOILET: SIGNATURE HARDWARE SIG479087 BRADENTON 2-PIECE ELONGATED TOILET w/ CHROME HANDLE (SHBD210WH TANK + SHBD255WH BOWL) 10" ROUGH VERSION NOTED, 12" AND 14" IS ALSO AVAILABLE
LAVATORY: KOHLER K-2031 GREENWICH WALL-MOUNT SINGLE-HOLE LAVATORY, color: WHITE
FAUCET: SIGNATURE HARDWARE LEXIA SINGLE-HOLE BATHROOM FAUCET, color: BRUSHED GOLD (SKU: 953760 Code: SHWSCLE107, SHL24DP)
MIRROR: EBURN DESIGNS, 30" x 40" MOLLY TEMPERED GLASS AND METAL FRAMED FRENCH CLEAT MOUNTED WALL BATHROOM VANITY MIRROR, finish: GOLD
BABY CHANGER: KOALA KARE KB300-05 (HORIZONTAL) -or- KB301-05 (VERTICAL) CONFIGURATION PER PLAN IN WHITE-GRANITE COLOR, INSTALLED & PROVIDED BY G.C.
SANITARY TRASH: BOBRICK B-270, WALL-MOUNTED SANITARY NAPKIN DISPOSAL, STAINLESS STEEL FINISH

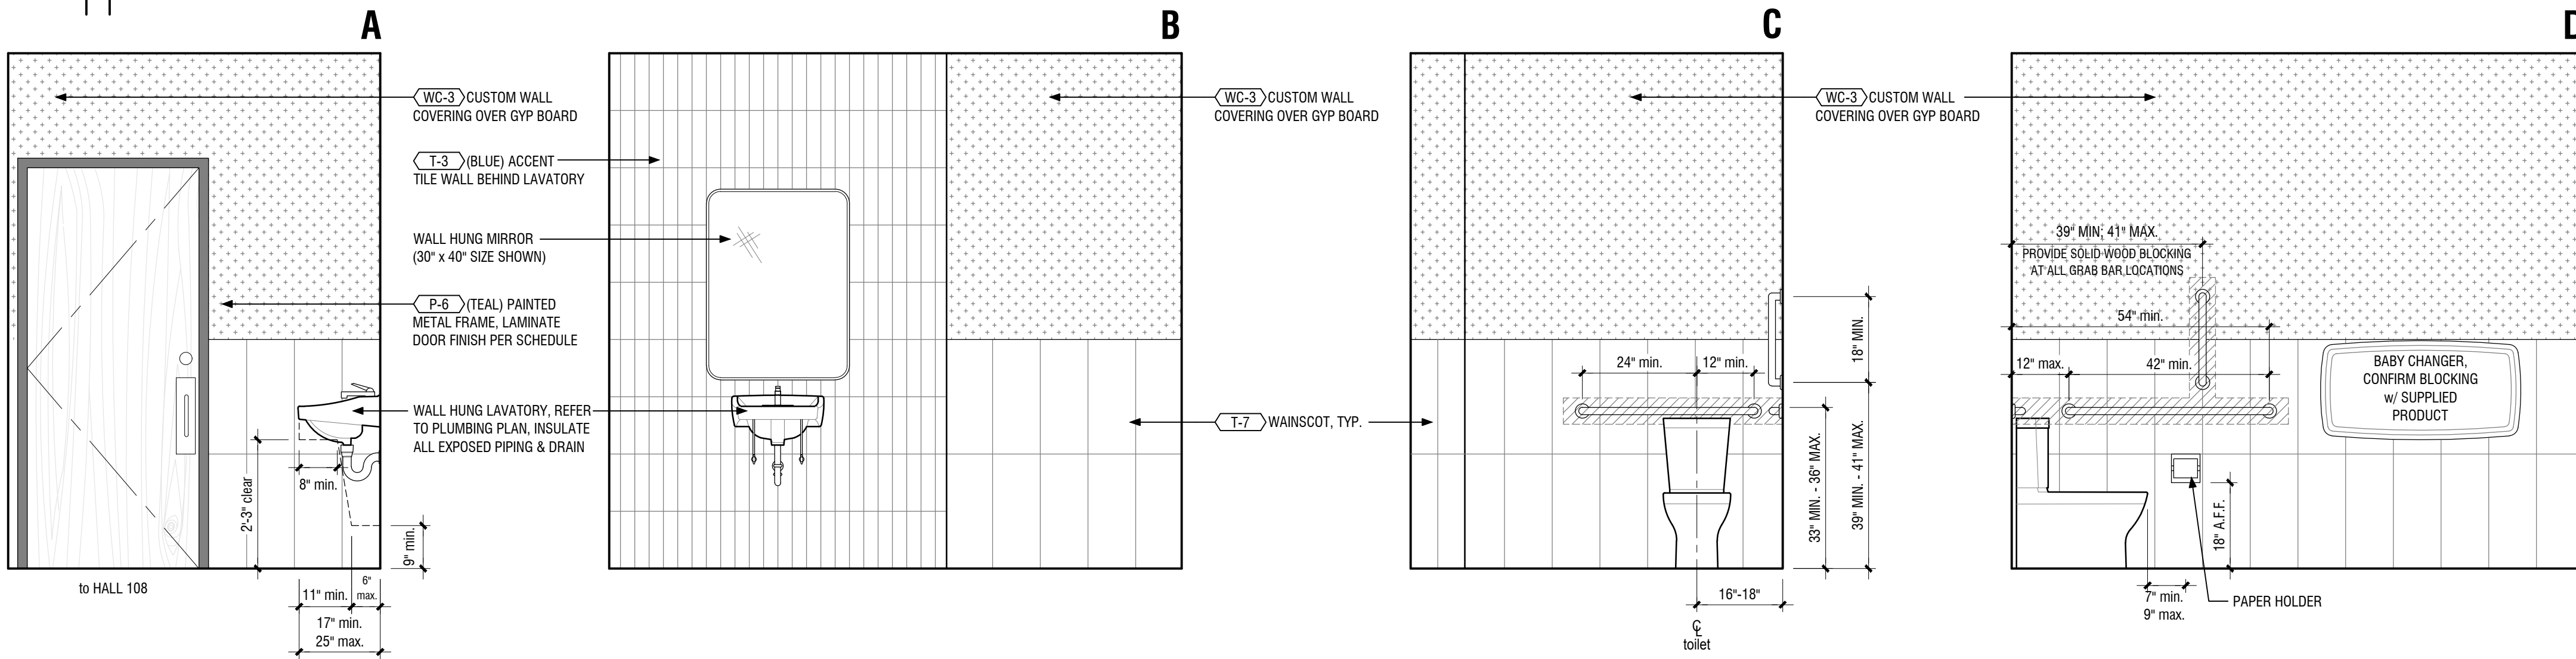


5 Men's Room 109 Interior Elevations
A3.0 scale: 1/2" = 1'-0"

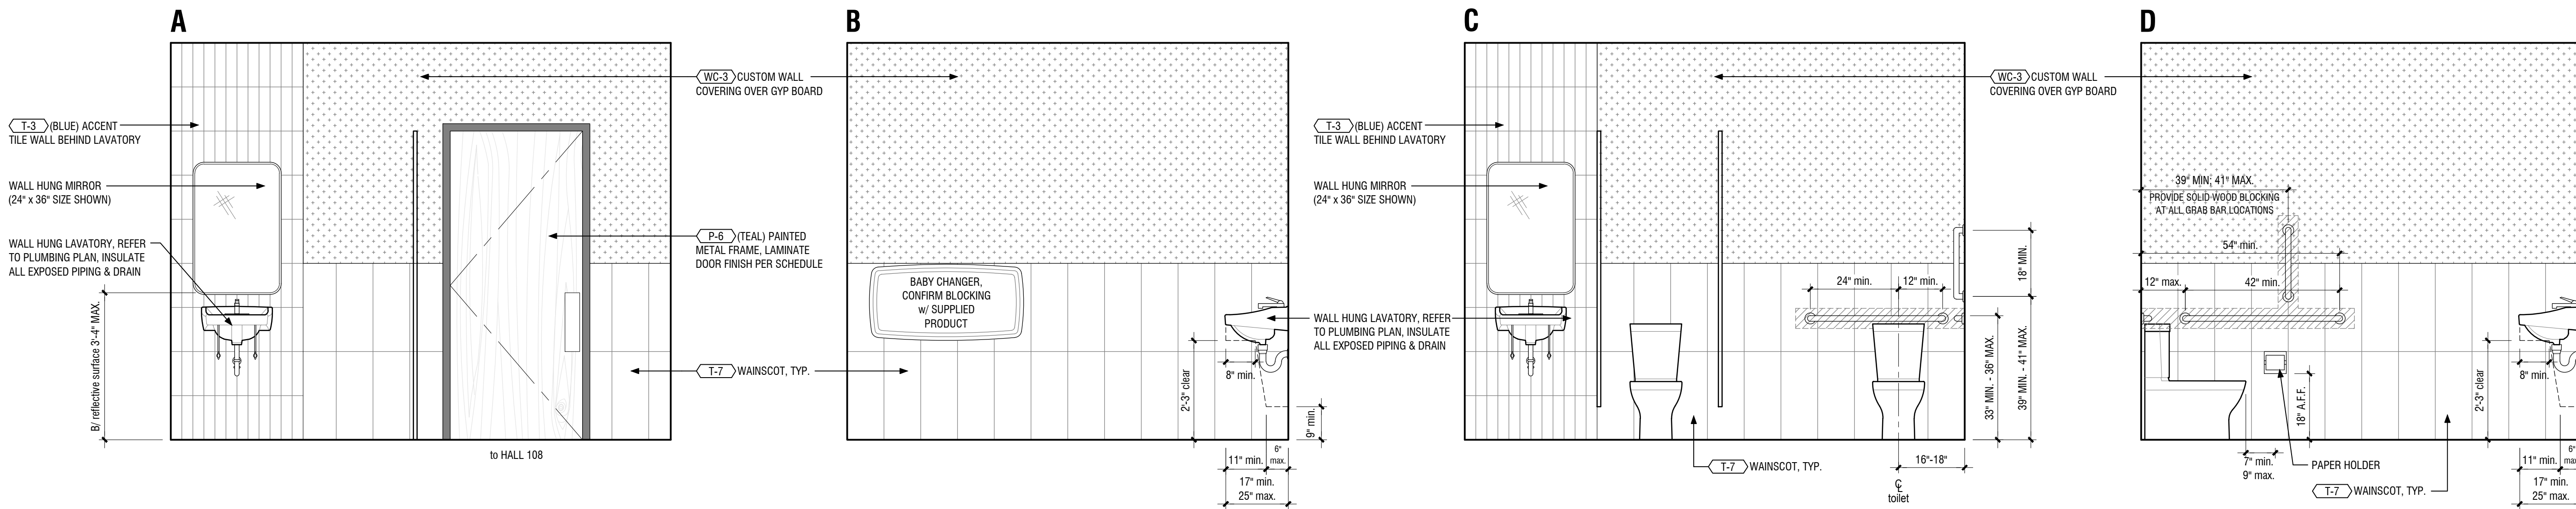


6 Women's Room 110 Interior Elevations
A3.0 scale: 1/2" = 1'-0"

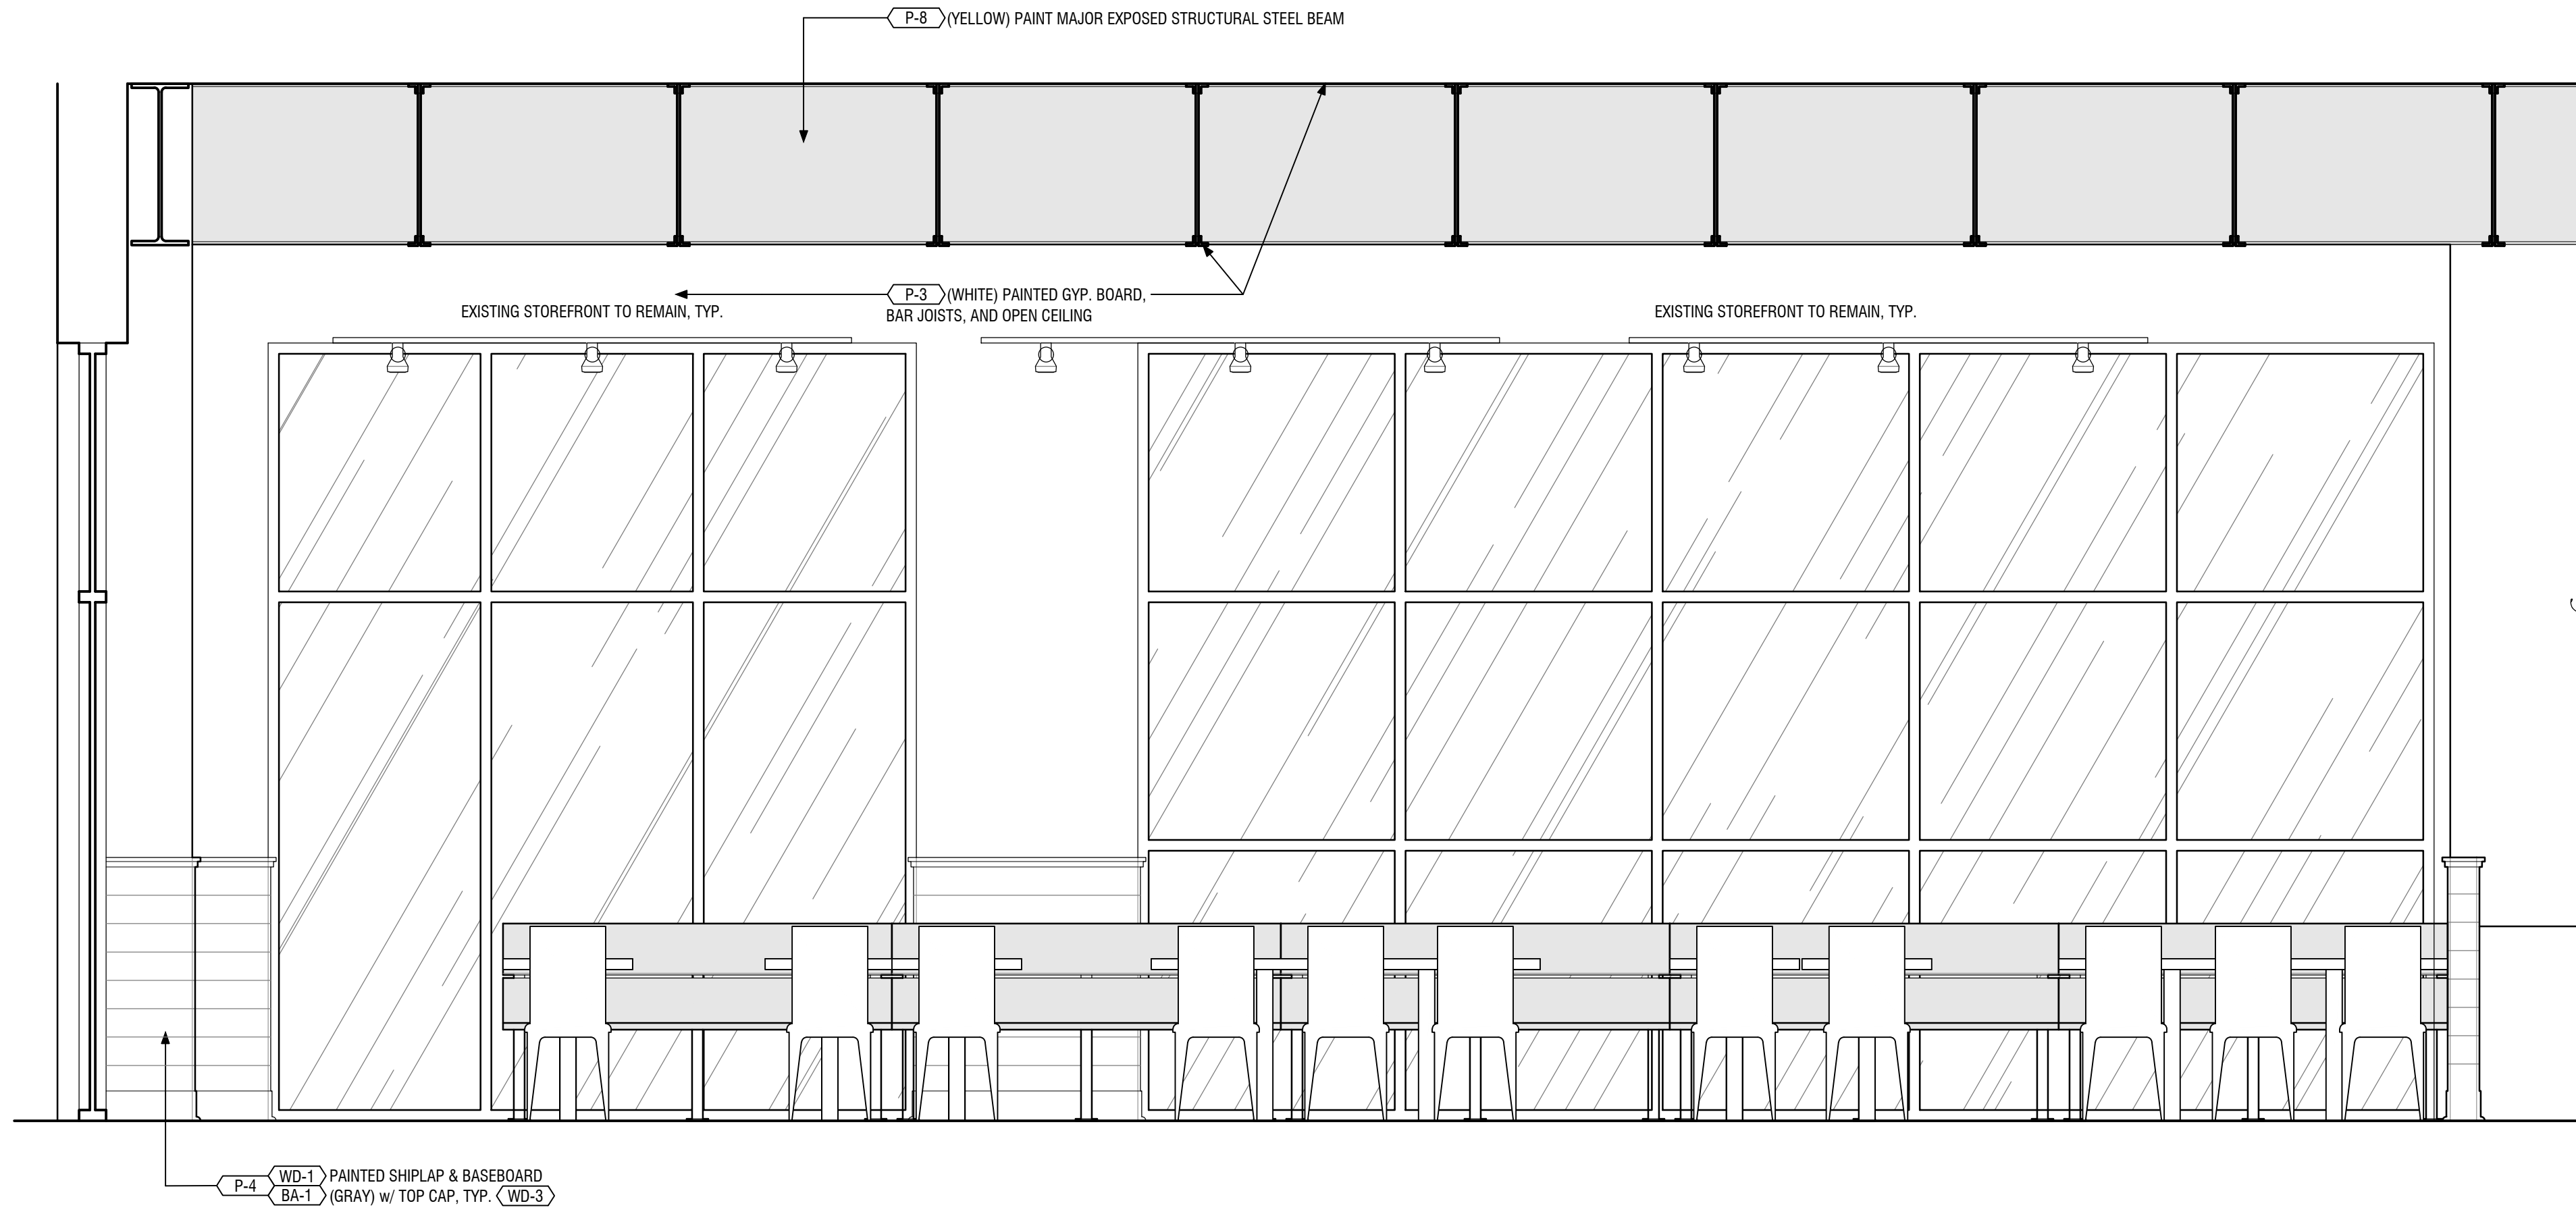

1 Dining Room 101 - Side Wall Elevation (partial)
A3.1 scale: 1/2" = 1'-0"

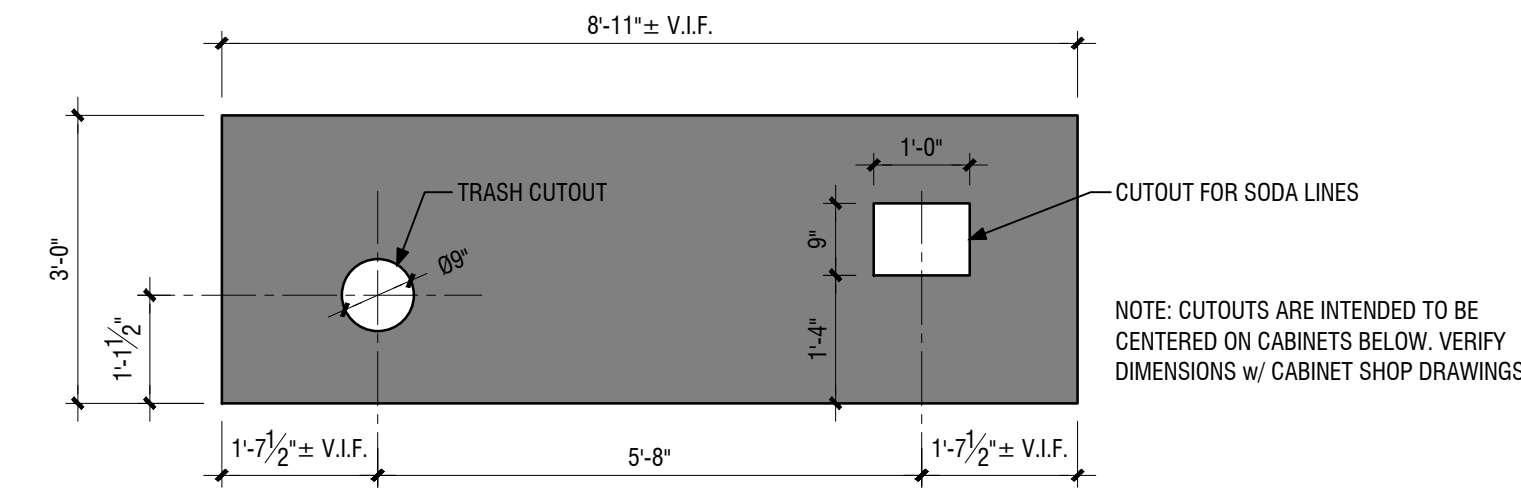


Soda Counter Plan Detail

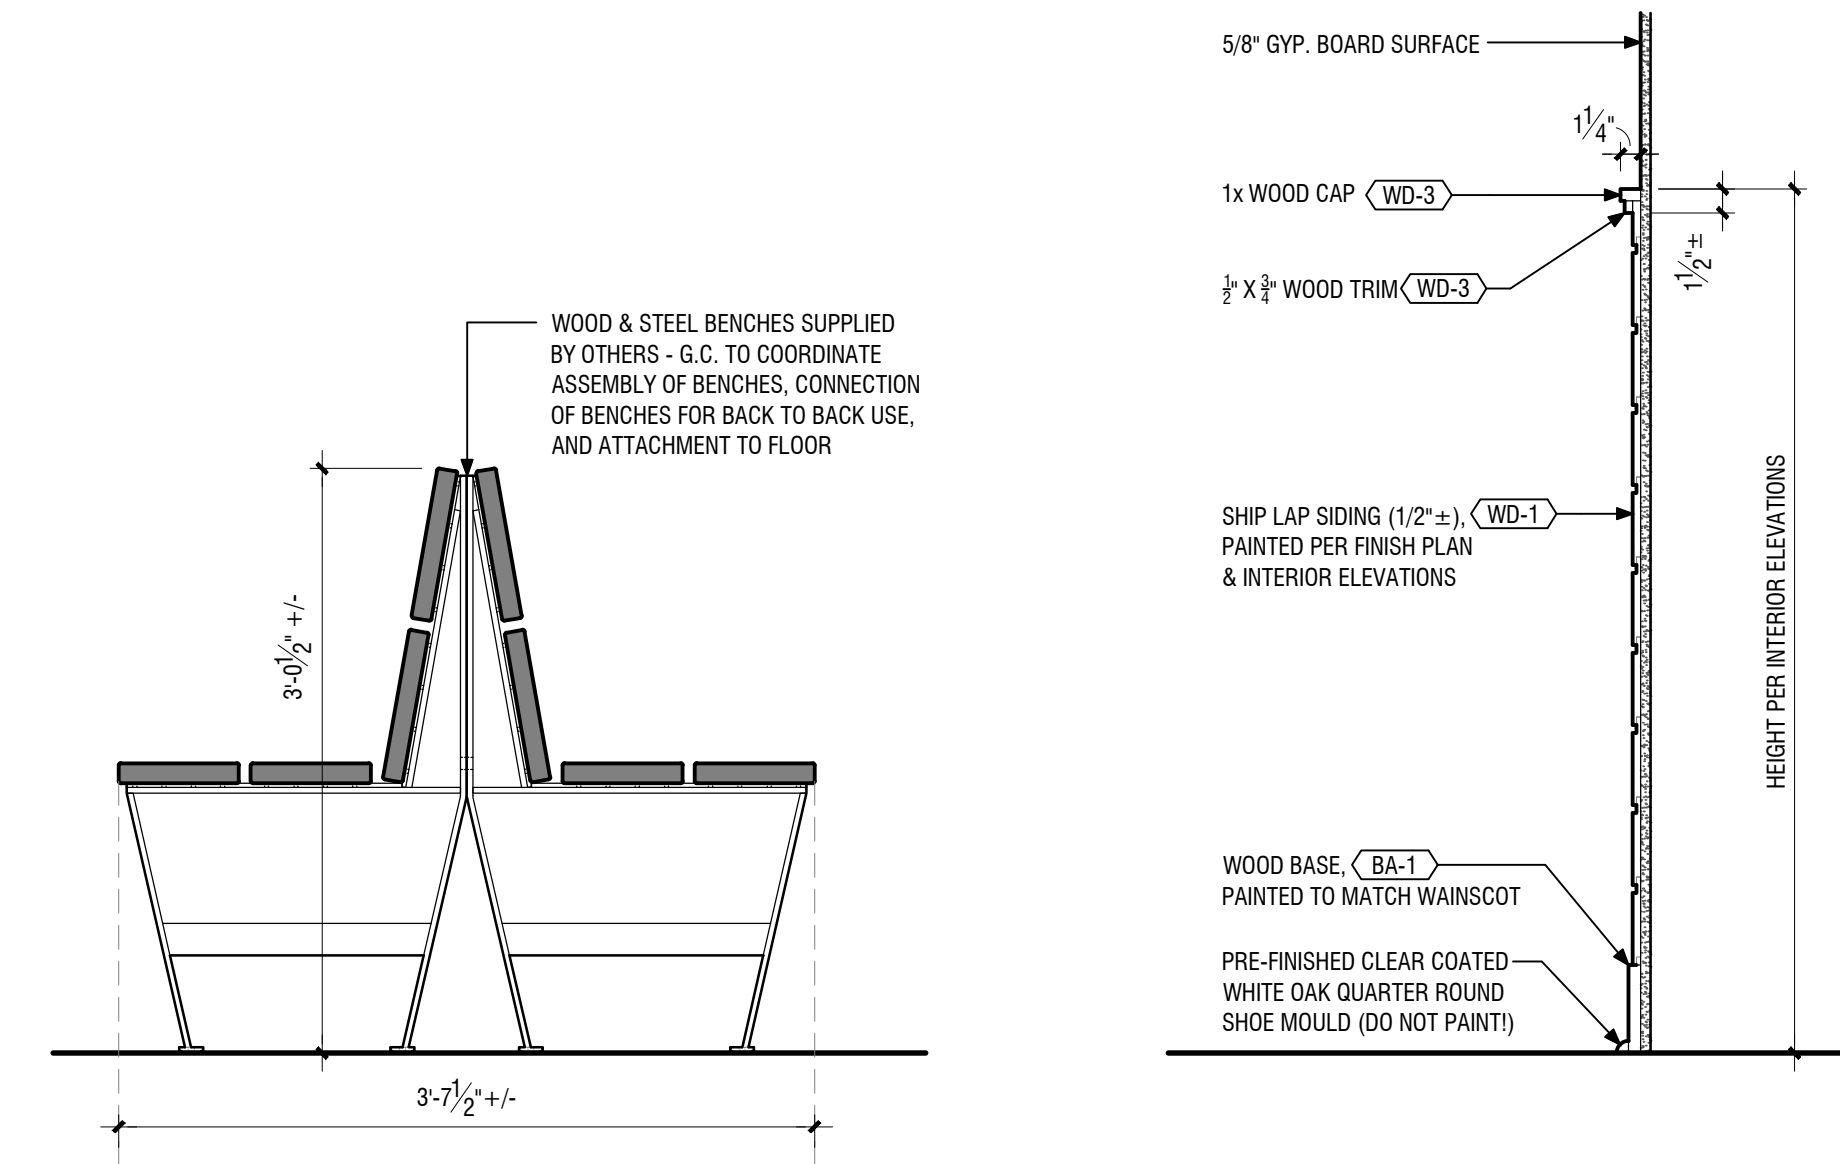


3 Booth Seating Detail
A3.1 scale: 1" = 1'-0"


4 Typ. Wainscot Detail
A3.1 scale: 1" = 1'-0"

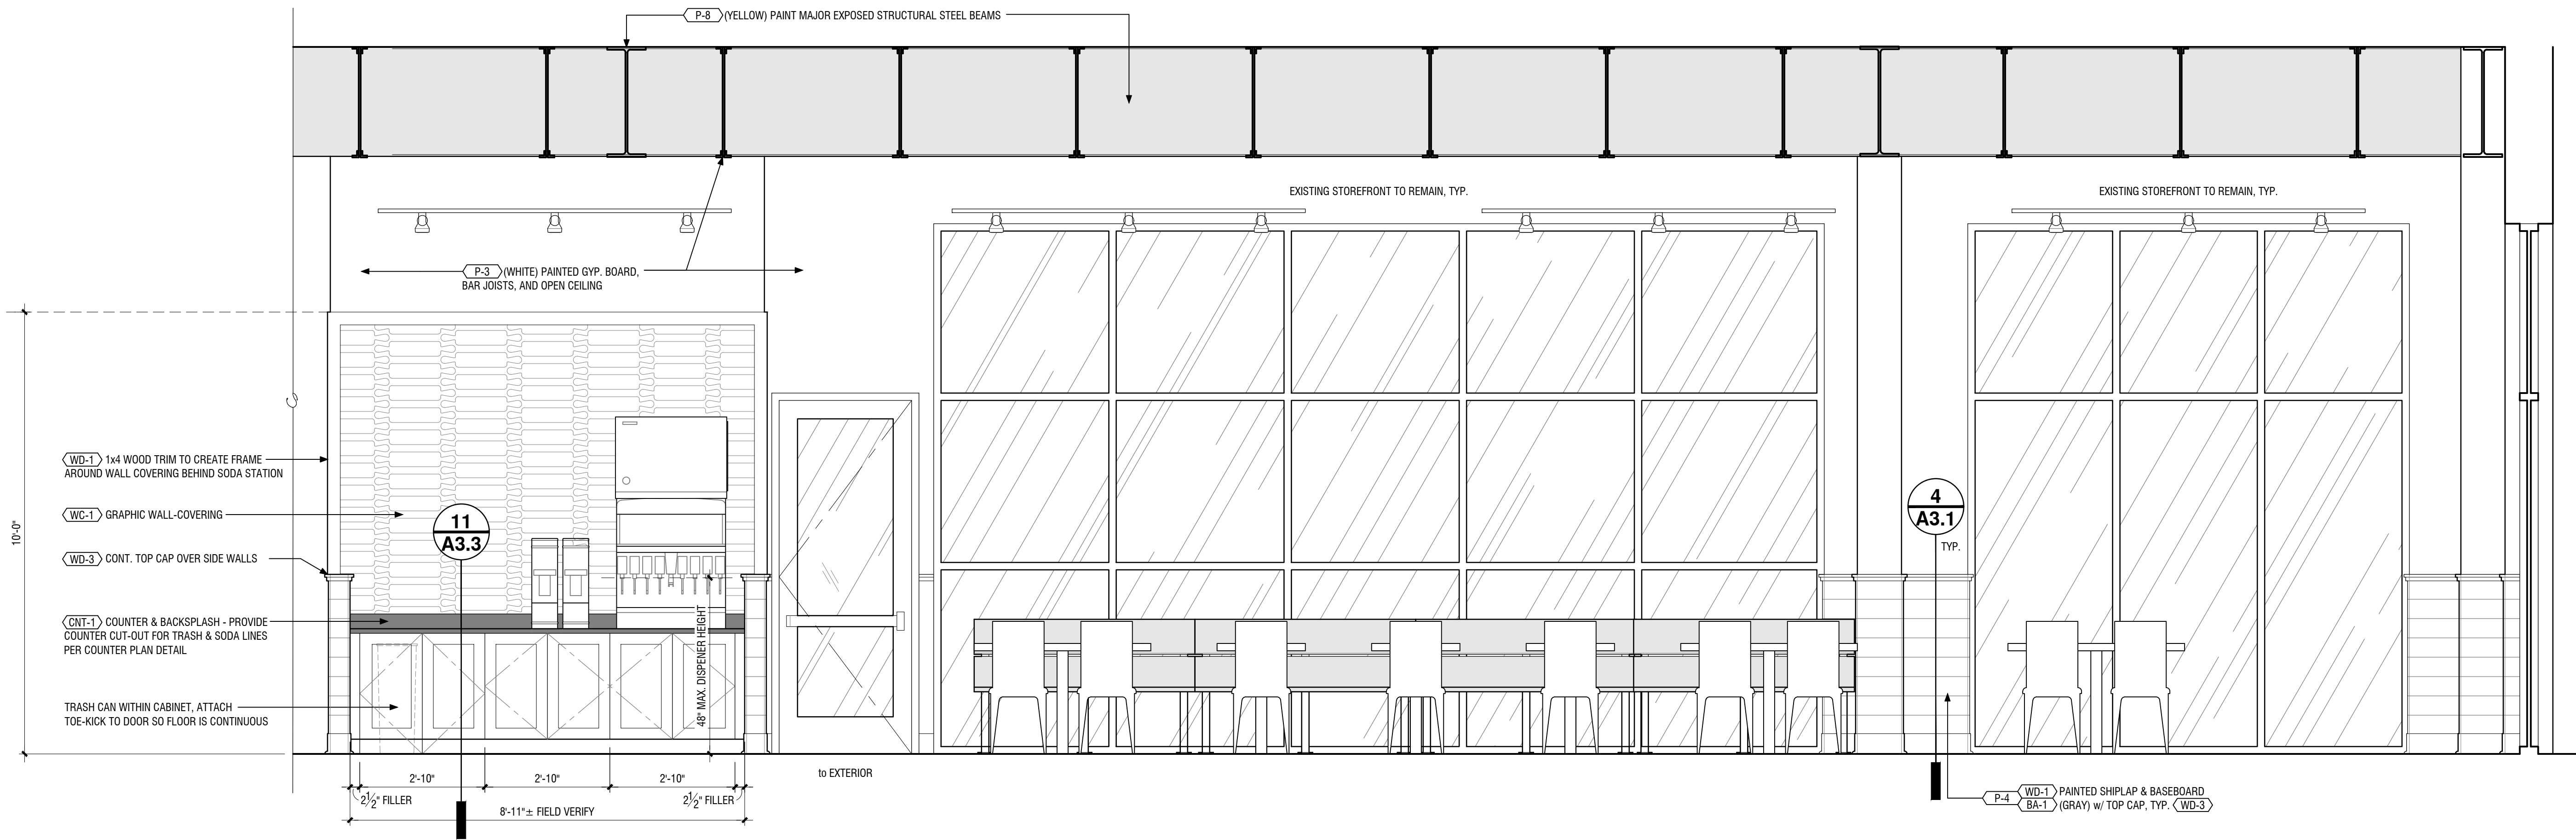


2 Dining Room 101 - Side Wall Elevation (cont.)
A3.1 scale: 1/2" = 1'-0"

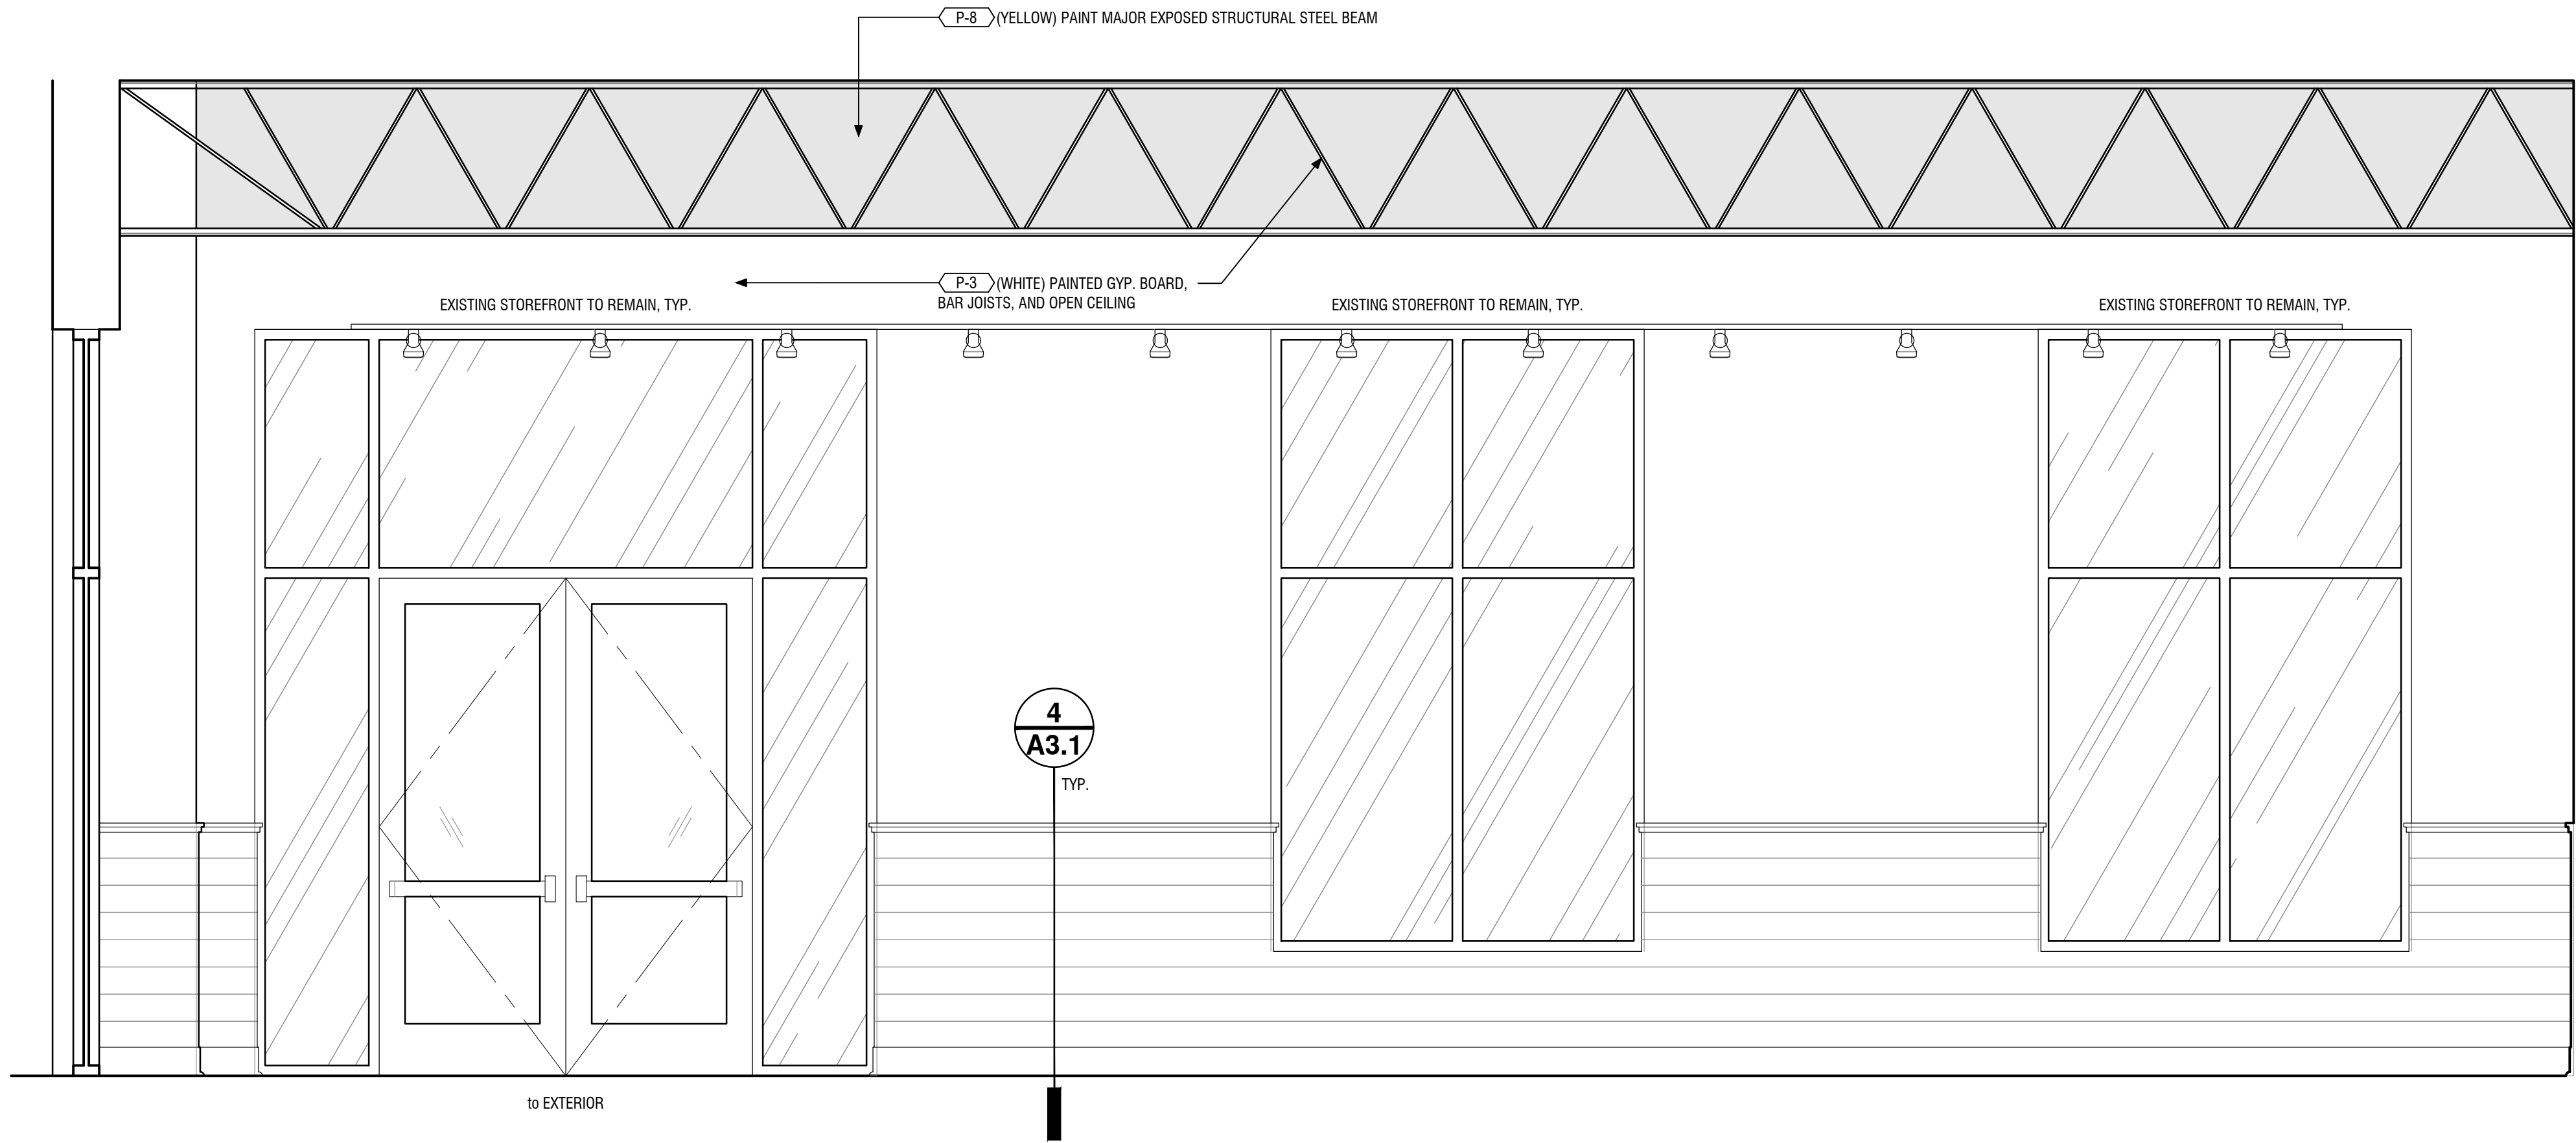


1 Dining Room 101 - Main Entrance Wall Elevation
A3.2 scale: 1/2" = 1'-0"

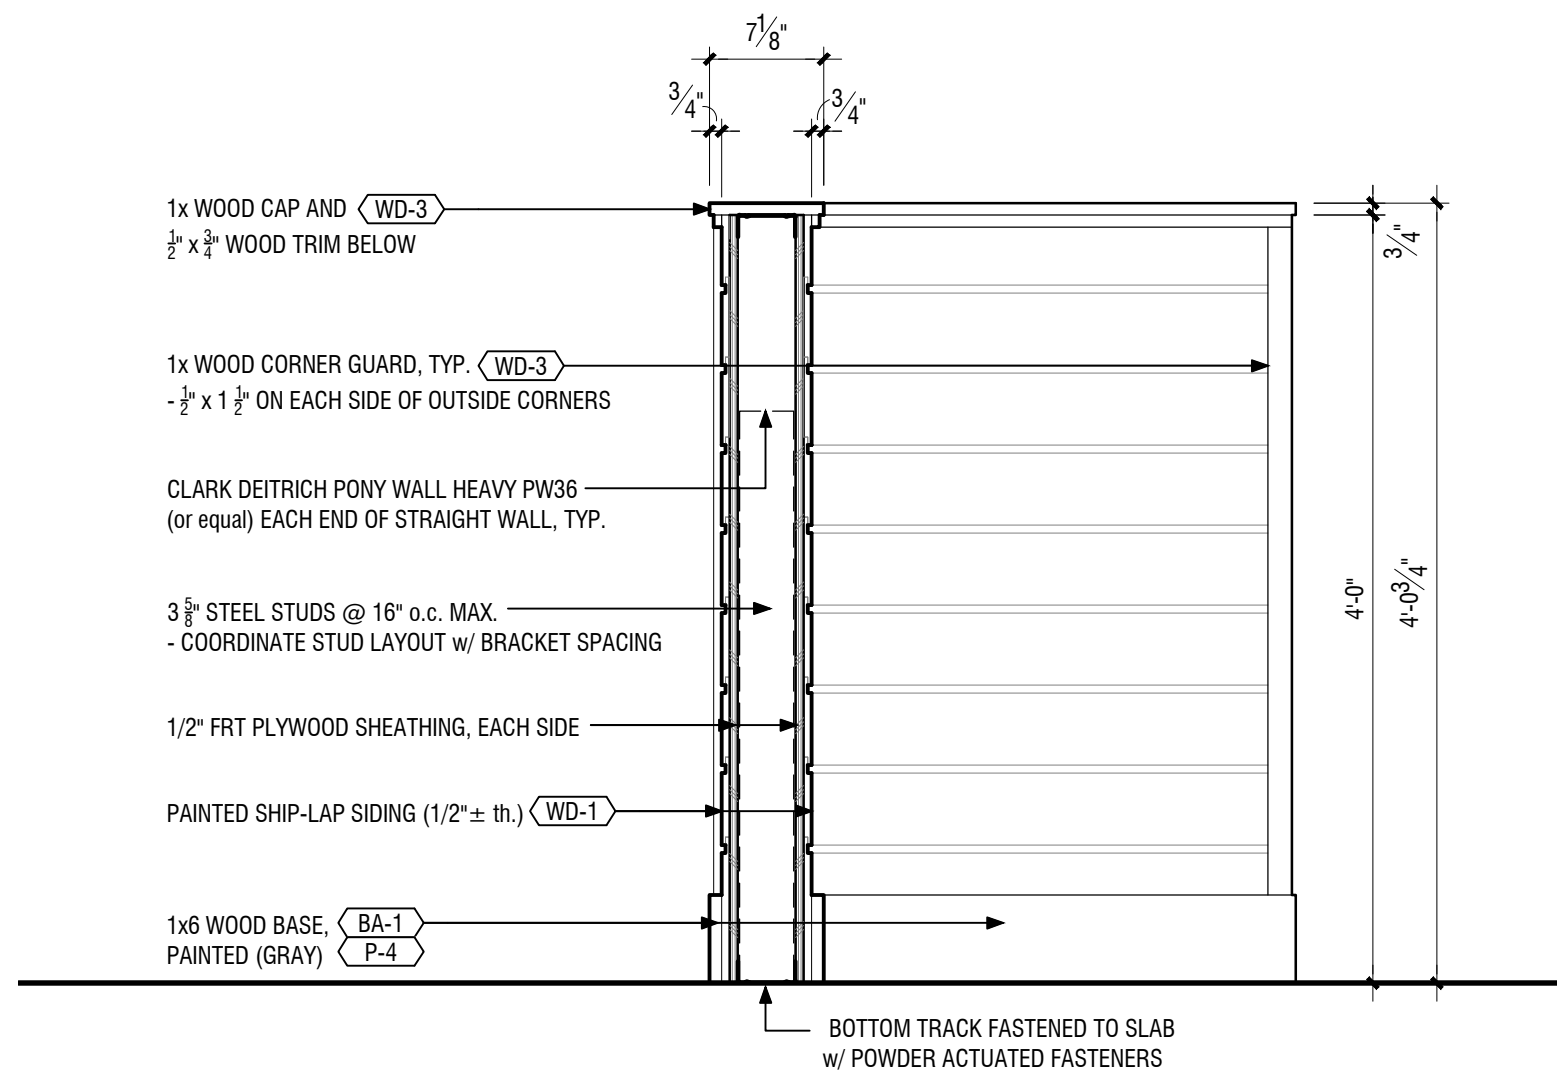



3 Half Wall Detail
A3.2 scale: 1" = 1'-0"

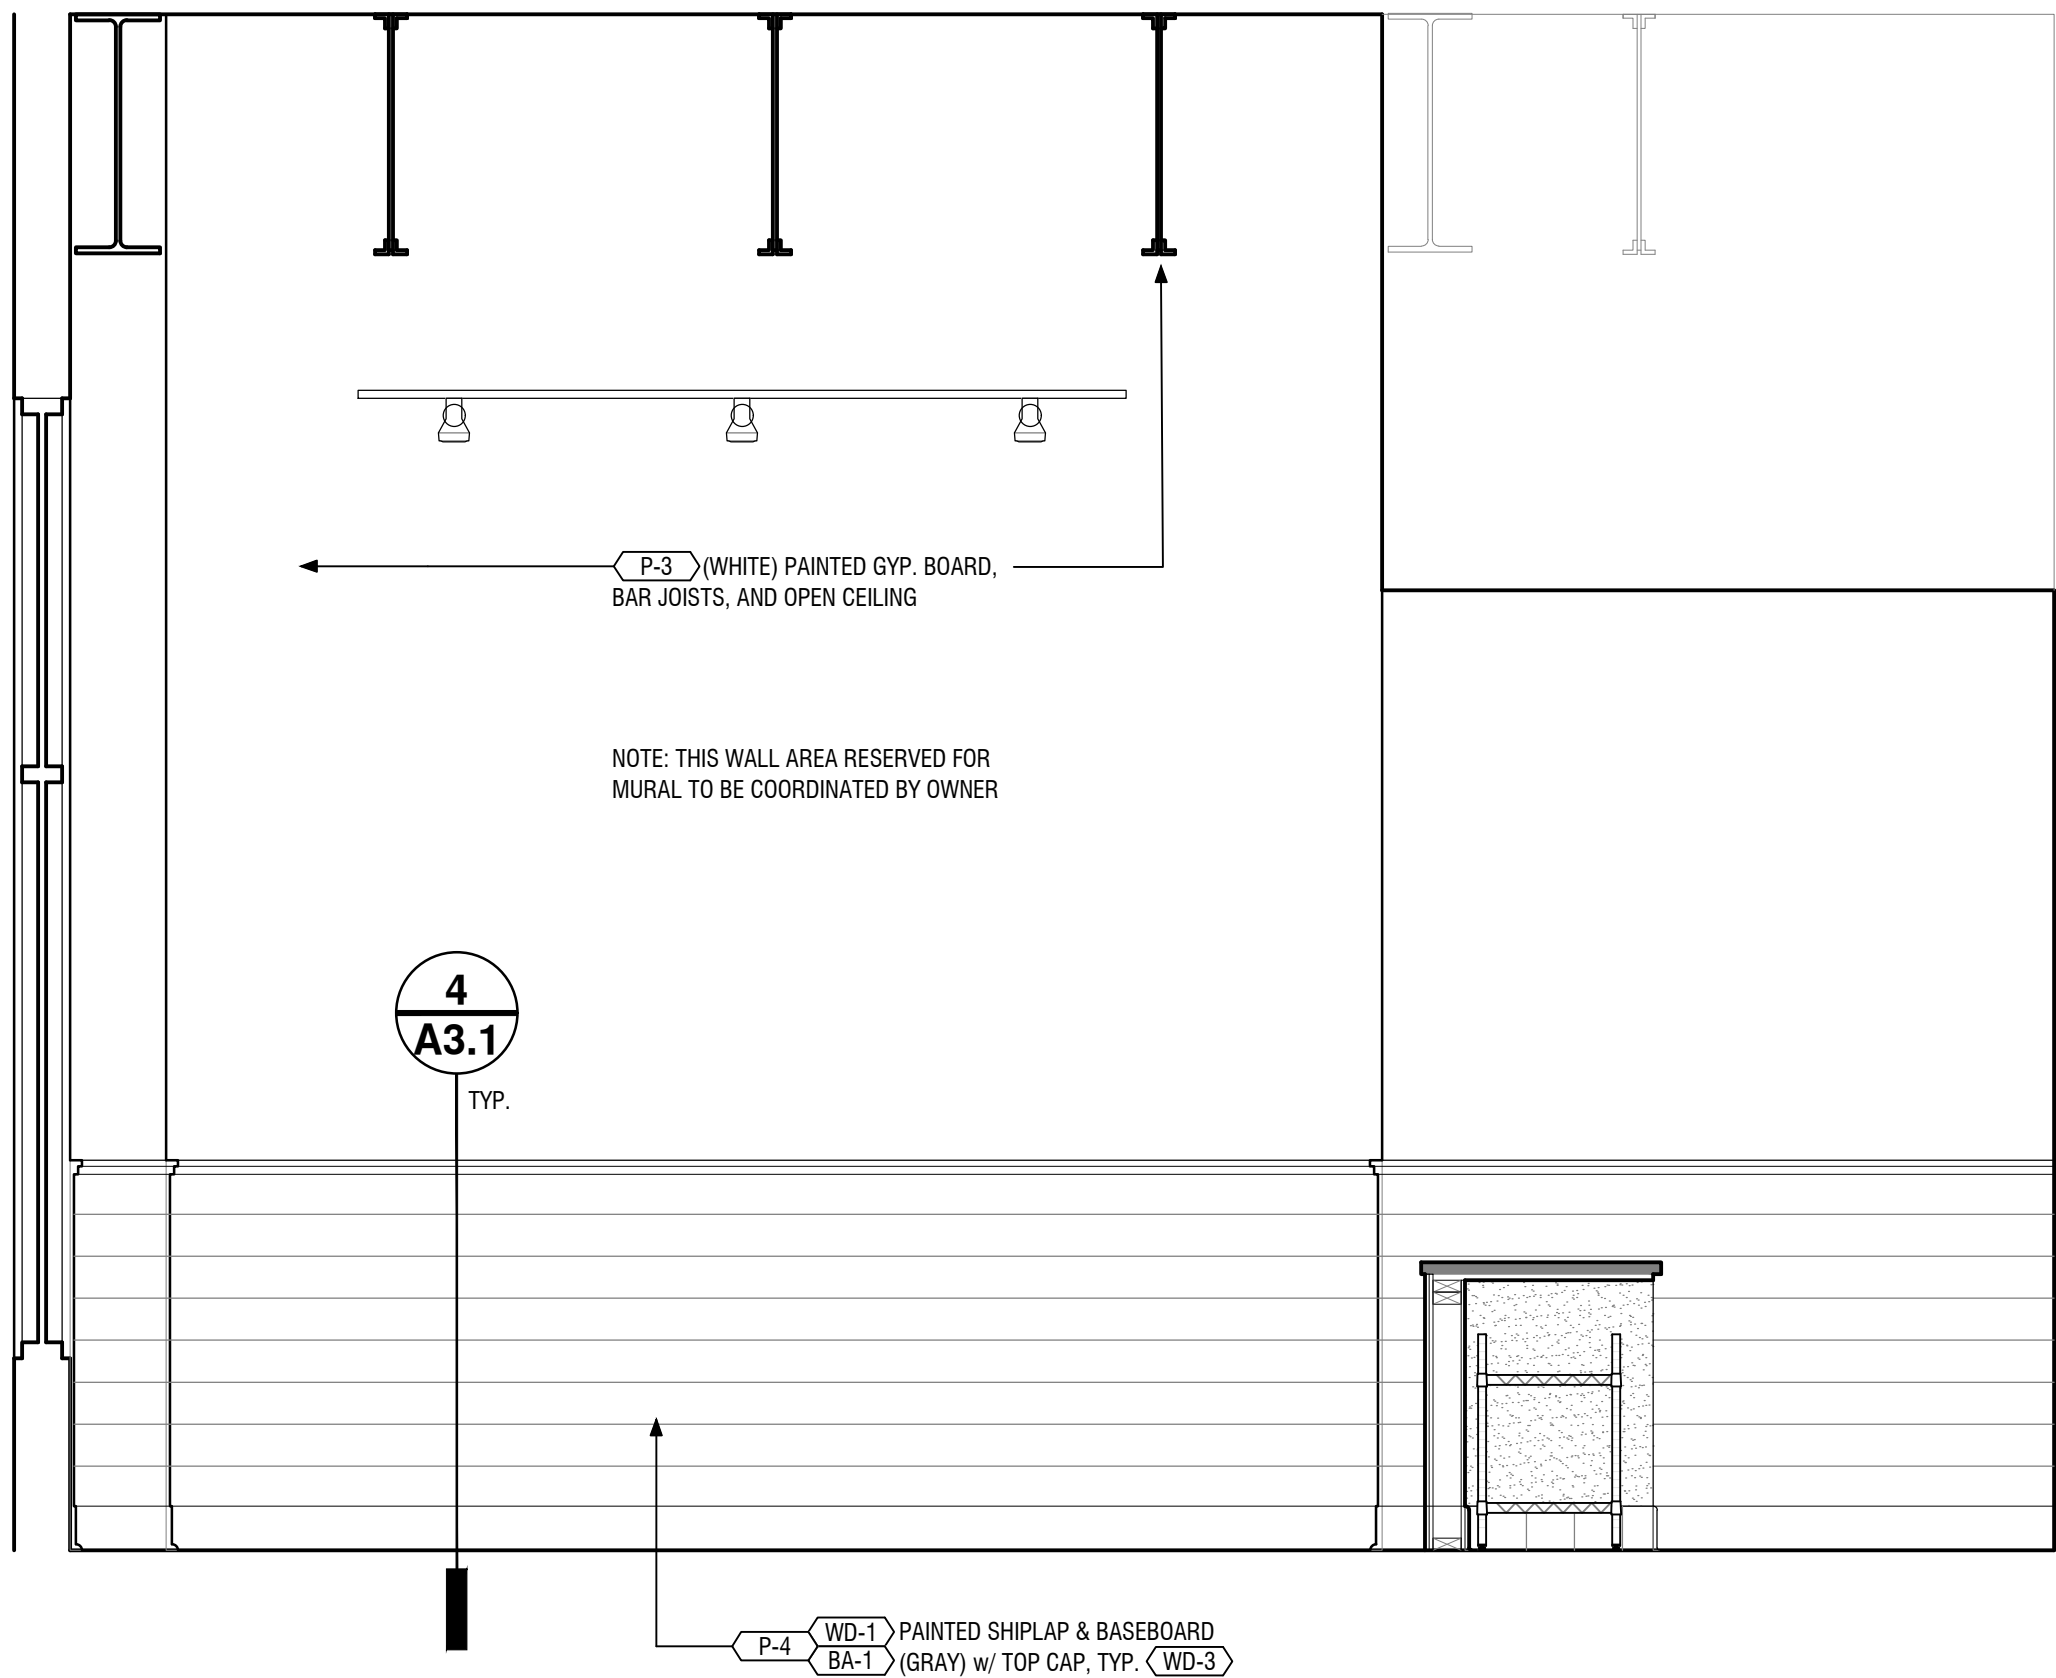


2 Dining Room 101 - Storefront Elevation
A3.2 scale: 1/2" = 1'-0"

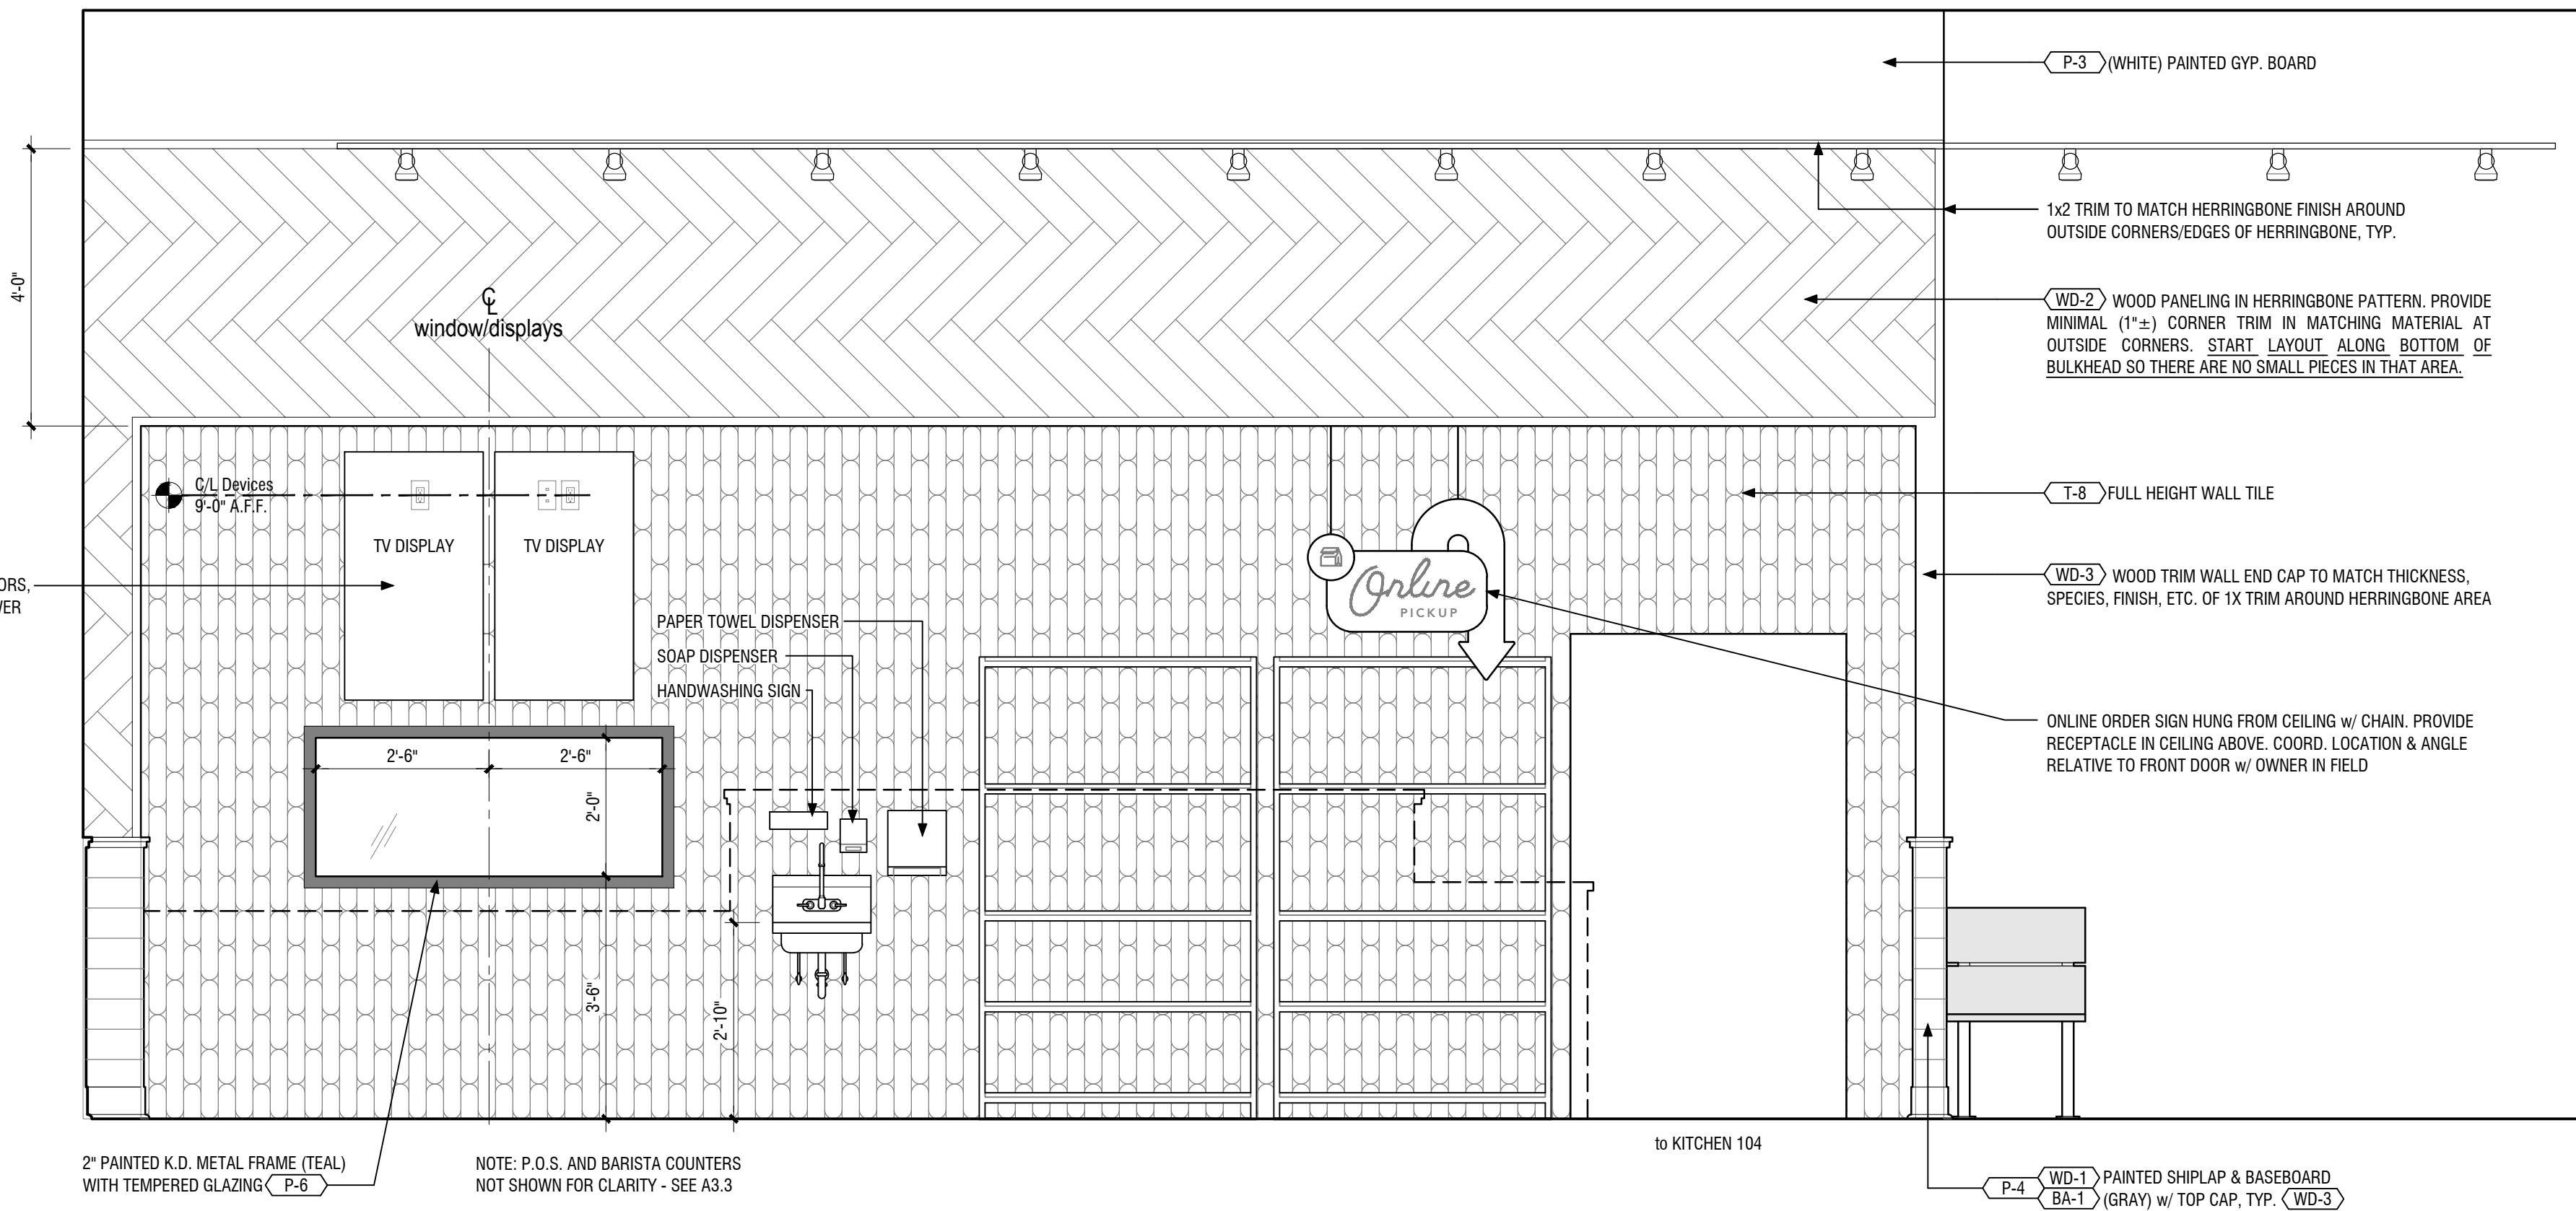


3 Dining Room 101 - Storefront Elevation
A3.2 scale: 1/2" = 1'-0"

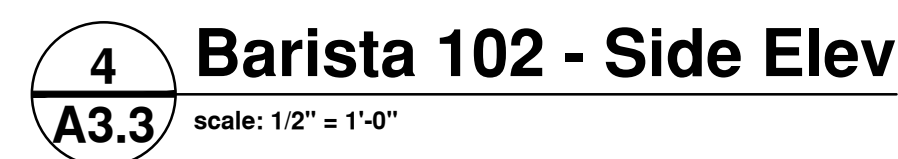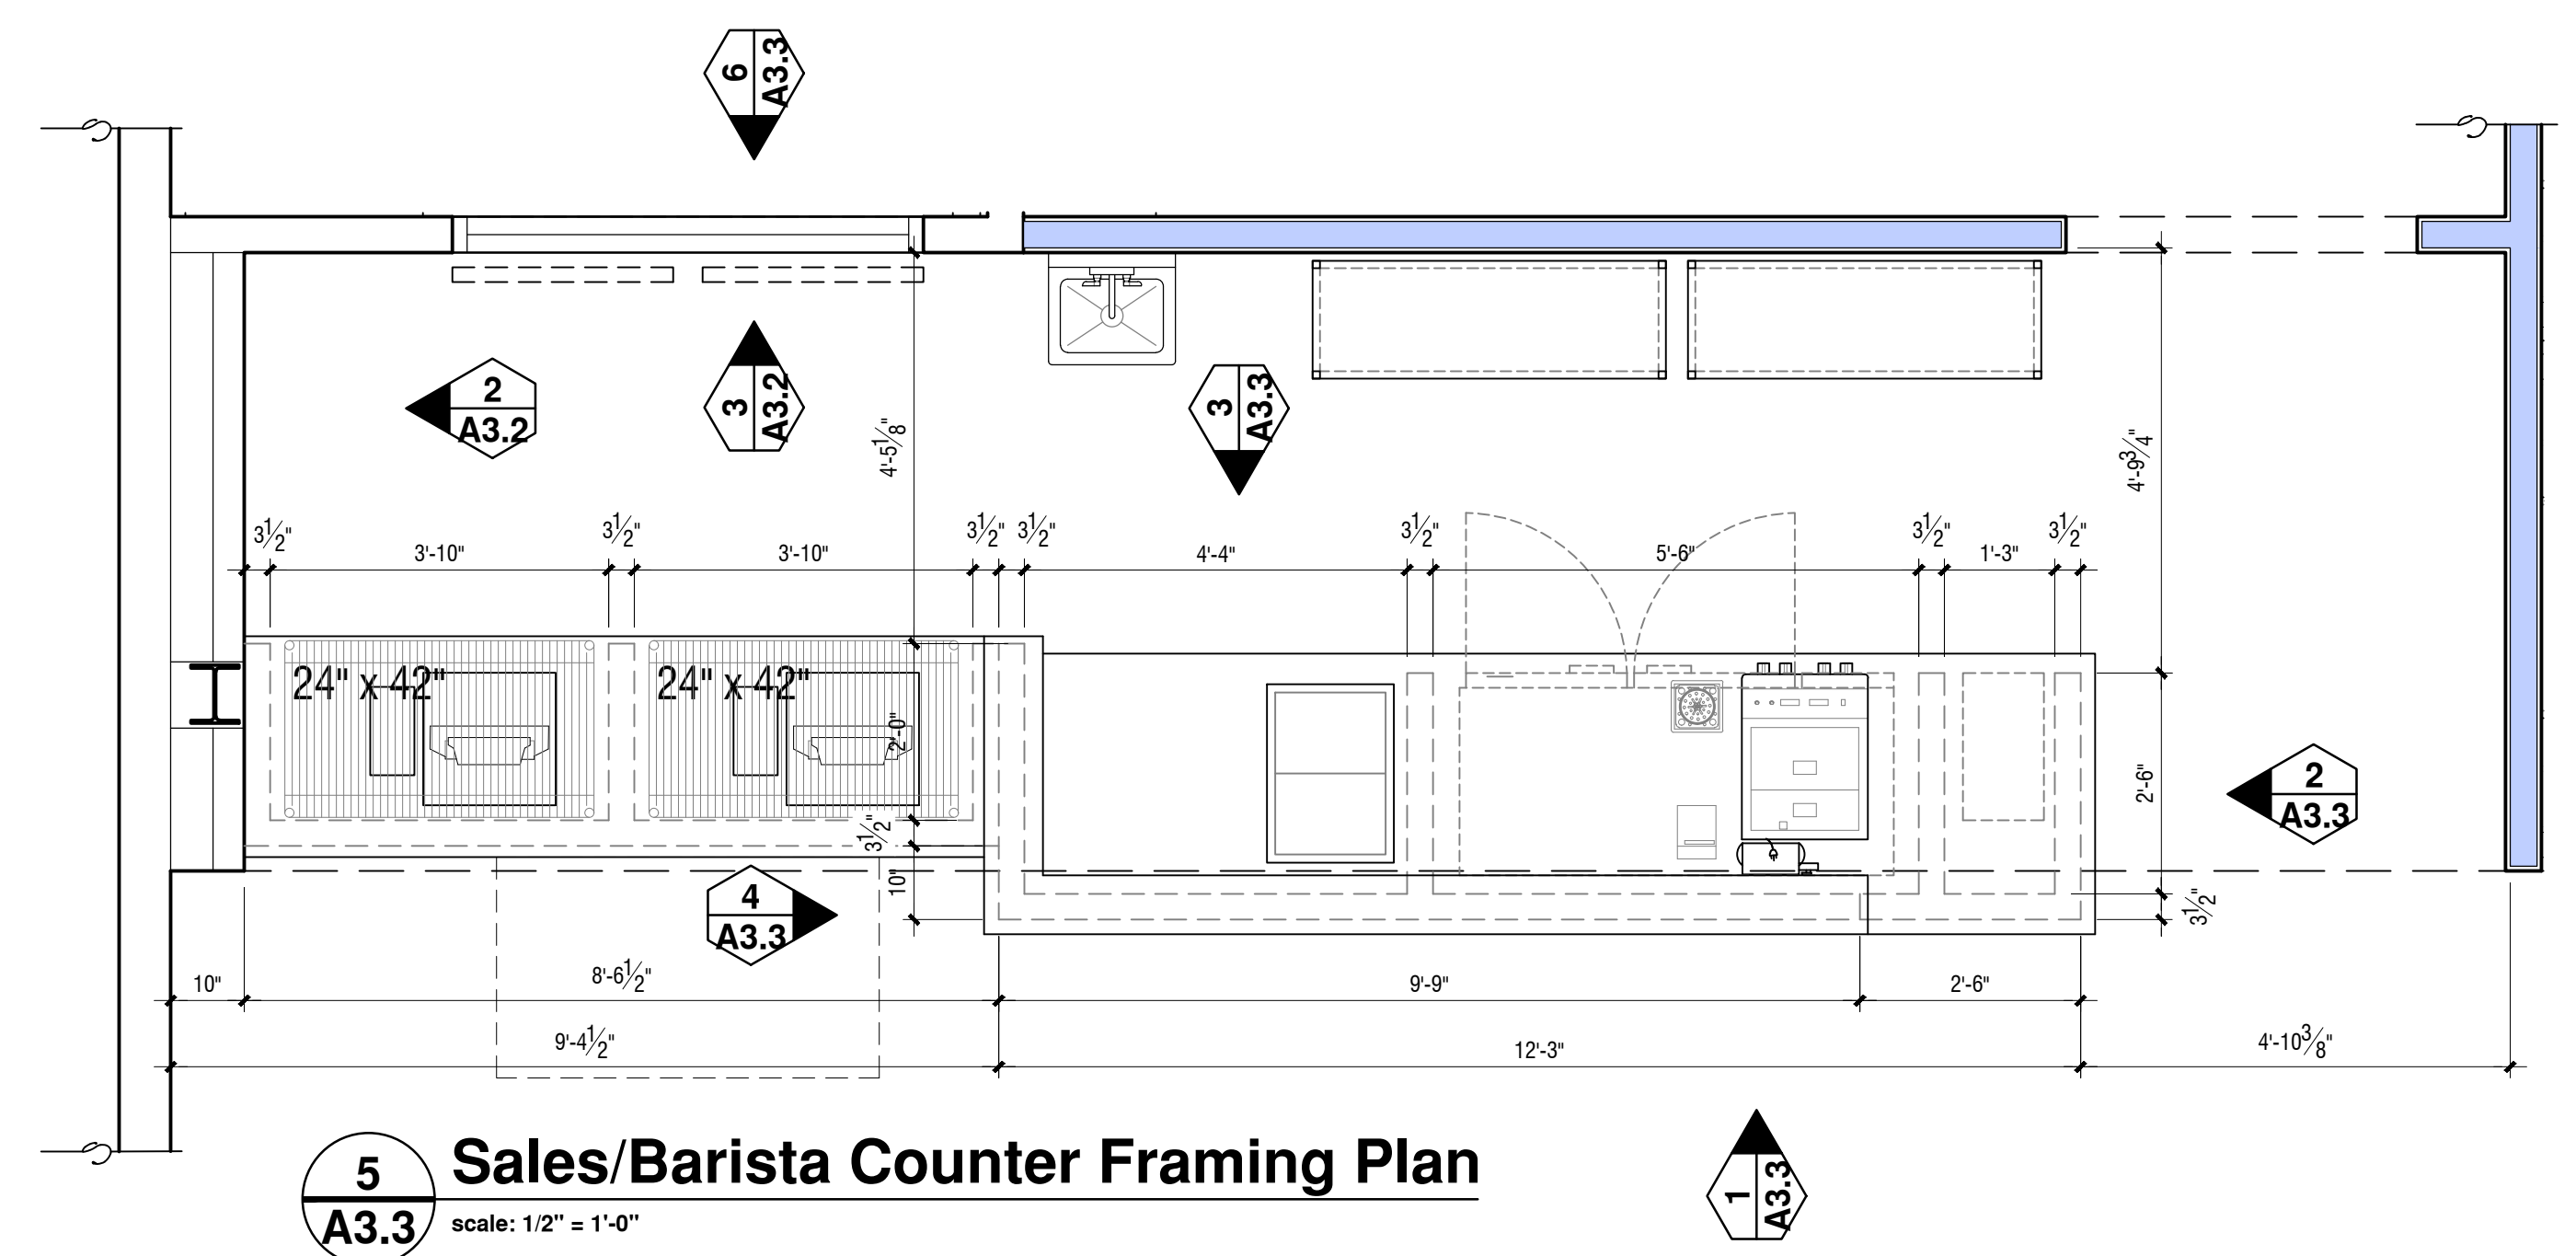


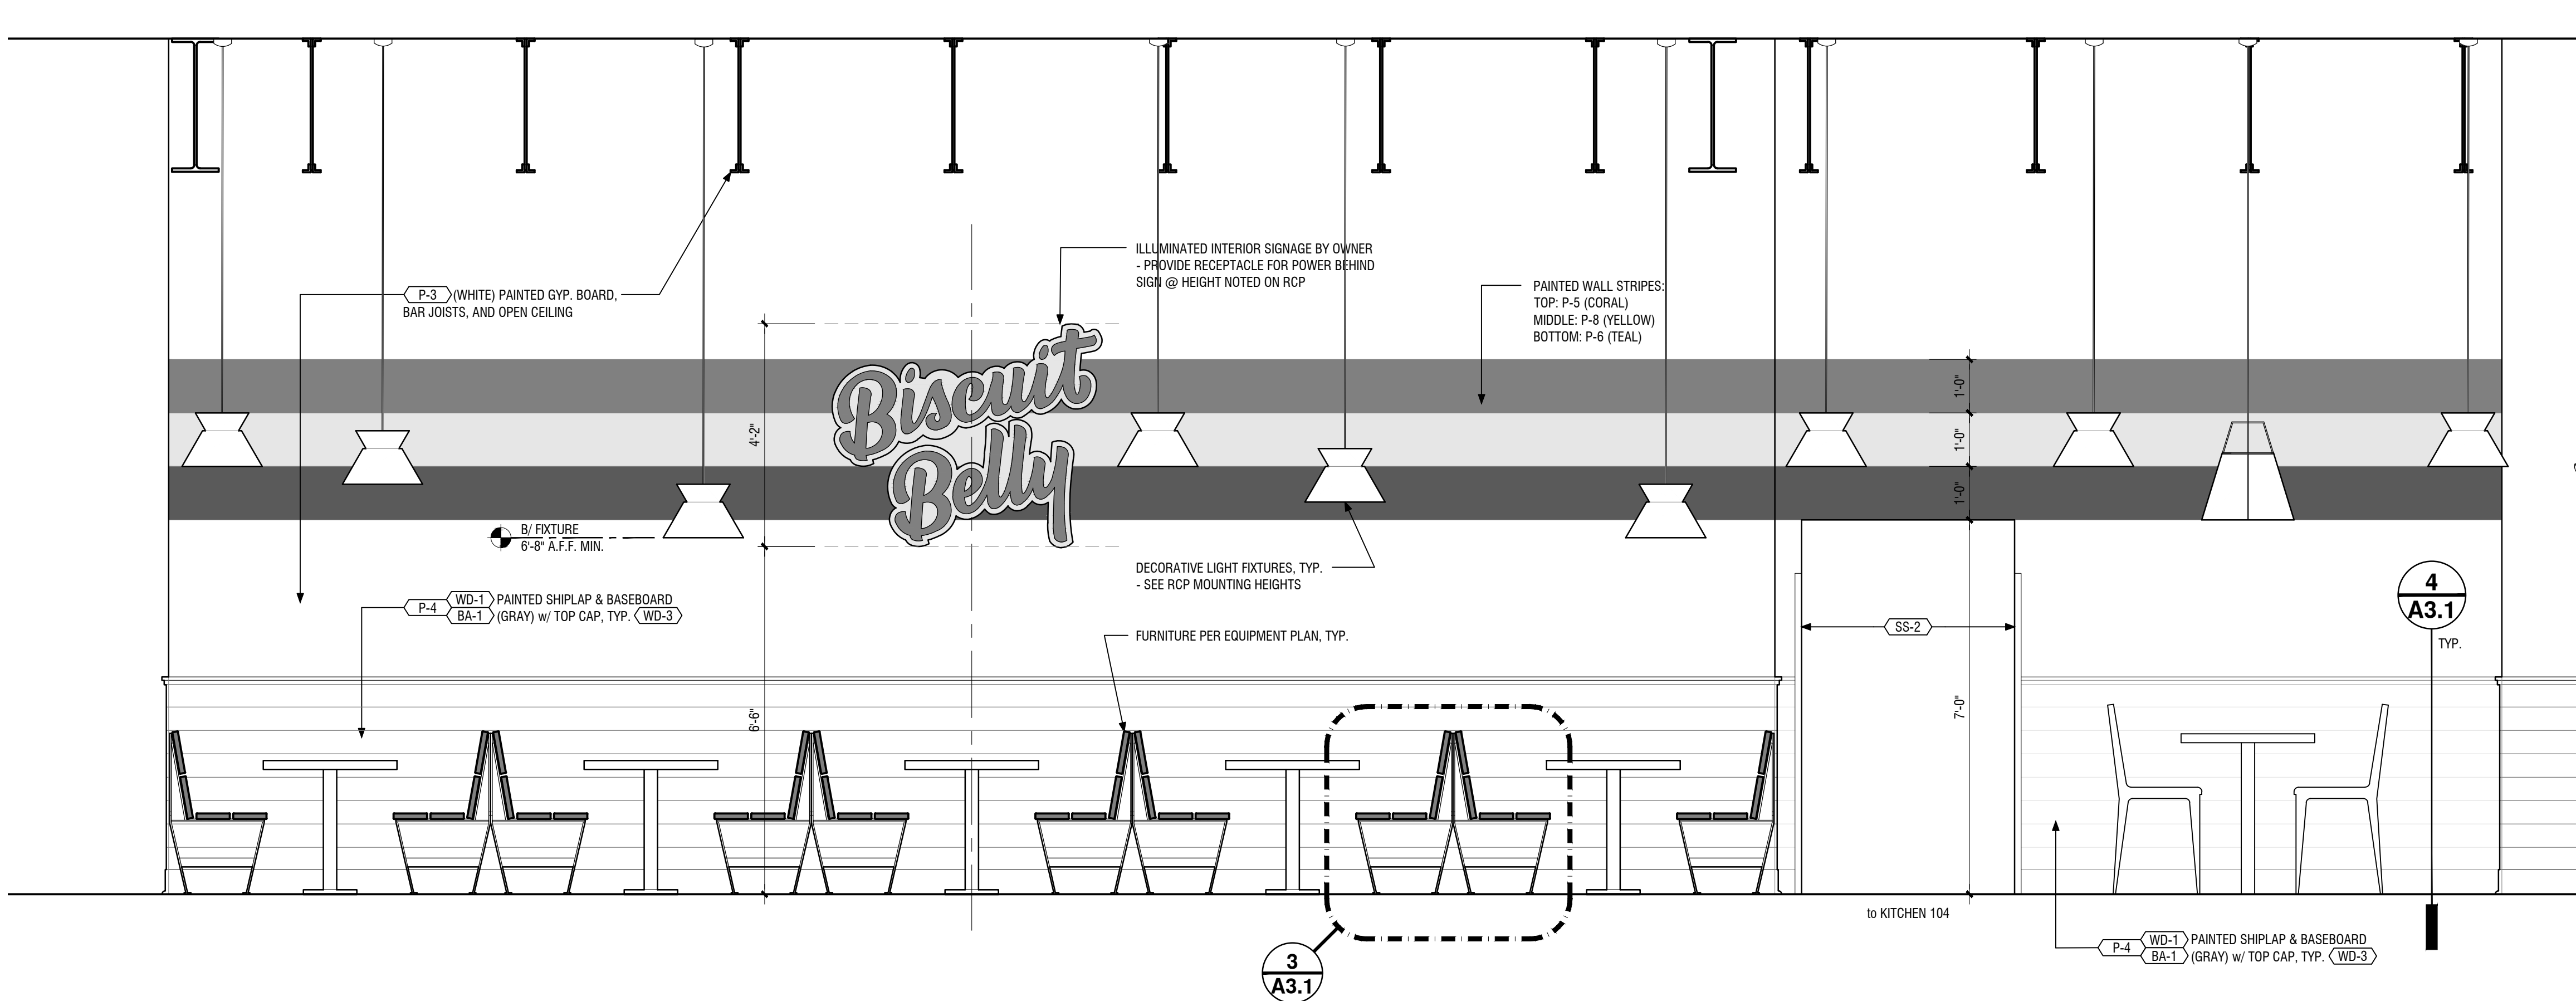


1 Dining Room 101 - Side Wall Elevation
A3.4 scale: 1/2" = 1'-0"

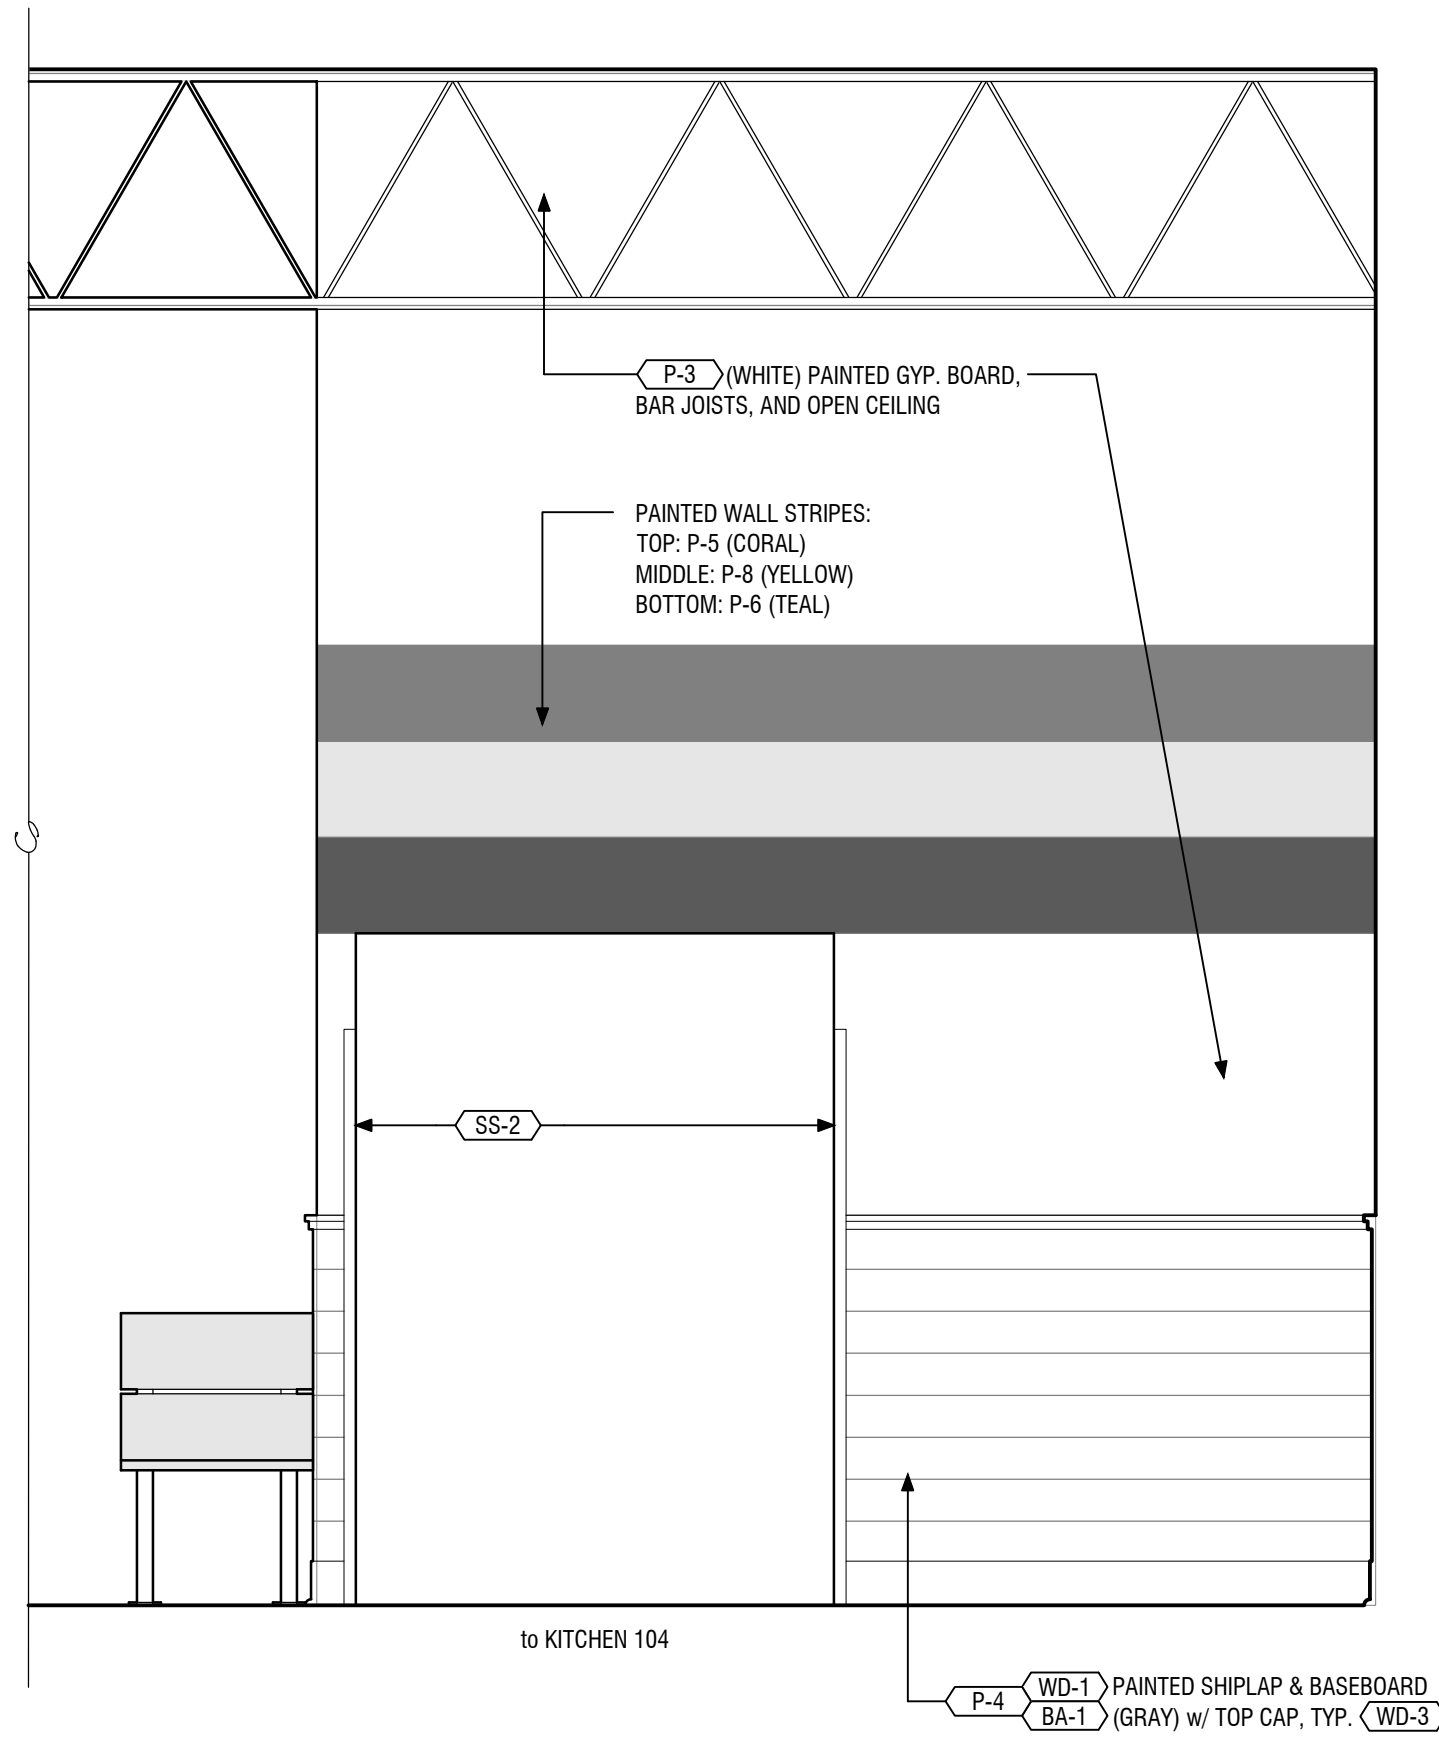


2 Dining Room 101
A3.4 scale: 1/2" = 1'-0"

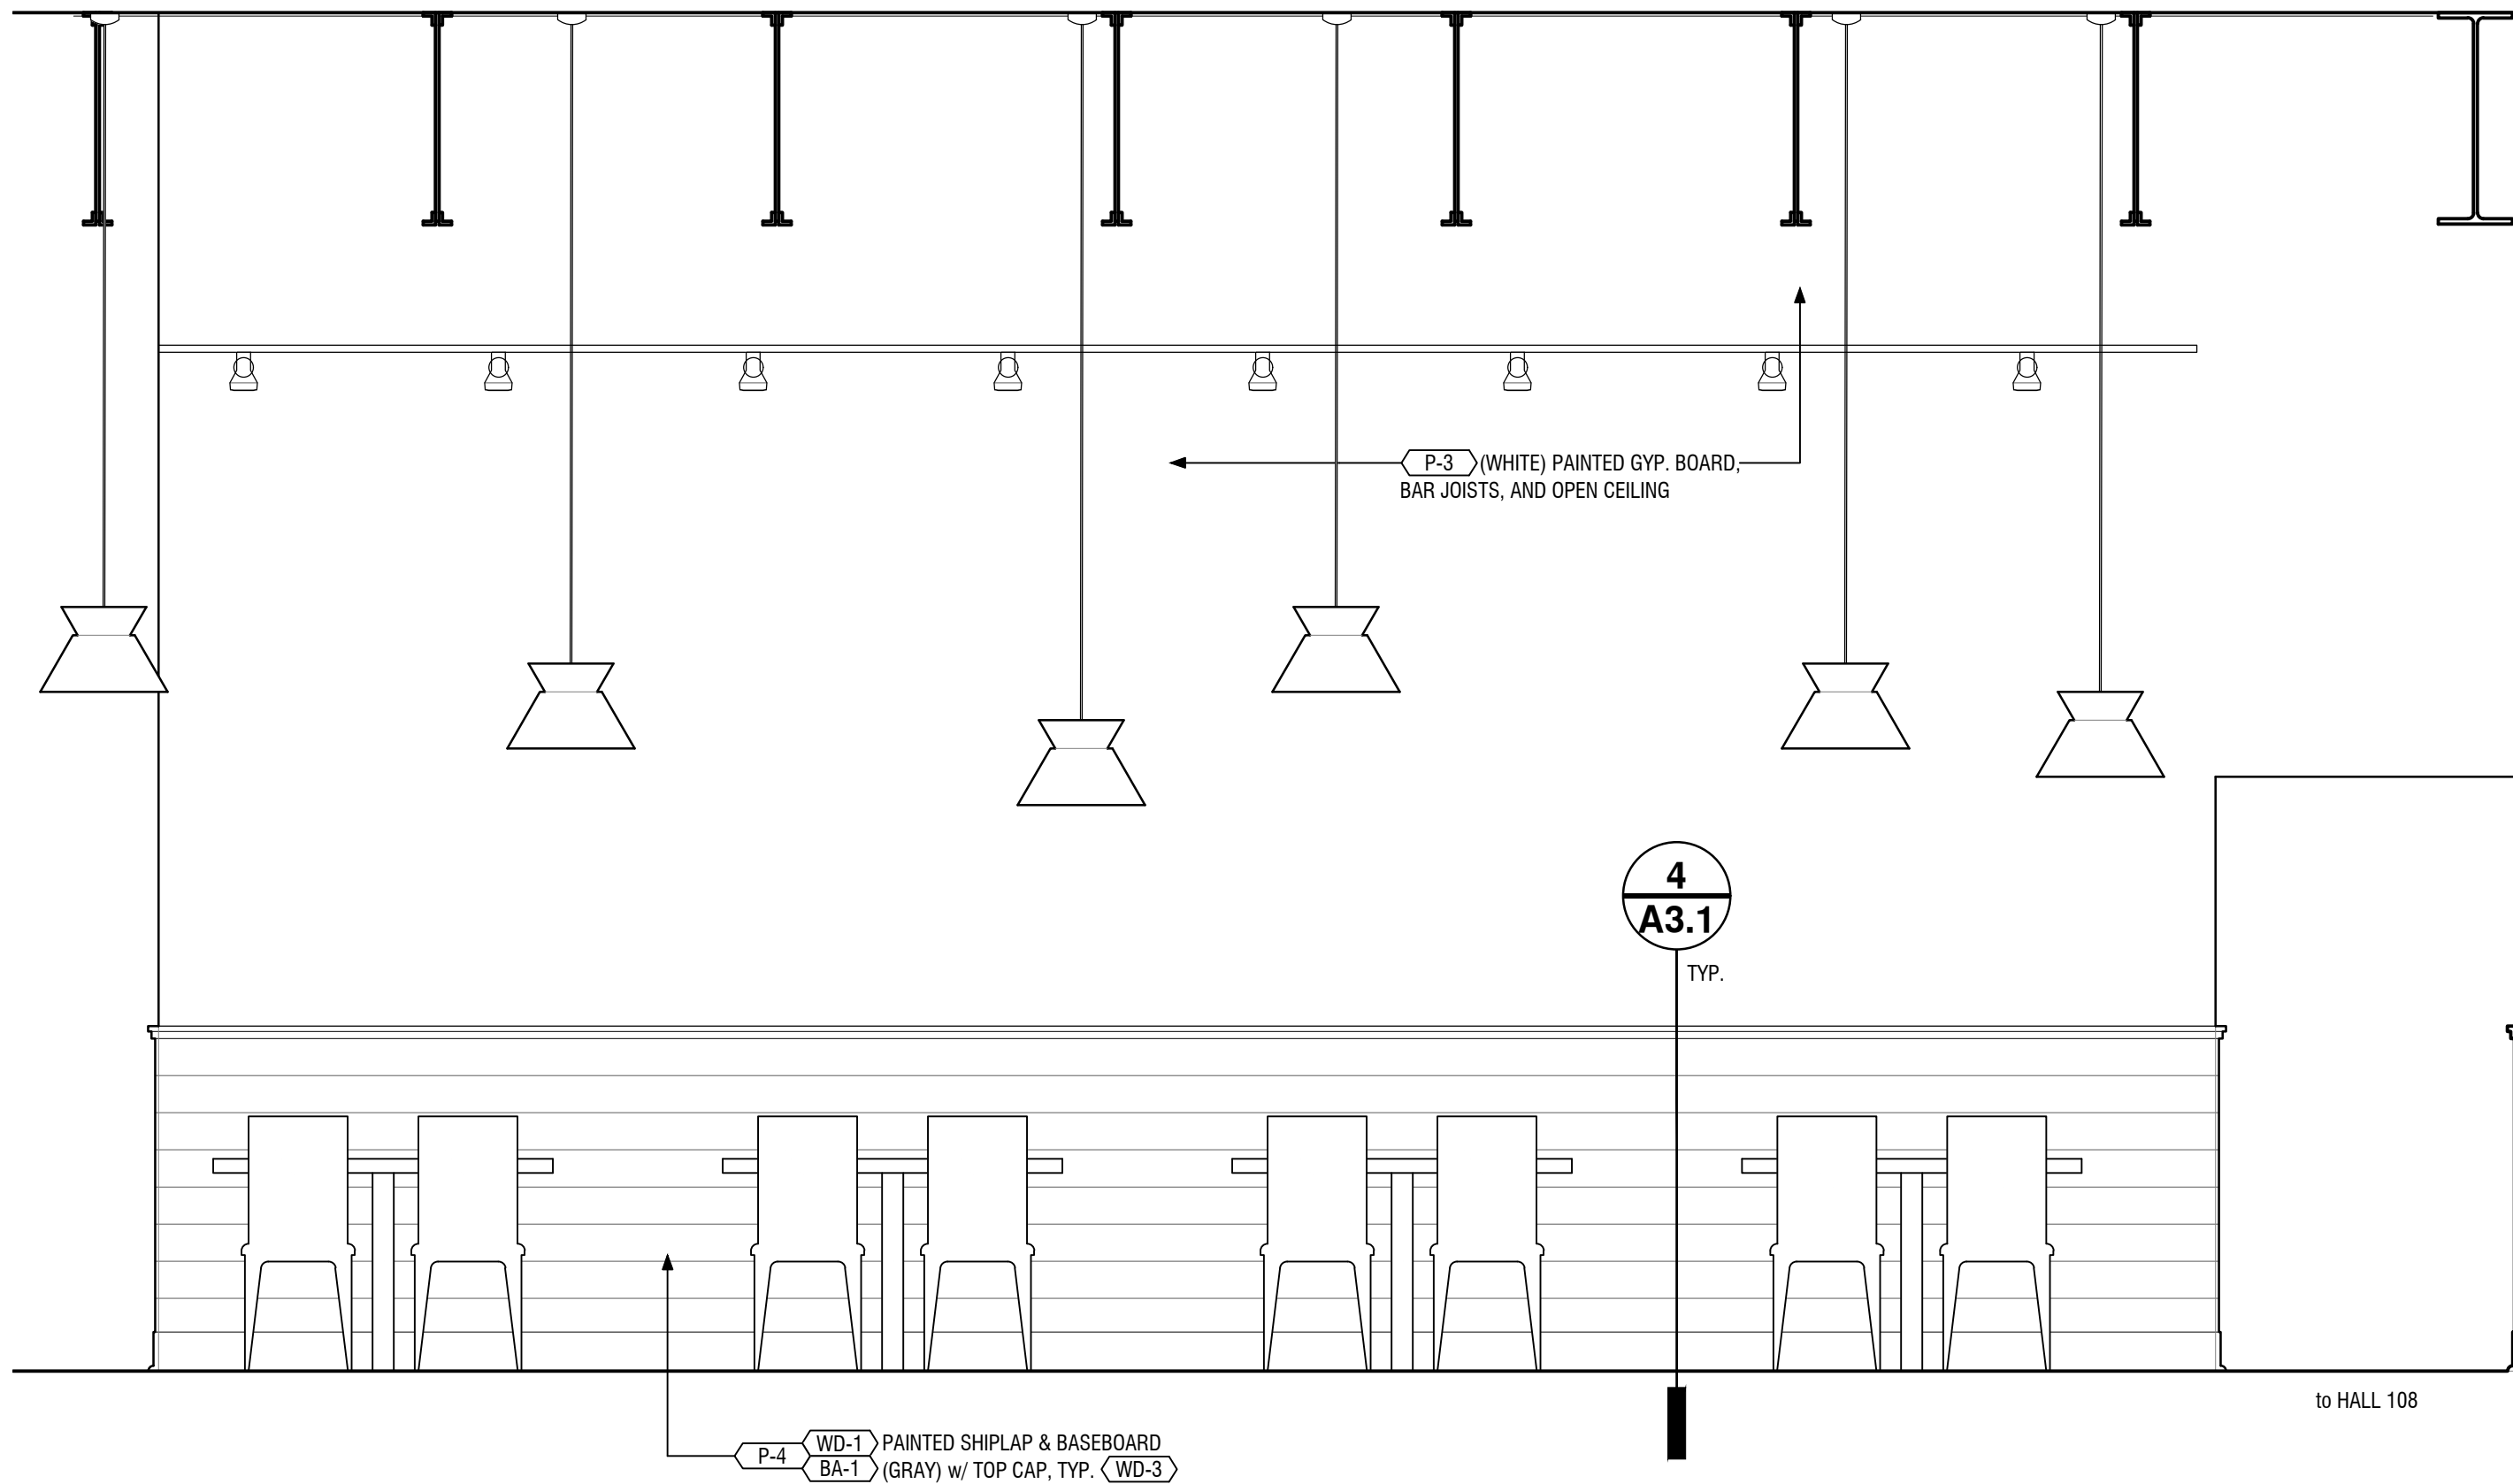


3 Dining Room 101 - Side Wall Elevation (cont.)
A3.4 scale: 1/2" = 1'-0"

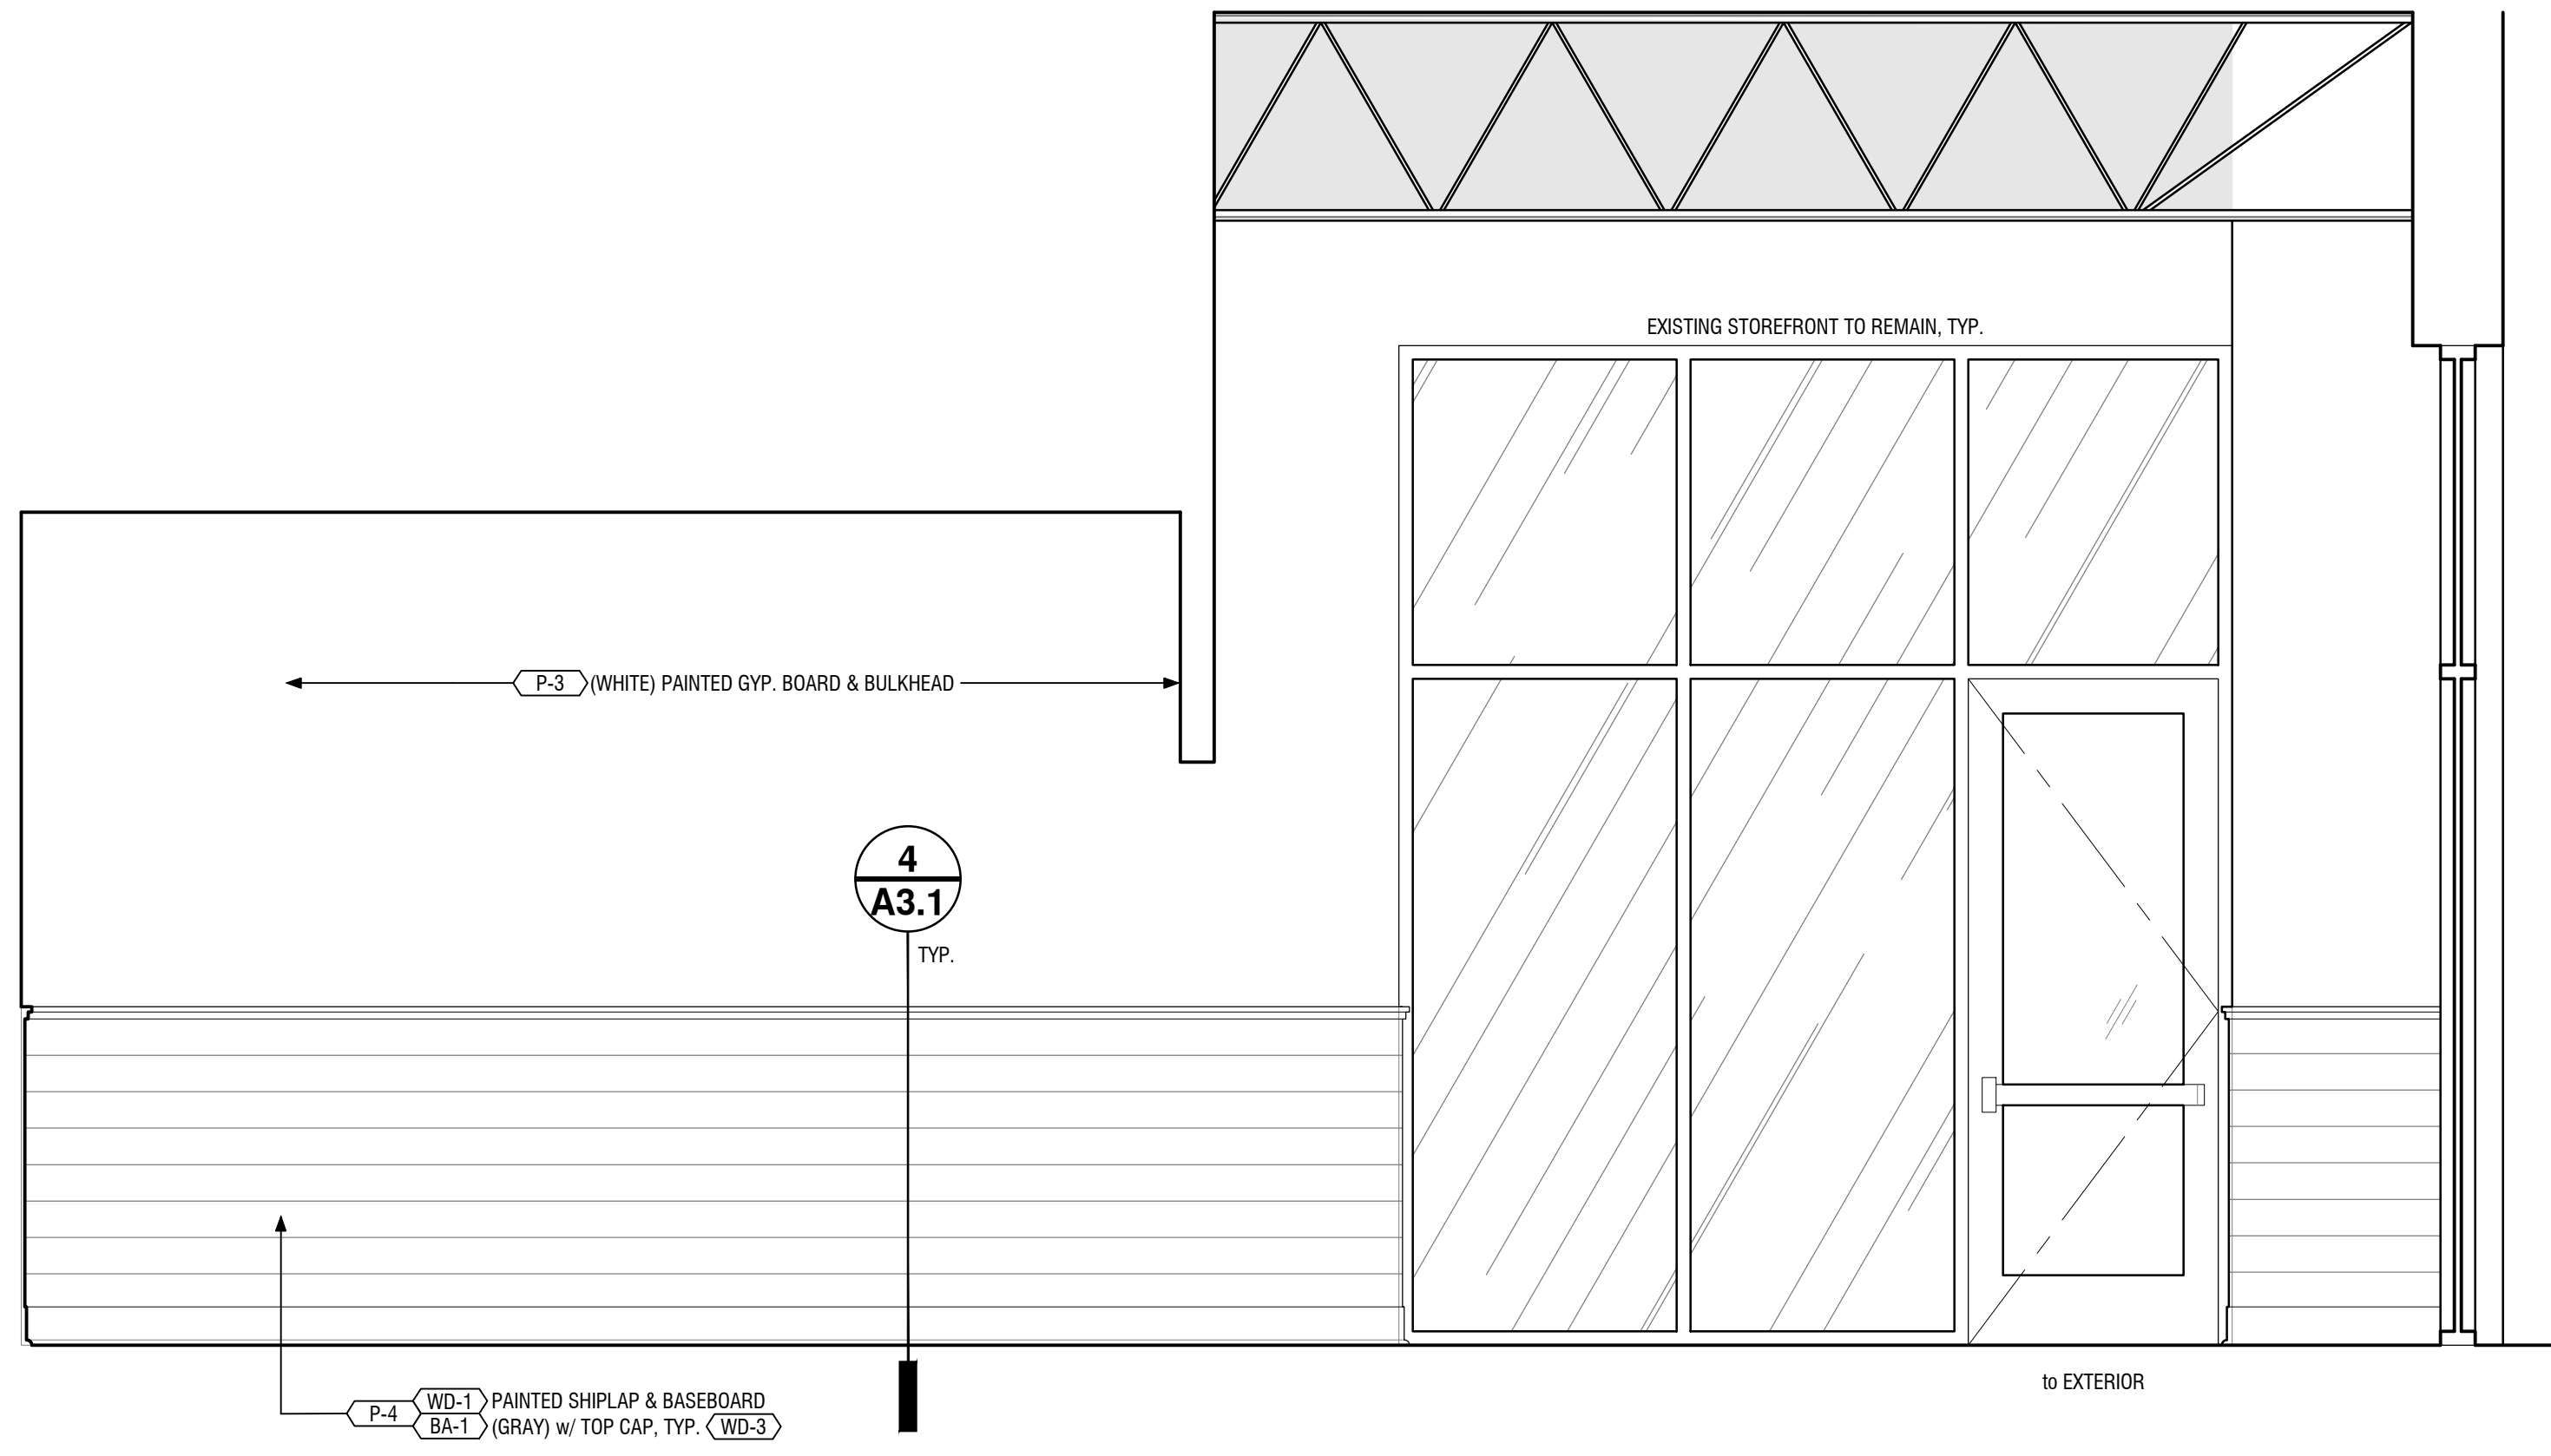


4 Hall 108/Dining Room 101 - Back Wall Elevation
A3.4 scale: 1/2" = 1'-0"

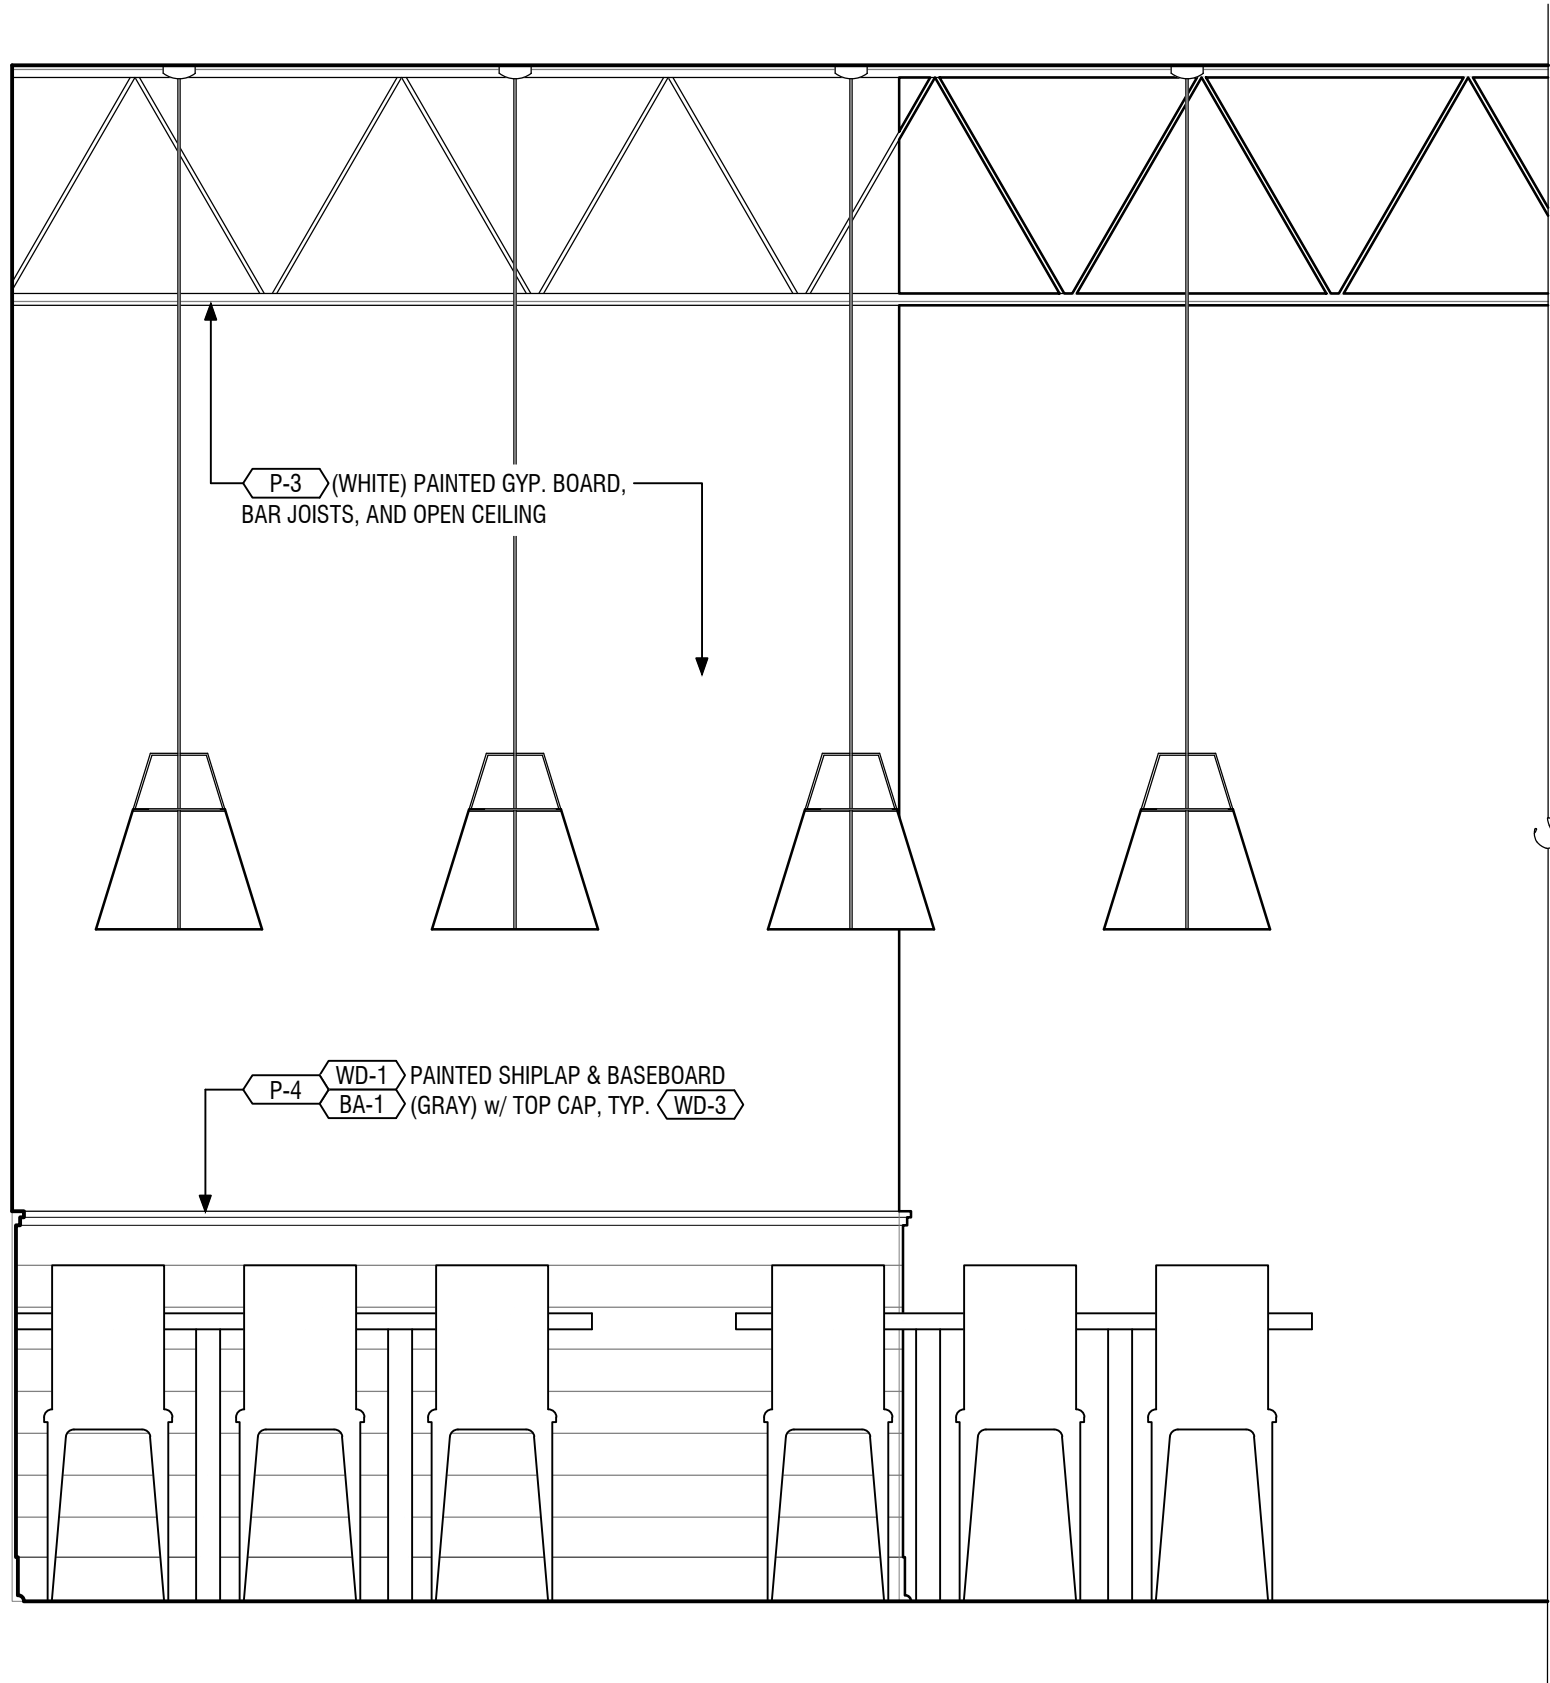

1 Dining Room 101
A3.5 scale: 1/2" = 1'-0"

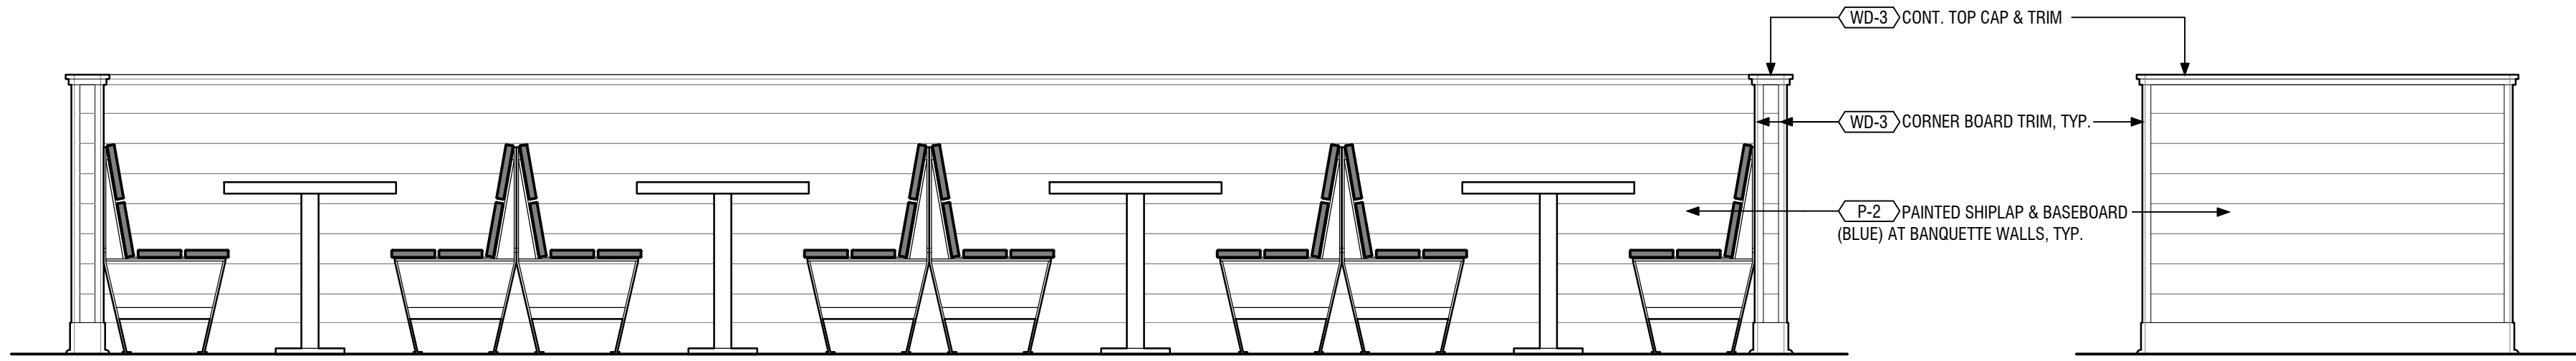


2 Dining Room 101 - Queue Booths
A3.5 scale: 1/2" = 1'-0"

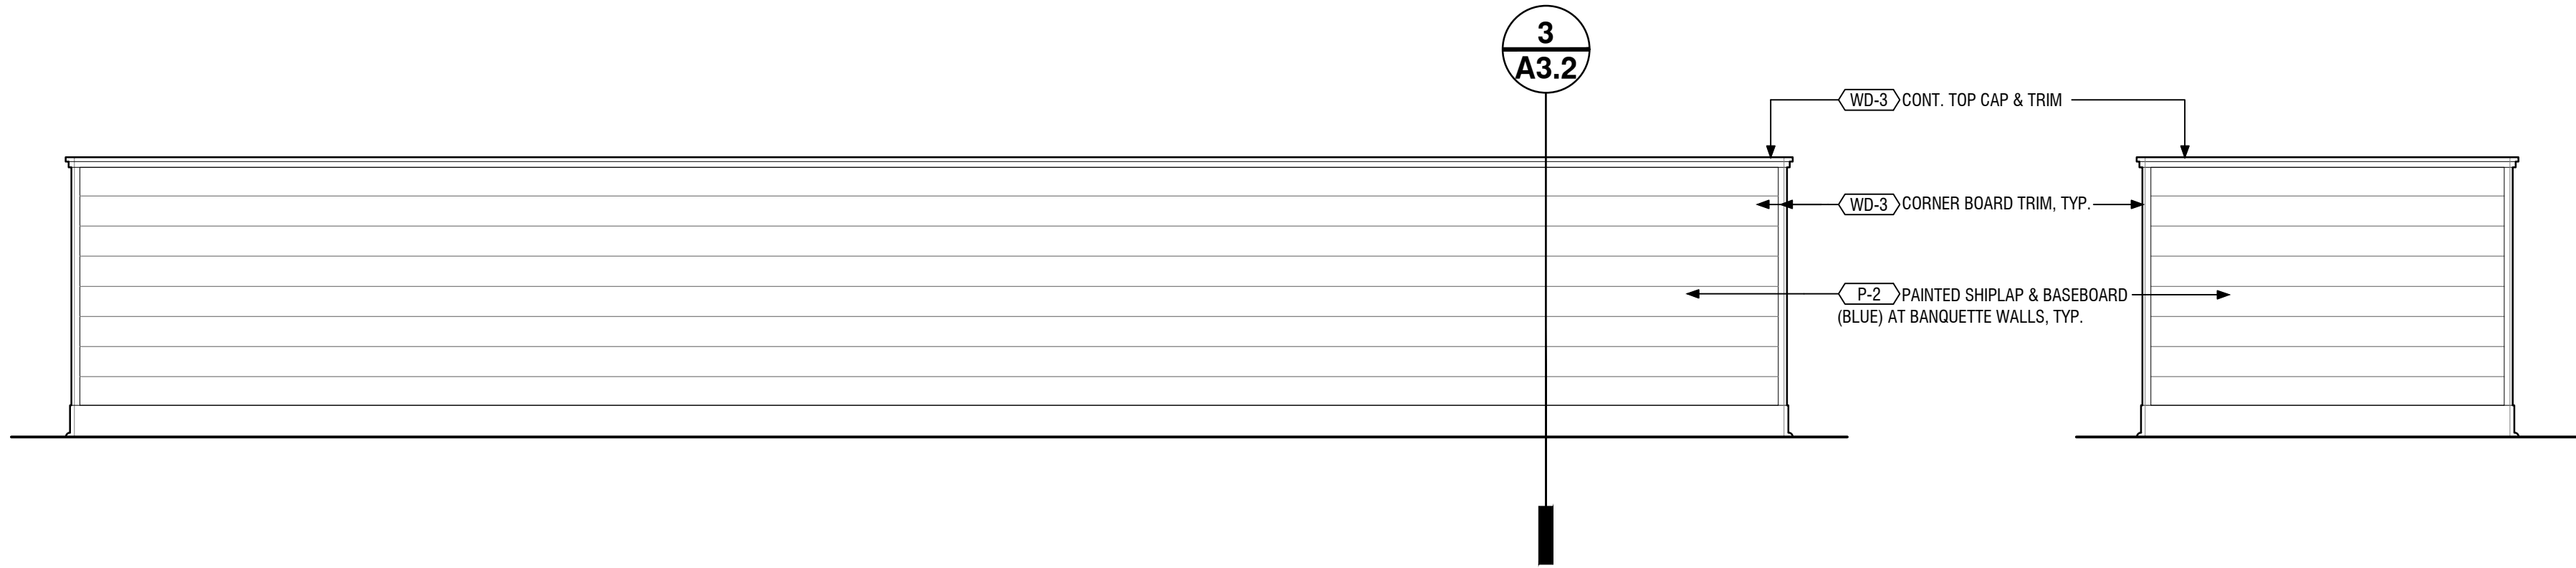


4 Dining Room 101 - Queue Booths
A3.5 scale: 1/2" = 1'-0"

3 Queue Booths
A3.5 scale: 1/2" = 1'-0"

5 Queue Booths
A3.5 scale: 1/2" = 1'-0"

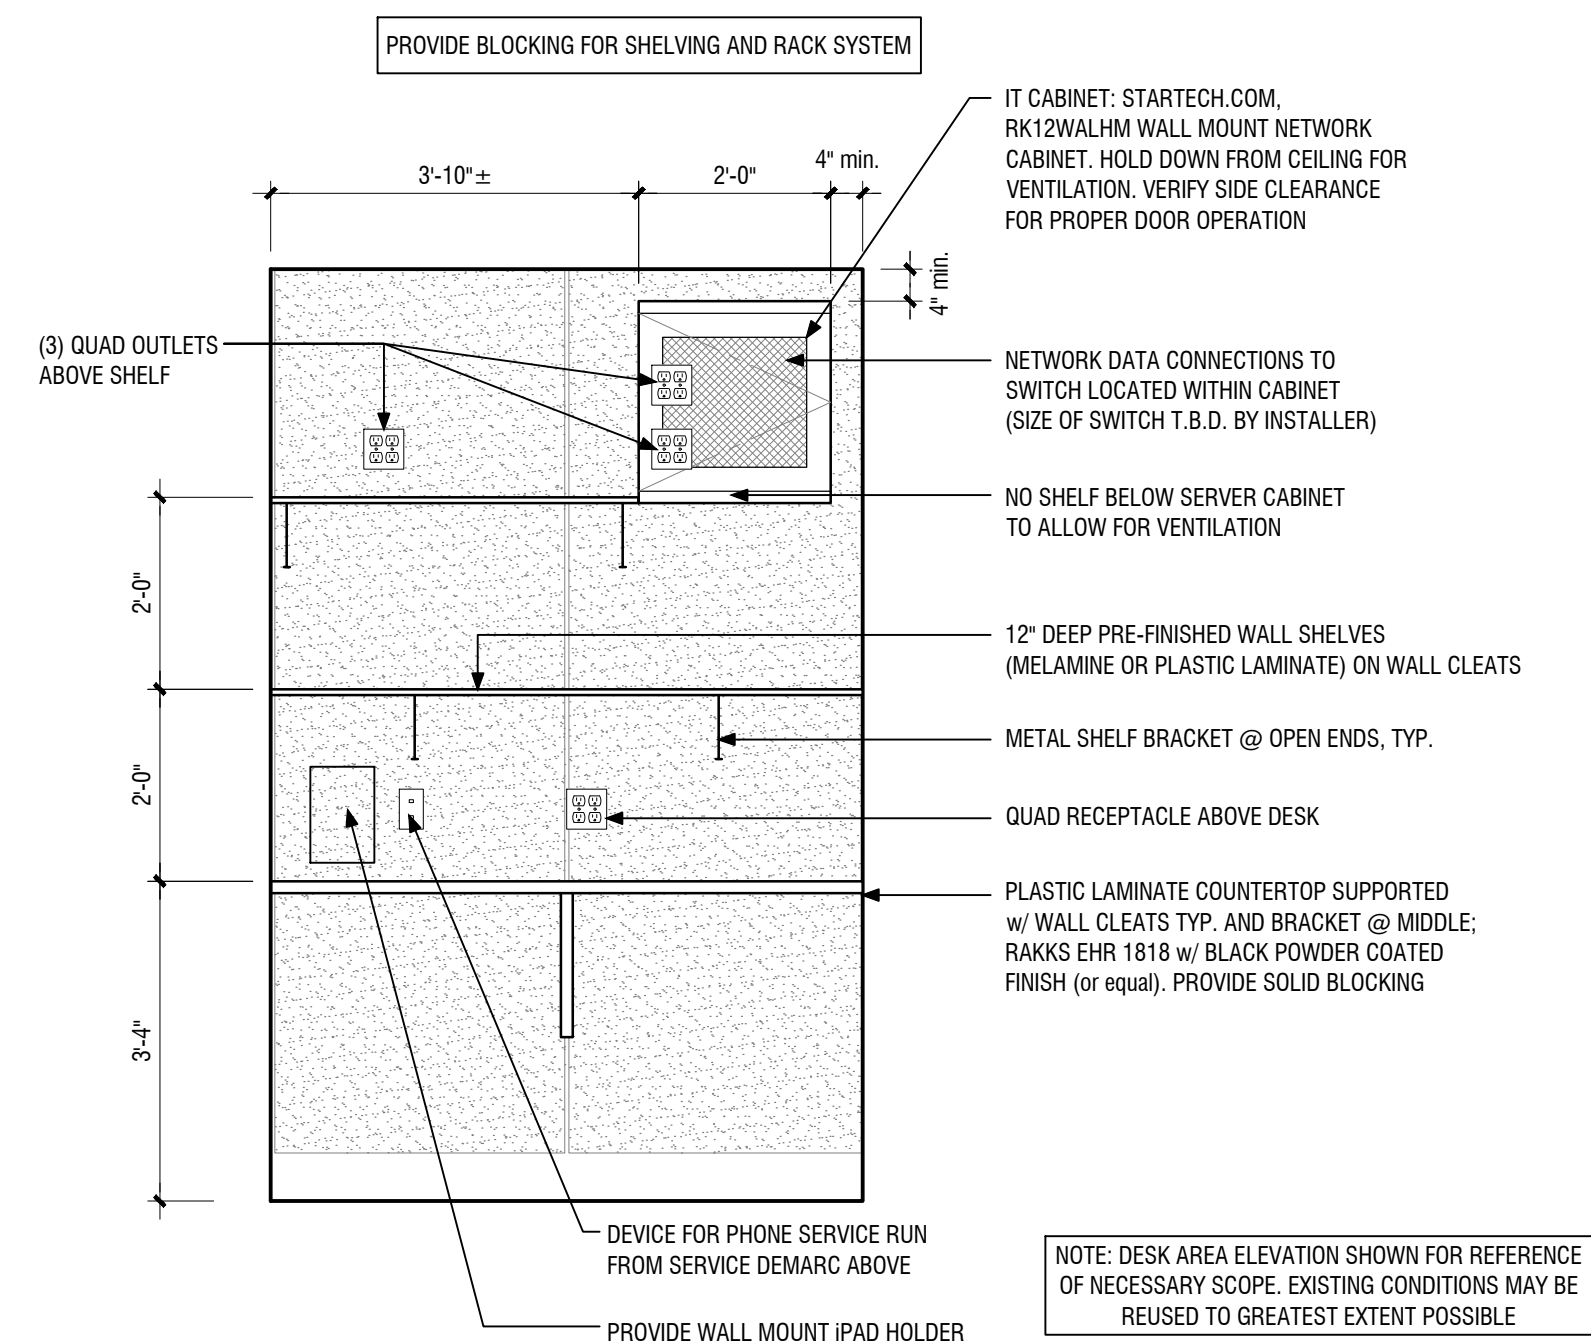


6 Office 107 Desk Elevation
A3.5 scale: 1/2" = 1'-0"

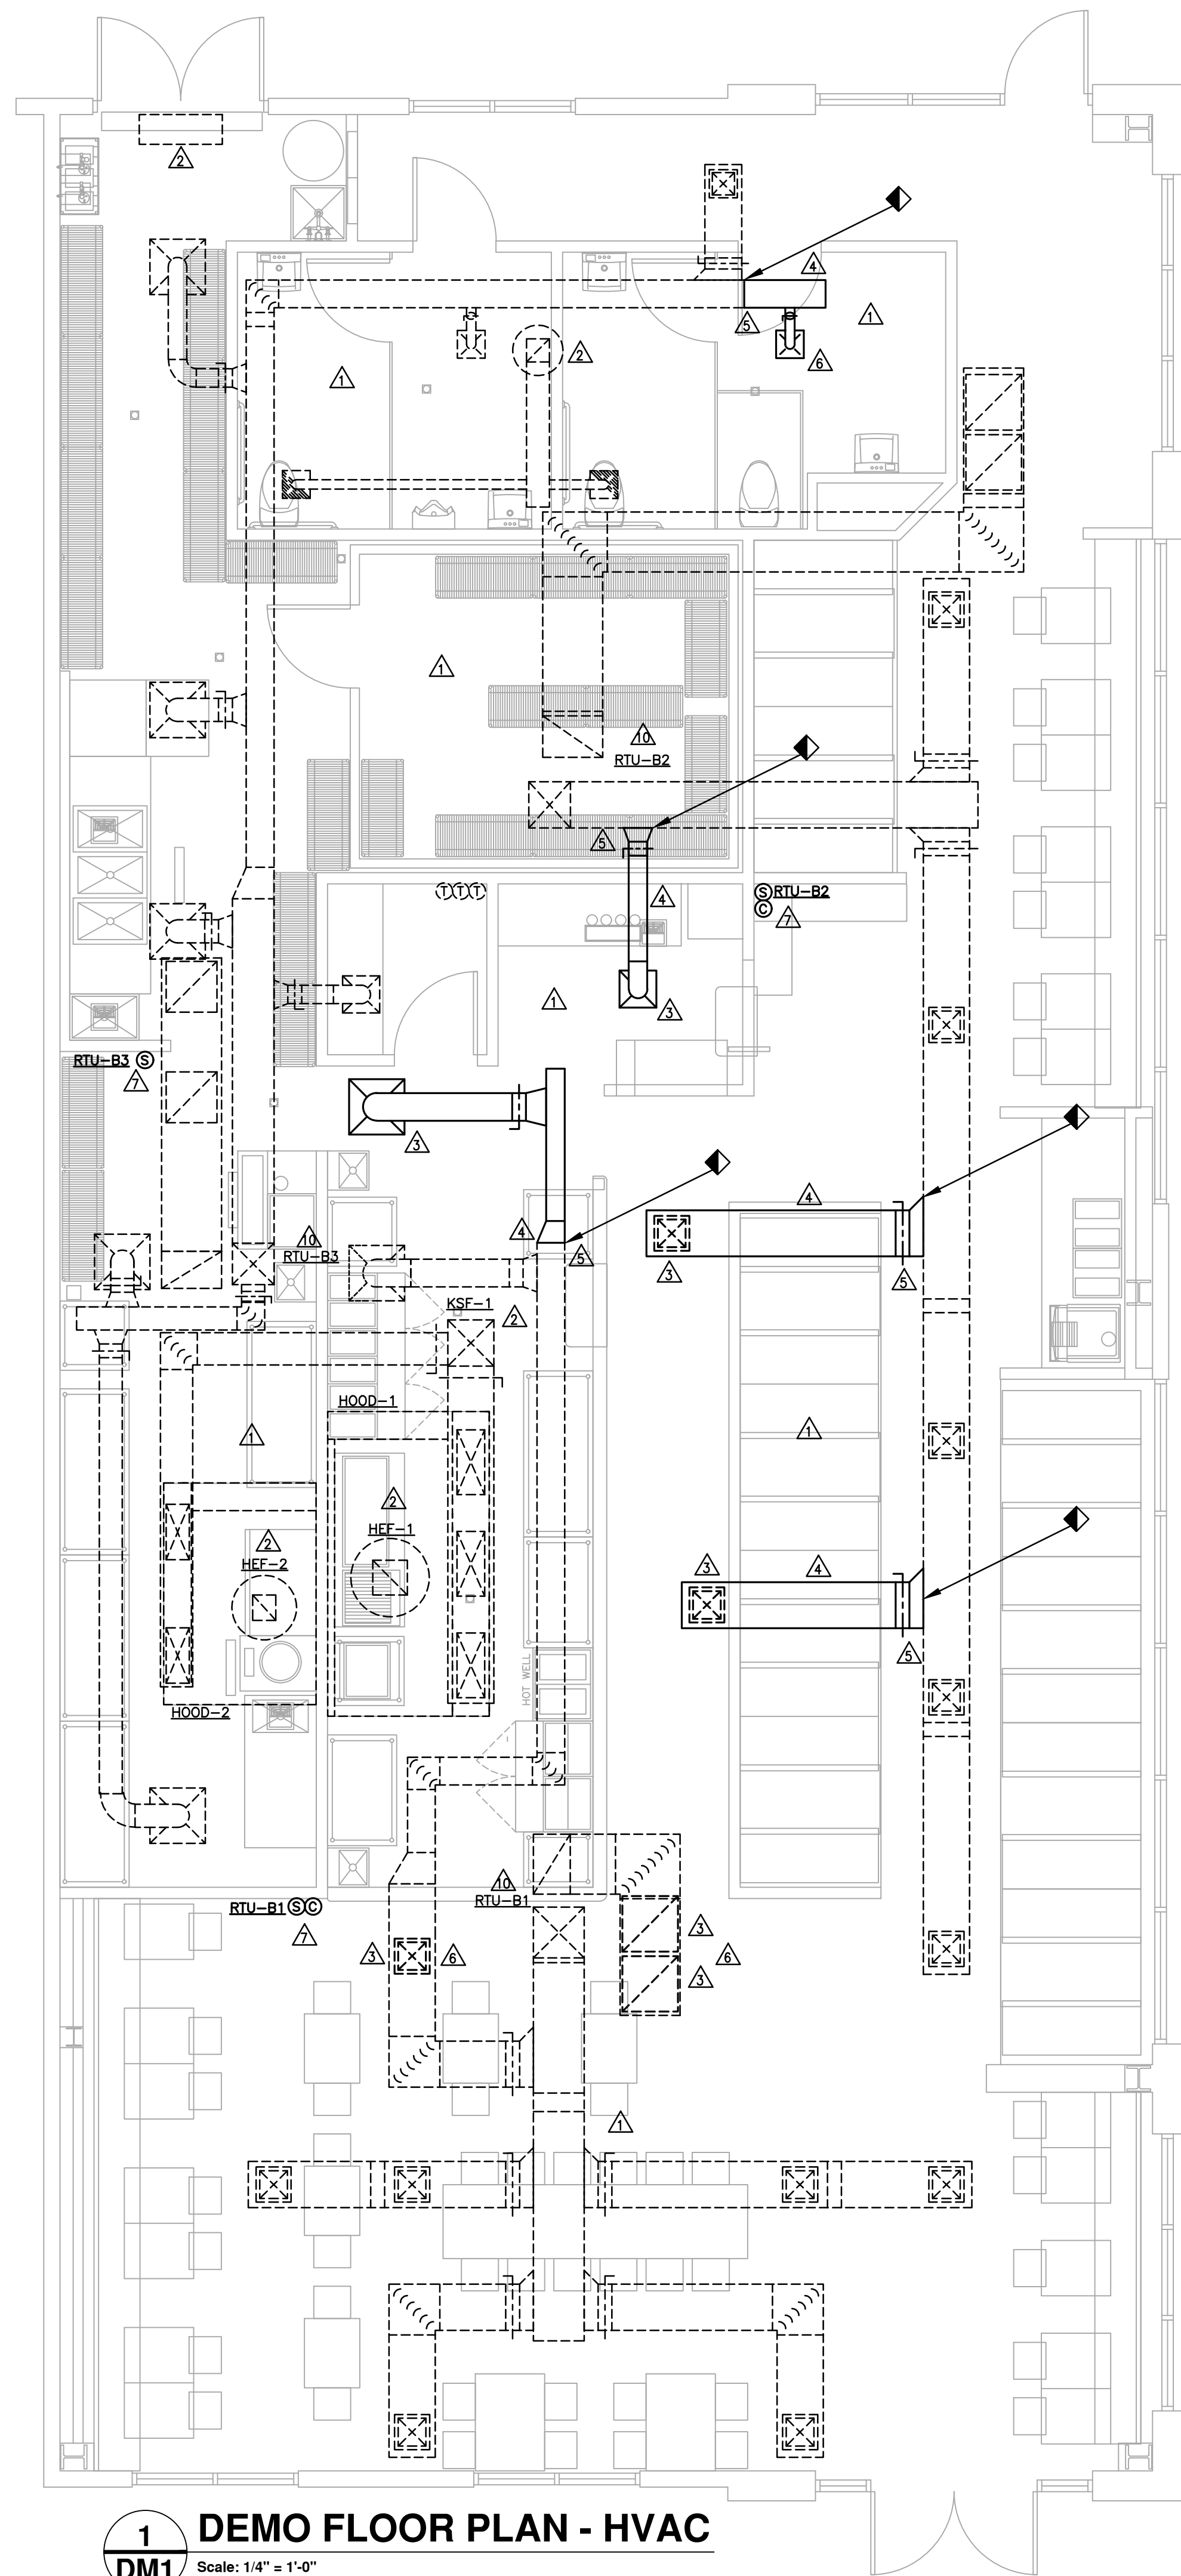


1 DEMO FLOOR PLAN - HVAC
Scale: 1/4" = 1'-0"

DEMOLITION NOTES:

- △ CONTRACTOR SHALL FIELD VERIFY EXISTING CONDITIONS.
- △ EXISTING HVAC EQUIPMENT, DUCTWORK, AND AIR DEVICES SHALL REMAIN IN USE UNLESS OTHERWISE NOTED.
- △ REMOVE EXISTING AIR DEVICES AS SHOWN.
- △ REMOVE EXISTING DUCTWORK AS SHOWN.
- △ CAP ALL UNUSED OPENINGS WITH INSULATED SHEET-METAL.
- △ REMOVE EXISTING AIR DEVICE AS SHOWN FOR RELOCATION UNDER NEW WORK.
- △ RELOCATE EXISTING SENSOR. REFER TO NEW PLANS FOR LOCATION.
- △ EXISTING GAS PIPING AND METER TO REMAIN.
- △ EXISTING GAS PIPING SHALL BE REMOVED AS SHOWN.
- △ EXISTING RTU TO REMAIN. CONTRACTOR SHALL SERVICE EXISTING HVAC UNITS AND PROVIDE ROUTINE MAINTENANCE PER MANUFACTURER'S RECOMMENDATIONS. REPORT ANY AND ALL DEFICIENCIES TO THE BUILDING OWNER AND TENANT.

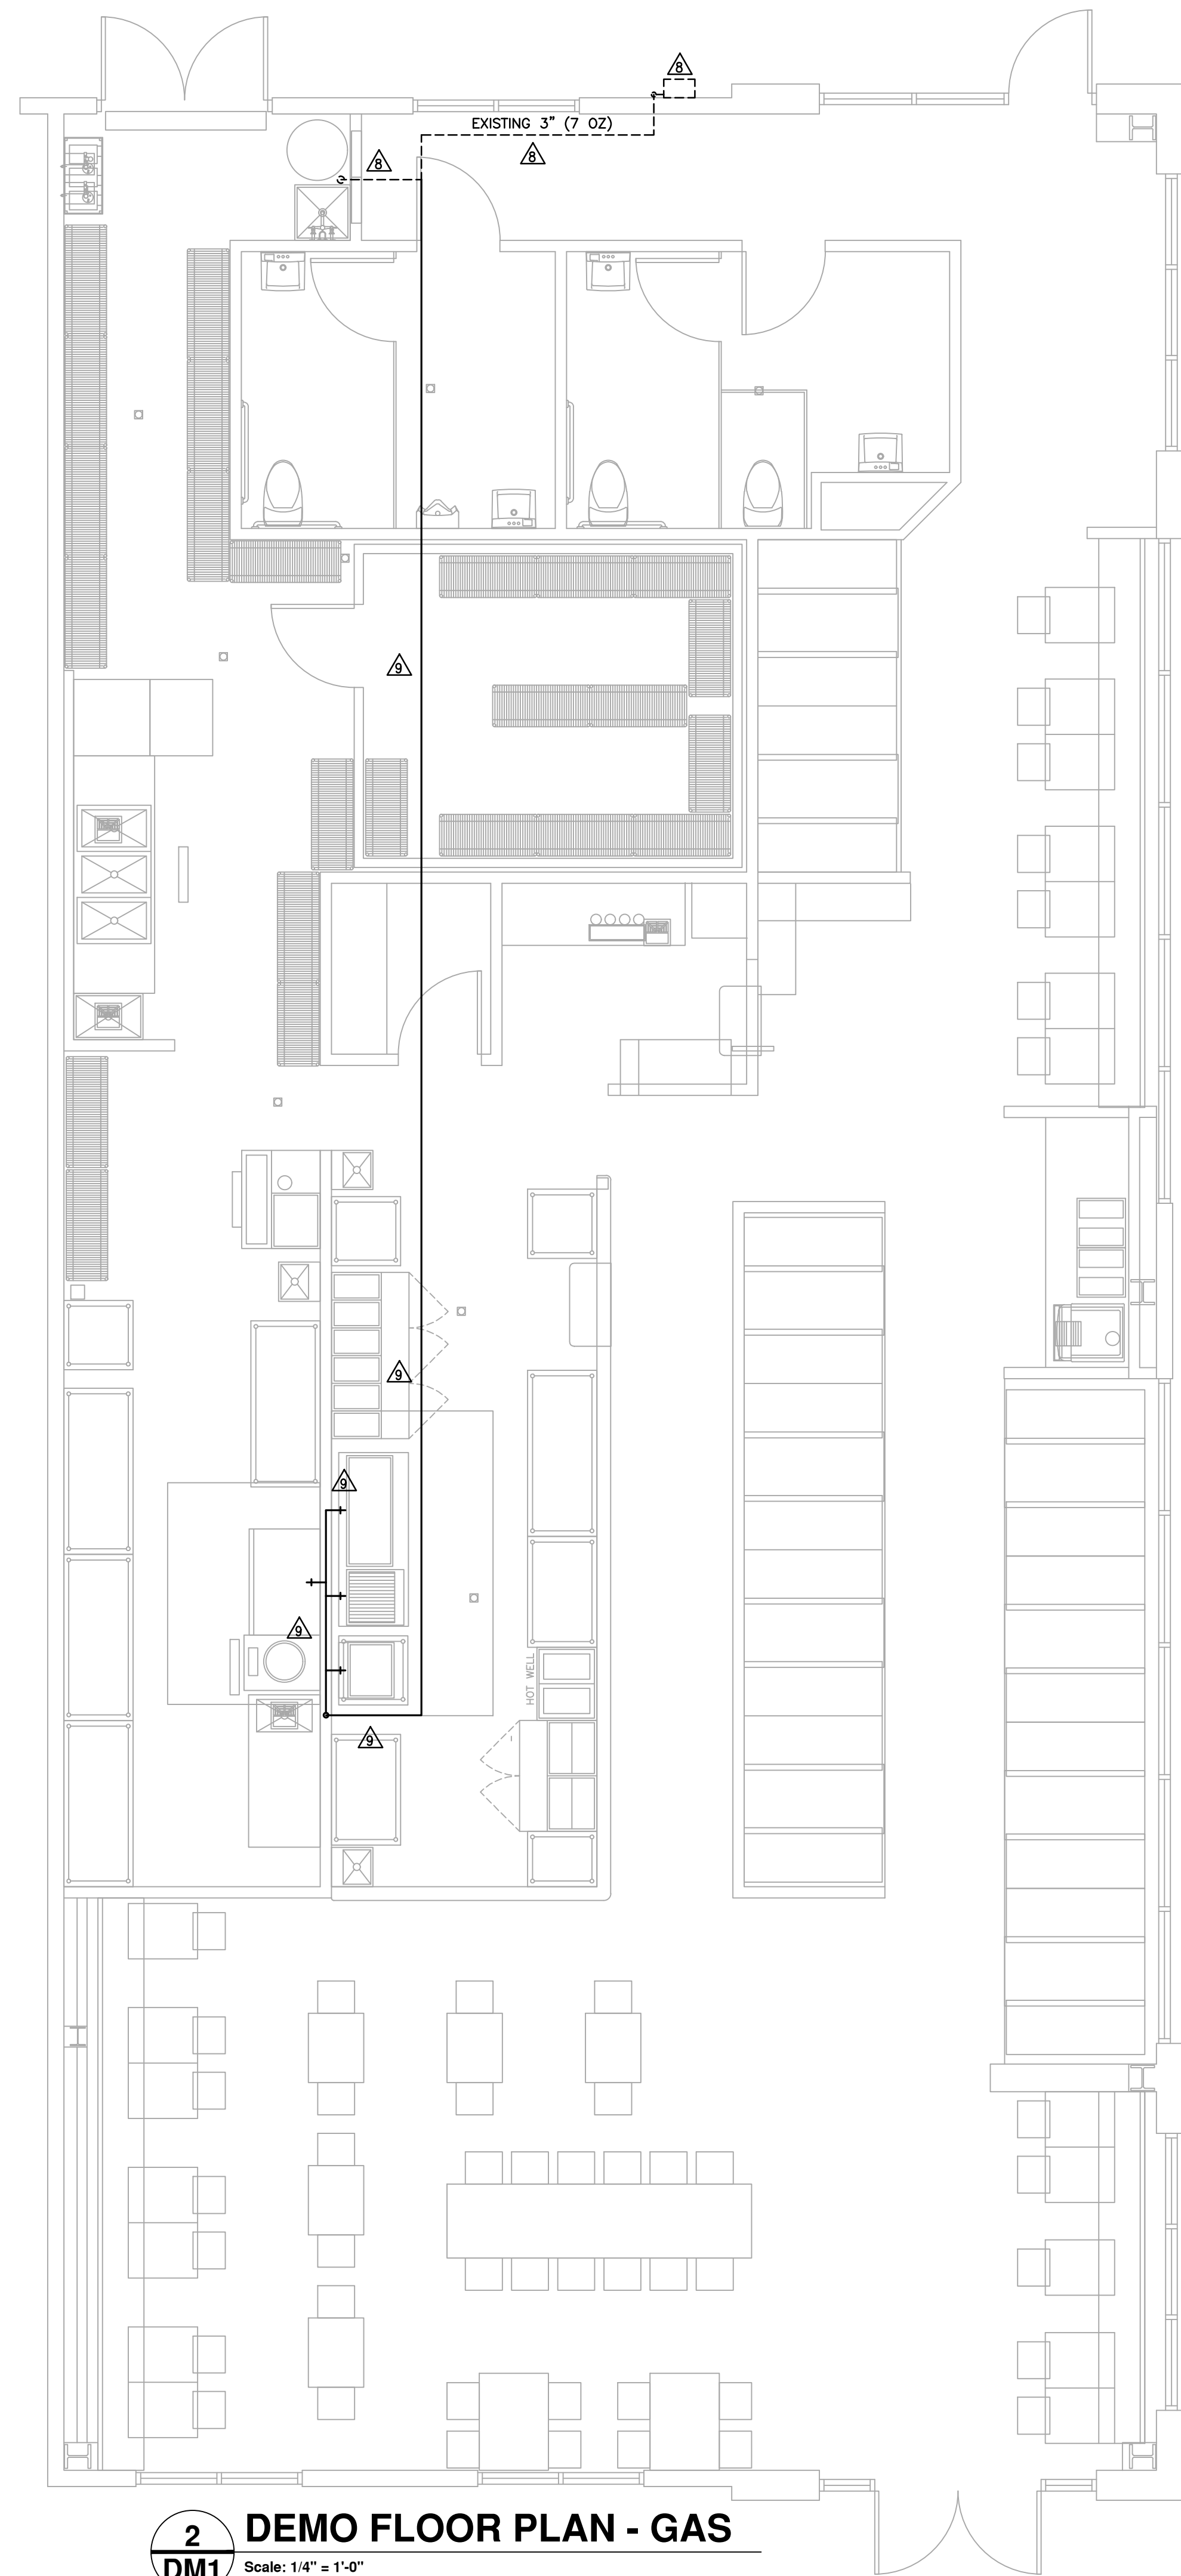

2 DEMO FLOOR PLAN - GAS
Scale: 1/4" = 1'-0"

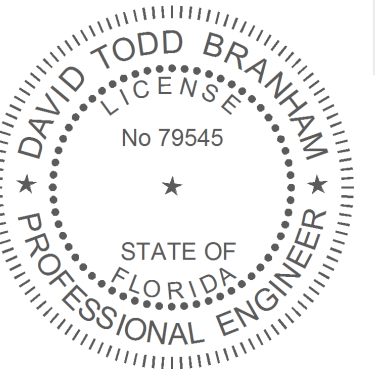



Biscuit Belly
15463 Panama City Beach Pkwy Ste B
Panama City Beach, FL 32413

insomnia DESIGN

15 Sept 2026
MEP Permit

DEMO FLOOR PLAN
- MECHANICAL

DM1

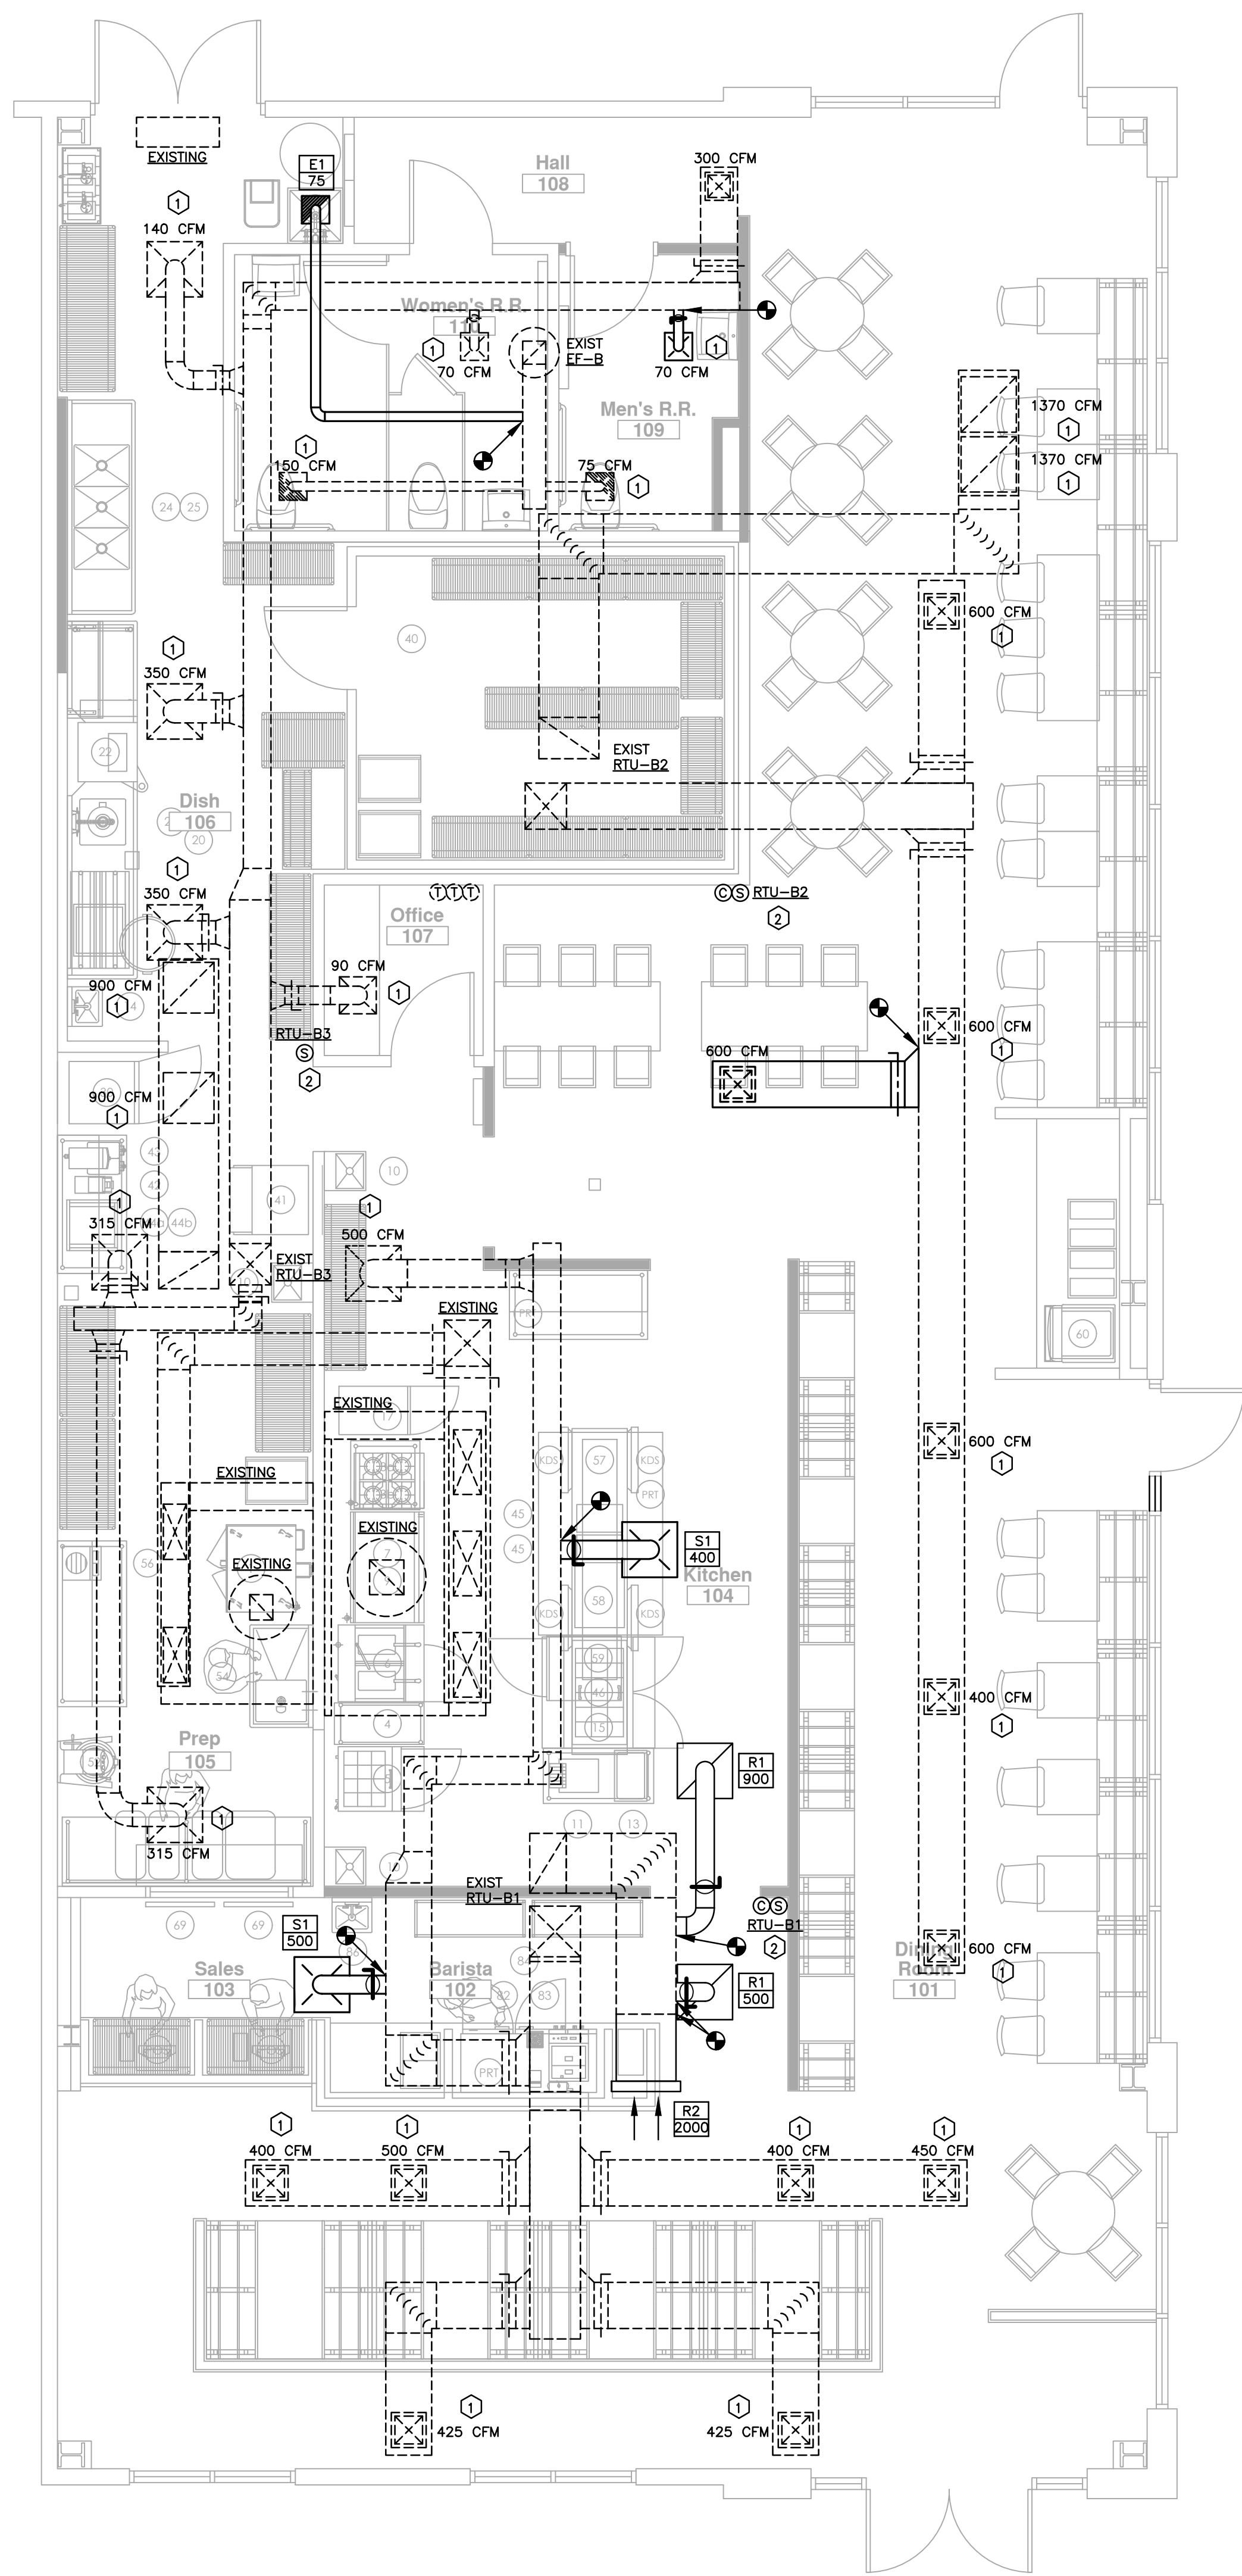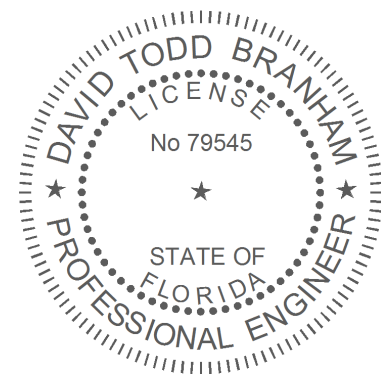

HVAC NOTES:

- ① RE-BALANCE EXISTING AIR DEVICE FOR CFM AS SHOWN.
- ② RELOCATED SENSORS MOUNTED 54" AFF.


GENERAL HVAC NOTES:



- 1. CONTRACT DOCUMENT DRAWINGS FOR MECHANICAL WORK ARE DIAGRAMMATIC AND ARE INTENDED TO CONVEY SCOPE AND GENERAL ARRANGEMENT ONLY.
- 2. SEE ARCHITECTURAL AND STRUCTURAL DRAWINGS FOR EXACT BUILDING ARRANGEMENT, DIMENSIONS AND DETAILS. THESE DRAWINGS ARE DIAGRAMMATIC, AND ARE NOT TO BE SCALED.
- 3. COORDINATE DUCT AND PIPE ROUTING AND EQUIPMENT LOCATION WITH PLUMBING AND ELECTRICAL INSTALLATIONS AND WITH BUILDING STRUCTURAL MEMBERS. OFF-SET DUCTS/PIPING AND SHIFT EQUIPMENT AS REQUIRED TO AVOID CONFLICTS WITH OTHER INSTALLATIONS.
- 4. COORDINATE LOCATION OF CEILING REGISTERS WITH LIGHTING LAYOUT, SPRINKLER HEADS AND CEILING GRID SYSTEMS AND APPURTENANCES. REFER TO ARCHITECTURAL REFLECTED CEILING PLANS FOR EXACT LOCATION.
- 5. DUCT SIZES INDICATED ON THE PLANS ARE CLEAR INSIDE DIMENSIONS REQUIRED. WHERE LINER IS INDICATED OR NOTED, INCREASE DUCT SIZE TO ACHIEVE INDICATED DIMENSION(S).
- 6. REFER TO THE ELECTRICAL DRAWINGS FOR VOLTAGE, PHASE, MAXIMUM ALLOWABLE CURRENT DRAW, AMPERAGE AND CONNECTION ARRANGEMENT (SINGLE, MULTI-POINT, ETC.) OF ALL MECHANICAL EQUIPMENT PRIOR TO ORDERING/INSTALLING EQUIPMENT.
- 7. SUPPORT ALL DUCTS, PIPING AND EQUIPMENT FROM PRIMARY BUILDING STRUCTURAL MEMBERS AND PROVIDE SUPPLEMENTAL STRUCTURAL FRAMING AS REQUIRED BETWEEN PRIMARY BUILDING STRUCTURAL MEMBERS TO SUPPORT ALL SYSTEMS INSIDE THE BUILDING.
- 8. PROVIDE STRUCTURAL FRAMING AROUND FULL PERIMETER OF ALL ROOF OPENING/EQUIPMENT. PROVIDE STRUCTURAL LINTELS ABOVE ALL WALL OPENINGS. SEE STRUCTURAL FOR LINTEL DETAIL(S).
- 9. PROVIDE PIPE SLEEVE THRU ALL WALLS AND THRU ALL FLOOR SLABS. SEE PIPE SLEEVE DETAIL.
- 10. PROVIDE PIPE HANGERS FOR ALL SUSPENDED PIPING AS SHOWN IN DETAILS. PROVIDE PIPE STAND FOR ALL FLOOR/GRADE MOUNTED PIPING AS SHOWN IN DETAILS.
- 11. INSTALL DUCT PENETRATIONS THROUGH NON-RATED WALLS AS SHOWN IN DETAILS.
- 12. PROTECT ALL NEW OPENING IN ACCORDANCE WITH BARRED ROOF OPENING AND ARCHITECTURAL REQUIREMENTS.
- 13. COORDINATE CONSTRUCTION OF ALL MECHANICAL WORK WITH ARCHITECTURAL, STRUCTURAL, CIVIL, AND OTHER DISCIPLINES PRIOR TO CONSTRUCTION.
- 14. PROVIDE ALL MATERIALS AND EQUIPMENT AND PERFORM ALL LABOR REQUIRED TO INSTALL COMPLETE AND OPERABLE MECHANICAL SYSTEM AS INDICATED ON THE DRAWINGS, AS SPECIFIED AND AS REQUIRED BY CODE.
- 15. INSTALL ALL MECHANICAL EQUIPMENT AND APPURTENANCES IN ACCORDANCE WITH MANUFACTURERS RECOMMENDATIONS, CONTRACT DOCUMENTS, AND APPLICABLE CODES AND REGULATIONS.
- 16. PROVIDE VIBRATION ISOLATION FOR ALL MECHANICAL EQUIPMENT TO PREVENT TRANSMISSION OF VIBRATION TO BUILDING STRUCTURE.
- 17. THE LOCATIONS OF ALL ITEMS SHOWN ON THE DRAWINGS OR CALLED FOR IN THE SPECIFICATIONS THAT ARE NOT DEFINITELY FIXED BY DIMENSIONS ARE APPROXIMATE ONLY. THE EXACT LOCATIONS NECESSARY TO SECURE THE BEST CONDITIONS AND RESULTS MUST BE DETERMINED BY THE PROJECT SITE CONDITIONS AND SHALL HAVE THE APPROVAL OF THE ENGINEER BEFORE BEING INSTALLED. DO NOT SCALE DRAWINGS.
- 18. ALL DUCTWORK SHALL BE RIGID TYPE UNLESS OTHERWISE NOTED ON PLANS.
- 19. REFER TO AIR DEVICE SCHEDULE FOR INDIVIDUAL RUNOUT SIZES.

1 FLOOR PLAN - HVAC
M1.1 Scale: 1/4" = 1'-0"

15 Sept 2026
MEP Permit

FLOOR PLAN –
HVAC

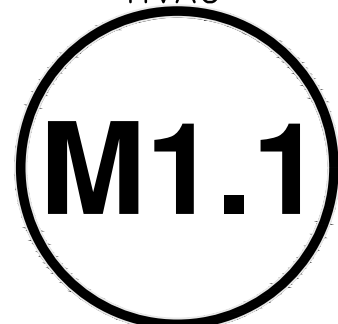

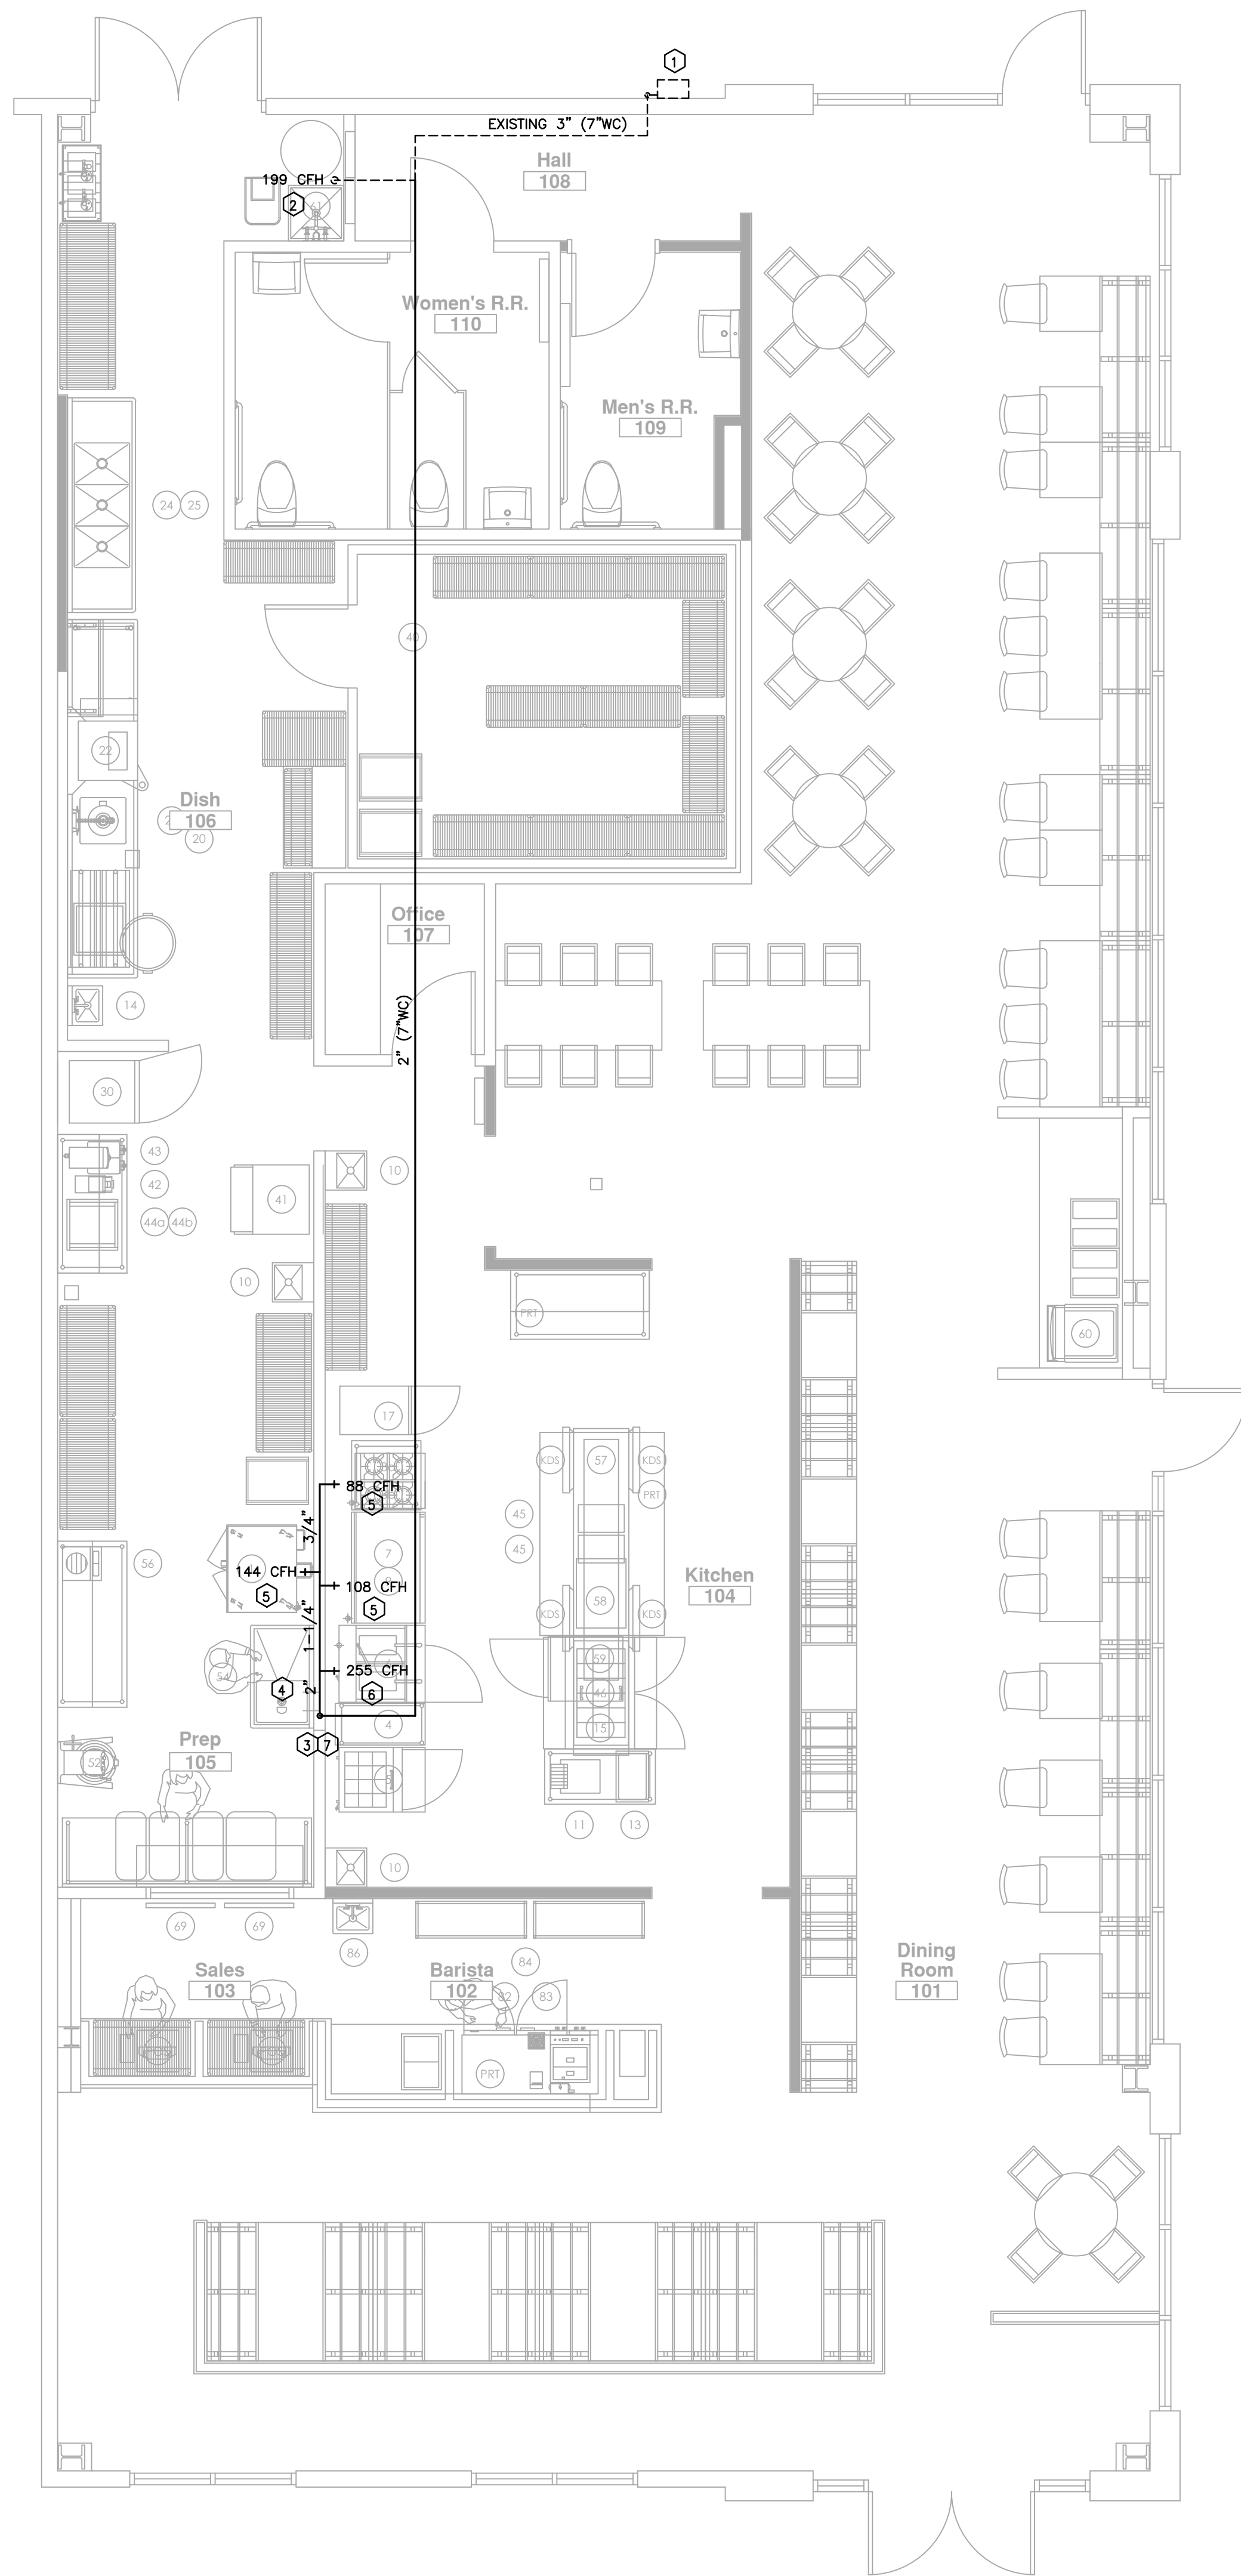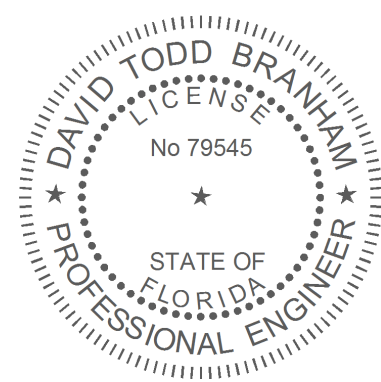

GAS NOTES:

- NEW CONNECTED LOAD AT METER SHALL BE 1,111 CFH. VERIFY WITH LOCAL UTILITY COMPANY THAT EXISTING METER IS SUFFICIENT FOR NEW LOAD. IF NOT SUFFICIENT, COORDINATE REPLACEMENT OF METER WITH LOCAL UTILITY.
- EXISTING 1-1/4" GAS TO EXISTING WATER HEATER.
- ROUTE 2" GAS PIPING TO HOOD AUTOMATIC SHUT-OFF VALVE(S) PROVIDED BY FIRE SUPPRESSION COMPANY.
- ROUTE 2" GAS PIPING HEADER FROM HOOD AUTOMATIC VALVE TO BEHIND EQUIPMENT.
- PROVIDE 3/4" CONNECTION WITH SHUT-OFF VALVE AND FLEXIBLE CONNECTOR TO APPLIANCE.
- PROVIDE 1" CONNECTION WITH SHUT-OFF VALVE AND FLEXIBLE CONNECTOR TO APPLIANCE.
- PROVIDE GAS COCK, AND DRIP LEG.


GENERAL HVAC NOTES:

- CONTRACT DOCUMENT DRAWINGS FOR MECHANICAL WORK ARE DIAGRAMMATIC AND ARE INTENDED TO CONVEY SCOPE AND GENERAL ARRANGEMENT ONLY.
- SEE ARCHITECTURAL AND STRUCTURAL DRAWINGS FOR EXACT BUILDING ARRANGEMENT, DIMENSIONS AND DETAILS. THESE DRAWINGS ARE DIAGRAMMATIC, AND ARE NOT TO BE SCALED.
- COORDINATE DUCT AND PIPE ROUTING AND EQUIPMENT LOCATION WITH PLUMBING AND ELECTRICAL INSTALLATIONS AND WITH BUILDING STRUCTURAL MEMBERS. OFF-SET DUCTS/PIPING AND SHIFT EQUIPMENT AS REQUIRED TO AVOID CONFLICTS WITH OTHER INSTALLATIONS.
- COORDINATE LOCATION OF CEILING REGISTERS WITH LIGHTING LAYOUT, SPRINKLER HEADS AND CEILING GRID SYSTEMS AND APPURTENANCES. REFER TO ARCHITECTURAL REFLECTED CEILING PLANS FOR EXACT LOCATION.
- DUCT SIZES INDICATED ON THE PLANS ARE CLEAR INSIDE DIMENSIONS REQUIRED. WHERE LINER IS INDICATED OR NOTED, INCREASE DUCT SIZE TO ACHIEVE INDICATED DIMENSION(S).
- REFER TO THE ELECTRICAL DRAWINGS FOR VOLTAGE, PHASE, MAXIMUM ALLOWABLE CURRENT DRAW, AMPERAGE AND CONNECTION ARRANGEMENT (SINGLE, MULTI-POINT, ETC.) OF ALL MECHANICAL EQUIPMENT PRIOR TO ORDERING/INSTALLING EQUIPMENT.
- SUPPORT ALL DUCTS, PIPING AND EQUIPMENT FROM PRIMARY BUILDING STRUCTURAL MEMBERS AND PROVIDE SUPPLEMENTAL STRUCTURAL FRAMING AS REQUIRED BETWEEN PRIMARY BUILDING STRUCTURAL MEMBERS TO SUPPORT ALL SYSTEMS INSIDE THE BUILDING.
- PROVIDE STRUCTURAL FRAMING AROUND FULL PERIMETER OF ALL ROOF OPENING/EQUIPMENT. PROVIDE STRUCTURAL LINTELS ABOVE ALL WALL OPENINGS. SEE STRUCTURAL FOR LINTEL DETAIL(S).
- PROVIDE PIPE SLEEVE THRU ALL WALLS AND THRU ALL FLOOR SLABS. SEE PIPE SLEEVE DETAIL.
- PROVIDE PIPE HANGERS FOR ALL SUSPENDED PIPING AS SHOWN IN DETAILS. PROVIDE PIPE STAND FOR ALL FLOOR/GRADE MOUNTED PIPING AS SHOWN IN DETAILS.
- INSTALL DUCT PENETRATIONS THROUGH NON-RATED WALLS AS SHOWN IN DETAILS.
- PROTECT ALL NEW OPENING IN ACCORDANCE WITH BARRED ROOF OPENING AND ARCHITECTURAL REQUIREMENTS.
- COORDINATE CONSTRUCTION OF ALL MECHANICAL WORK WITH ARCHITECTURAL, STRUCTURAL, CIVIL, AND OTHER DISCIPLINES PRIOR TO CONSTRUCTION.
- PROVIDE ALL MATERIALS AND EQUIPMENT AND PERFORM ALL LABOR REQUIRED TO INSTALL, COMPLETE AND OPERABLE MECHANICAL SYSTEM AS INDICATED ON THE DRAWINGS, AS SPECIFIED AND AS REQUIRED BY CODE.
- INSTALL ALL MECHANICAL EQUIPMENT AND APPURTENANCES IN ACCORDANCE WITH MANUFACTURERS RECOMMENDATIONS, CONTRACT DOCUMENTS, AND APPLICABLE CODES AND REGULATIONS.
- PROVIDE VIBRATION ISOLATION FOR ALL MECHANICAL EQUIPMENT TO PREVENT TRANSMISSION OF VIBRATION TO BUILDING STRUCTURE.
- THE LOCATIONS OF ALL ITEMS SHOWN ON THE DRAWINGS OR CALLED FOR IN THE SPECIFICATIONS THAT ARE NOT DEFINITELY FIXED BY DIMENSIONS ARE APPROXIMATE ONLY. THE EXACT LOCATIONS NECESSARY TO SECURE THE BEST CONDITIONS AND RESULTS MUST BE DETERMINED BY THE PROJECT SITE CONDITIONS AND SHALL HAVE THE APPROVAL OF THE ENGINEER BEFORE BEING INSTALLED. DO NOT SCALE DRAWINGS.
- ALL DUCTWORK SHALL BE RIGID TYPE UNLESS OTHERWISE NOTED ON PLANS.
- REFER TO AIR DEVICE SCHEDULE FOR INDIVIDUAL RUNOUT SIZES.

GAS LOAD AND FLUE SCHEDULE						
ITEM	NUMBER OF ITEMS	TOTAL LOAD FOR ITEMS (CFH)	GAS PRESSURE	LOCATION	FLUE SIZE AND TYPE (EACH ITEM)	REMARKS
EXISTING RTU-B1	1	120	7" WC	ROOF	-	1,2
EXISTING RTU-B2	1	125	7" WC	ROOF	-	1,2
EXISTING RTU-B3	1	72	7" WC	ROOF	-	1,2
#1 - OVEN	1	144	7" WC	KITCHEN	-	-
#6 - FRYER	1	255	7" WC	KITCHEN	-	-
#9 - GRIDDLE	1	108	7" WC	KITCHEN	-	-
#3 - HOT PLATE	1	88	7" WC	KITCHEN	-	-
EXISTING WH-1	1	199	7" WC	KITCHEN	2" PVC	1,2
	8	1,111				

NOTES:

- EXISTING GAS PIPING SIZED FOR LOW PRESSURE.
- GAS PIPING SIZED AT 100 EQUIVALENT FEET.

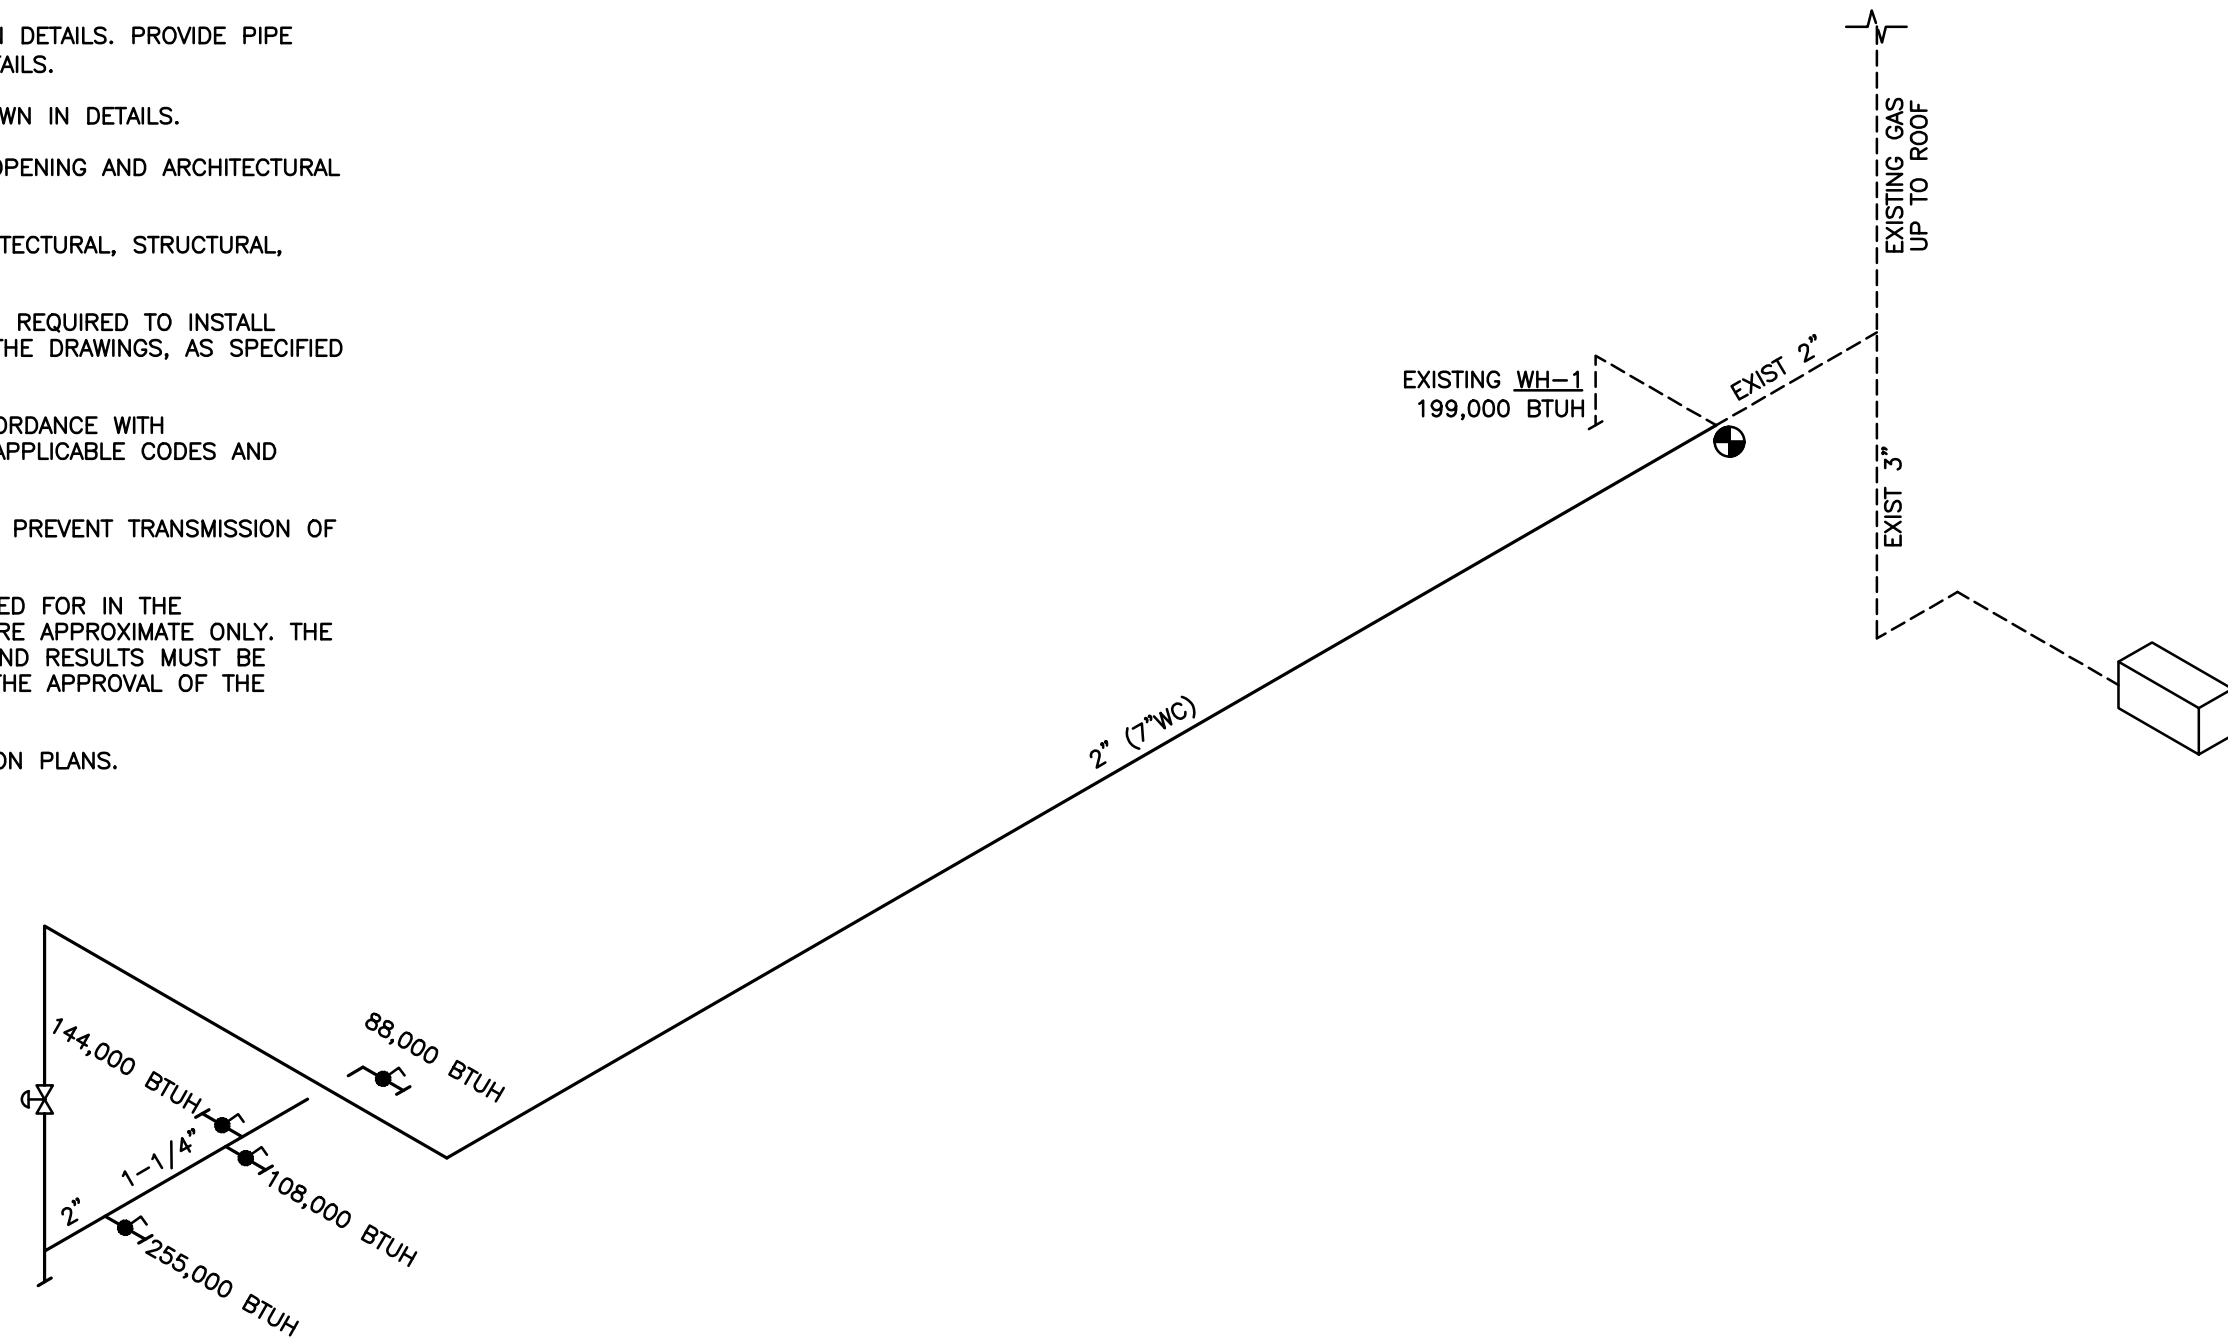

SUPPLY AIR DEVICES									
MARK	NECK SIZE	CFM RANGE	MAX TOTAL ΔP	MAX NC	TITUS MODEL NO.				
					SERIES	ACCESSORIES	REMARKS		
S1	4"ø NECK	UP TO 85	0.08"	30	TMSI	①	12x12 SQUARE CEILING DIFFUSER WITH OPPOSED BLADE DAMPER AND INSULATION BLANKET		
	5"ø NECK	86–125	0.08"	30	TMSI				
	6"ø NECK	126–160	0.08"	30	TMSI				
S1	6"ø NECK	161–180	0.08"	30	TMSI	①	24x24 SQUARE CEILING DIFFUSER WITH OPPOSED BLADE DAMPER AND INSULATION BLANKET		
	8"ø NECK	181–310	0.08"	30	TMSI				
	10"ø NECK	311–440	0.08"	30	TMSI				
	12"ø NECK	441–590	0.08"	30	TMSI				
	14"ø NECK	591–750	0.08"	30	TMSI				
	15"ø NECK	751–825	0.08"	30	TMSI				
S2	12x4 NECK	121–170	0.08"	30	300RS	①	LOUVERED FACE, DOUBLE DEFLECTION SIDEWALL SUPPLY REGISTER, 22.5" BLADE DEFLECTION TO EACH SIDE, 3/4" SPACING		
	16x4 NECK	171–230	0.08"	30	300RS				
	20x4 NECK	231–300	0.08"	30	300RS				
RETURN DEVICES									
R1	6"ø NECK	UP TO 115	0.08"	30	8R		24x24 PERFORATED FACE RETURN		
	8"ø NECK	116–200	0.08"	30	8R				
	10"ø NECK	201–310	0.08"	30	8R				
	12"ø NECK	311–450	0.08"	30	8R				
	14"ø NECK	451–600	0.08"	30	8R				
	15x15 NECK	601–930	0.08"	30	8R				
R2	24X24	UP TO 1800	0.08"	30	350RL		LOUVERED FACE, SINGLE DEFLECTION SIDEWALL RETURN GRILLE, 30" BLADE DEFLECTION		
	36X18	1800 TO 2800	0.08"	30	350RL				
EXHAUST DEVICES									
E1	6x6	UP TO 115	0.08"	30	50F		1/2" EGGRATE RETURN GRILLE W/ ALUMINUM BORDER AND GRID		
	8x8	116–250	0.08"	30	50F				
X XXX SERVICE AND MARK NUMBER S = SUPPLY R = RETURN ACCESSORIES: ① OBD									
NOTES: 1. CEILING DEVICES FURNISHED SHALL BE COMPATIBLE WITH CEILINGS SPECIFIED BY ARCHITECT. 2. UNLESS OTHERWISE NOTED, PROVIDE SOUND ATTENUATING FLEX DUCT AT CONNECTION. 3. PROVIDE SUPPLY AIR CEILING DEVICES WITH 4-WAY THROW PATTERN, UNLESS OTHERWISE INDICATED.									
SUPPLY RUNOUT SIZES (U.N.O.) CFM RANGES DUCT SIZE 0–100 6"ø 101–130 7"ø 131–200 8"ø 201–260 9"ø 261–400 10"ø 401–500 11"ø 501–620 12"ø 621–790 14"ø RETURN RUNOUT SIZES (U.N.O.) CFM RANGES DUCT SIZE 0–75 6"ø or 6/6 76–140 7"ø or 8/6 141–190 8"ø or 8/8 191–250 9"ø or 10/8 251–320 10"ø or 10/10 321–420 11"ø or 12/10 421–520 12"ø or 12/12 521–800 14"ø or 14/12 * RUNOUT SIZES TO BE USED ONLY IF NOT NOTED ON PLANS.									


EXISTING ROOFTOP UNIT SCHEDULE																			
MARK	SA CFM MAXIMUM	OA CFM	EXT. SPWG (INCHES)	COOLING DATA				HEATING DATA				ELECTRICAL DATA						MANUFACTURER & MODEL NUMBER	INTERLOCKS (SEE FAN SCHED.)
				ENT. AIR Fdb	FWD	CAPACITY AIR SUPPLY SENSIBLE	STANDARD TOTAL	FUEL	INPUT MBH	HEAT STAGE	FURNACE MIN. EFFIC. (AFU)	VOLTAGE	MCA	MOCp	COMPRESSOR RLA / LRA	CONDENSER FAN FLA	EVAPORATOR FAN HP / FLA		
RTU-B1	4,000	600																	
RTU-B2	3,400	660																	
RTU-B3	2,000	200																	


NOTES:
1. REBALANCE OUTSIDE AIR FOR CFM AS SHOWN. PROVIDE MANUAL OUTSIDE AIR DAMPER IF NOT EQUIPPED.

LEGEND	
SYMBOL	DESCRIPTION
AFF	ABOVE FINISHED FLOOR
BFC	BELOW FINISHED CEILING
CO	CLEAN OUT
CU	CONDENSING UNIT
EF	EXHAUST FAN
F	FAN COIL UNIT
OA	OUTSIDE AIR
RA	RETURN AIR
SA	SUPPLY AIR
SF	SUPPLY FAN
UH	UNIT HEATER
	SUPPLY DUCTWORK
	RETURN DUCTWORK
	EXHAUST DUCTWORK
	DUCT MOUNTED SUPPLY GRILLE
	SUPPLY AIR (DENOTES FOUR WAY DIFFUSER)
	RETURN AIR
	EXHAUST AIR
	SIDEWALL RETURN AIR GRILLE
	SUPPLY DUCT UP
	RETURN / EXHAUST DUCT UP
①	WALL THERMOSTAT
②	INDICATES KEY NOTES
	AIR DEVICE #1 CFM AIR QUANTITY
	MANUAL VOLUME BALANCING DAMPER
	NEW TO EXISTING SYMBOL
	DEMOLITION POINT OF DISCONNECT

OUTSIDE AIR REQUIREMENTS (ASHRAE 62.1-2019)											
AREA	AREA	UNIT	FLOOR	OA RATE		OCCUPANCY	TOTAL				
SERVED	CLASSIFICATION	SERVED	AREA (SF)	CFM/SF	CFM	PEOPLE / 1000 SF	PEOPLE	CFM / PERSON	CFM	EXHAUST	TOTAL OA
MAIN ENTRY	MAIN ENTRY	RTU-B1	180	0.06	11	10	2	5	9	0	20
	RESTAURANT DINING ROOM	RTU-B1	350	0.18	63	70	25	7.5	184	0	247
	SALES	RTU-B1	200	0.12	24	15	3	7.5	23	0	47
	KITCHEN (COOKING)	RTU-B1	420	0.12	50	20	8	7.5	63	0	113
											426
DINING	RESTAURANT DINING ROOM	RTU-B2	920	0.18	166	70	64	7.5	483	0	649
	CORRIDOR	RTU-B2	180	0.06	11	0	0	0	0	0	11
											659
RESTROOM	TOILET	RTU-B3	115	0	0	0	0	0	0	0	0
RESTROOM	TOILET	RTU-B3	65	0	0	0	0	0	0	0	0
OFFICE	OFFICE	RTU-B3	40	0.06	2	5	0	5	1	0	3
KITCHEN	KITCHEN (COOKING)	RTU-B3	575	0.12	69	20	12	7.5	86	0	155
HALL	CORRIDOR	RTU-B3	65	0.06	4	0	0	0	0	0	4
											163

AIR BALANCE						
MARK	SUPPLY CFM	RETURN CFM	OUTSIDE AIR CFM	EXHAUST CFM	RELATIVE PRESSURE (CFM)	REMARKS
EXISTING RTU-B1	4,000	3,400	600	–	–	FRONT OF HOUSE AC
EXISTING RTU-B2	3,400	2,740	660	–	–	FRONT OF HOUSE AC
EXISTING RTU-B3	2,000	3,000	200	–	–	BACK OF HOUSE AC
KSF-1	2,980	–	2,980	–	–	MAKE-UP AIR UNIT
HEF-1	–	–	–	2,500	–	HOOD EXHAUST
HEF-2	–	–	–	1,225	–	HOOD EXHAUST
EF-B	–	–	–	300	–	TOILET/JAN EXHAUST
TOTALS	12,380	9,140	4,440	4,025	415	

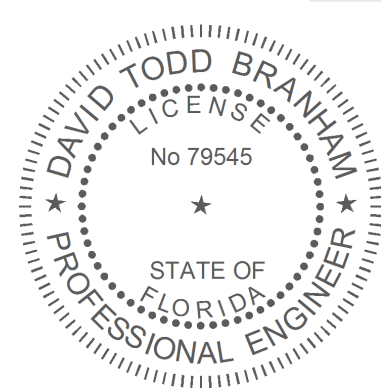

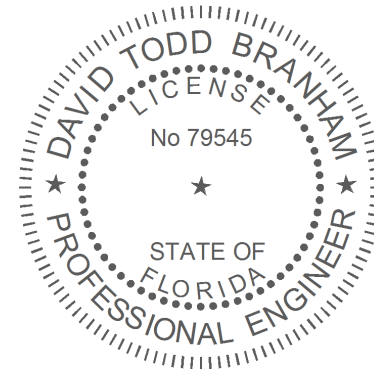

HVAC SPECIFICATIONS

PART 1

GENERAL

- FURNISH ALL MATERIALS, LABOR, TOOLS, TRANSPORTATION AND INCIDENTALS TO COMPLETE THE PROJECT IN EVERY DETAIL, AND LEAVE IN WORKING ORDER ALL ITEMS CALLED FOR HEREIN OR SHOWN ON THE ACCOMPANYING DRAWINGS.
- IT IS THE RESPONSIBILITY OF CONTRACTOR TO READ ALL SPECIFICATIONS AND CONSULT ALL DRAWINGS WHICH MAY AFFECT THE INSTALLATION AND COORDINATION OF HIS WORK WITH OTHER TRADES. CONTRACTOR SHALL COORDINATE AND MAKE MINOR ADJUSTMENTS IN LOCATION OF EQUIPMENT AND MATERIALS AS NECESSARY TO SECURE COORDINATION.
- LAYOUT SHOWN IN DRAWINGS IS BASED ON A PARTICULAR MAKE OF EQUIPMENT. CONTRACTOR SHALL PROVIDE SIX SUBMITTAL SETS OF SHOP DRAWINGS TO ENGINEER FOR APPROVAL PRIOR TO STARTING WORK. IF ANOTHER MAKE OF EQUIPMENT IS DESIRED, THESE SUBMITTALS SHALL ALSO SHOW ALL REQUIRED MODIFICATIONS AND CHANGES, INCLUDING THOSE INVOLVING OTHER TRADES, AND COST THEREOF SHALL BE INCLUDED IN HIS BID. CONTRACTOR MUST RECEIVE APPROVED SUBMITTAL COPY, SIGNED BY ENGINEER BEFORE PROCEEDING WITH ANY MODIFICATIONS. WORK INSTALLED USING UNAPPROVED SUBSTITUTIONS SHALL BE REPLACED AT NO ADDITIONAL COST TO THE OWNER.
- CONTRACTOR SHALL VISIT THE SITE AND FULLY INFORM HIMSELF CONCERNING ALL CONDITIONS AFFECTING SCOPE OF WORK. FAILURE TO DO SO SHALL NOT RELIEVE CONTRACTOR OF ANY RESPONSIBILITY IN THE PERFORMANCE OF HIS WORK. ALL WORKMANSHIP SHALL BE OF THE HIGHEST QUALITY IN ACCORDANCE WITH THE BEST PRACTICES OF THE TRADE BY CRAFTSMEN SKILLED IN THIS PARTICULAR WORK. CONTRACTOR SHALL FILE ALL DRAWINGS, PAY ALL FEES AND OBTAIN ALL PERMITS AND CERTIFICATES OF INSPECTION RELATIVE TO THIS WORK.
- COMPLETED INSTALLATION SHALL CONFORM TO ALL APPLICABLE FEDERAL, STATE AND LOCAL CODES AND ORDINANCES, INCLUDING BUT NOT LIMITED TO THE LATEST APPROVED EDITIONS OF THE FOLLOWING: STATE BUILDING CODE, INTERNATIONAL BUILDING CODE, NFPA-90A, NFPA-101, NFPA-96, AND NFPA-54. ALL EQUIPMENT SHALL BE ARI CERTIFIED AND U.L. LISTED.
- SYSTEM LAYOUT IS SCHEMATIC AND EXACT LOCATIONS SHALL BE DETERMINED BY STRUCTURAL CONDITIONS, COORDINATION WITH OTHER TRADES, COORDINATION WITH FINISHES AND OTHER CONDITIONS. STRUCTURAL SUPPORTS SHALL NOT BE CUT OR ALTERED TO ASSURE FIT OF HVAC SYSTEM.
- CONTRACTOR SHALL BE RESPONSIBLE FOR ALL DEFECTS, REPAIRS AND REPLACEMENTS IN MATERIALS AND WORKMANSHIP FOR A PERIOD OF ONE (1) YEAR AFTER FINAL PAYMENT IS APPROVED. CONTRACTOR SHALL HONOR FACTORY WARRANTIES ON ALL EQUIPMENT PROVIDED AS PART OF THIS SYSTEM. COMPRESSORS SHALL BE PROVIDED WITH A MINIMUM OF FIVE (5) YEAR WARRANTY INCLUDING LABOR.
- UPON COMPLETION OF PROJECT, ALL SYSTEM EQUIPMENT AND MATERIALS SHALL BE IN NEW, CLEAN CONDITION WITH ALL DAMAGE RESTORED TO ACCEPTABLE CONDITION. ALL EQUIPMENT COMPONENTS AND DUCTWORK SHALL BE INSPECTED AND THOROUGHLY CLEANED, READY FOR USE. AT COMPLETION OF JOB, ALL MISCELLANEOUS TOOLS, SCAFFOLDING, SURPLUS MATERIALS, RUBBISH AND DEBRIS SHALL BE REMOVED BY CONTRACTOR.
- IF HVAC EQUIPMENT IS USED FOR TEMPORARY HEATING, THE CONTRACTOR SHALL ASSUME THE RESPONSIBILITY FOR CLEANING FILTERS, COILS, AND OTHER EQUIPMENT. FINAL PERMANENT CONNECTIONS OF SERVICES TO UNITS SHALL BE COMPLETE PRIOR TO ANY START-UP OF EQUIPMENT.


PART 2

PRODUCTS

- HEATING AND COOLING EQUIPMENT

- FURNISH AND INSTALL ROOFTOP SINGLE PACKAGE COMBINATION ELECTRIC COOLING AND NATURAL GAS FIRED HEATING UNITS BY CAPTIVEAIRE AS SHOWN ON DRAWINGS. UNITS SHALL BE MOUNTED ON A MATCHING FULL PERIMETER SEISMICALLY BRACED ROOF CURB PROVIDED BY EQUIPMENT MANUFACTURER. REFER TO SCHEDULE FOR ALL ACCESSORIES. MANUFACTURERS NOT LISTED ABOVE SHALL BE REQUIRED TO GET PRE-APPROVED PRIOR TO BIDDING. CONTACT ENGINEER OF RECORD FOR APPROVAL.
- UNIT SHALL BE FACTORY ASSEMBLED, TESTED AND HAVE COMPLETE REFRIGERANT CHARGE, READY TO OPERATE. ALL TUBING JOINTS SHALL BE BRAZED. COIL SHALL BE MINIMUM OF 3-ROWS DEEP. COIL SHALL BE COPPER TUBING W/ ALUMINUM PLATE FINS. SPINE FINS ARE NOT ACCEPTABLE.
- FAN SHALL BE STATICALLY AND DYNAMICALLY BALANCED, DOUBLE INLET, FORWARD CURVED BLOWER CAPABLE OF DELIVERING DESIGN CFM. FAN SHALL BE QUIET IN OPERATION AS DETERMINED BY THE ENGINEER, AND INTERNALLY VIBRATION ISOLATED.
- EQUIPMENT SHALL BE COMPLETELY FACTORY WIRED WITH ALL CONTROL AND PROTECTIVE DEVICES. ALL EQUIPMENT SHALL HAVE A SMOKE DETECTOR IN RETURN DUCT AND CONTROLS FOR SMOKE DETECTORS SHUTDOWN. FIRE-STATS SHALL BE INCLUDED ON ALL OTHER UNITS AS REQUIRED BY CODE. ALL FIRE-STATS SHALL HAVE 136" SETPOINT.
- FILTERS SHALL BE FARR MERV-4 1" OR MERV-7 2" THROW AWAY TYPE, OR AS SCHEDULED. A CLEAN SET OF REPLACEMENT FILTERS SHALL BE PROVIDED BY CONTRACTOR UPON START-UP OF EQUIPMENT.
- SYSTEMS SHALL BE COMPLETE WITH THERMOSTAT AND SUBBASE SPECIFICALLY DESIGNED FOR SYSTEM AND AS SHOWN ON DRAWINGS.
- ACCESSORIES SHALL INCLUDE TIME DELAY RELAYS TO PREVENT COMPRESSOR SHORT CYCLING, MALFUNCTION SWITCH, FIRE-STAT CUT-OUTS, LOW PRESSURE SWITCH, HIGH-PRESSURE CUT-OUT, LOW AMBIENT OPERATING KIT, CRANK CASE HEATER & COIL GUARD.
- UNITS SHALL HAVE MANUAL OUTSIDE AIR DAMPERS EXCEPT AS SHOWN ON DRAWINGS.
- REFRIGERANT PIPING TO BE ACR COPPER, TYPE L, HARD DRAWN WITH SILVER BRAZED JOINTS. ALL JOINT CONNECTIONS TO BE WITH SILFOS OR STAY-BRITE #8. USE MANUFACTURER'S RECOMMENDED FLUX ON ALL BRAZED JOINTS. PROVIDE ISOLATION / CHARGING VALVES, FILTER DRIER, AND MOISTURE INDICATING SIGHT GLASS. REFRIGERANT SUCTION PIPING TO BE INSULATED WITH 3/4" THICK AP ARMAFLEX. EXTERIOR INSULATED PIPING SHALL HAVE ALUMINUM JACKET COVER WITH ALL SEAMS CAULKED WITH RTV CLEAR SILICONE CAULKING.
- GAS FIRED EQUIPMENT
- ALL GAS FIRED EQUIPMENT SHALL BE AGA CERTIFIED.
- BURNERS SHALL BE EQUIPPED WITH CONTROLS AND SAFETIES REQUIRED FOR COMPLETE AND FULLY OPERATIONAL SYSTEM. PILOT SHALL BE INTERMITTENT ELECTRIC IGNITION TYPE.
- HEAT EXCHANGER SHALL BE PROVIDED WITH A MINIMUM FIVE (5) YEAR FULL WARRANTY.
- FANS
- FANS SHALL BE EQUAL TO THE MAKE AND MODEL(S) INDICATED AND SHALL BE LOCATED AS SHOWN ON DRAWINGS. FANS SHALL BE PENN, ACME, LOREN COOK OR GREENHECK. CURB MOUNTED FANS SHALL BE MOUNTED ON INSULATED CURBS, MINIMUM 1'-0" HIGH.
- FANS SHALL OPERATE CONTINUOUSLY UNLESS OTHERWISE NOTED ON EQUIPMENT SCHEDULE TO BE SWITCHED. SWITCH SHALL BE INSTALLED BY DIVISION 13.
- DUCTWORK AND INSULATION
- ALL LOW PRESSURE DUCTWORK SHALL BE SHEETMETAL 1" SPWG CONSTRUCTION EXCEPT AS NOTED. CONSTRUCTION STANDARDS AND RECOMMENDATIONS OF SMACNA, LATEST EDITION, SHALL BE FOLLOWED WITH RESPECT TO CONSTRUCTION, INSTALLATION AND SUPPORTING OF ALL DUCTWORK. EXCEPT MINIMUM GAUGE SHALL BE 24 GAUGE. ALL JOINTS SHALL BE SEALED WITH APPROVED SEALANT.
- DIMENSIONS FOR SHEETMETAL WORK ON DRAWINGS ARE INSIDE CLEAR UNLESS OTHERWISE NOTED. CONTRACTOR SHALL ADJUST SHEETMETAL SIZES TO ALLOW FOR INTERNAL LINER WHERE SPECIFIED.
- ALL RECTANGULAR RETURN DUCTS SHALL HAVE INTERNAL INSULATION. INSULATION SHALL BE 1" THICK AT 1.5 LB DENSITY, GLUED AND PINNED. WHERE INTERNAL LINER AND EXTERNAL WRAP MEET, THEY SHALL OVERLAP BY MINIMUM OF 6". INSULATION SHALL BE BY ARXVILLE T-1 CORPORATION, CERTAINTED OR KNAUF. ROUND RETURN DUCTS IN UNCONDITIONED SPACES SHALL HAVE 2" EXTERNAL INSULATION SAME AS SUPPLY DUCTS.
- ALL SUPPLY DUCTS SHALL BE EXTERNALLY INSULATED WITH MINIMUM 2" THICK FIBERGLASS FLEXIBLE DUCT INSULATION WITH VAPOR BARRIER, MANVILLE CORPORATION, CERTAINTED OR KNAUF. IN ADDITION, INSULATE INTERNALLY WHEN INDICATED. SPIRAL DUCTWORK IS THE ONLY EXCEPTION.
- TRUNK DUCTS SHALL BE ISOLATED FROM UNIT VIBRATION WITH THE USE OF NFPA AND U.L. APPROVED FLEXIBLE CONNECTORS IN BOTH SUPPLY AND RETURN.


- INSULATED FLEXIBLE DUCT MAY BE UTILIZED FOR CONNECTION TO GRILLES AND REGISTERS IN MAXIMUM LENGTHS OF 4'-0" PER BRANCH RUN. FLEXIBLE DUCT SHALL BE CERTAINTED, WIREMOLD OR MANVILLE CORPORATION, FLEX METAL. INSULATED WITH ACOUSTICAL VINYL VAPOR BARRIER, U.L. APPROVED WITH CONDUCTANCE 0.22 AT 75° F.
- ROUND DUCT TAKE-OFFS SHALL BE SPIN-IN OR CONICAL TEE TYPE WITH DAMPERS, NO AIR SCOOPS. ALL ROUND PIPE TO BE CONNECTED WITH SHEET METAL SCREWS AND SUPPORTED WITH 1" METAL STRAP. RECTANGULAR TAKE-OFFS AND BRANCHES SHALL BE 45° ANGLE BOOT OR TEE.
- SINGLE THICKNESS TURNING VANES SHALL BE INSTALLED AT 90° TURNS IN LOW PRESSURE MAIN SUPPLY DUCTS.
- INTERNALLY INSULATE AND WEATHERPROOF DUCTWORK EXPOSED TO WEATHER WITH MINIMUM THREE COATS OF FIBERGLASS CLOTH AND EG-800. FINISH WITH COMPATIBLE EXTERIOR PAINT, COLOR AS SELECTED BY ARCHITECT.
- SMOKE/FIRE DAMPERS
- CONTRACTOR SHALL COORDINATE ALL RATED ASSEMBLY'S WITH LATEST EDITION OF ARCHITECTURAL DRAWINGS. CONTRACTOR SHALL ASSUME ALL RESPONSIBILITY TO INSTALL FIRE, COMBINATION FIRE & SMOKE, AND RADIATION DAMPERS IN RATED ASSEMBLY'S.
- FIRE AND SMOKE DAMPERS SHALL BE U.L. LISTED BY RUSKIN OR EQUAL RATED IN ACCORDANCE WITH THE ASSEMBLY IN WHICH DAMPER IS INSTALLED. INSTALL IN ACCORDANCE WITH APPLICABLE CODES AND DAMPER LISTING. DAMPERS SHALL BE DYNAMIC TYPE.
- FIRE DAMPERS AND CEILING DAMPERS MAY BE FUSIBLE LINK TYPE.
- SMOKE DAMPERS AND COMBINATION FIRE/SMOKE DAMPERS SHALL BE ELECTRIC MOTOR OPERATED, REMOTE RESETTABLE TYPE. COORDINATE DAMPER MOTOR VOLTAGE WITH SMOKE DETECTOR BY DIVISION 16, PROVIDE CONTROL VOLTAGE TRANSFORMER IF REQUIRED.
- CONTRACTOR SHALL INSTALL REQUIRED ACCESS DOORS TO EACH FIRE DAMPER AND LABEL ACCORDINGLY.
- AIR DEVICES
- AIR DEVICES SHALL BE TITUS OR METALARE COMMERCIAL TYPE WITH FRAME TYPE SUITABLE FOR CEILING FINISH. ALL CEILING DIFFUSERS WITHIN A SPACE SHALL HAVE UNIFORM FACE DIMENSIONS UNLESS OTHERWISE NOTED. SEE DRAWINGS FOR OTHER REQUIREMENTS.
- CEILING DIFFUSERS SHALL BE SQUARE LOUVER TYPE WITH OPPOSED BLADE DAMPERS, ALUMINUM CONSTRUCTION, OFF WHITE FINISH, SIZES AS SHOWN ON DRAWINGS.
- SUPPLY AIR REGISTERS SHALL BE HORIZONTAL FACE TYPE WITH OPPOSED BLADE DAMPERS, OFF WHITE FINISH, ALUMINUM, SIZES AS SHOWN ON DRAWINGS.
- CEILING RETURN AIR AND EXHAUST GRILLES SHALL BE 2" X 2" EGGORATE TYPE WITH OFF-WHITE FINISH, ALUMINUM, SIZES AS SHOWN ON DRAWINGS.
- SIDEWALL RETURN AIR GRILLES SHALL BE HORIZONTAL FACE TYPE ALUMINUM (STEEL CONSTRUCTION FOR GRILLES NEAR FLOOR), OFF-WHITE FINISH OR AS SPECIFIED BY OWNER, SIZE AS SHOWN ON DRAWINGS.
- AIR DEVICES IN CEILINGS NOT EASILY ACCESSIBLE SHALL HAVE CABLE-OPERATED ACTUATED DAMPERS OR BALANCING DAMPERS AT THE AIR DEVICE.
- LOUVERS AND DAMPERS
- INTAKE AND RELIEF AIR LOUVERS SHALL BE AMERICAN WARMING, RUSKIN, LOUVERS AND DAMPERS OR VENT PRODUCTS, 6" DEEP "STORMPROOF", DRAINABLE DESIGN, FABRICATED OF EXTRUDED ALUMINUM. LOUVER SHALL BE SUPPLIED WITH ALUMINUM BIRD SCREEN IN A REMOVABLE FRAME AND WITH PRIMER FINISH FOR PAINTING TO ARCHITECT'S SPECIFICATIONS. SEE DRAWINGS FOR SIZES. LOUVERS SHALL BE AMCA RATED. WATER PENETRATION SHALL NOT EXCEED 0.01 OZ./S.F. PER MINUTES AT 1,000 FPM WITH WATER FLOW AT 0.25 GPM.
- DAMPERS SHALL BE AMERICAN WARMING, RUSKIN, LOUVERS AND DAMPERS OR VENT PRODUCTS, ELECTRIC MOTORIZED DAMPER OF EXTRUDED ALUMINUM. DAMPER SHALL BE LOW LEAKAGE TYPE, RUSKIN CD-50 OR EQUAL.
- MANUAL VOLUME DAMPERS SHALL BE INSTALLED IN AREAS ACCESSIBLE FOR BALANCING. IF ACCESS IS NOT AVAILABLE VIA ACCESS DOORS OR REMOVABLE CEILING TILE, PROVIDE CABLE OPERATED DAMPER WITH CABLE INSIDE AIRSTREAM OR OUTSIDE AIRSTREAM.
- FLUES AND VENTS
- CONTRACTOR SHALL FURNISH AND INSTALL ALL FLUES AND VENTS. FLUES AND VENTS SHALL BE U.L. LISTED DOUBLE WALL TYPE, "B" OR PVC FOR CONDENSING FURNACES PER MANUFACTURER WITH SIZES AS INDICATED ON DRAWINGS.
- CONSTRUCTION AND HEIGHT OF FLUE ABOVE ROOF SHALL CONFORM TO REQUIREMENTS OF NFPA 54 AND LOCAL CODES.
- PAINTING
- ALL EQUIPMENT LOCATED OUTDOORS SHALL BE FURNISHED WITH FACTORY FINISH. CONTRACTOR SHALL TOUCH UP ANY SCRATCHES OR CHIPS IN ORIGINAL FINISH WITH FACTORY TOUCH-UP PAINT.
- PAINT INSIDE OF DUCTS VISIBLE TO VIEW WITH FLAT BLACK PAINT.
- EQUIPMENT OR DEVICES INSTALLED AND SCRATCHED SHALL BE PAINTED USING MANUFACTURERS TOUCH-UP PAINT OR REPLACED WITH NEW.
- SLEEVES
- PROVIDE 18 GAGE SLEEVING AT MASONRY WALLS, ETC.
- SEAL ALL PENETRATIONS OF RATED PARTITIONS WITH U.L. LISTED FIRE BARRIER MATERIAL.
- CONTROLS
- HVAC CONTRACTOR SHALL BE RESPONSIBLE FOR INSTALLATION OF ALL LOW VOLTAGE CONTROL WIRING AND CONDUIT REQUIRED TO OPERATE THE HVAC EQUIPMENT AS SPECIFIED HEREIN OR AS SHOWN ON DRAWINGS. WIRING SHALL BE INSTALLED IN ACCORDANCE WITH LATEST EDITION OF NEC. REFER TO DRAWINGS OR SCHEDULE FOR COORDINATION OF EQUIPMENT STARTERS AND SAFETY DISCONNECTS.
- DUCT MOUNTED SMOKE DETECTORS FURNISHED AND INSTALLED ON SUPPLY AND RETURN DUCT FOR ALL UNITS. COORDINATE POWER CONNECTIONS WITH DIVISION 16 IF BUILDING HAS FIRE ALARM SYSTEM; OTHERWISE WIRE TO SHUT-DOWN UNIT IN PRESENCE OF SMOKE.
- MANUFACTURERS CONTROLS SHALL BE COMPATIBLE WITH UNITS AND UNIT CAPABILITIES. VERIFY ALL COOLING AND HEATING STAGES WORK AS INTENDED.
- NATURAL GAS PIPING
- PIPE SHALL BE SCHEDULE 40 BLACK STEEL CONFORMING TO ASTM A53, ASSEMBLED WITH MALLEABLE IRON (ANSI/ASME 816.3) OR FORMED STEEL WELDING FITTINGS. USE WELDING FITTINGS ON 2" AND ABOVE, ON ALL BURIED PIPING, AND ON ALL PIPING FROM GAS METER TO GAS PRESSURE REGULATORS (ON PIPING SYSTEMS ABOVE STANDARD PRESSURE). WELDING SHALL CONFORM TO ANSI/AWS D1.1.
- PIPE BELOW GRADE SHALL BE COATED AND WRAPPED. STRAIGHT LENGTHS SHALL BE FURNISHED WITH FACTORY-APPLIED ELECTRICALLY INSULATING COATING. FITTINGS AND DAMAGED COATING SHALL BE WRAPPED WITH TAPECOAT CT APPLIED IN ACCORDANCE WITH MANUFACTURER'S LATEST PRINTED INSTRUCTIONS. PROVIDE INSULATING FILLINGS (ABOVE GRADE) AT EACH END OF PIPE RUN.
- IF APPROVED BY THE LOCAL GAS UTILITY, PIPE BELOW GRADE SHALL BE DRISCOPIE 6500 OR AS APPROVED POLYETHYLENE TYPE, INSTALLED TO CONFORM TO MANUFACTURER'S RECOMMENDATIONS AND LOCAL UTILITY REQUIREMENTS.
- GAS PRESSURE REGULATORS, WHERE INDICATED, SHALL BE INTERNALLY VENTED TYPE. VENT TO OUTSIDE WHEN APPLICABLE. DO NOT INSTALL ABOVE CEILINGS.
- PROVIDE GAS COCK AND DIRT LEG AT EACH APPLIANCE AND WHERE INDICATED ON DRAWINGS. PROVIDE DIELECTRIC FLANGES AT DISSIMILAR METAL CONNECTIONS AND WHERE INDICATED ON DRAWINGS.
- AFTER COMPLETION OF WORK, AND BEFORE BACKFILLING, IF REQUIRED, THE ENTIRE SYSTEM SHALL BE TESTED TO AN AIR PRESSURE OF 125 PSI FOR A PERIOD OF TWO HOURS AND PROVED TIGHT BY INSPECTION. FURNISH RESULTS OF THE TESTS, SIGNED BY THE CONTRACTOR, TO THE ARCHITECT-ENGINEER.
- GREASE HOOD DUCT SYSTEM
- ALL DUCT SYSTEMS SERVING EXHAUST HOODS REMOVING SMOKE OR GREASE-LADEN VAPORS SHALL BE CONSTRUCTED AND SUPPORTED BY STEEL MINIMUM 0.0598 INCH THICKNESS IN ACCORDANCE WITH NFPA 96. ALL SEAM AND JOINTS SHALL BE CONTINUOUS EXTERNAL WELD, LIQUID TIGHT. CLEAN-OUT OPENINGS ON THE SIDES OF DUCT SHALL BE OF SUFFICIENT SIZE TO PERMIT THOROUGH CLEANING OF DUCT AND SHALL HAVE LIQUID TIGHT FITTING DOORS OF SAME THICKNESS AS DUCT. DUCT SIZE SHALL MAINTAIN MINIMUM AIR VELOCITY OF 1500 FT. PER MINUTE.

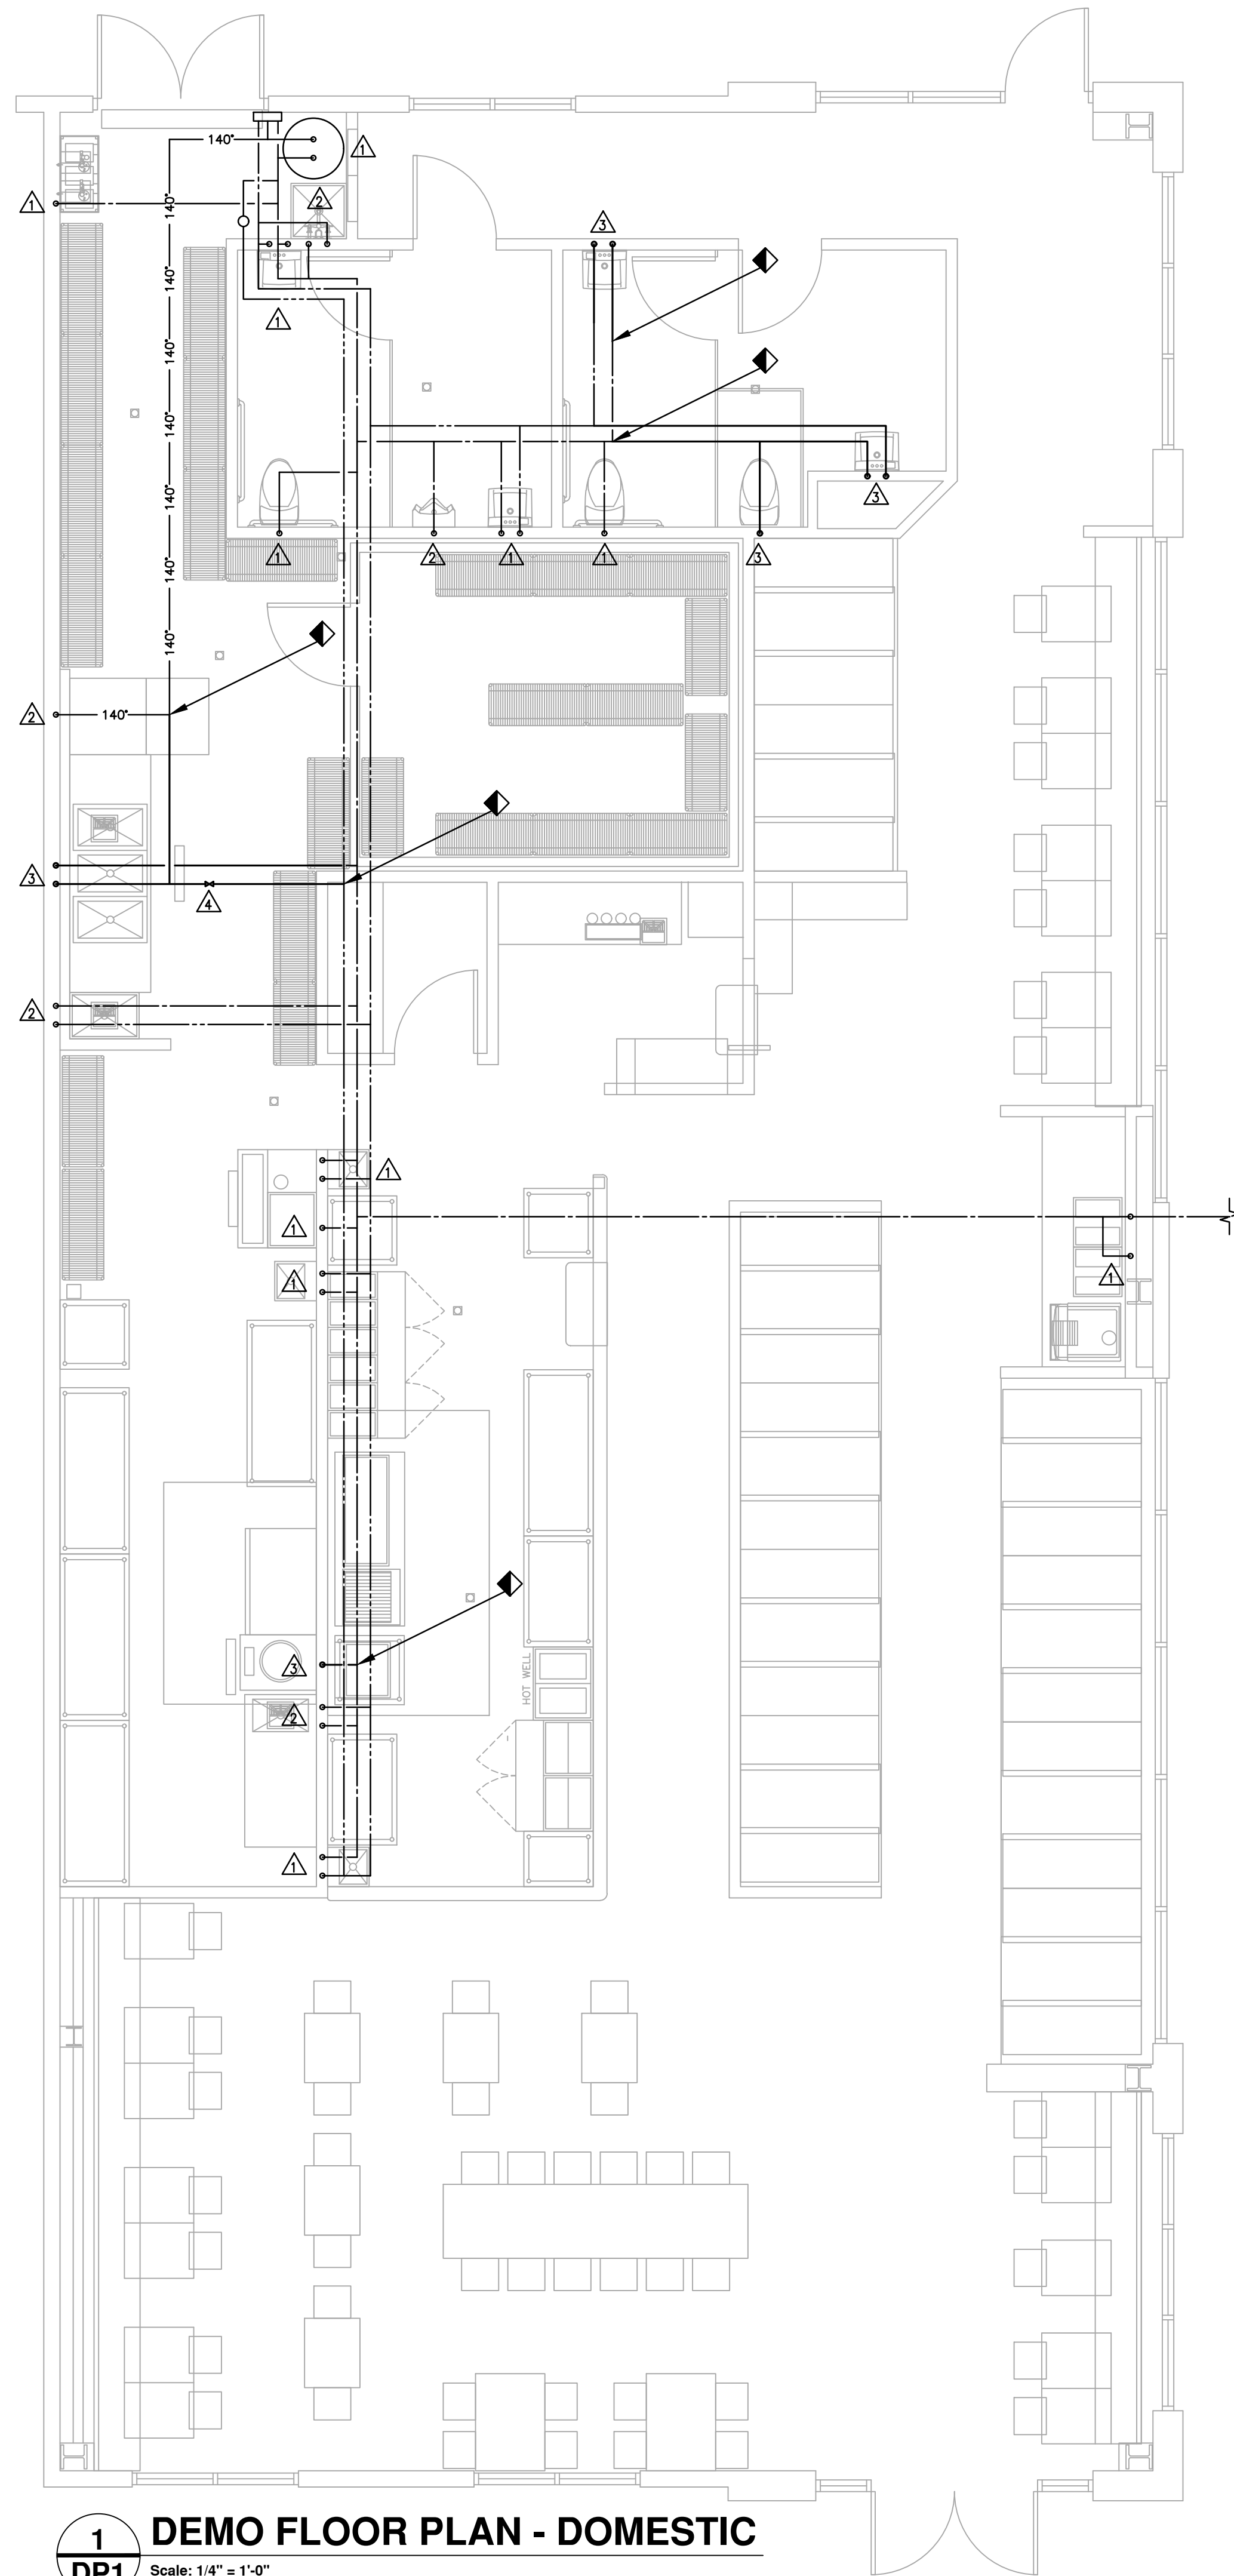


1
DP1 **DEMO FLOOR PLAN - DOMESTIC**
Scale: 1/4" = 1'-0"

DEMOLITION NOTES:

- △ EXISTING FIXTURE TO REMAIN.
- △ PLUMBING FIXTURE TO BE REPLACED WITH NEW AS SCHEDULED. REUSE EXISTING PIPING.
- △ EXISTING FIXTURE TO BE DEMOLISHED. DEMOLISH ALL ASSOCIATED PIPING AS SHOWN. VERIFY EXACT LOCATION.
- △ RELOCATE BALANCING VALVE TO NEW LOCATION AS SHOWN ON P1.1.

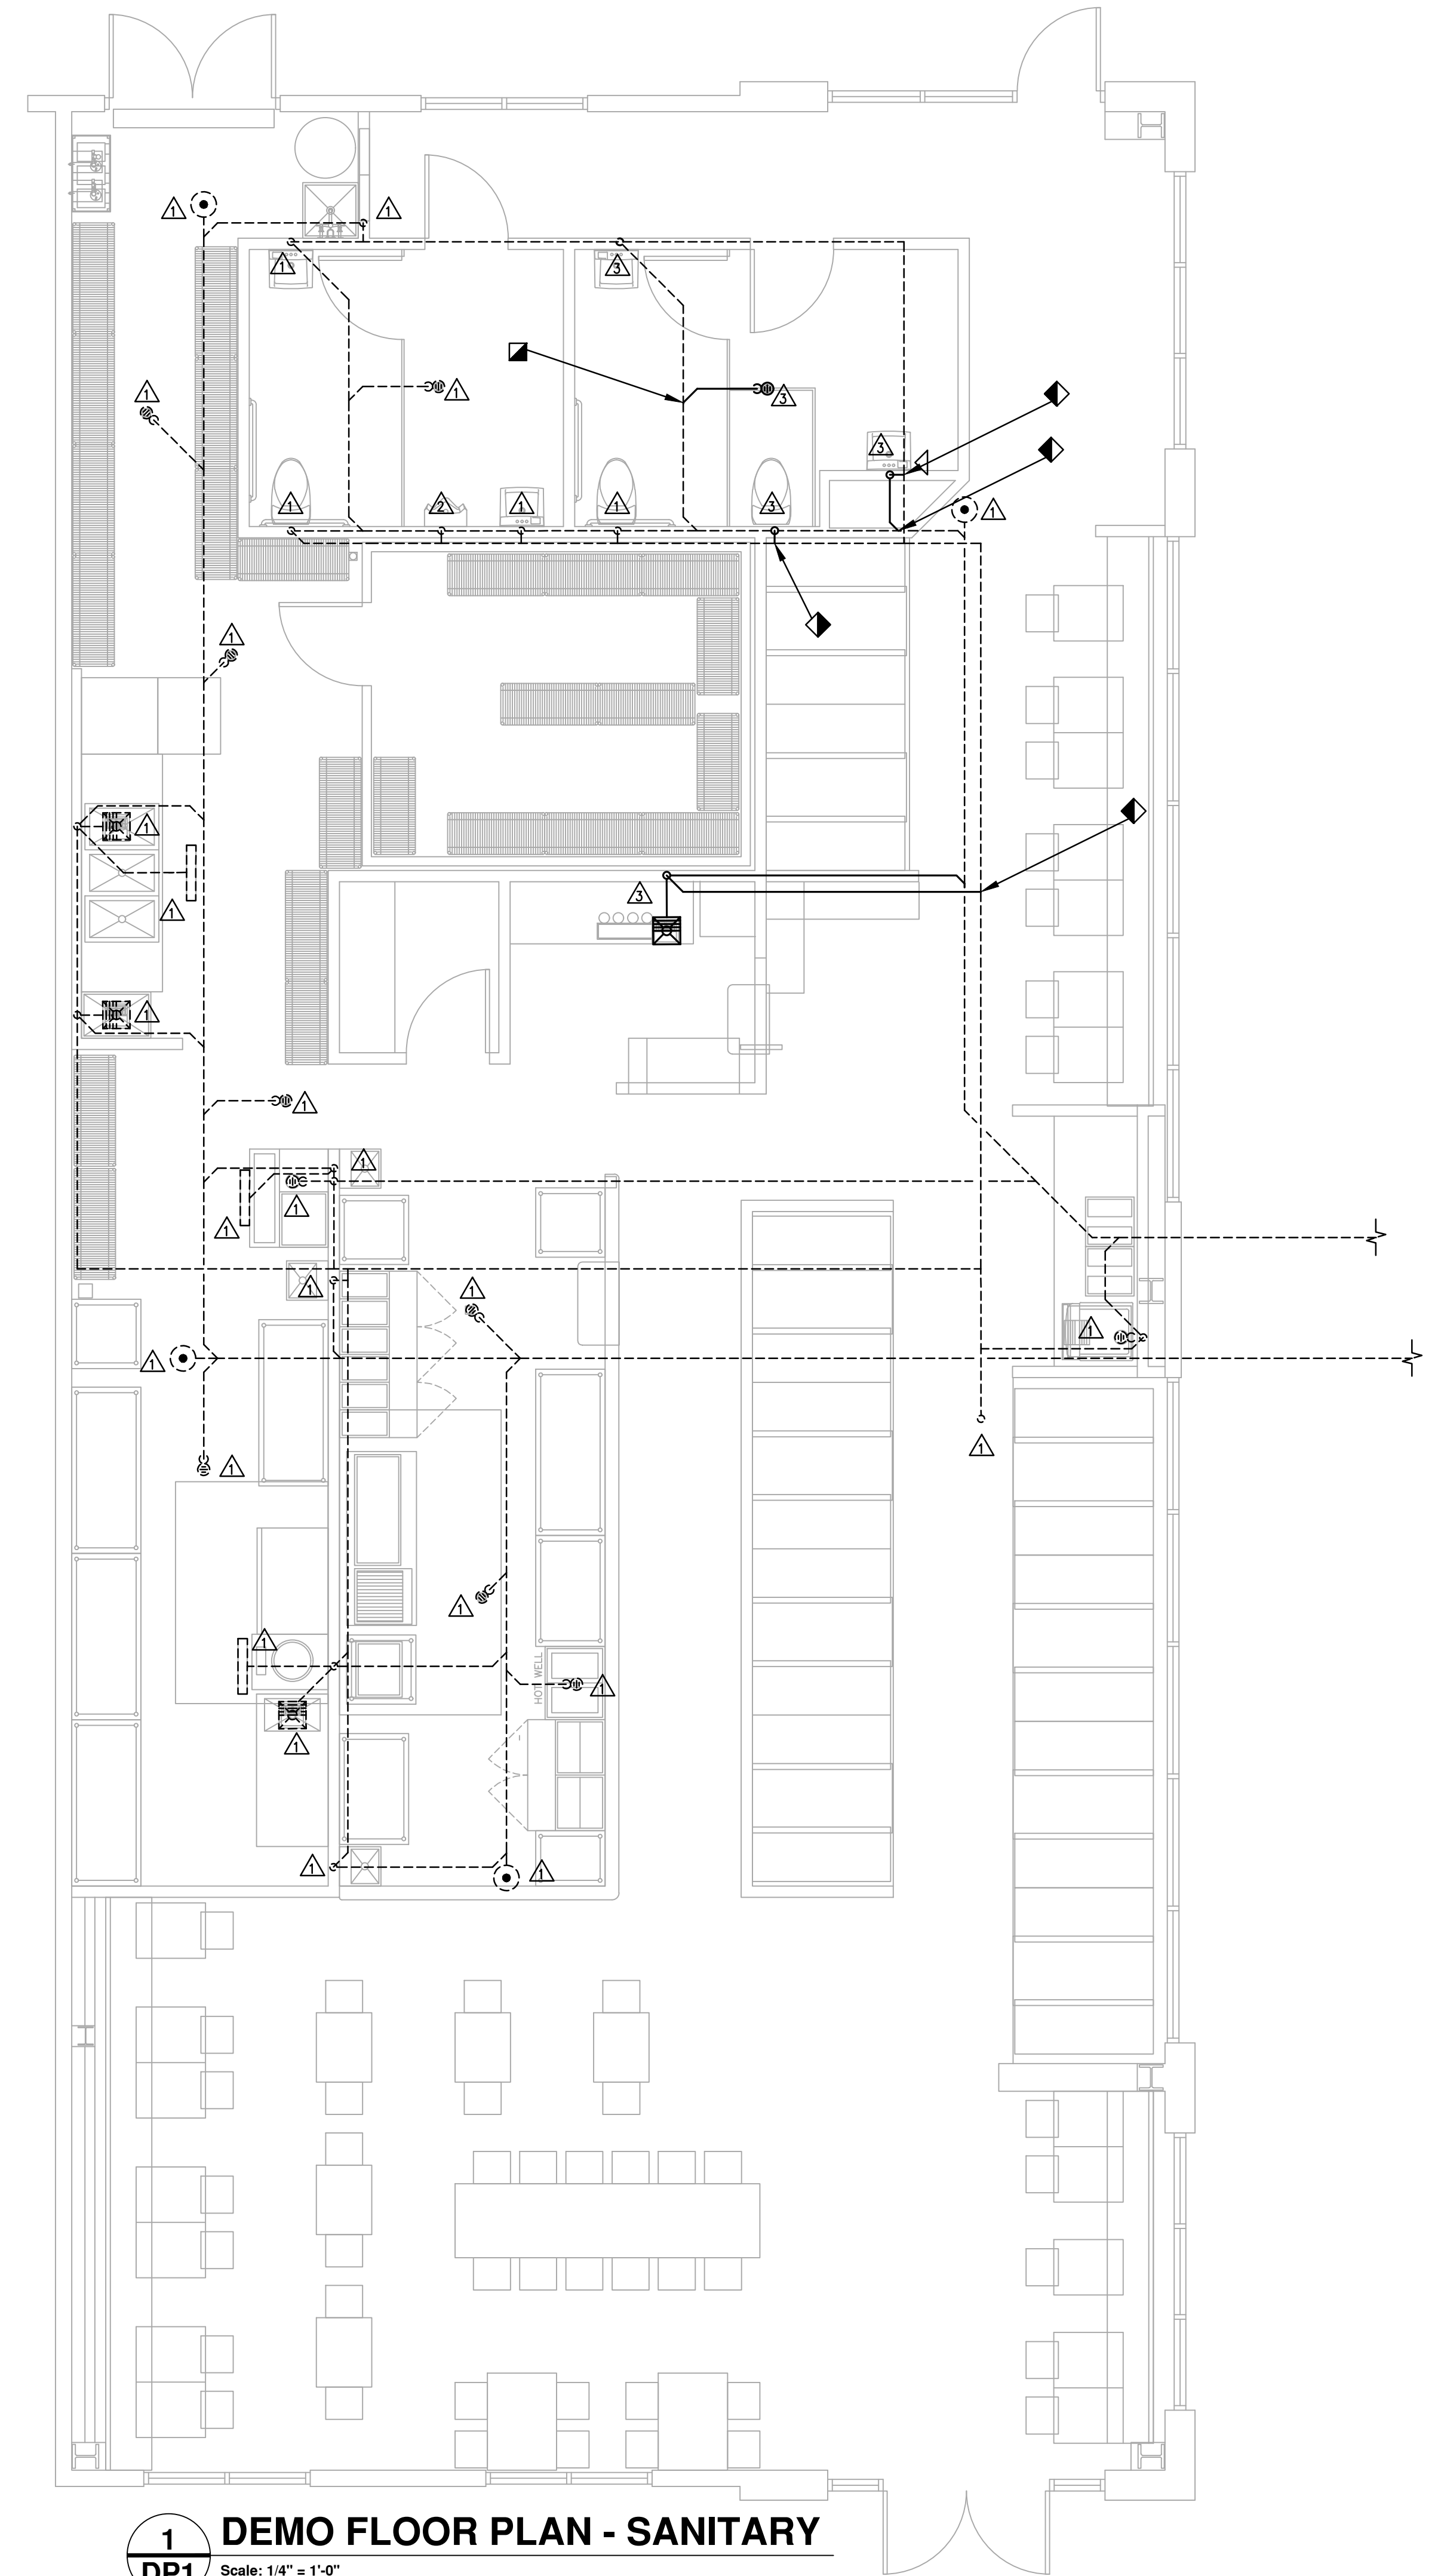

1
DP1 **DEMO FLOOR PLAN - SANITARY**
Scale: 1/4" = 1'-0"

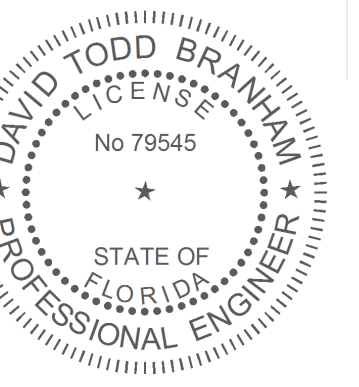



Biscuit Belly
15463 Panama City Beach Pkwy Ste B
Panama City Beach, FL 32413

insomnia DESIGN

15 Sept 2026
MEP Permit

DEMO FLOOR
PLAN - PLUMBING



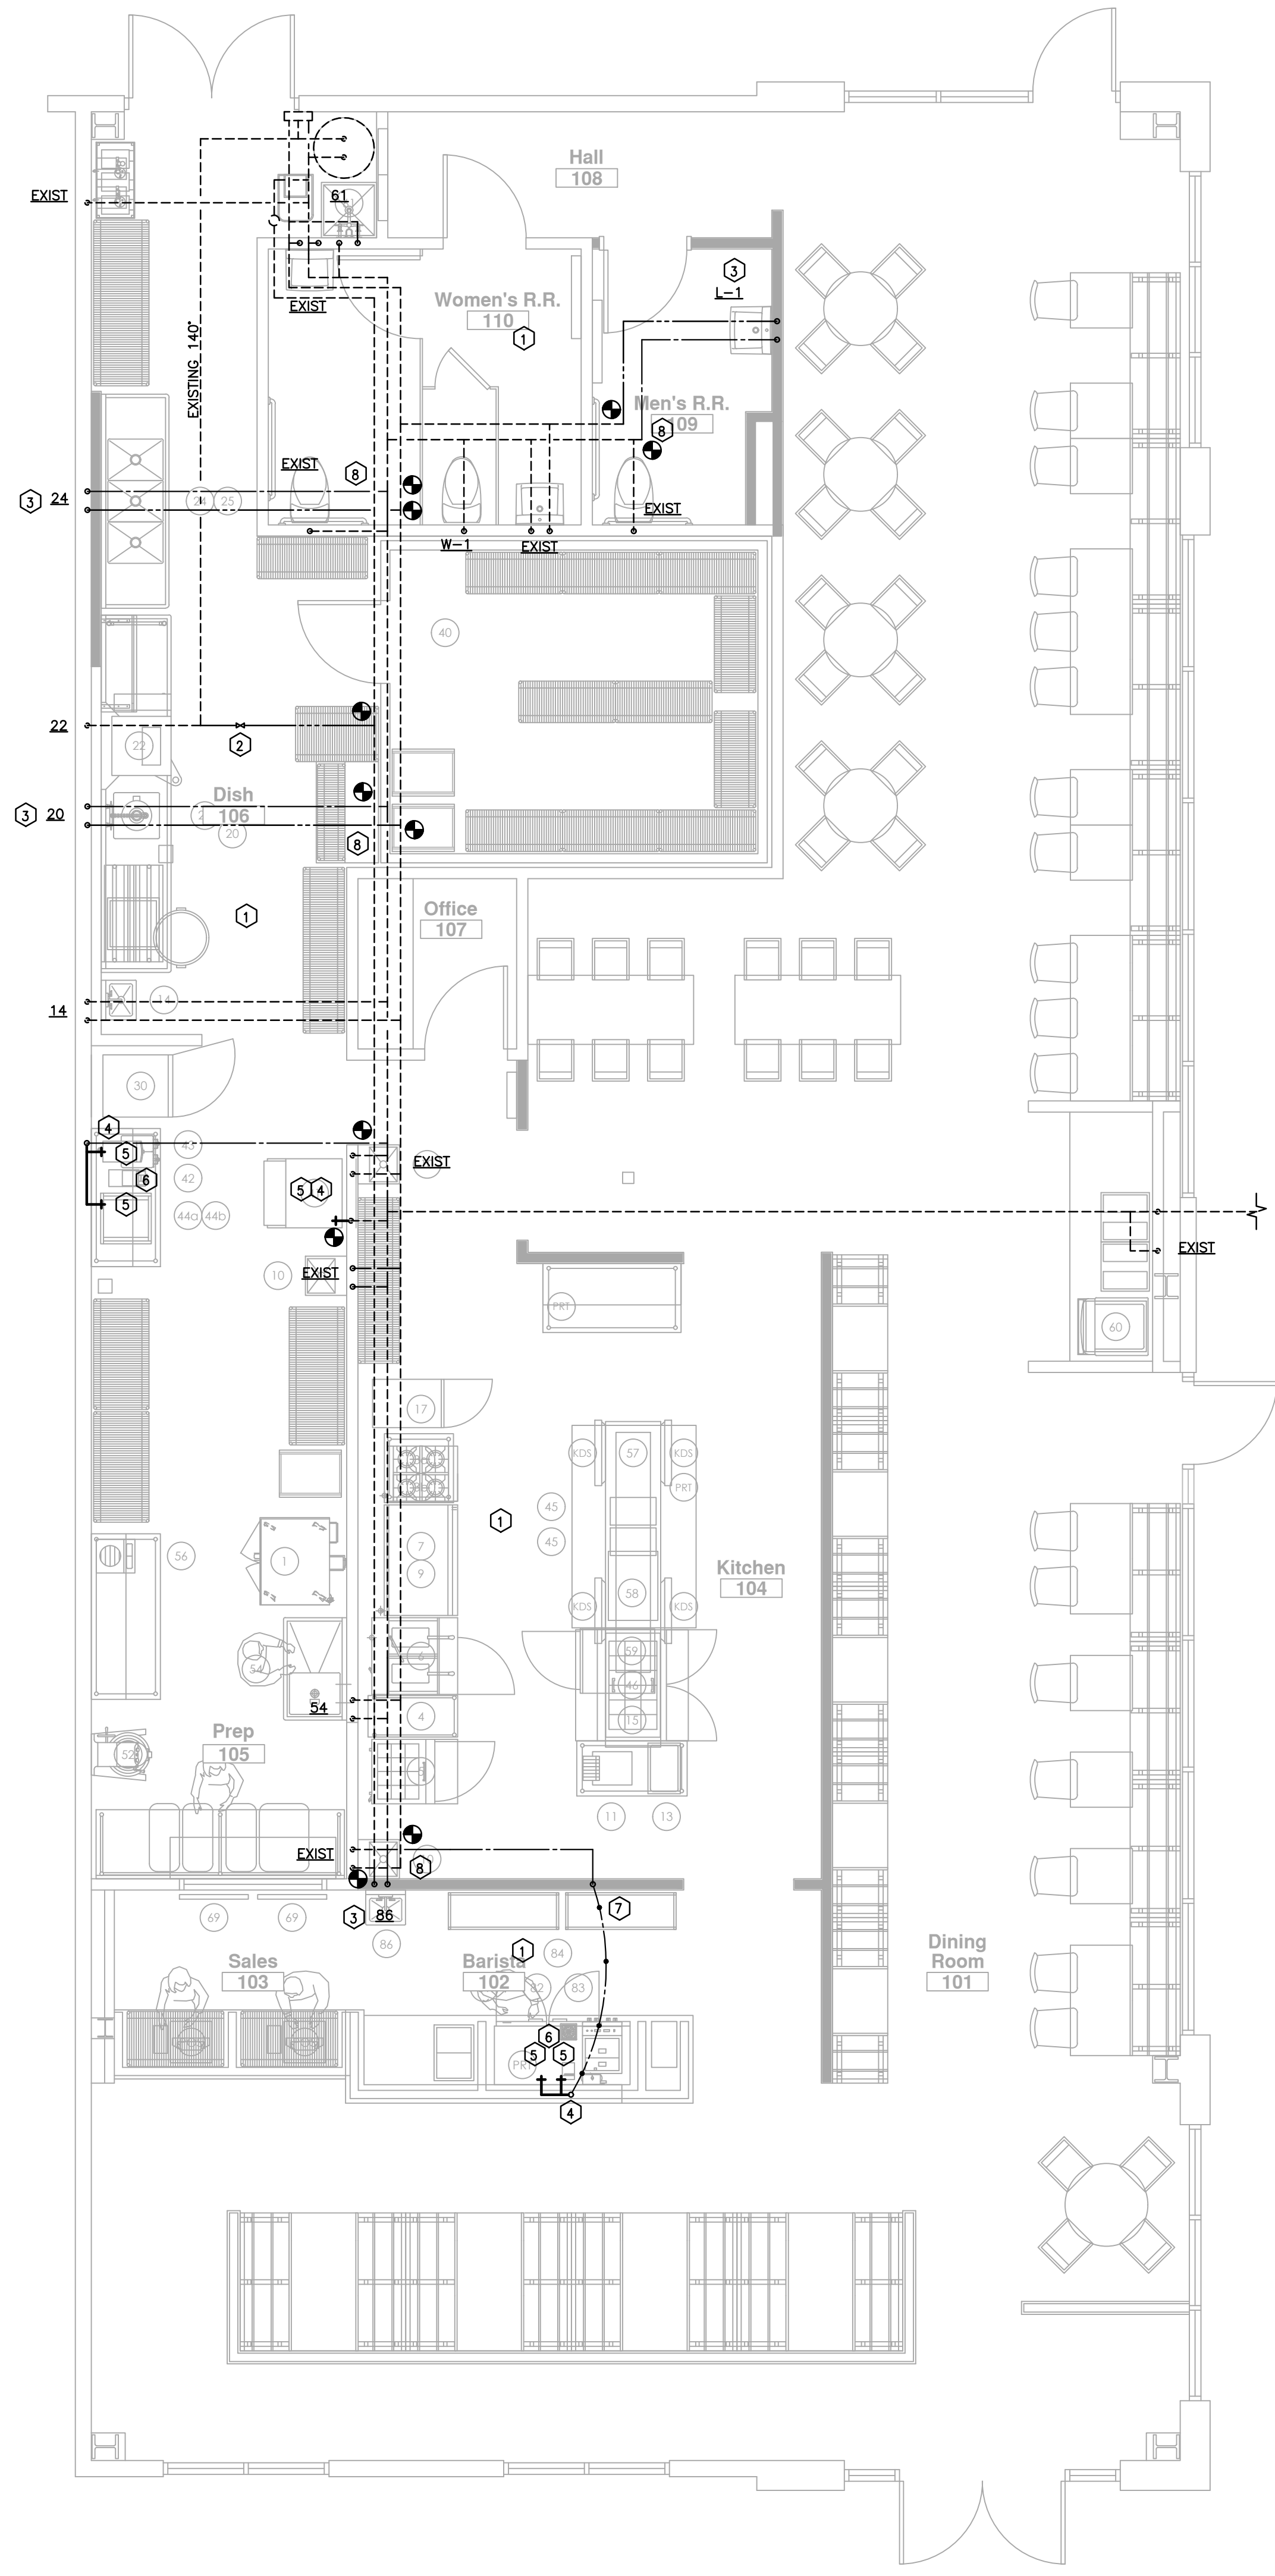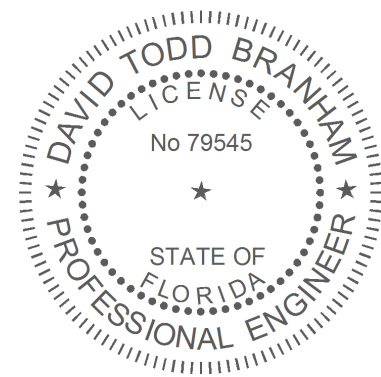

DOMESTIC NOTES:

- 1 CONTRACTOR SHALL COORDINATE ALL PLUMBING REQUIREMENTS WITH OWNER FURNISHED EQUIPMENT FOR A COMPLETE OPERABLE SYSTEM. REFERENCE ARCHITECTURAL KITCHEN SHEETS FOR ADDITIONAL INFORMATION.
- 2 NEW BALANCING VALVE LOCATION. TIE IN NEW HWR AS SHOWN.
- 3 1/2" CW AND 1/2" HW DOWN TO FIXTURE WITH SHUT-OFF VALVES.
- 4 1/2" CW TO FILTER.
- 5 1/2" FILTERED CW TO FIXTURE WITH SHUT-OFF VALVE.
- 6 IN-LINE WATER FILTERS, PRESSURE REDUCING VALVES, AND BACKWATER VALVES REQUIRED FOR EQUIPMENT SHALL BE INSTALLED.
- 7 COUNTER-HEIGHT HALF WALL. ALL WATER LINES TO DROP DOWN IN FULL HEIGHT WALL AND RAN UNDERGROUND.
- 8 CONNECT NEW 1/2" CW AND 1/2" HW TO EXISTING OF EQUAL OR GREATER SIZE.



GENERAL PLUMBING NOTES:

- 1. THESE DRAWINGS ARE DIAGRAMMATIC AND SHOW GENERAL PLUMBING LAYOUTS AND PIPE ROUTING FOR BIDDING PURPOSES ONLY. IT IS THE RESPONSIBILITY OF THE CONTRACTOR TO PREPARE DETAILED SHOP DRAWINGS AND TO CONFIRM SPACE ALLOCATIONS.
- 2. CONTRACTOR SHALL COORDINATE INSTALLATION FOR ALL EQUIPMENT PROVIDED BY OTHERS. USE LATEST EDITION OF VENDOR DRAWINGS FOR MODEL NUMBERS AND REQUIREMENTS FOR A COMPLETE OPERABLE SYSTEM. CONTRACTOR SHALL ASSUME ALL RESPONSIBILITY FOR A COMPLETE OPERABLE SYSTEM.
- 3. SEE ARCHITECTURAL AND STRUCTURAL DRAWINGS FOR ALL BUILDING DIMENSIONS, DETAILS, ELEVATIONS AND EXACT LOCATIONS OF FIXTURES.
- 4. CONTRACTOR SHALL VERIFY ALL FLOW LINES PRIOR TO ROUGHING IN.
- 5. ALL WORK SHALL CONFORM TO APPLICABLE PLUMBING CODE, LOCAL BUILDING CODES AND STATE HEALTH REGULATIONS HAVING JURISDICTION.
- 6. PLUMBING CONTRACTOR SHALL REVIEW ARCHITECTURAL, STRUCTURAL, ELECTRICAL, SPRINKLER AND MECHANICAL DRAWINGS AND COORDINATE HIS WORK WITH ALL OTHER TRADES FOR PIPE ROUTING AND EQUIPMENT PLACEMENT. AVOID INTERFERENCE WITH ARCHITECTURAL FEATURES, BEAMS, FOOTINGS, WINDOWS, ETC. NOTIFY ARCHITECT OF ANY CONFLICTS.
- 7. CONTRACTOR MAY RE-LAYOUT TO HIS ADVANTAGE CODE EQUIVALENT PLUMBING SO AS TO REDUCE INSTALLATION COSTS, OR TO RE-ROUTE TO AVOID CONFLICTS WITH OTHER TRADES AFTER FIRST HAVING RECEIVED THE APPROVAL OF THE ARCHITECT / ENGINEER.
- 8. PLUMBING CONTRACTOR SHALL COORDINATE WITH ELECTRICAL CONTRACTOR ALL VOLTAGES, ELECTRICAL LOADS, ETC. OF ELECTRICALLY OPERATED EQUIPMENT PRIOR TO ORDERING. ALL EQUIPMENT SHALL BE U.L. AND N.E.M.A. LISTED.
- 9. PLUMBING CONTRACTOR SHALL FURNISH ACCESS PANELS TO BE INSTALLED BY GENERAL CONTRACTOR AS REQUIRED FOR PLUMBING INSTALLATIONS.
- 10. ALL VALVES AND SHOCKSTOPS SHALL BE ACCESSIBLE.
- 11. SLEEVES SHALL BE INSTALLED WHERE PIPING PASSES THROUGH STRUCTURE.
- 12. ALL OPENINGS THROUGH RATED WALLS SHALL BE SEALED WITH AN APPROVED FIREPROOFING TO MAINTAIN THE INTEGRITY OF THE WALL.
- 13. PROVIDE MANUFACTURED COMPATIBLE PIPE HANGERS, RODS AND INSERTS, OR CLAMPS FOR THE PROPER SUPPORT OF ALL PIPING. NO BAND IRON, TIE WIRE, METAL STRAPPING OR WIRE STRAPPING WILL BE PERMITTED.
- 14. PROVIDE SUITABLE BACKING AND SUPPORT FOR ALL PLUMBING FIXTURES.
- 15. OFFSET ALL V.T.R.'S AS REQUIRED WHETHER OR NOT SHOWN ON DRAWINGS.
- 16. ALL V.T.R.'S SHALL BE A MINIMUM OF 10 FT. AND/OR AS REQUIRED BY CODE AWAY FROM A/C INTAKES WHETHER OR NOT SHOWN ON PLANS.
- 17. ALL PIPING SHALL BE LABELED.
- 18. UPON COMPLETION OF THE WORK COVERED BY THIS CONTRACT, FURNISH THE OWNER WITH ONE (1) SET OF REPRODUCIBLE RECORD DOCUMENTS WHICH SHOW ALL PLUMBING INSTALLED UNDER THIS CONTRACT.
- 19. ALL PIPING SUBJECT TO FREEZING SHALL BE WRAPPED WITH HEAT TAPE EQUAL TO RAYCHEM "XL TRACE" AND SHALL BE INSULATED.
- 20. ALL WATER PIPING SHALL BE SLOPED TO LOW POINTS AND PROVIDED WITH DRAINS SO THAT ENTIRE SYSTEM MAY BE DRAINED. ALL DRAINS SHALL BE ACCESSIBLE.
- 21. PROVIDE ALL V.T.R.'S WITH 4 LB. HIGH BOOT LEAD FLASHING.
- 22. ALL WATER PIPING INSTALLED BELOW SLAB SHALL BE TYPE "K" COPPER, 2" OR SMALLER SHALL BE LOOPED (NO JOINTS). LARGER THAN 2" SHALL HAVE SILFOS BRAZED JOINTS.
- 23. DO NOT RUN ANY WATER PIPING ABOVE ELECTRICAL PANELS (COORDINATE WITH ELECTRICAL CONTRACTOR).
- 24. CONTRACTOR SHALL NOT INSTALL ANY DEAD ENDS IN WATER PIPING. WATER HAMMER ARRESTORS AND VALVED WATER CONNECTIONS FOR FUTURE SHALL BE INSTALLED AS CLOSE AS POSSIBLE TO TEE CONNECTION. WATER HAMMER ARRESTORS SHALL BE INSTALLED ABOVE CEILING FOR ACCESS PURPOSES.

1

FLOOR PLAN - DOMESTIC

Scale: 1/4" = 1'-0"

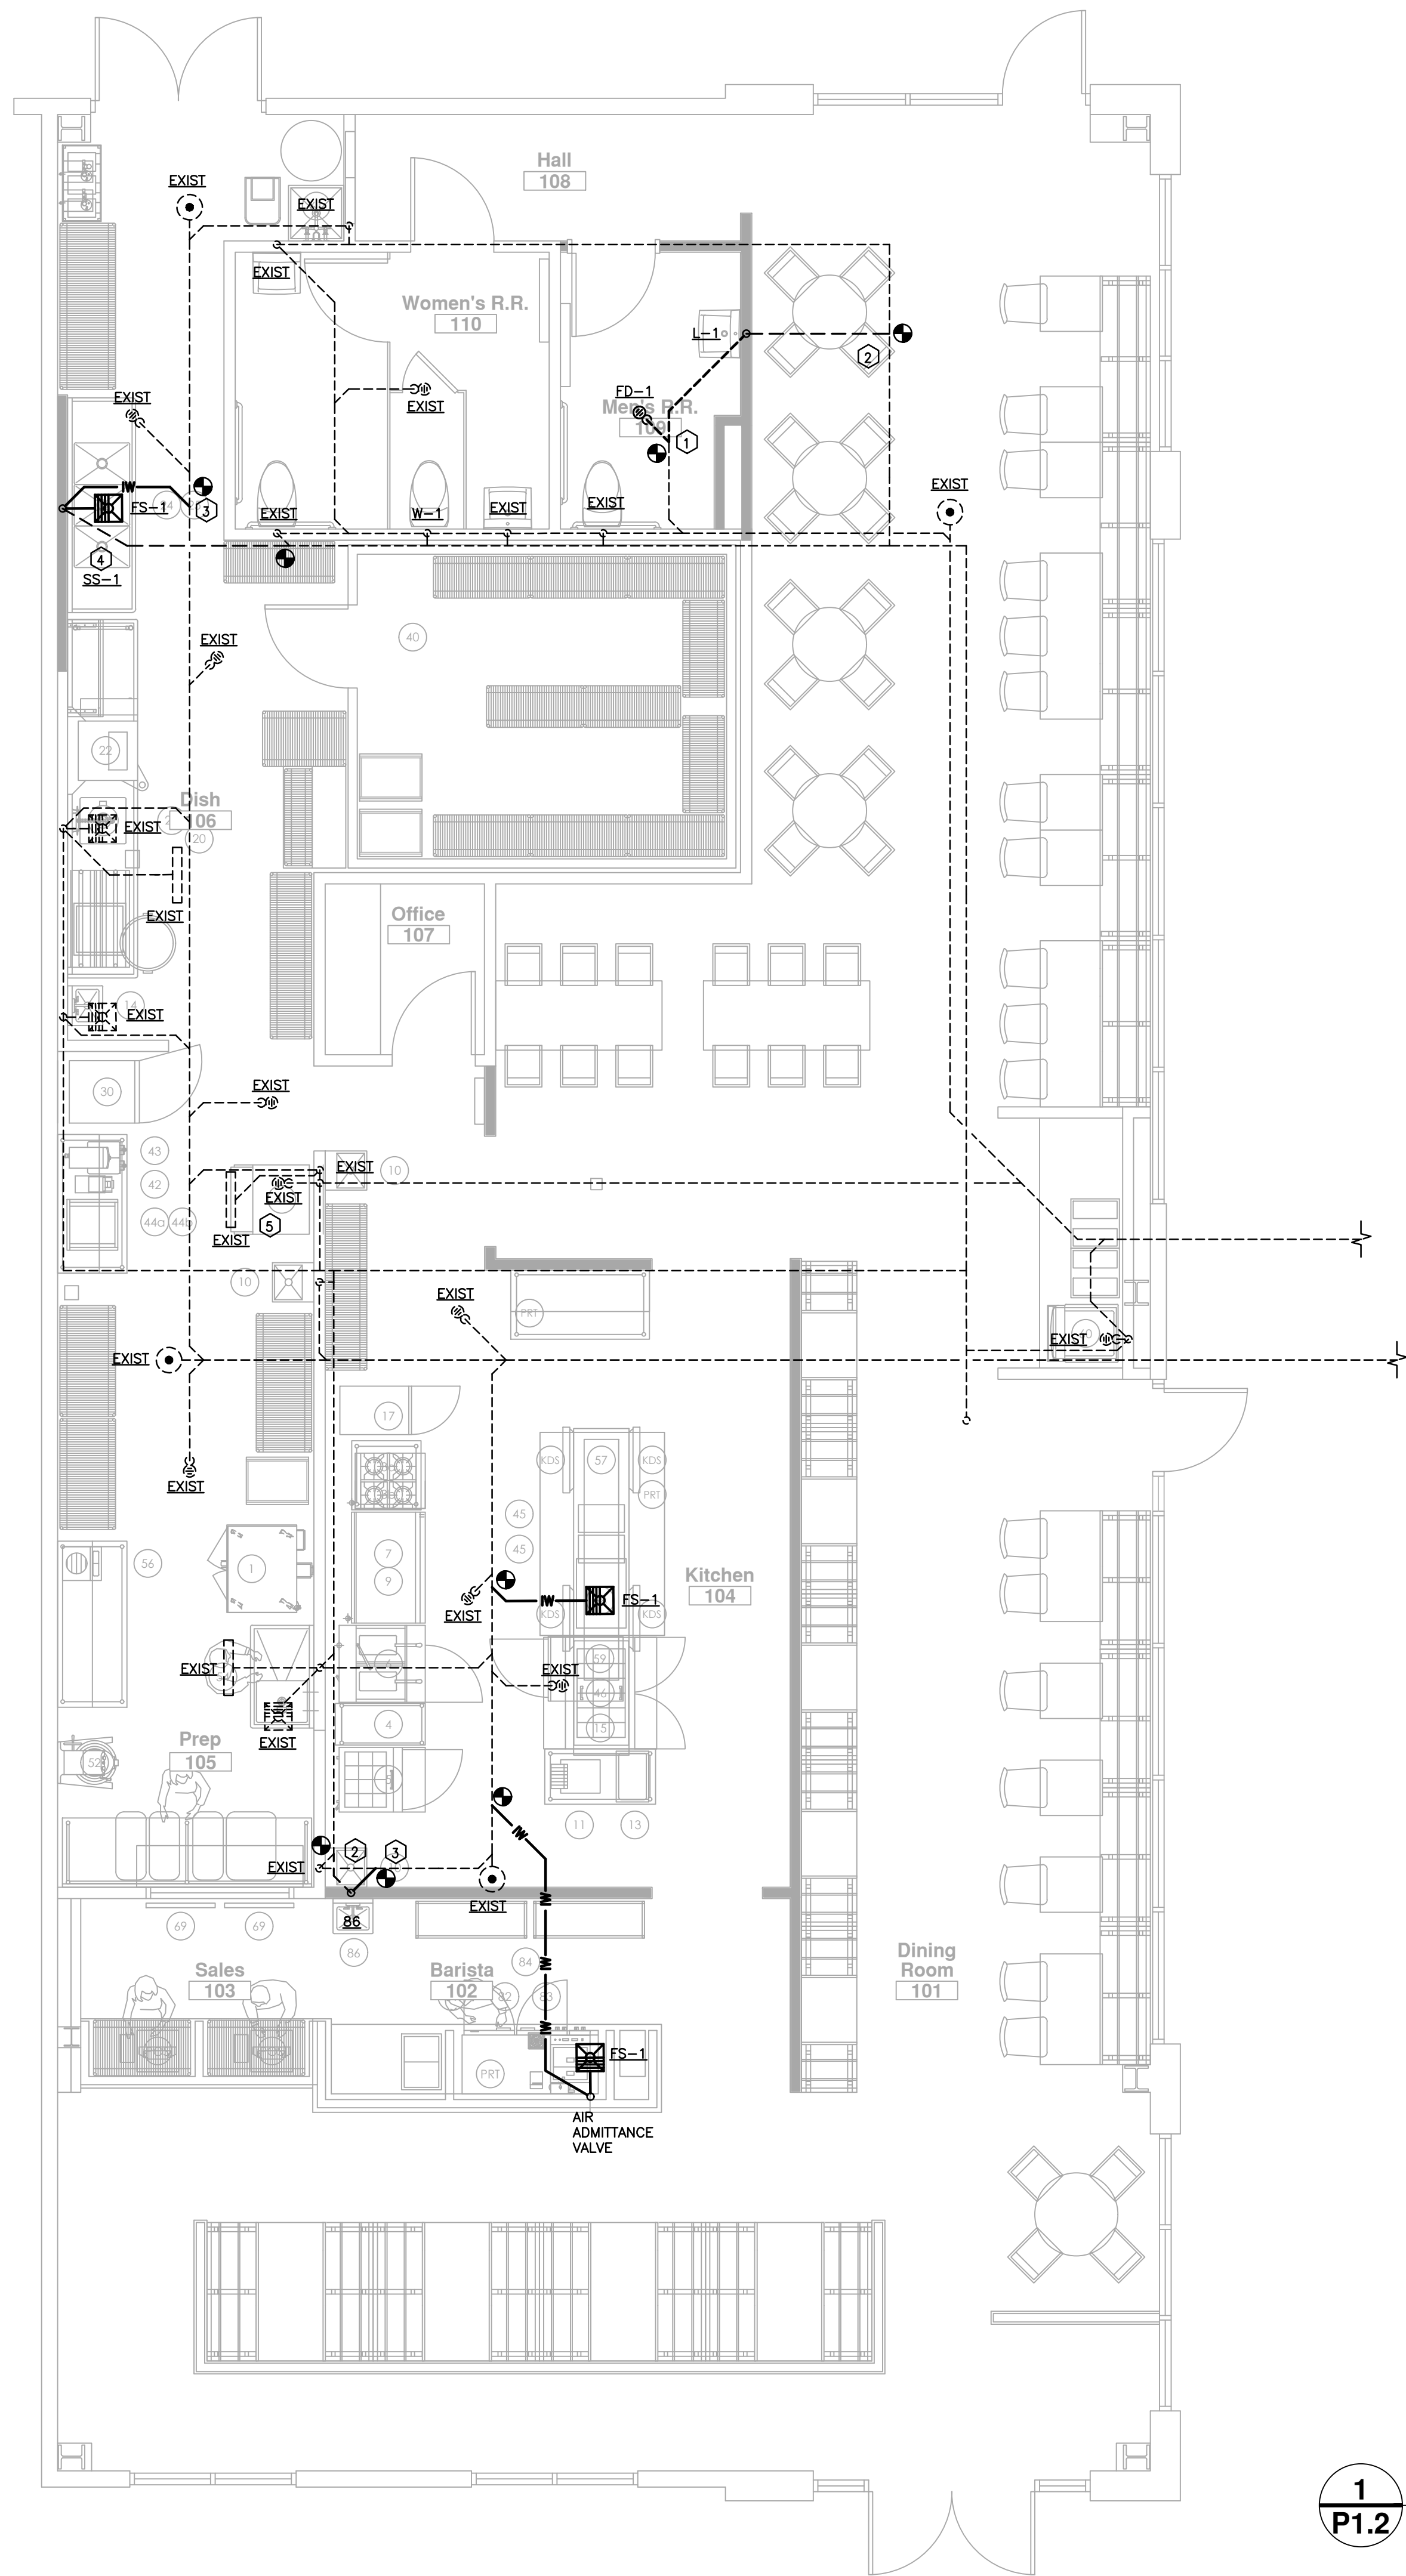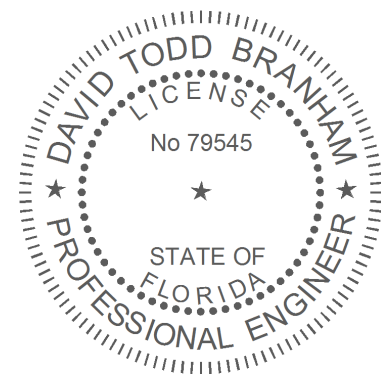

SANITARY NOTES:

- 1 TIE NEW SANITARY INTO EXISTING OF EQUAL OR GREATER SIZE. FIELD VERIFY EXACT LOCATION.
- 2 TIE NEW VENT INTO EXISTING OF EQUAL OR GREATER SIZE. FIELD VERIFY EXACT LOCATION.
- 3 TIE NEW GREASE INTO EXISTING OF EQUAL OR GREATER SIZE. FIELD VERIFY EXACT LOCATION OF EXISTING GREASE TRAP AND PIPING.
- 4 3-COMPARTMENT SINKS SHALL DISCHARGE (EACH COMPARTMENT) INDEPENDENTLY OF EACH OTHER INTO FLOOR SINK WITH AIR GAP. ROUTE TIGHT TO WALL.
- 5 DRAIN ICE MACHINE TO HUB DRAIN WITH AIR-GAP.

GENERAL PLUMBING NOTES:

- 1. THESE DRAWINGS ARE DIAGRAMMATIC AND SHOW GENERAL PLUMBING LAYOUTS AND PIPE ROUTING FOR BIDDING PURPOSES ONLY. IT IS THE RESPONSIBILITY OF THE CONTRACTOR TO PREPARE DETAILED SHOP DRAWINGS AND TO CONFIRM SPACE ALLOCATIONS.
- 2. CONTRACTOR SHALL COORDINATE INSTALLATION FOR ALL EQUIPMENT PROVIDED BY OTHERS. USE LATEST EDITION OF VENDOR DRAWINGS FOR MODEL NUMBERS AND REQUIREMENTS FOR A COMPLETE OPERABLE SYSTEM. CONTRACTOR SHALL ASSUME ALL RESPONSIBILITY FOR A COMPLETE OPERABLE SYSTEM.
- 3. SEE ARCHITECTURAL AND STRUCTURAL DRAWINGS FOR ALL BUILDING DIMENSIONS, DETAILS, ELEVATIONS AND EXACT LOCATIONS OF FIXTURES.
- 4. CONTRACTOR SHALL VERIFY ALL FLOW LINES PRIOR TO ROUGHING IN.
- 5. ALL WORK SHALL CONFORM TO APPLICABLE PLUMBING CODE, LOCAL BUILDING CODES AND STATE HEALTH REGULATIONS HAVING JURISDICTION.
- 6. PLUMBING CONTRACTOR SHALL REVIEW ARCHITECTURAL, STRUCTURAL, ELECTRICAL, SPRINKLER AND MECHANICAL DRAWINGS AND COORDINATE HIS WORK WITH ALL OTHER TRADES FOR PIPE ROUTING AND EQUIPMENT PLACEMENT. AVOID INTERFERENCE WITH ARCHITECTURAL FEATURES, BEAMS, FOOTINGS, WINDOWS, ETC.. NOTIFY ARCHITECT OF ANY CONFLICTS.
- 7. CONTRACTOR MAY RE-LAYOUT TO HIS ADVANTAGE CODE EQUIVALENT PLUMBING SO AS TO REDUCE INSTALLATION COSTS, OR TO RE-ROUTE TO AVOID CONFLICTS WITH OTHER TRADES AFTER FIRST HAVING RECEIVED THE APPROVAL OF THE ARCHITECT / ENGINEER.
- 8. PLUMBING CONTRACTOR SHALL COORDINATE WITH ELECTRICAL CONTRACTOR ALL VOLTAGES, ELECTRICAL LOADS, ETC. OF ELECTRICALLY OPERATED EQUIPMENT PRIOR TO ORDERING. ALL EQUIPMENT SHALL BE U.L. AND N.E.M.A. LISTED.
- 9. PLUMBING CONTRACTOR SHALL FURNISH ACCESS PANELS TO BE INSTALLED BY GENERAL CONTRACTOR AS REQUIRED FOR PLUMBING INSTALLATIONS.
- 10. ALL VALVES AND SHOCKSTOPS SHALL BE ACCESSIBLE.
- 11. SLEEVES SHALL BE INSTALLED WHERE PIPING PASSES THROUGH STRUCTURE.
- 12. ALL OPENINGS THROUGH RATED WALLS SHALL BE SEALED WITH AN APPROVED FIREPROOFING TO MAINTAIN THE INTEGRITY OF THE WALL.
- 13. PROVIDE MANUFACTURED COMPATIBLE PIPE HANGERS, RODS AND INSERTS, OR CLAMPS FOR THE PROPER SUPPORT OF ALL PIPING. NO BAND IRON, TIE WIRE, METAL STRAPPING OR WIRE STRAPPING WILL BE PERMITTED.
- 14. PROVIDE SUITABLE BACKING AND SUPPORT FOR ALL PLUMBING FIXTURES.
- 15. OFFSET ALL V.T.R.'S AS REQUIRED WHETHER OR NOT SHOWN ON DRAWINGS.
- 16. ALL V.T.R.'S SHALL BE A MINIMUM OF 10 FT. AND/OR AS REQUIRED BY CODE AWAY FROM A/C INTAKES WHETHER OR NOT SHOWN ON PLANS.
- 17. ALL PIPING SHALL BE LABELED.
- 18. UPON COMPLETION OF THE WORK COVERED BY THIS CONTRACT, FURNISH THE OWNER WITH ONE (1) SET OF REPRODUCIBLE RECORD DOCUMENTS WHICH SHOW ALL PLUMBING INSTALLED UNDER THIS CONTRACT.
- 19. ALL PIPING SUBJECT TO FREEZING SHALL BE WRAPPED WITH HEAT TAPE EQUAL TO RAYCHEM "XL TRACE" AND SHALL BE INSULATED.
- 20. ALL WATER PIPING SHALL BE SLOPED TO LOW POINTS AND PROVIDED WITH DRAINS SO THAT ENTIRE SYSTEM MAY BE DRAINED. ALL DRAINS SHALL BE ACCESSIBLE.
- 21. PROVIDE ALL V.T.R.'S WITH 4 LB. HIGH BOOT LEAD FLASHING.
- 22. ALL WATER PIPING INSTALLED BELOW SLAB SHALL BE TYPE "K" COPPER, 2" OR SMALLER SHALL BE LOOPED (NO JOINTS). LARGER THAN 2" SHALL HAVE SILFOS BRAZED JOINTS.
- 23. DO NOT RUN ANY WATER PIPING ABOVE ELECTRICAL PANELS (COORDINATE WITH ELECTRICAL CONTRACTOR).
- 24. CONTRACTOR SHALL NOT INSTALL ANY DEAD ENDS IN WATER PIPING. WATER HAMMER ARRESTORS AND VALVED WATER CONNECTIONS FOR FUTURE SHALL BE INSTALLED AS CLOSE AS POSSIBLE TO TEE CONNECTION. WATER HAMMER ARRESTORS SHALL BE INSTALLED ABOVE CEILING FOR ACCESS PURPOSES.

PLUMBING SPECIFICATIONS:

PART 1:

GENERAL

1. MATERIALS AND INSTALLATION SHALL COMPLY WITH ALL APPLICABLE STATE AND LOCAL CODES AND REQUIREMENTS.
2. OBTAIN AND PAY FOR ALL REQUIRED PERMITS, INSPECTION FEES, TAPPING FEES, CONNECTION CHARGES, AND UTILITY COMPANY SERVICE CHARGES.
3. INSTALLATION SHALL BE DONE IN A NEAT AND PROFESSIONAL MANNER. PART

PART 2:

PRODUCTS

1. ALL PIPING AND FITTINGS FOR THE DOMESTIC WATER SYSTEM SHALL BE CERTIFIED BY THE UNDERWRITERS LABORATORY TO MEET THE ANSI NSF 61 SECTION 9 STANDARD.
2. ALL DOMESTIC WATER PIPING INSIDE THE BUILDING ABOVE SLAB SHALL BE TYPE "L" HARD COPPER.
3. DOMESTIC WATER PIPING BELOW SLAB AND OUTSIDE SHALL BE TYPE "K" SOFT SEAMLESS. NO JOINTS SHALL BE ALLOWED BELOW SLAB.
4. COPPER PIPE FITTINGS SHALL BE SWEATED JOINT, WROUGHT COPPER, SWEEP PATTERN FITTINGS, SOLDERED USING 95-5 LEAD-FREE SOLDER.
5. ALL SANITARY WASTE AND VENT PIPING INSIDE AND UNDERSLAB TO 5'-0" OUTSIDE THE BUILDING SHALL BE SCHEDULE 40 PVC, DWV OR SERVICE WEIGHT CAST IRON WITH DRAINAGE FITTINGS. OUTSIDE PVC PIPING 5'-0" FROM BUILDING SHALL BE SDR-35 OR D-3034.
6. JOINT FOR PVC PIPING SHALL BE SOLVENT WELD TYPE INSIDE AND UNDERSLAB TO 5'-0" OUTSIDE THE BUILDING AND NEOPRENE PUSH-ON TYPE JOINTS OUTSIDE 5'-0" FROM THE BUILDING. JOINTS FOR CAST IRON PIPE SHALL BE NO-HUB TYPE ABOVE, SLAB ON GRADE, AS MANUFACTURED BY CLAMP-ALL OR ANKO HUSKY. CAST IRON SOIL PIPING INSTITUTE NO-HUB, DOUBLE BAND CONNECTORS SHALL NOT BE ALLOWED. JOINTS FOR CAST IRON PIPE BELOW SLAB OR GRADE SHALL BE NEOPRENE PUSH-ON TYPE.
7. HANGERS: PIPE SIZES 1/2" TO 1-1/2": ADJUSTABLE WROUGHT STEEL LOOP (COPPER, ELECTROPLATE IF APPLICABLE).
8. HANGERS: PIPE SIZES 2" AND UP: ADJUSTABLE WROUGHT STEEL CLEVIS (COPPER, ELECTROPLATE IF APPLICABLE).
9. MULTIPLE OR TRAPEZE HANGERS: STEEL CHANNELS WITH WELDED SPACERS AND HANGER RODS.
10. PROVIDE STEEL HANGER RODS, THREADED BOTH ENDS, THREADED ONE END, OR CONTINUOUS THREADED AS REQUIRED.
11. INSULATE DOMESTIC COLD WATER, HOT WATER WITH 1" THICK FIBERGLASS INSULATION WITH MOLDED FIBERGLASS VAPOR AS MANUFACTURED BY MANVILLE CORPORATION, OWENS-CORNING, KNAUF, OR CERTAINTED. INSULATE DOMESTIC HOT AND COLD WATER PIPING IN WALLS AND CHASSES BEHIND FIXTURES WITH 1/2" THICK FIBERGLASS INSULATION.
12. INSULATE ALL DOMESTIC WATER PIPING BELOW SLAB AND TO 5'-0" OUTSIDE THE BUILDING WITH 1/2" ARMAFLEX.
13. PIPE INSULATION AND COVERINGS SHALL HAVE A RATING OF NO GREATER THAN 25 FLAME SPREAD, NO HIGHER THAN 50 SMOKE DEVELOPED, AND NO MORE THAN 50 FUEL CONTRIBUTED.
14. CONCRETE ANCHORS (WEDGE ANCHORS) SHALL BE ZINC-PLATED CARBON STEEL WEDGE ANCHORS AVAILABLE IN ANCHOR/DRILL SIZES 1/4" TO 3/4" AND LENGTHS OF 1-3/4" THROUGH 12", MEETING U.S. GOVERNMENT C.S.A. SPECIFICATIONS FF-S-325 GROUP II, TYPE 4, CLASS 1, FOR FASTENING PLUMBING SYSTEMS TO CONCRETE AND PIPE HANGING. ITW RAMSET/RED HEAD BRAND OR APPROVED EQUAL.
15. ACCEPTABLE FIXTURE MANUFACTURERS
- A. NO OTHER MANUFACTURER SUBSTITUTIONS SHALL BE ALLOWED WITHOUT PRIOR WRITTEN APPROVAL FROM THE ENGINEER FIVE (5) DAYS BEFORE BIDDING.
- B. CONTRACTOR SHALL PROVIDE FAUCETS AND FITTINGS THAT ARE CERTIFIED BY UNDERWRITERS LABORATORY TO MEET THE ANSI NSF 61, SECTION 9 STANDARD.
- C. FIXTURES SHALL BE MOUNTED RIGID TO WALLS AND FLOOR.
- D. FIXTURES: ELJER, AMERICAN STANDARD OR KOHLER.
- E. FITTINGS: SYMMONS, CHICAGO FAUCET CO.
- F. FLUSH VALVES: SLOAN VALVE COMPANY, ZURN, OR DELANEY (IF MODIFIED TO BE NON-HOLD OPEN)
- G. STAINLESS STEEL SINKS: JUST OR ELKAY.
- H. SERVICE BASINS: STERN WILLIAMS, FIAT, OR CREATIVE INDUSTRIES.
- I. WATER HEATERS: LOCHINVAR, STATE, RUUD, OR A. O. SMITH.
- J. TOILET SEATS: CHURCH, OLSONITE, BENEKE OR BEMIS.
- K. DRAIN, HYDRANTS, CARRIERS AND SHOCK ABSORBERS: J. R. SMITH, ZURN, WADE, OR JOSAM.
- L. WATER HEATER PANS: SHAMROCK OR TREND MFG. OF AMERICA.
- M. REDUCED PRESSURE BACKFLOW PREVENTION: FEBCO, HERSEY, WATTS, OR WILKINS.

PART 3:

EXECUTION

1. EXCAVATION, BACKFILLING AND TRENCH WORK SHALL BE DONE IN ACCORDANCE WITH O.S.H.A. AND EXISTING SAFETY STANDARDS.
- A. PROVIDE SHORING AND CLEANING NECESSARY TO KEEP TRENCHES IN WORKING CONDITIONS, INCLUDING PUMPING OUT WATER.
- B. IN MOSTLY ROCK MATERIAL, TRENCHES SHALL BE EXCAVATED TO AT LEAST 6" BELOW THE ELEVATION OF THE BOTTOM OF THE PIPES. AFTER EXCAVATION, TRENCH SHALL THEN BE FILLED TO THE PROPER ELEVATION WITH CRUSHED LIMESTONE. GRAVEL SHALL BE SCOOPED OUT UNDER PIPE BELLS SO THE PIPE RESTS FIRMLY ON THE TRENCH BOTTOM.
- C. IN MOSTLY EARTH OR SAND MATERIAL, THE LAST 6" OF EXCAVATION SHALL BE DONE BY HAND. TRENCH BOTTOM SHALL BE SCOOPED OUT AT PIPE BELLS SO THE PIPE RESTS FIRMLY ON THE TRENCH BOTTOM.
- D. BACKFILLING AND TAMPING SHALL BE CAREFULLY DONE SIMULTANEOUSLY ALONG BOTH SIDES OF THE PIPE USING ROCK FREE EARTH, CRUSHED STONE OR SAND UNTIL THE PIPE IS COVERED TO A DEPTH OF AT LEAST 12". THE REST OF THE FILL UP TO THE TOPSOIL LAYER MAY BE GRAVEL OR ROCK FREE EARTH. ACCEPTABLE SOIL MATERIALS FOR BACKFILL AND FILL SHALL BE FREE OF CLAY, ROCK OR GRAVEL LARGER THAN 2" IN ANY DIMENSION. DEBRIS: WASTE, FROZEN MATERIALS AND OTHER DELETERIOUS MATTER HAVING A ELASTICITY INDEX LESS THAN 30. BACKFILL SHALL BE DONE IN LAYERS OF NOT MORE THAN 8" AND EACH LAYER SHALL BE COMPACTED. THE LAST 12" OF BACKFILL SHALL BE ROCK FREE TOPSOIL.
- E. SURFACE SHALL BE RESTORED TO ITS ORIGINAL CONDITION.
2. EXPOSED HOT AND COLD WATER TRIM IN FINISHED AREAS SHALL BE CHROME FINISHED.
3. ALL HORIZONTAL AND VERTICAL PIPING SHALL BE SUPPORTED IN ACCORDANCE WITH APPLICABLE STATE AND LOCAL CODE RECOMMENDATIONS. SUPPORTS SHALL SECURELY HOLD PIPING, PREVENT VIBRATION, COMPENSATE FOR ALL STATIC AND OPERATIONAL CONDITIONS OF THE VARIOUS SYSTEMS AND SHALL NOT BE SUBJECT TO ELECTROLYTIC ACTION. THIS SHALL BE ACCOMPLISHED BY USING THE SUMMER SYSTEM, THE POSIFIX, STAKFIX, PIPEFIX OR CHANNEL.
4. SHOCK ABSORBERS SHALL BE INSTALLED ON ALL HOT AND COLD WATER BRANCH LINES CONTAINING SINGLE LEVER FAUCETS, FLUSH VALVES OR QUICK CLOSING VALVES SUCH AS DISHWASHERS, CLOTHES WASHERS, AND THEIR EQUIPMENT, BETWEEN THE LAST TWO FIXTURES. THIS SHALL BE ACCOMPLISHED BY USING THE SUMMER SYSTEM, THE POSIFIX, STAKFIX, PIPEFIX OR CHANNEL.

5. SANITARY WASTE AND VENT, RAINWATER LEADERS, AND STORMWATER PIPING SHALL BE UNIFORMLY GRADED TO ELEVATIONS SHOWN. IF NO ELEVATIONS ARE GIVEN, SEWERS SHALL BE PITCHED NOT LESS THAN 1/4" PER FOOT FOR ALL PIPING 3" IN DIAMETER AND SMALLER AND 1/8" PER FOOT FOR PIPE LARGER THAN 3" IN DIAMETER.

6. SUPPORT HORIZONTAL PIPING AS FOLLOWS:

MAXIMUM NOMINAL PIPE SIZE (IN.)	MINIMUM DISTANCE BETWEEN SUPPORT (FT.)	HANGER ROD DIAMETER (IN.)
1/2	6	3/8
3/4 TO 1-1/2	6	3/8
2 TO 2-1/2	10	3/8
3 TO 4	12	1/2 TO 5/8
6	14	3/4

7. HANGERS FOR PIPING GREATER THAN 1" SHALL PASS OVER THE INSULATION. PROVIDE SADDLES FOR INSULATED PIPING.
8. HANGERS SHALL BE ATTACHED TO STRUCTURAL STEEL WORK BY CLAMPING OR OTHER APPROVED METHODS, EXCEPT THAT STRUCTURAL WORK SHALL NOT BE DRILLED AND PUNCHED.
9. INSULATION SHALL BE APPLIED WITH JOINTS TIGHTLY BUTTED. OPEN CRACKS, VOIDS AND DEPRESSIONS SHALL BE FILLED WITH HYDRAULIC SETTING CEMENT AND LAPPING MATCHING THE FINISH SHALL BE PASTED NEATLY OVER JOINTS.
10. FITTINGS AND VALVES SHALL BE INSULATED WITH THE SAME TYPE INSULATION AS THE PIPING OR WITH HYDRAULIC SETTING CEMENT. BUILT UP TO THE SAME THICKNESS AS LINES. COVER SHALL BE SAME AS ADJACENT PIPING OR PVC PREFORMED JACKET.
11. SEAL ALL PENETRATIONS OF RATED PARTITIONS WITH U.L. RATED FIRE BARRIER MATERIAL.
12. AIR ADMITTANCE VALVES SHALL NOT BE ALLOWED ON SANITARY WASTE AND VENT SYSTEMS.
13. THE SYSTEM TESTS DESCRIBED HEREIN ARE MINIMUM REQUIREMENTS. HOWEVER, ADDITIONAL TESTS AS REQUIRED BY THE AUTHORITY HAVING JURISDICTION SHALL ALSO BE PERFORMED.
14. DOMESTIC WATER PIPING SHALL BE TESTED AT 125 PSI. IN ADDITION, PIPING SHALL BE TESTED IN ACCORDANCE WITH APPLICABLE CODE REQUIREMENTS.
15. THE DOMESTIC WATER SYSTEM SHALL BE FLUSHED OUT PROGRESSIVELY BY OPENING OUTLETS AND FLOWING WATER UNTIL RUNS CLEAR. AFTER PIPE CLEANING IS COMPLETED, THE STRAINERS SHALL BE REMOVED, CLEANED, AND REPLACED. THEN THE ENTIRE DOMESTIC WATER SYSTEM SHALL BE DISINFECTED IN ACCORDANCE WITH THE AUTHORITY HAVING JURISDICTION.
16. THE SANITARY WASTE SYSTEMS SHALL BE FLUSHED OUT PROGRESSIVELY WITH FLOWING WATER UNTIL IT RUNS CLEAR.
17. THE ENTIRE SANITARY WASTE SYSTEMS SHALL BE TESTED AGAINST A HEAD PRESSURE OF 10' TSH, FOR A MINIMUM OF 8 HOURS WITHOUT LEAKAGE.

PLUMBING FIXTURE SCHEDULE							
SYMBOL	FIXTURE	DESCRIPTION	SOIL	WASTE	VENT	HW	CW
<u>W-1</u>	WATER CLOSET	BRADENTON SHBD225WH ELONGATED FLOOR MOUNTED TANK TYPE (1.28 GAL. FLUSH) WITH CENTOCO 1500STSCC OPEN FRONT WHITE SEAT WITH COVER, AND WATTS MODEL 890-003LK ANGLE SUPPLY STOP.	4"	-	2"	-	1"
<u>L-1</u>	LAVATORY	KOHLER #K-2031 'GREENWICH', SIGNATURE HARDWARE LEXIA SINGLE-HOLE LEVER FAUCET, MCGUIRE #155WC C.P. OFFSET GRID DRAIN W/ STRAINER & 17 GA. TAILPIECE, #8872 17 GA. C.P. BRASS "P" TRAP WITH WALL BEND, #H2165LK C.P. SUPPLY WITH LOOSE KEY STOP, CONCEALED ARM CHAIR CARRIER, AND TRUEBRO #103 INSULATION KIT.	-	2"	1-1/2"	1/2"	1/2"
<u>14</u>	OWNER FURNISHED SINK	OWNER FURNISHED EQUIPMENT WITH ALL ACCESSORIES. PROVIDE COMPLETE INSTALL PER MANUFACTURERS RECOMMENDATIONS. REFER TO ARCHITECTURAL PLANS. SINK SHALL HAVE NON-SCALDING DEVICES.	-	2"	1-1/2"	1/2"	1/2"
<u>20</u>	OWNER FURNISHED PRE-RINSE	OWNER FURNISHED EQUIPMENT WITH ALL ACCESSORIES. PROVIDE COMPLETE INSTALL PER MANUFACTURERS RECOMMENDATIONS. REFER TO ARCHITECTURAL PLANS.	-	2" IN-DIRECT	1-1/2"	1/2"	1/2"
<u>22</u>	OWNER FURNISHED DISHWASHER	OWNER FURNISHED EQUIPMENT WITH ALL ACCESSORIES. PROVIDE COMPLETE INSTALL PER MANUFACTURERS RECOMMENDATIONS.	-	2" IN-DIRECT	-	1"	-
<u>24</u>	OWNER FURNISHED 3-COMP	OWNER FURNISHED EQUIPMENT WITH ALL ACCESSORIES. PROVIDE COMPLETE INSTALL PER MANUFACTURERS RECOMMENDATIONS. REFER TO ARCHITECTURAL PLANS. THIS SINK IS FOR FOOD PREP.	-	(3) 2" IN-DIRECT	1-1/2"	1/2"	1/2"
<u>54</u>	OWNER FURNISHED SINK	OWNER FURNISHED EQUIPMENT. PROVIDE COMPLETE INSTALL PER MANUFACTURERS RECOMMENDATIONS. REFER TO ARCHITECTURAL PLANS. THIS SINK IS FOR FOOD PREP.	-	2"	1-1/2"	1/2"	1/2"
<u>61</u>	OWNER FURNISHED SINK	OWNER FURNISHED EQUIPMENT WITH ALL ACCESSORIES. PROVIDE COMPLETE INSTALL PER MANUFACTURERS RECOMMENDATIONS.	-	3"	2"	3/4"	3/4"
<u>86</u>	OWNER FURNISHED SINK	OWNER FURNISHED EQUIPMENT WITH ALL ACCESSORIES. PROVIDE COMPLETE INSTALL PER MANUFACTURERS RECOMMENDATIONS. REFER TO ARCHITECTURAL PLANS. SINK SHALL HAVE NON-SCALDING DEVICES.	-	2"	1-1/2"	1/2"	1/2"


1. WATER CLOSETS SHALL BE PROVIDED WITH A MAXIMUM FLUSHING RATE PER CODE IF MORE RESTRICTED THAN FIXTURE SPECIFIED.
2. PROVIDE SET SCREWS ON ALL ESCUTCHEONS.
3. PROVIDE 3 GPM MAX. FLOW CONTROLS ON ALL SINK FAUCETS AND .5 GPM MAX. FLOW CONTROLS ON ALL LAVATORY FAUCETS.
4. INSULATE ALL TRAPS, CW AND HW SUPPLIES ON HANDICAPPED LAVATORIES AND SINKS WITH TRUEBRO. INC., MODEL #102W & #105W. (UNLESS NOTED OTHERWISE.)
5. MOUNT ALL HANDICAPPED FIXTURES AT HEIGHT AS PER ADA REQUIREMENTS.
6. ALL FIXTURES ARE WHITE OR STAINLESS STEEL UNLESS NOTED OTHERWISE.
7. MOUNT ALL PUBLIC FLUSH VALVES AT A HEIGHT OF 42 INCHES, UNLESS OTHERWISE NOTED.
8. REFER TO ARCH. PLAN FOR EXACT LOCATION AND MOUNTING HEIGHT OF ALL FIXTURES.
9. PROPERLY ADJUST ALL AUTOMATIC FAUCETS TO PROVIDE WARM WATER.

MISC. PLUMBING SCHEDULE		
SYMBOL	FIXTURE	DESCRIPTION
<u>FCO</u>	FLOOR CLEANOUT	PVC CLEANOUT WITH SECURED DUCTILE IRON COVER
<u>WCO</u>	WALL CLEANOUT	PVC WALL CLEANOUT FOR DRY OR BLOCK WALL CONSTRUCTION, WITH ACCESS COVER SUITABLE FOR WALL FINISH.
<u>GCO</u>	GRADE CLEANOUT	PVC CLEANOUT WITH TRAFFIC-RATED COVER, SET IN CONCRETE PAD.
<u>FD-1</u>	FLOOR DRAIN	PVC FLOOR DRAIN WITH 6" STRAINER AND SEDIMENT BUCKET
<u>FS-1</u>	FLOOR SINK	PVC FLOOR SINK 12"x12"x6" WITH DOME STRAINER AND SEDIMENT BUCKET.
<u>HD-1</u>	HUB DRAIN	DEEP SEAL P-TRAP WITH 1/2" TRAP PRIMER CONNECTION, MODEL 7222-P050. 3" FIXED AIR GAP WITH 1-1/4" SET SCREW INLET AND 2" NO-HUB OUTLET, MODEL 3955S.
<u>IM</u>	ICE MAKER BOX	PLASTIC ICE MAKER BOX WITH SHUT-OFF VALVE AND BACKWATER VALVE
<u>TD-1</u>	TRENCH DRAIN	SECTIONAL PVC TRENCH DRAIN W/ INSIDE CAULK OUTLET, FLANGE, AND GRATE. PROVIDE W/ 3" OUTLET AND 12" EXTENSION.


NOTES:

1. PROVIDE CARPET MARKERS FOR ALL FLOOR CLEANOUTS IN CARPETED AREAS.
2. ALL FLOOR DRAINS SHALL BE PROVIDED WITH TRAP PRIMERS. TRAP PRIMERS SHALL BE LOCATED AT NEAREST LAVATORY OR SINK AND RUN ½" TYPE "K" COPPER BELOW SLAB TO FLOOR DRAINS. KITCHEN DRAINS AND SHOWERS ARE THE ONLY EXCEPTION.
3. ALL CLEANOUTS AND FLOOR DRAINS IN TILE FLOOR SHALL BE PROVIDED WITH SQUARE TOP.
4. ALL VENTS THRU ROOF SHALL BE PROVIDED WITH VANDAL PROOF VENT CAPS.
5. PROVIDE VANDAL PROOF SCREWS FOR ALL CLEANOUTS, FLOOR DRAINS.
6. ALL FLOOR SINKS AND HUB DRAINS SHALL BE INSTALLED WITH RIMS 1/2" TO 3/4" ABOVE FINISHED FLOOR AS PER #802.3.2 IPC.

PLUMBING LEGEND	
SYMBOL	DESCRIPTION
-----	SANITARY WASTE
-----	SANITARY VENT
-----	HOT WATER (HW)
-----	HOT WATER RETURN (HWR)
140"	140" HOT WATER (140')
-----	COLD WATER (CW)
-----	COLD WATER (CW) BELOW GRADE
-----	BALL VALVE
F.D.	FLOOR DRAIN
C.O.	CLEAN OUT
F.C.O.	FLOOR CLEANOUT
G.C.O.	GRADE CLEANOUT
W.C.O.	WALL CLEANOUT
V.T.R.	VENT THRU ROOF
WH	WALL HYDRANT
NFWH	NON-FREEZE WALL HYDRANT
DF-1	PLUMBING FIXTURE
R.P.B.P.	REDUCED PRESSURE BACKFLOW PREVENTER
OSCI	OWNER SUPPLIED, CONTRACTOR INSTALLED
●	NEW WORK POINT OF NEW TO EXISTING
◀	DEMOLITION POINT OF DISCONNECT

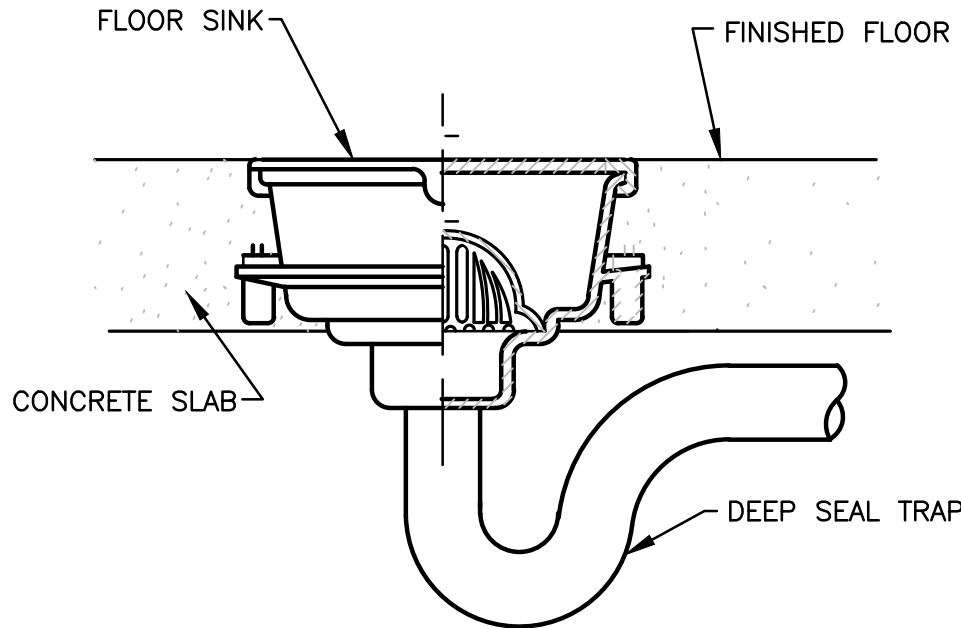

FLOOR SINK DETAIL

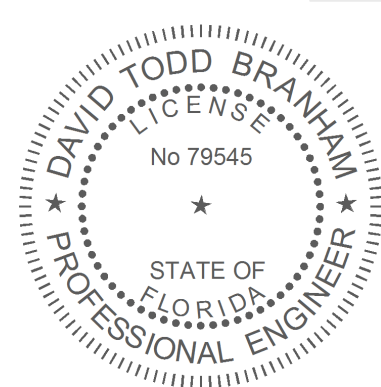

Biscuit Belly

15463 Panama City Beach Pkwy Ste B
Panama City Beach, FL 32413


DESIGN

insomnia


15 Sept 2026
MEP Permit

PLUMBING
SCHEDULES

P2.1

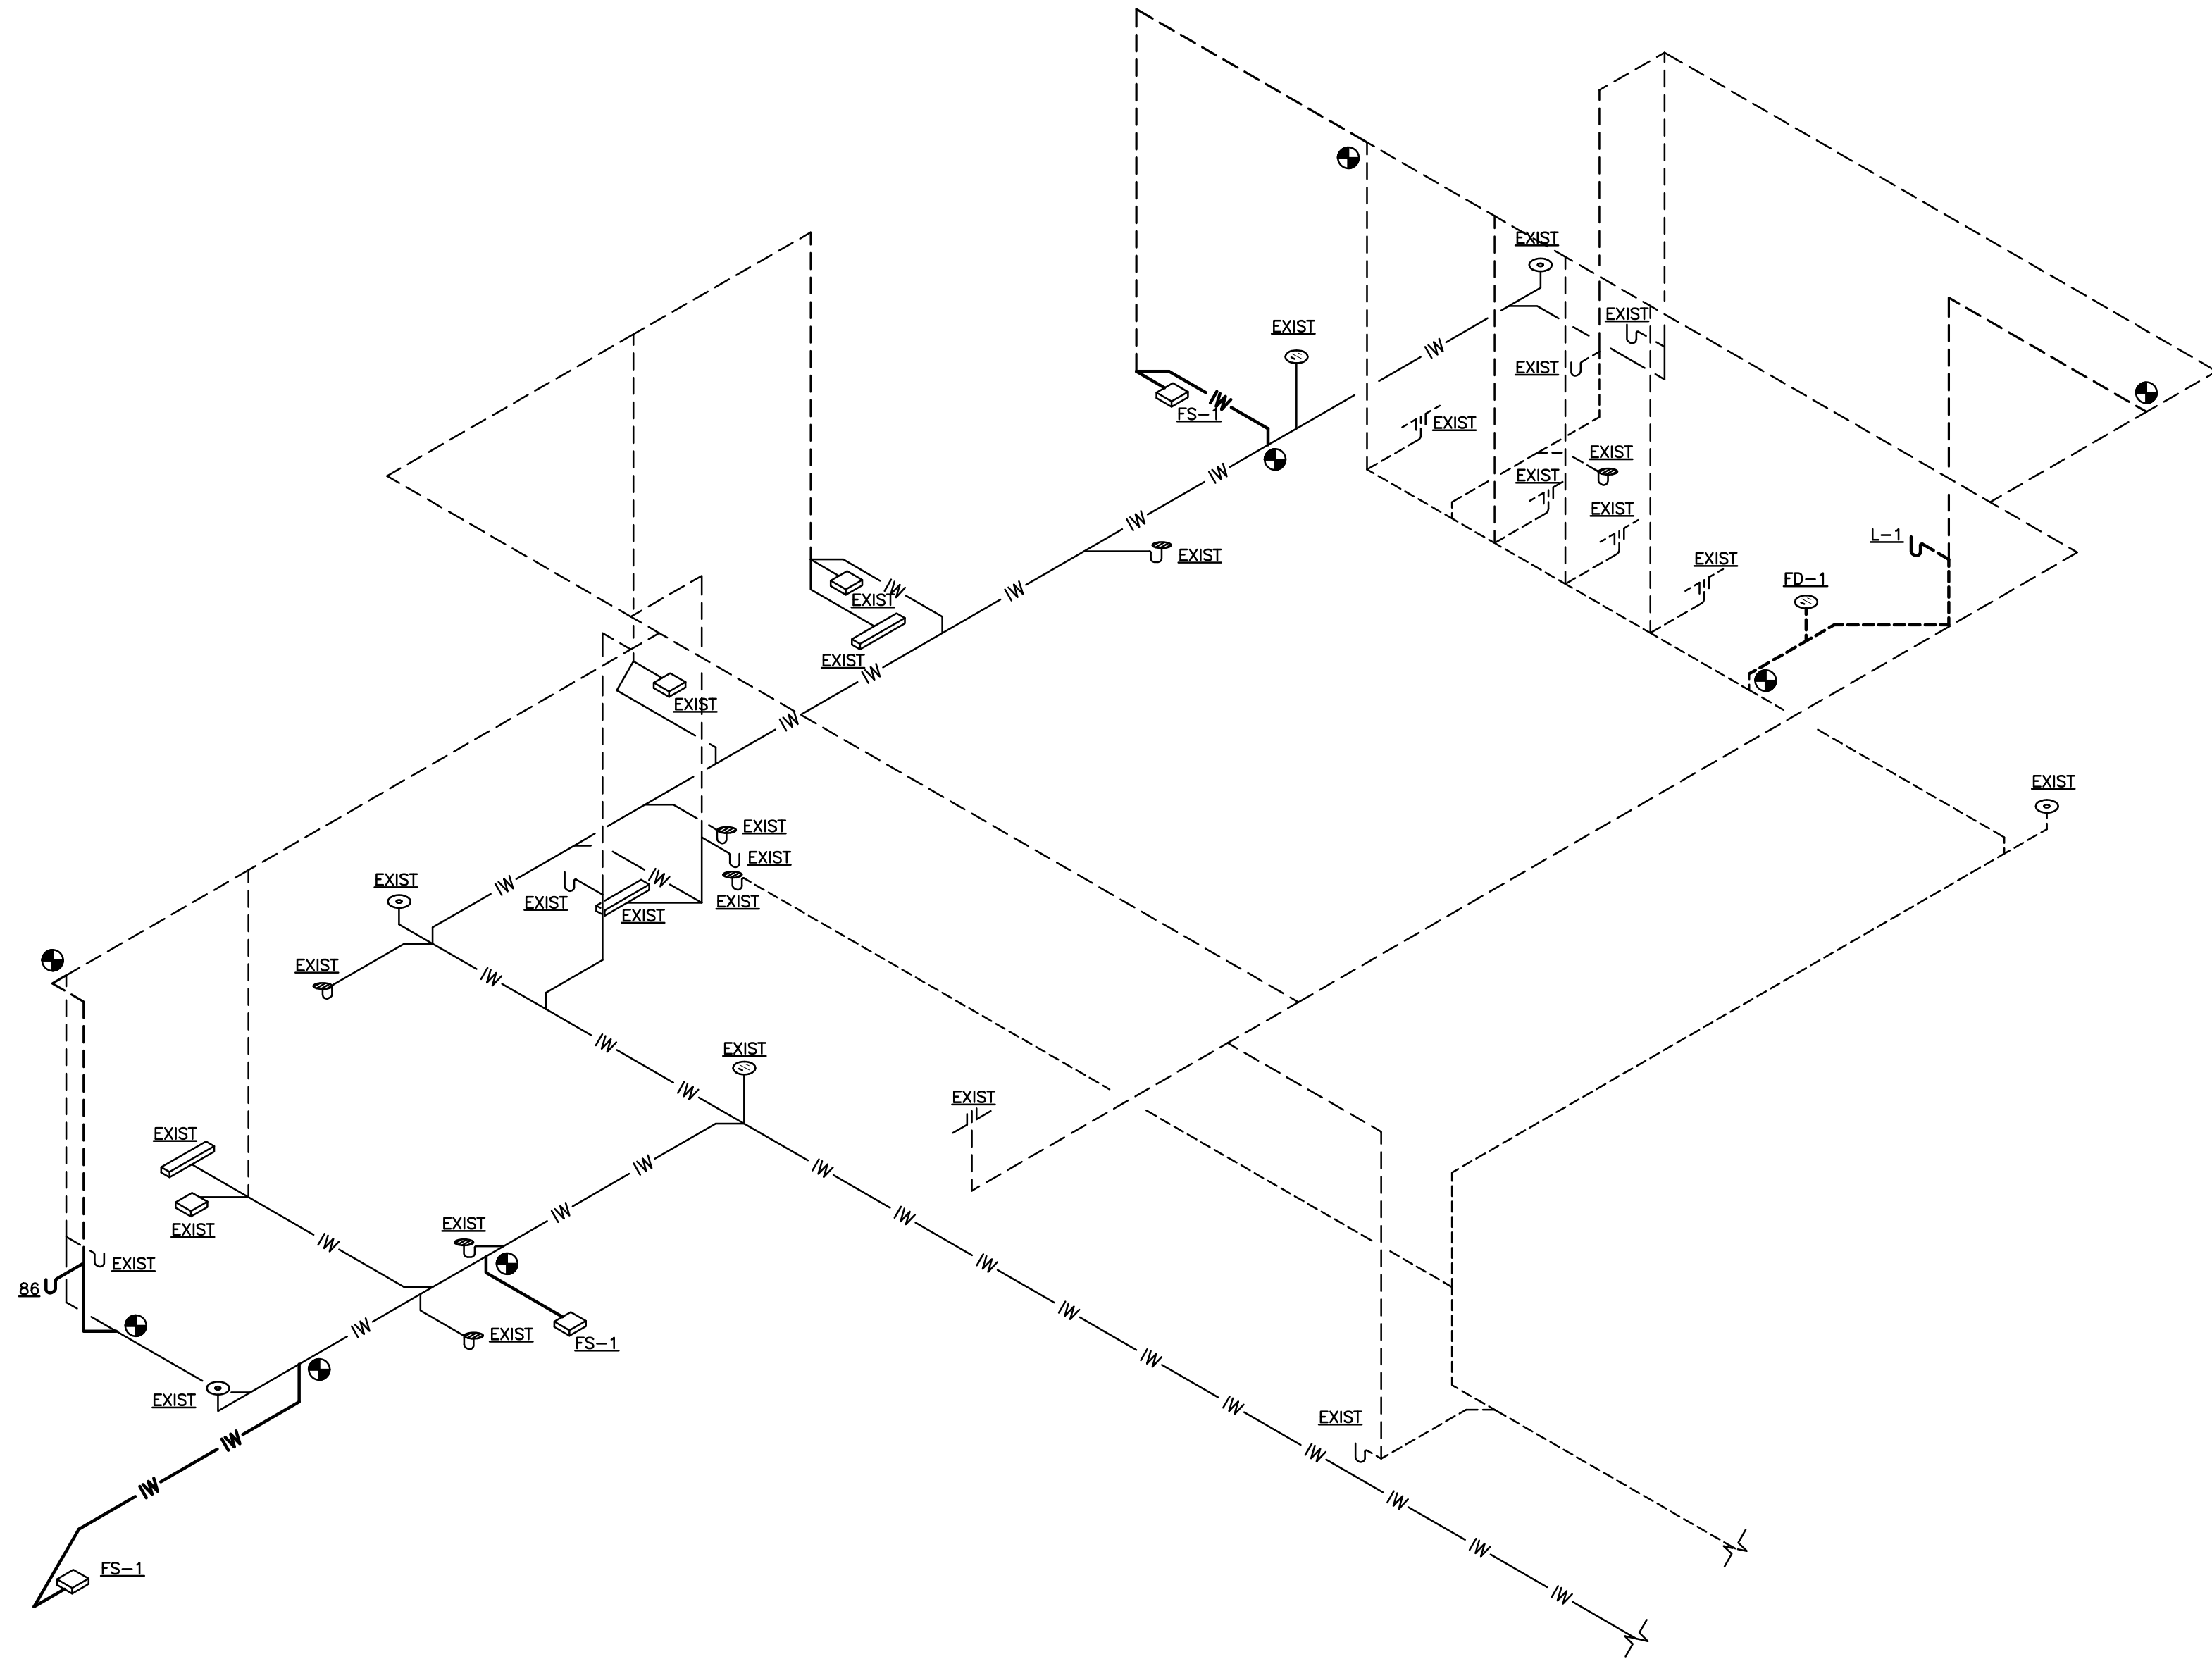

SANITARY RISER

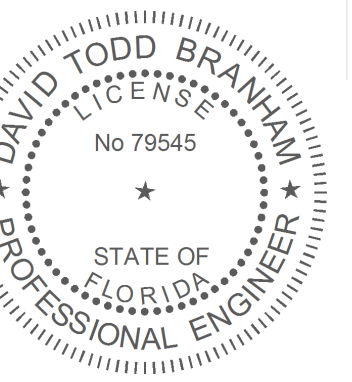



Biscuit Belly
15463 Panama City Beach Pkwy Ste B
Panama City Beach, FL 32413

insomnia DESIGN

15 Sept 2026
MEP Permit


PLUMBING
SPECIFICATIONS



P3.1

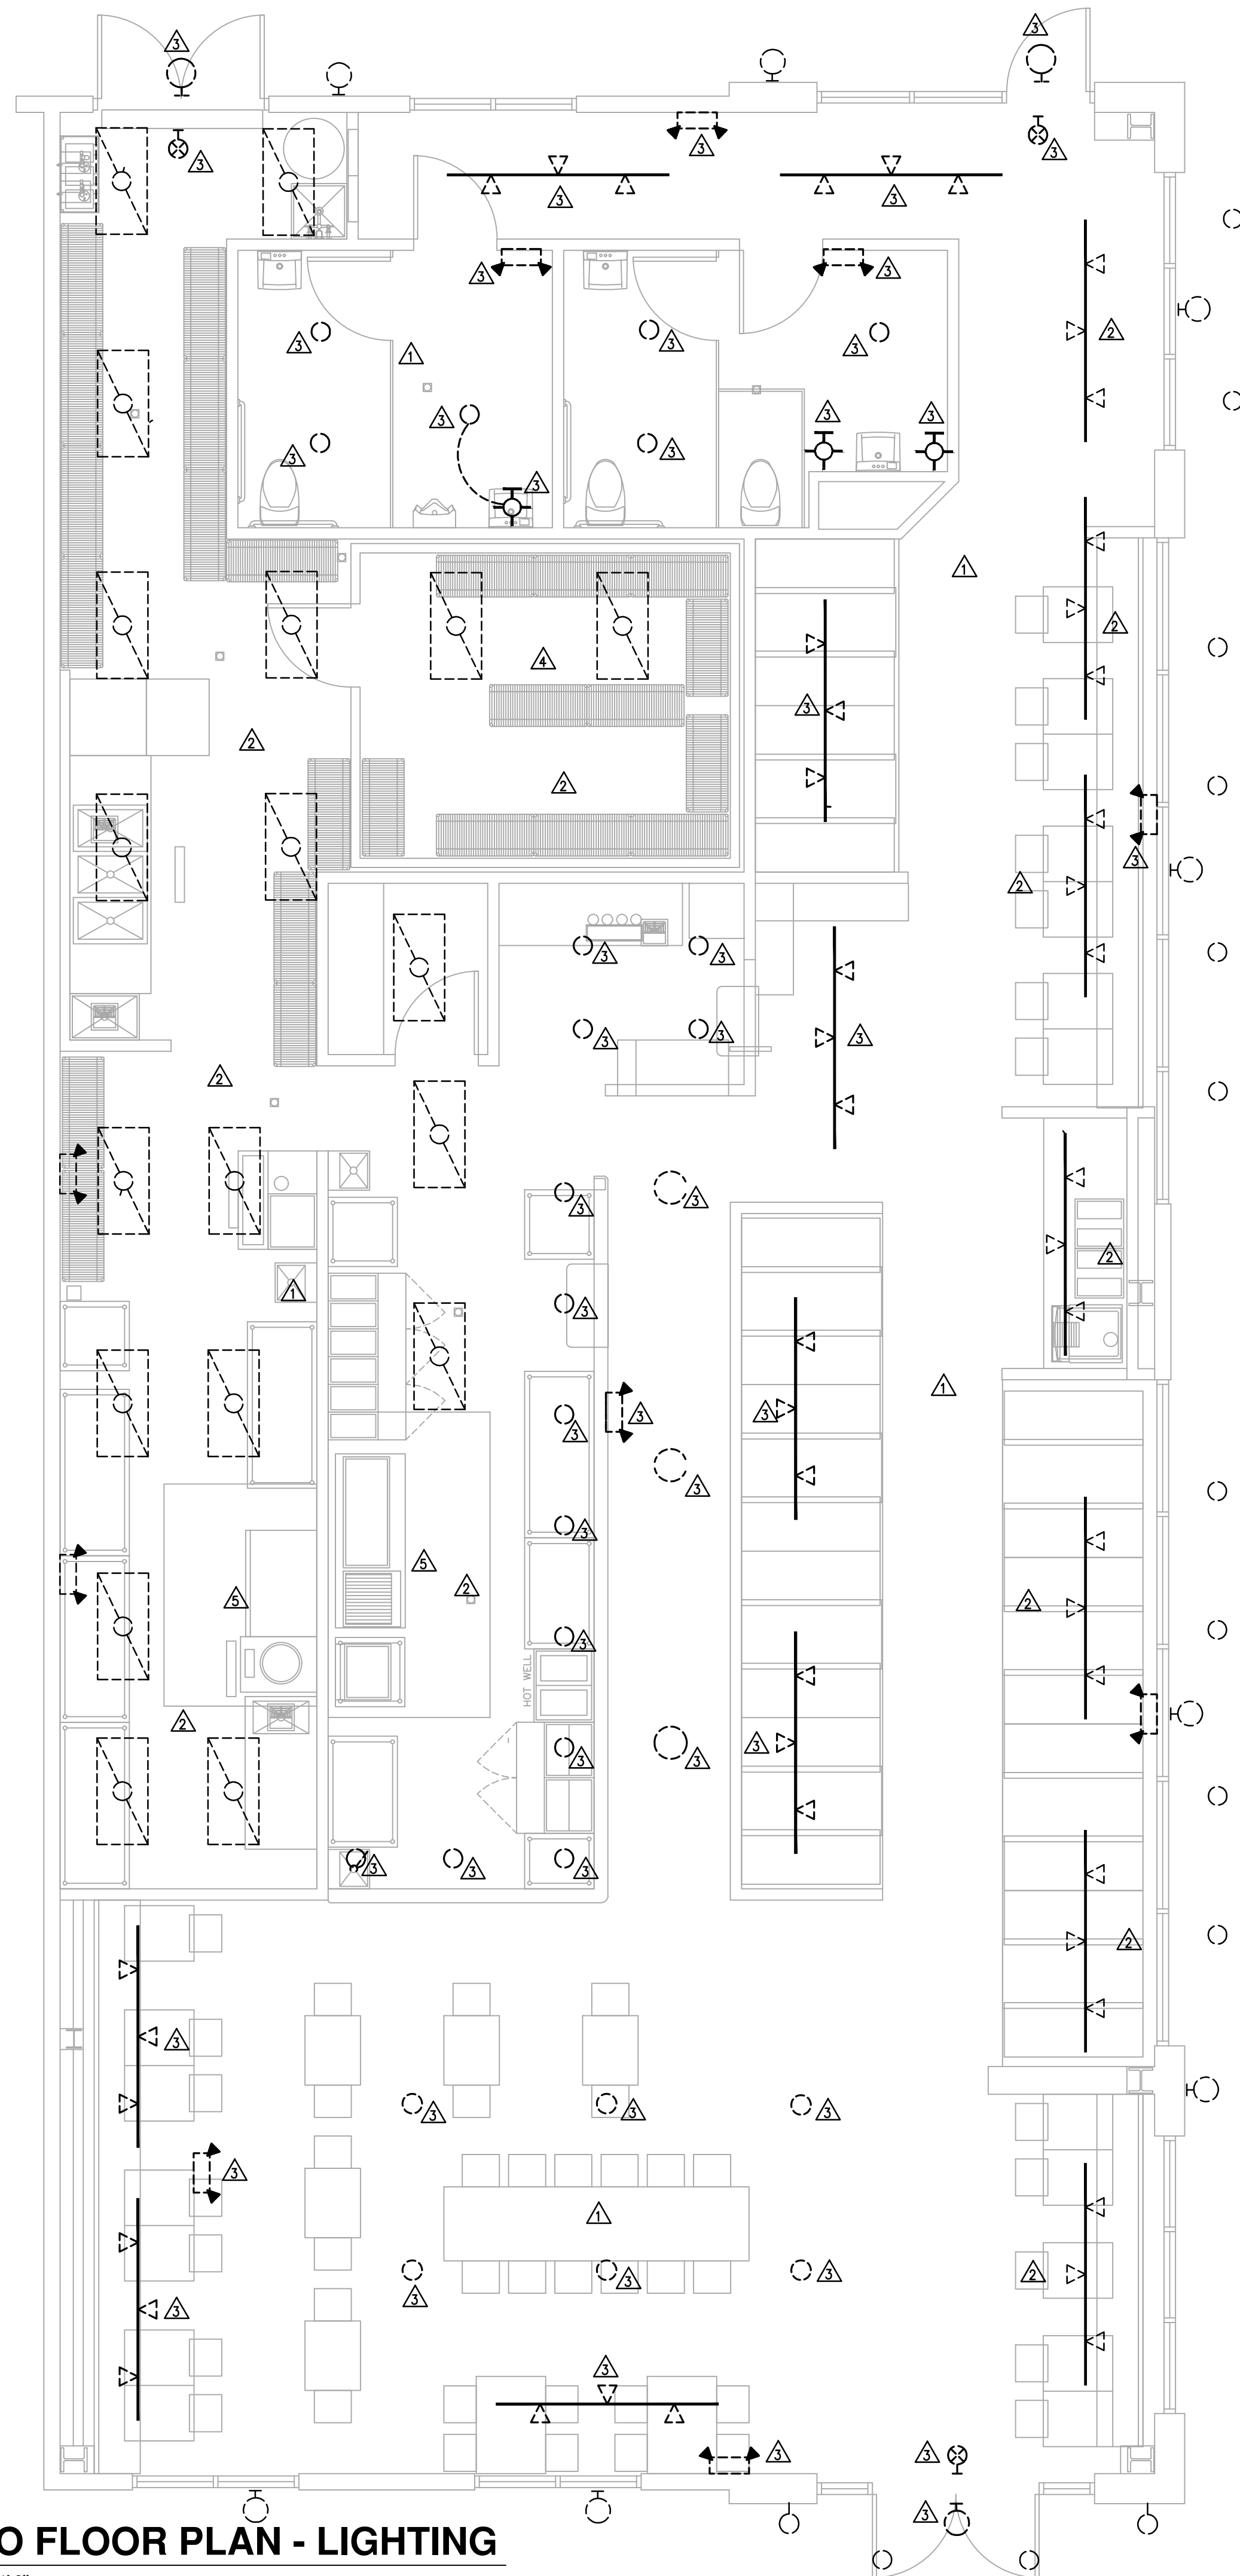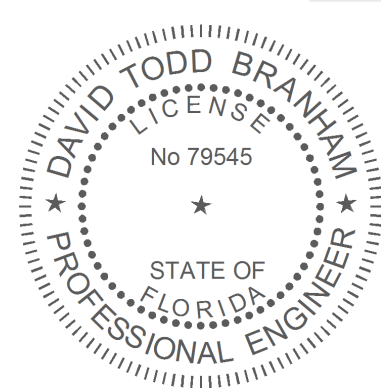

DEMOLITION NOTES:

- △ CONTRACTOR SHALL FIELD VERIFY EXISTING CONDITIONS.
- △ EXISTING LIGHT FIXTURES AND CONTROLS SHALL REMAIN IN USE UNLESS OTHERWISE NOTED. FIELD VERIFY EXISTING CIRCUITS.
- △ REMOVE EXISTING LIGHT FIXTURE.
- △ LIGHTING FOR COOLER SHALL BE EXISTING TO REMAIN.
- △ LIGHTING FOR HOODS SHALL BE EXISTING TO REMAIN.
- △ EXISTING POWER SHALL REMAIN IN USE UNLESS OTHERWISE NOTED. VERIFY EXISTING CIRCUIT.
- △ REMOVE EXISTING RECEPTACLE / JUNCTION BOX. TERMINATE CIRCUIT AS REQUIRED. COORDINATE WITH GENERAL CONTRACTOR.

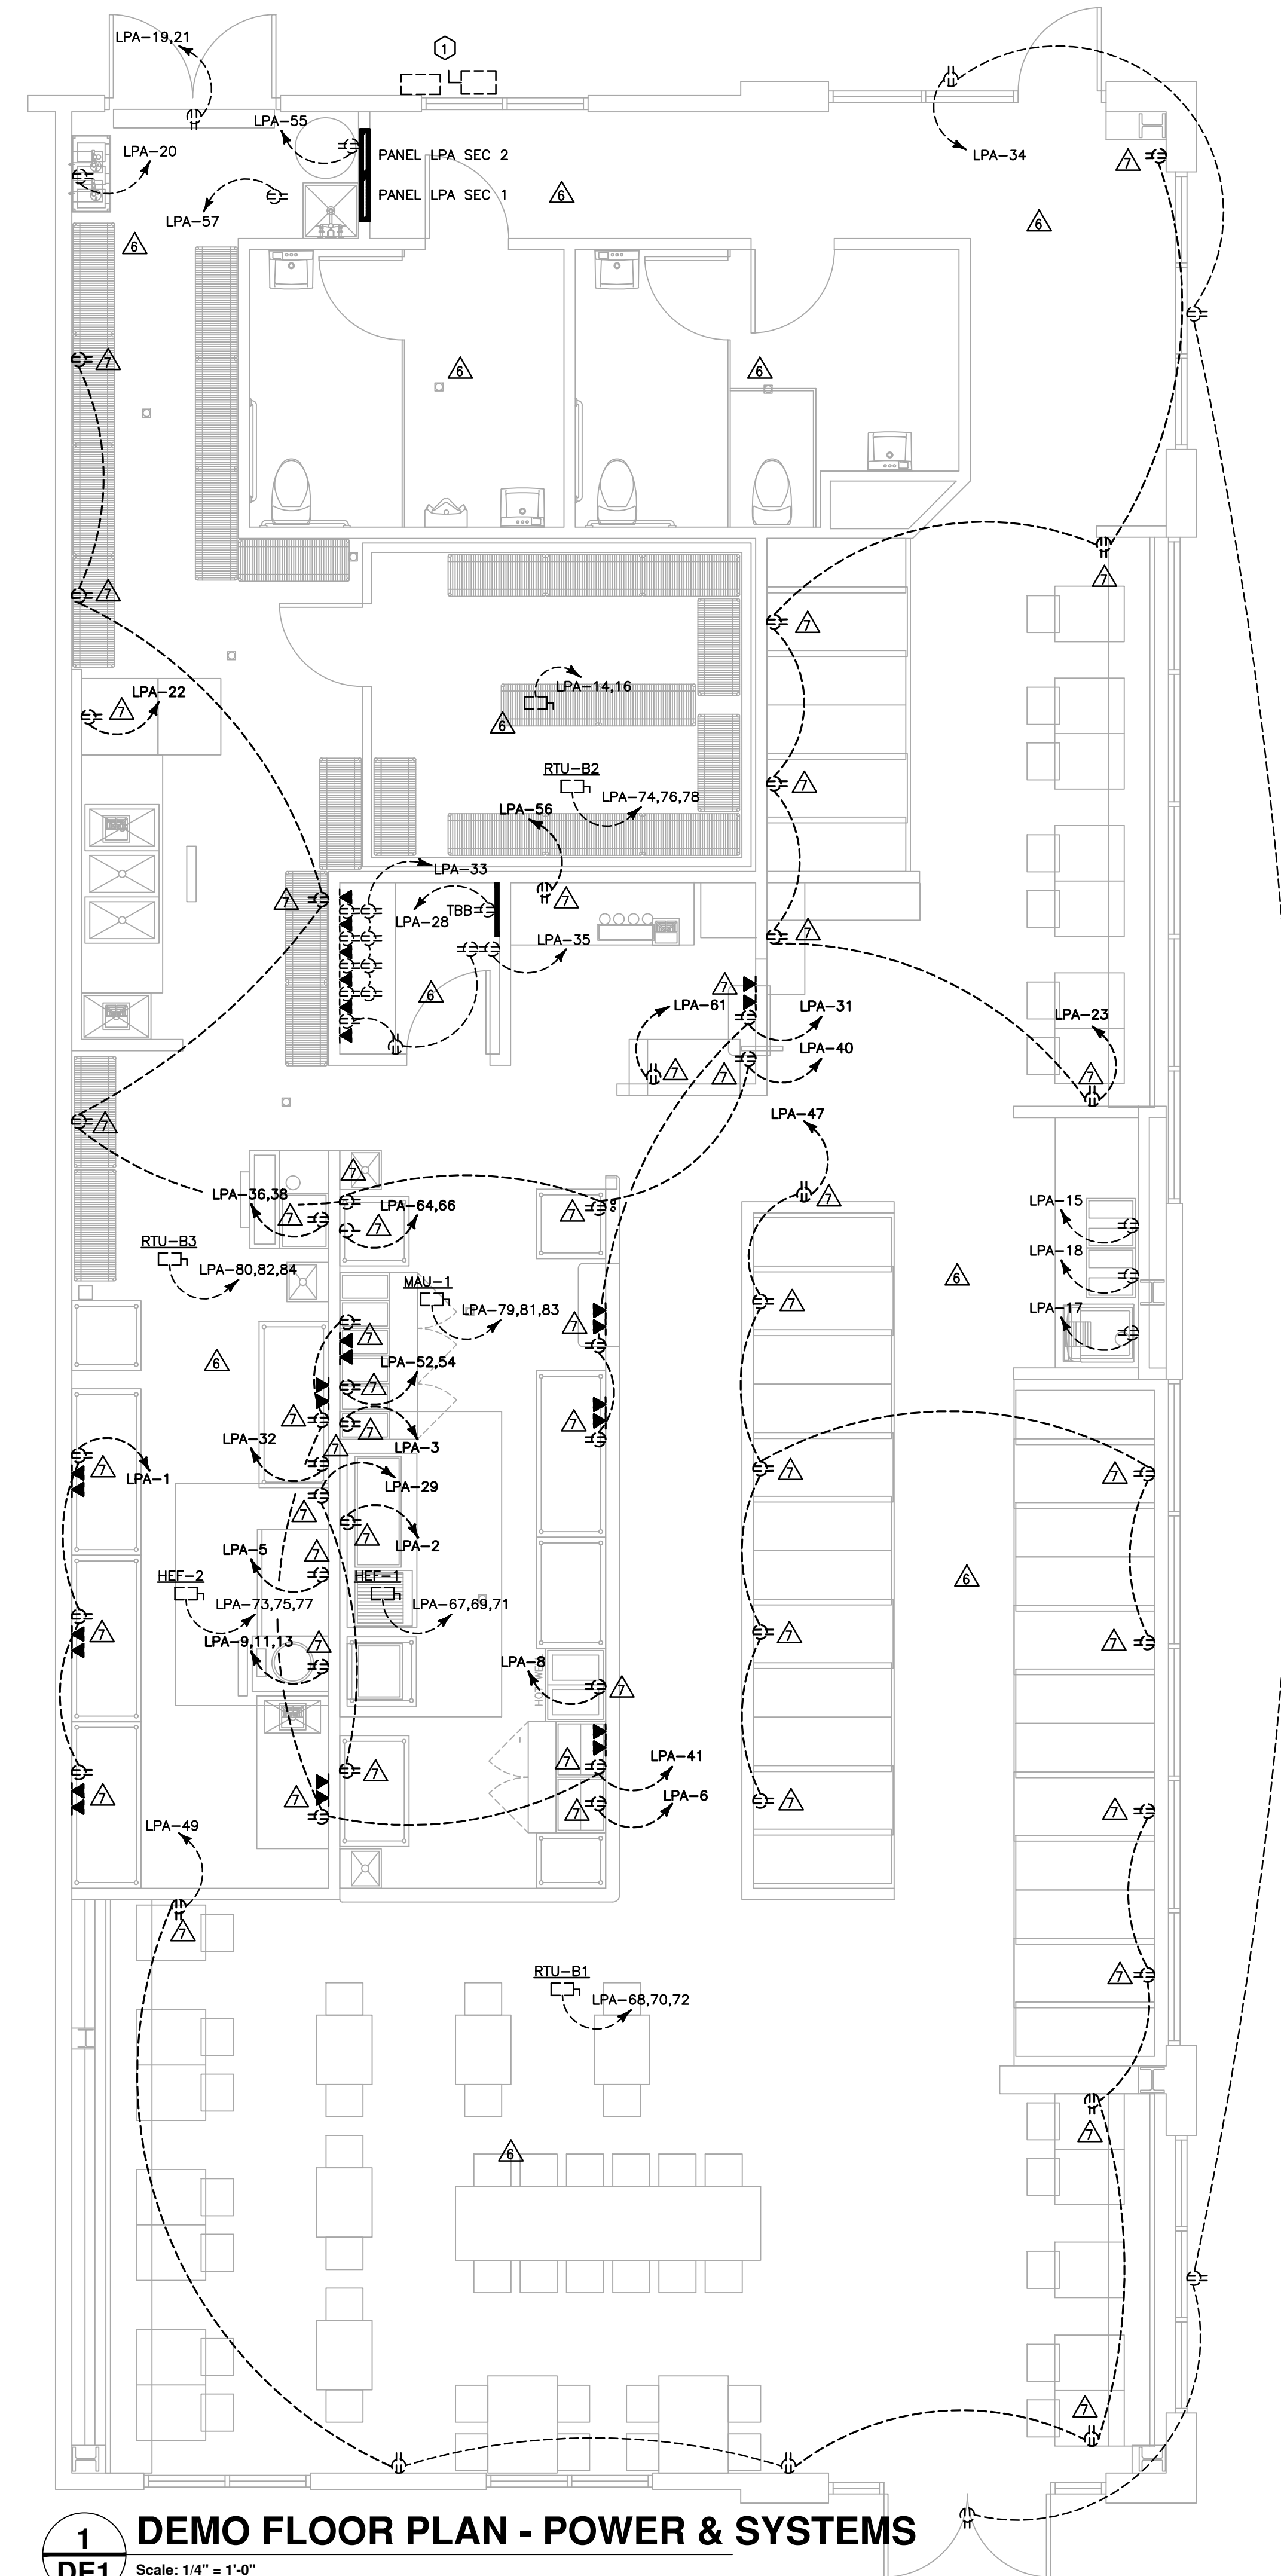

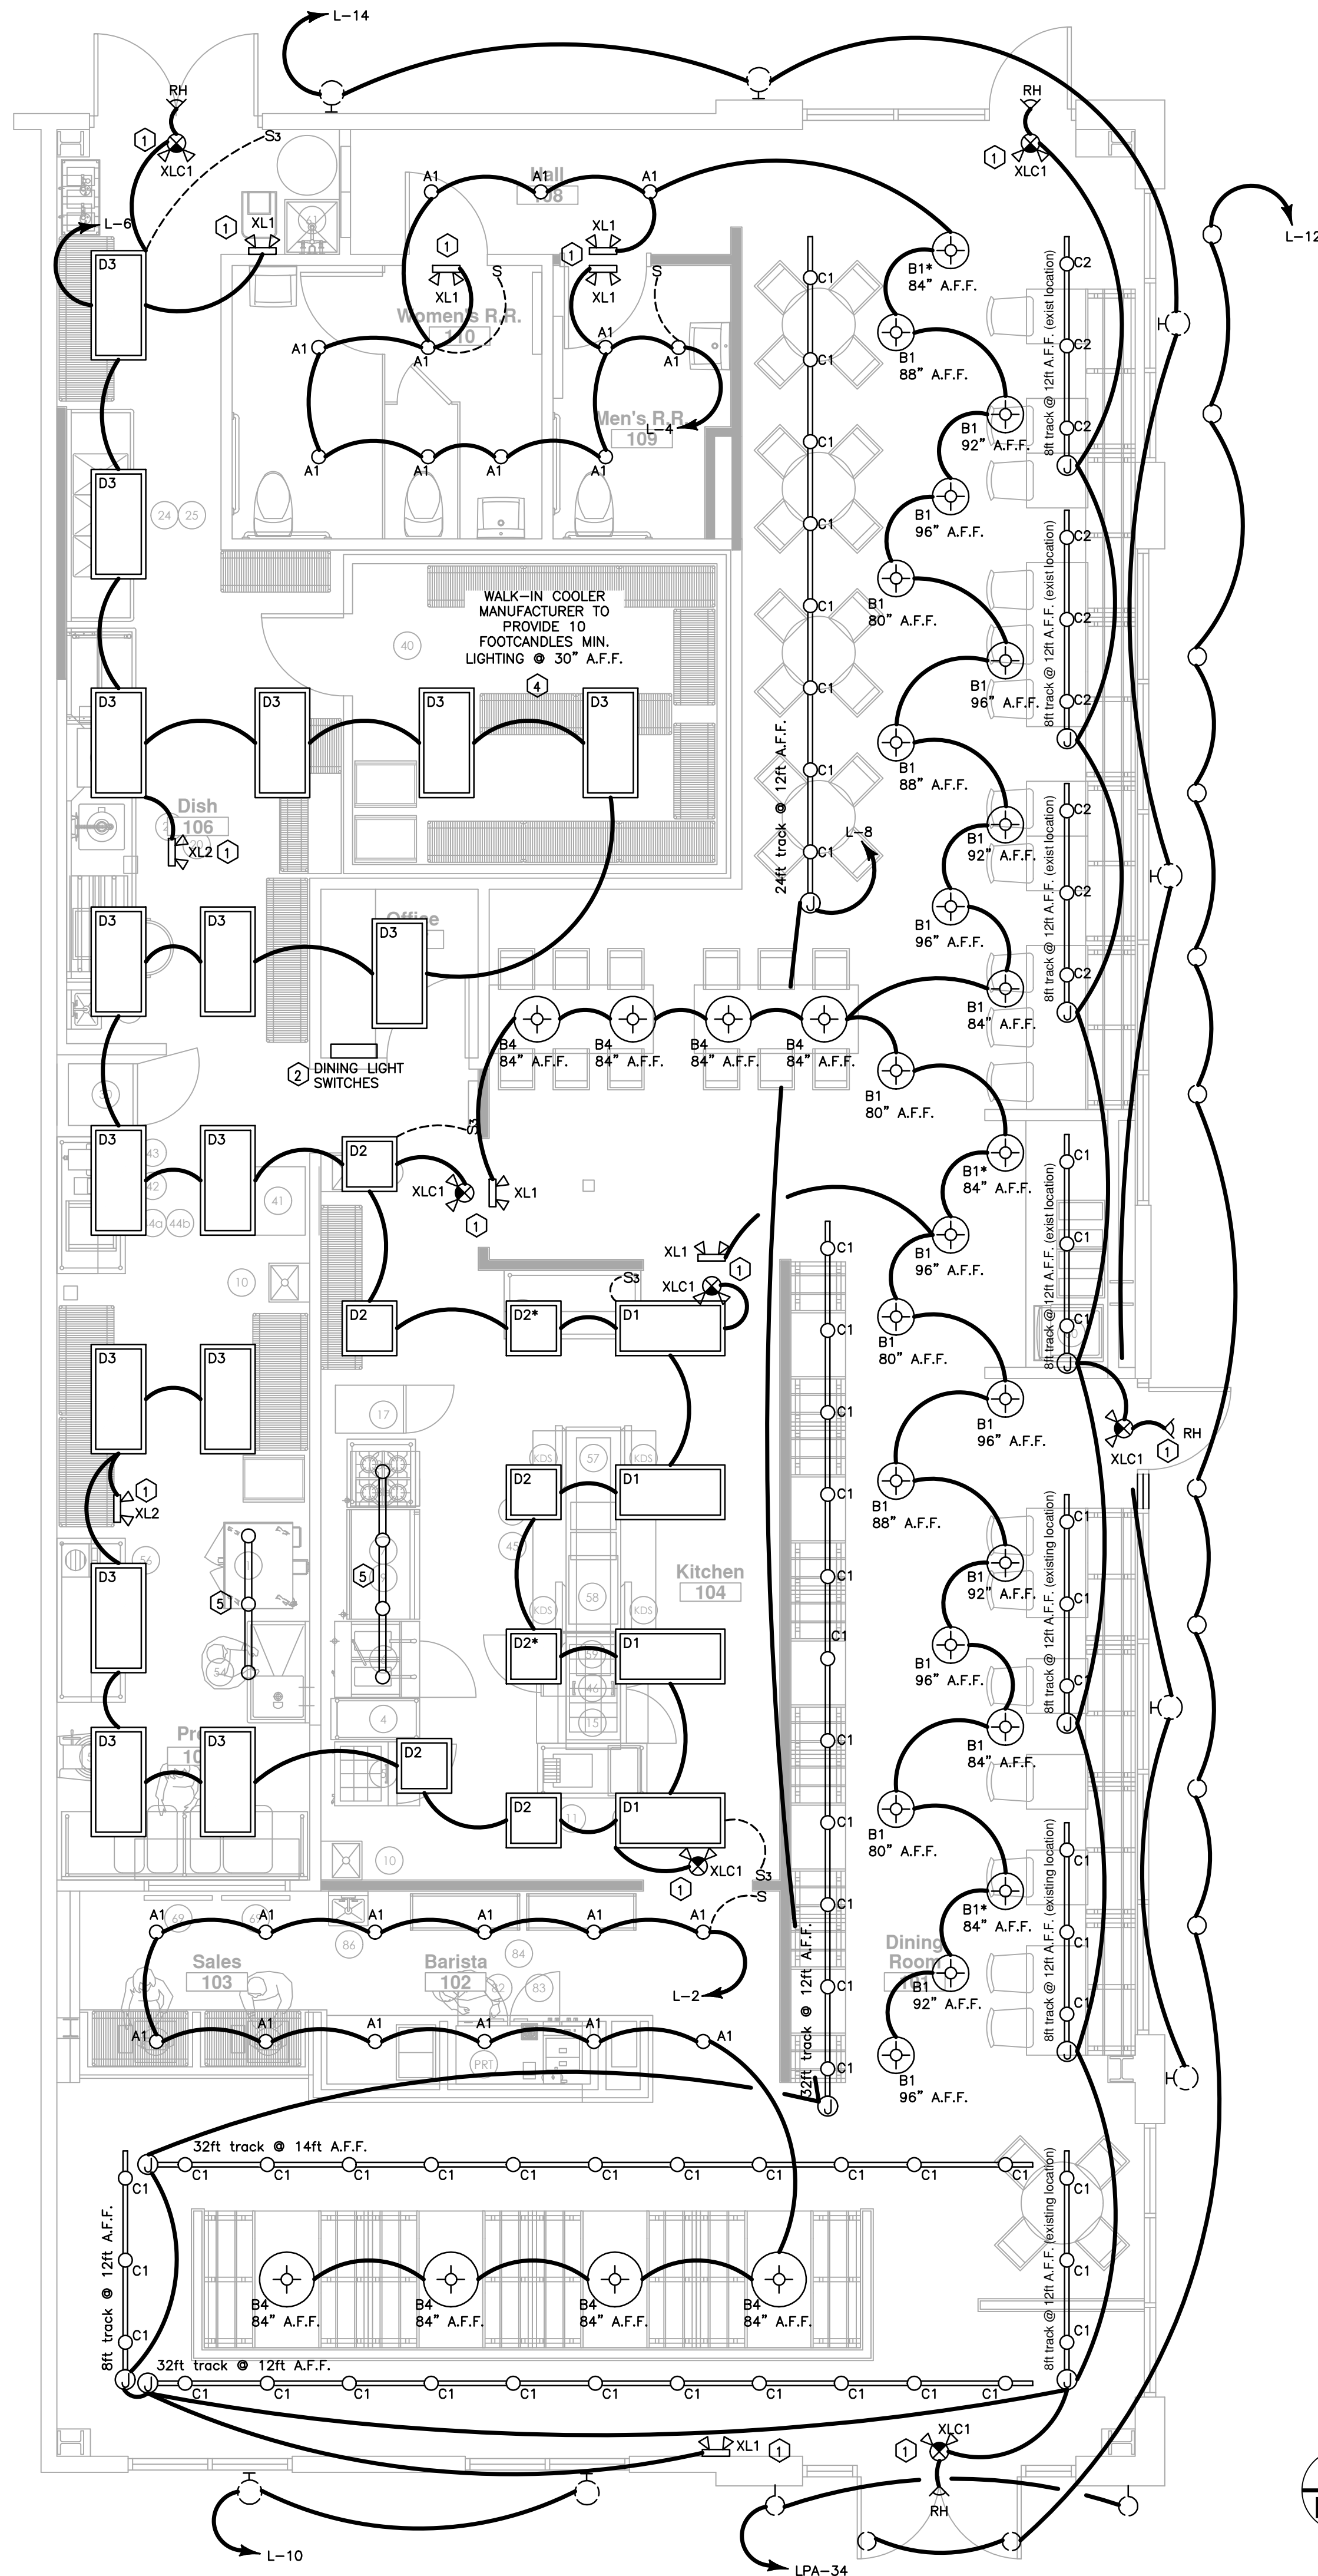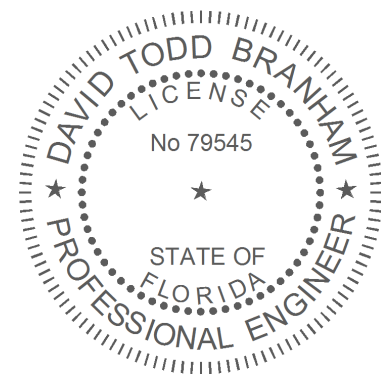

LIGHTING NOTES:



- 1 ALL EMERGENCY FIXTURES SHALL BE UNSWITCHED.
- 2 PROVIDE DIMMER SWITCHES IN OFFICE FOR DINING ROOM LIGHTS AS FOLLOWS:
- ALL C1 TRACK LIGHTING
 - ALL C2 TRACK LIGHTING
 - ALL B1 PENDANTS
 - ALL B4 PENDANTS

GENERAL ELECTRICAL NOTES:

1. THESE DRAWINGS ARE DIAGRAMMATIC AND SHOW GENERAL ELECTRICAL LAYOUTS FOR BIDDING PURPOSES ONLY. IT IS THE RESPONSIBILITY OF THE CONTRACTOR TO PREPARE DETAILED SHOP DRAWINGS AND TO CONFIRM SPACE ALLOCATIONS.
2. CONTRACTOR SHALL COORDINATE INSTALLATION FOR ALL EQUIPMENT PROVIDED BY OTHERS. USE LATEST EDITION OF VENDOR DRAWINGS FOR MODEL NUMBERS AND REQUIREMENTS FOR A COMPLETE OPERABLE SYSTEM. CONTRACTOR SHALL ASSUME ALL RESPONSIBILITY FOR A COMPLETE OPERABLE SYSTEM.
3. SEE ARCHITECTURAL AND STRUCTURAL DRAWINGS FOR ALL BUILDING DIMENSIONS, DETAILS, ELEVATIONS AND EXACT LOCATIONS OF FIXTURES.
4. CONTRACTOR SHALL VERIFY VOLTAGES AVAILABLE PRIOR TO ROUGHING IN.
5. MOUNTING HEIGHTS AS INDICATED ON DRAWINGS SHALL BE FROM THE FINISHED FLOR TO THE CENTER LINE OF THE OUTLET BOX.
6. PANELBOARD AND SAFETY DISCONNECTS SHALL BE EASILY ACESIBLE AND MAINTAIN ALL SERVICE CLEARANCE PER NEC.
7. THE ELECTRICAL DRAWINGS ARE ONLY A PART OF THE CONTRACT DOCUMENTS. ALL OF THE DRAWINGS AND SPECIFICATIONS MUST BE REVIEWED FOR THEIR INTER-RELATIONSHIP AND REQUIRED COORDINATION BETWEEN TRADES.
8. ALL WORK SHALL CONFORM TO APPLICABLE NEC, LOCAL BUILDING CODES, AND STATE HEALTH REGULATIONS HAVING JURISDICTION, AND STATE AMENDMENTS TO BUILDING CODE.
9. IN AREAS WHERE ELECTRICAL OUTLETS ARE LOCATED BENEATH A WINDOW AND THE WINDOW PREVENTS ROUTING OF CONDUIT UP THE WALL; CONDUIT SHALL BE ROUTED TO A WALL WHICH ALLOWS CONDUIT TO RISE UP TO CEILING SPACE.
10. ALL CONDUIT ROUTED FROM PANELBOARD TO DISCONNECTS AT EXTERIOR HVAC UNITS OR ANY OTHER EQUIPMENT SHALL BE ROUTED BELOW GRADE. TRANSITION FROM GRADE TO EQUIPMENT TO MAKE A SEALTIGHT CONNECTION.
11. ALL FLUSH RECESSED OUTLET BOXES SHALL BE INSTALLED SUCH THAT FRONT EDGE OF BOX WILL NOT BE SET BACK OF THE FINISHED SURFACE MORE THAN 1/4" IN ORDER TO COMPLY WITH N.E.C. 314-20. SUPPORT OF OUTLET BOX BY RECEPTACLE AND COVERPLATE IS NOT ACCEPTABLE.
12. ALL CONDUIT, OUTLET BOXES, AND LOW VOLTAGE CABLING SHALL BE APPROPRIATELY SUPPORTED THROUGHOUT THE PROJECT. SUPPORT OF THESE ITEMS BY CEILING GRID OR GRID SUPPORT WIRES IS NOT ACCEPTABLE.
13. ALL RECEPTACLES LOCATED WITHIN 6'-0" TO THE EDGE SINK OR OTHER WATER SOURCE SHALL BE GFCI TYPE DEVICE IN ACCORDANCE WITH N.E.C. 210-8A.7. COORDINATE LOCATIONS WITH ARCHITECTURAL AND PLUMBING DRAWINGS PRIOR TO ROUGH-IN.
14. COORDINATE EXACT LOCATION OF ALL MECHANICAL AND PLUMBING EQUIPMENT WITH DIVISION 23 PRIOR TO ROUGH IN. ADJUST LOCATION OF DISCONNECTING MEANS AND BRANCH CIRCUITRY AS REQUIRED.
15. PRIOR TO PROJECT COMPLETION, ELECTRICAL CONTRACTOR SHALL OBTAIN FINAL SPACE NUMBERS FROM OWNER AND/OR ARCHITECT. TYPEWRITTEN PANELBOARD DIRECTORIES SHALL REFLECT SPACE DESIGNATION OF EACH CIRCUIT. NO EXCEPTIONS.
16. ALL THHN / THWN WIRE SHALL HAVE A FACTORY INSTALLED COLOR CODED OUTER JACKET. CONTRACTOR IS TO NOTE THAT ALL FEEDER CONDUCTORS SHALL HAVE FULL COLOR CODED OUTER JACKET INTEGRAL TO THE CONDUCTOR INSULATION. USE OF COLOR PHASING TAPE IS NOT ALLOWED.
17. ALL RECEPTACLES AND SWITCHES SHALL BE SIDEWIRED. CONTRACTOR MY ELECT TO USE FACTORY TERMINATED MALE / FEMALE QUICK CONNECTS. (P&S "PLUGTAIL" OR EQUAL).
18. ALL LOW VOLTAGE SYSTEMS WHICH HAVE UNDERGROUND CONDUIT / CONDUCTORS ROUTED OUTSIDE OF THE BUILDING FOOTPRINT SHALL HAVE LIGHTNING PROTECTION SURGE MODULES LOCATED AT EACH END OF LOW VOLTAGE CABLING.
19. ALL WIRING DEVICE COVERPLATES SHALL BE HAND LABELED ON BACK OF COVERPLATE. LABELING SHALL BE PERMANENT MARKER, LEGIBLE, AND NOTE PANEL/CIRCUIT NUMBER SERVING DEVICE.
20. ALL EMPTY CONDUITS SHALL HAVE PULLSTRINGS INSTALLED. CAP OFF ALL STUB UP CONDUIT, INSTALL LABEL NOTING LOCATION OF CONDUIT STUB OUT.
21. ALL LOW VOLTAGE CONDUCTORS NOT IN CONDUIT SHALL BE PLENUM RATED. ALL TY-WRAPPS SUPPORTING SUCH SHALL BE PLENUM RATED. PROVIDE J-HOOKS AND SUPPORT MEANS AS REQUIRED.
22. ELECTRICAL CONTRACTOR SHALL REVIEW ARCHITECTURAL, STRUCTURAL, PLUMBING, SPRINKLER AND MECHANICAL DRAWINGS AND COORDINATE HIS WORK WITH ALL OTHER TRADES FOR POWER REQUIREMENTS AND EQUIPMENT PLACEMENT. AVOID INTERFERENCE WITH ARCHITECTURAL FEATURES, BEAMS, FOOTINGS, WINDOWS, ETC. NOTIFY ARCHITECT OF ANY CONFLICTS.
23. SLEEVES SHALL BE INSTALLED WHERE PIPING PASSES THROUGH STRUCTURE.
24. ALL OPENINGS THROUGH RATED WALLS SHALL BE SEALED WITH AN APPROVED FIREPROOFING TO MAINTAIN THE INTEGRITY OF THE WALL.
25. PROVIDE MANUFACTURED COMPATIBLE PIPE HANGERS, RODS AND INSERTS, OR CLAMPS FOR THE PROPER SUPPORT OF ALL CONDUIT. NO BAND IRON, TIE WIRE, METAL STRAPPING OR WIRE STRAPPING WILL BE PERMITTED.
26. UPON COMPLETION OF THE WORK COVERED BY THIS CONTRACT, FURNISH THE OWNER WITH ONE (1) SET OF REPRODUCIBLE RECORD DOCUMENTS WHICH SHOW ALL ELECTRICAL INSTALLED UNDER THIS CONTRACT.

1 FLOOR PLAN - LIGHTING

E1.1 Scale: 1/4" = 1'-0"

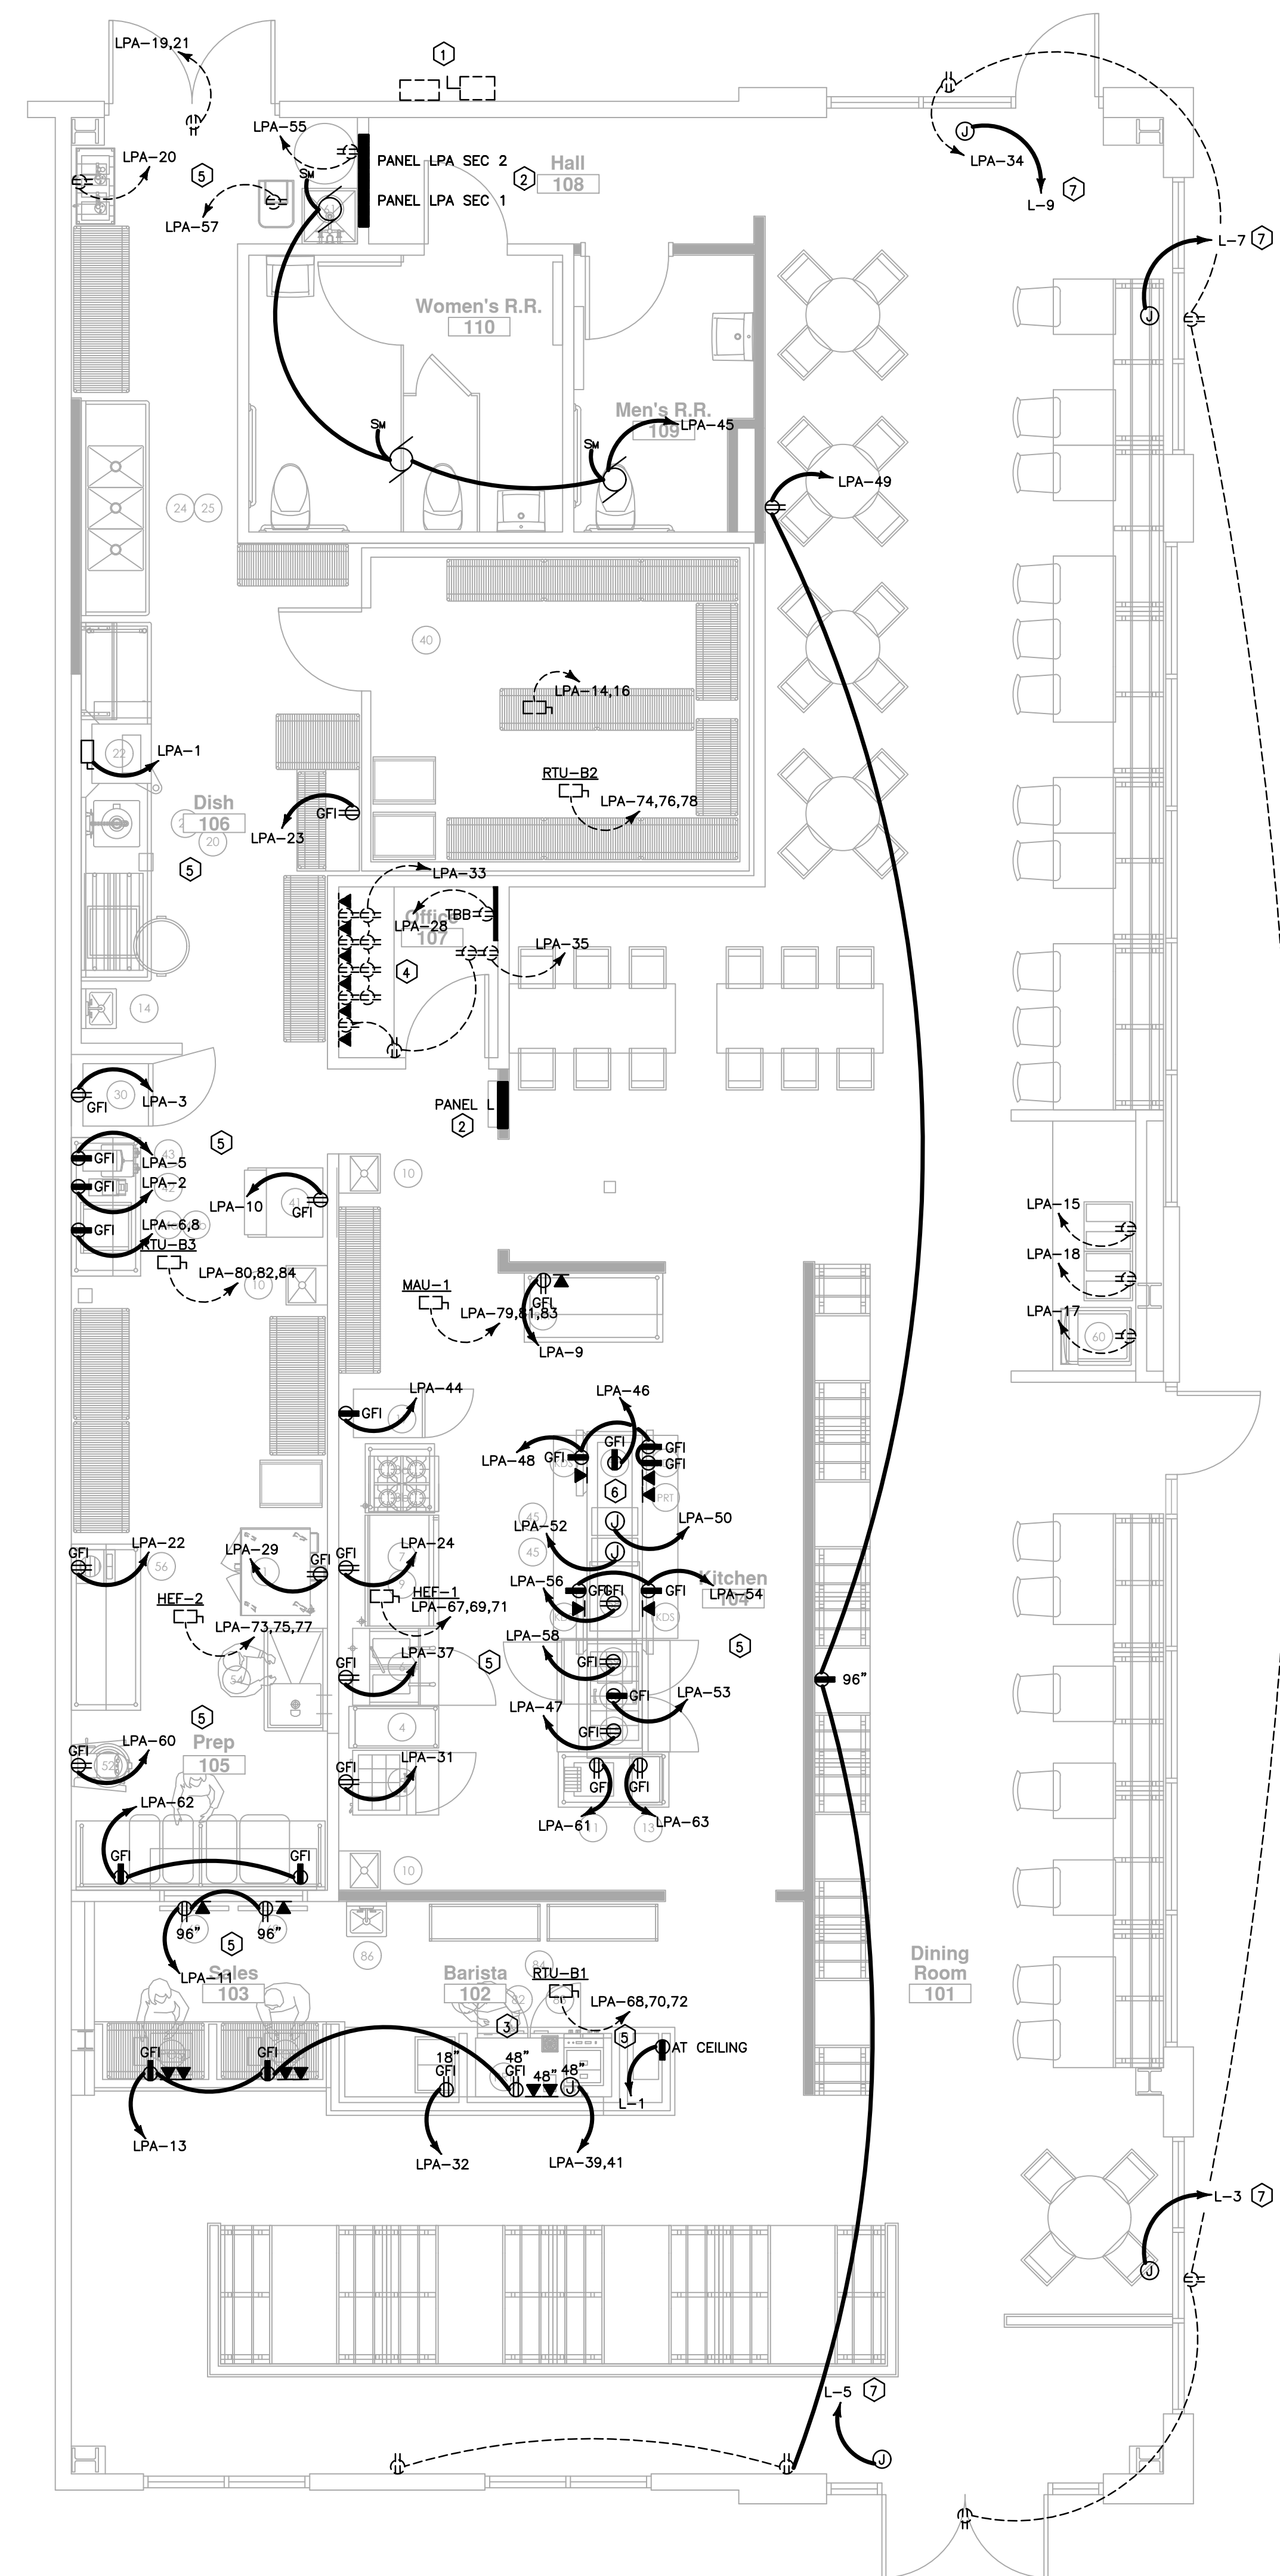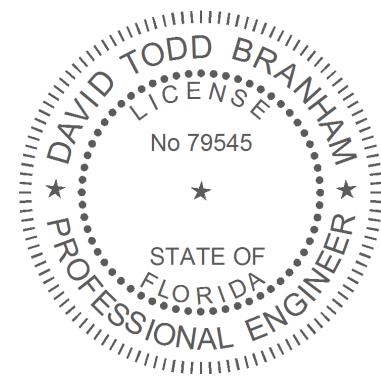


POWER & SYSTEMS NOTES:

- EXISTING 400-AMP 120/208 VOLT 3-PHASE SERVICE WITH 400-AMP SERVICE DISCONNECT AND METER WITH NEMA-3R ENCLOSURE AT SERVICE ENTRANCE. FIELD VERIFY EXACT LOCATION.
- NEW 100-AMP SUB-PANEL AT LOCATION SHOWN. PROVIDE NEW CONDUCTORS FROM DISCONNECT.
- SEE 3/A3.3 INTERIOR ELEVATIONS FOR ELECTRICAL LAYOUT AT BARISTA COUNTER. ESPRESSO AND PRINTER SHALL BE ABOVE COUNTER WITH REFRIGERATOR BELOW COUNTER.
- SEE ARCHITECTURAL INTERIOR ELEVATIONS FOR ELECTRICAL LAYOUT AT DESK AREA.
- ALL 15-AMP AND 20-AMP RECEPTACLES IN KITCHEN, DISH, PREP, SALES AREAS ARE TO BE GFI.
- COORDINATE KITCHEN ISLAND AREA POWER REQUIREMENTS WITH SHOP DRAWINGS.
- COORDINATE POWER REQUIREMENTS FOR EXTERIOR SIGNAGE WITH OWNER AND SIGN FABRICATOR DRAWINGS.

GENERAL ELECTRICAL NOTES:

- THESE DRAWINGS ARE DIAGRAMMATIC AND SHOW GENERAL ELECTRICAL LAYOUTS FOR BIDDING PURPOSES ONLY. IT IS THE RESPONSIBILITY OF THE CONTRACTOR TO PREPARE DETAILED SHOP DRAWINGS AND TO CONFIRM SPACE ALLOCATIONS.
- CONTRACTOR SHALL COORDINATE INSTALLATION FOR ALL EQUIPMENT PROVIDED BY OTHERS. USE LATEST EDITION OF VENDOR DRAWINGS FOR MODEL NUMBERS AND REQUIREMENTS FOR A COMPLETE OPERABLE SYSTEM. CONTRACTOR SHALL ASSUME ALL RESPONSIBILITY FOR A COMPLETE OPERABLE SYSTEM.
- SEE ARCHITECTURAL AND STRUCTURAL DRAWINGS FOR ALL BUILDING DIMENSIONS, DETAILS, ELEVATIONS AND EXACT LOCATIONS OF FIXTURES.
- CONTRACTOR SHALL VERIFY VOLTAGES AVAILABLE PRIOR TO ROUGHING IN.
- MOUNTING HEIGHTS AS INDICATED ON DRAWINGS SHALL BE FROM THE FINISHED FLOR TO THE CENTER LINE OF THE OUTLET BOX.
- PANELBOARD AND SAFETY DISCONNECTS SHALL BE EASILY ACCESIBLE AND MAINTAIN ALL SERVICE CLEARANCE PER NEC.
- THE ELECTRICAL DRAWINGS ARE ONLY A PART OF THE CONTRACT DOCUMENTS. ALL OF THE DRAWINGS AND SPECIFICATIONS MUST BE REVIEWED FOR THEIR INTER-RELATIONSHIP AND REQUIRED COORDINATION BETWEEN TRADES.
- ALL WORK SHALL CONFORM TO APPLICABLE NEC, LOCAL BUILDING CODES, AND STATE HEALTH REGULATIONS HAVING JURISDICTION, AND STATE AMENDMENTS TO BUILDING CODE.
- IN AREAS WHERE ELECTRICAL OUTLETS ARE LOCATED BENEATH A WINDOW AND THE WINDOW PREVENTS ROUTING OF CONDUIT UP THE WALL; CONDUIT SHALL BE ROUTED TO A WALL WHICH ALLOWS CONDUIT TO RISE UP TO CEILING SPACE.
- ALL CONDUIT ROUTED FROM PANELBOARD TO DISCONNECTS AT EXTERIOR HVAC UNITS OR ANY OTHER EQUIPMENT SHALL BE ROUTED BELOW GRADE. TRANSITION FROM GRADE TO EQUIPMENT TO MAKE A SEALTIGHT CONNECTION.
- ALL FLUSH RECESSED OUTLET BOXES SHALL BE INSTALLED SUCH THAT FRONT EDGE OF BOX WILL NOT BE SET BACK OF THE FINISHED SURFACE MORE THAN 1/4" IN ORDER TO COMPLY WITH N.E.C. 314-20. SUPPORT OF OUTLET BOX BY RECEPTACLE AND COVERPLATE IS NOT ACCEPTABLE.
- ALL CONDUIT, OUTLET BOXES, AND LOW VOLTAGE CABLING SHALL BE APPROPRIATELY SUPPORTED THROUGHOUT THE PROJECT. SUPPORT OF THESE ITEMS BY CEILING GRID OR GRID SUPPORT WIRES IS NOT ACCEPTABLE.
- ALL RECEPTACLES LOCATED WITHIN 6'-0" TO THE EDGE SINK OR OTHER WATER SOURCE SHALL BE GFCI TYPE DEVICE IN ACCORDANCE WITH N.E.C. 210-8.A.7. COORDINATE LOCATIONS WITH ARCHITECTURAL AND PLUMBING DRAWINGS PRIOR TO ROUGH-IN.
- COORDINATE EXACT LOCATION OF ALL MECHANICAL AND PLUMBING EQUIPMENT WITH DIVISION 23 PRIOR TO ROUGH IN. ADJUST LOCATION OF DISCONNECTING MEANS AND BRANCH CIRCUITRY AS REQUIRED.
- PRIOR TO PROJECT COMPLETION, ELECTRICAL CONTRACTOR SHALL OBTAIN FINAL SPACE NUMBERS FROM OWNER AND/OR ARCHITECT. TYPEWRITTEN PANELBOARD DIRECTORIES SHALL REFLECT SPACE DESIGNATION OF EACH CIRCUIT. NO EXCEPTIONS.
- ALL THHN / THWN WIRE SHALL HAVE A FACTORY INSTALLED COLOR CODED OUTER JACKET. CONTRACTOR IS TO NOTE THAT ALL FEEDER CONDUCTORS SHALL HAVE FULL COLOR CODED OUTER JACKET INTEGRAL TO THE CONDUCTOR INSULATION. USE OF COLOR PHASING TAPE IS NOT ALLOWED.
- ALL RECEPTACLES AND SWITCHES SHALL BE SIDEWIRED, CONTRACTOR MY ELECT TO USE FACTORY TERMINATED MALE / FEMALE QUICK CONNECTS. (P&S "PLUGTAIL" OR EQUAL).
- ALL LOW VOLTAGE SYSTEMS WHICH HAVE UNDERGROUND CONDUIT / CONDUCTORS ROUTED OUTSIDE OF THE BUILDING FOOTPRINT SHALL HAVE LIGHTNING PROTECTION SURGE MODULES LOCATED AT EACH END OF LOW VOLTAGE CABLING.
- ALL WIRING DEVICE COVERPLATES SHALL BE HAND LABELED ON BACK OF COVERPLATE. LABELING SHALL BE PERMANENT MARKER, LEGIBLE, AND NOTE PANEL/CIRCUIT NUMBER SERVING DEVICE.
- ALL EMPTY CONDUITS SHALL HAVE PULLSTRINGS INSTALLED. CAP OFF ALL STUB UP CONDUIT, INSTALL LABEL NOTING LOCATION OF CONDUIT STUB OUT.
- ALL LOW VOLTAGE CONDUCTORS NOT IN CONDUIT SHALL BE PLENUM RATED. ALL TY-WRAPPS SUPPORTING SUCH SHALL BE PLENUM RATED. PROVIDE J-HOOKS AND SUPPORT MEANS AS REQUIRED.
- ELECTRICAL CONTRACTOR SHALL REVIEW ARCHITECTURAL, STRUCTURAL, PLUMBING, SPRINKLER AND MECHANICAL DRAWINGS AND COORDINATE HIS WORK WITH ALL OTHER TRADES FOR POWER REQUIREMENTS AND EQUIPMENT PLACEMENT. AVOID INTERFERENCE WITH ARCHITECTURAL FEATURES, BEAMS, FOOTINGS, WINDOWS, ETC. NOTIFY ARCHITECT OF ANY CONFLICTS.
- SLEEVES SHALL BE INSTALLED WHERE PIPING PASSES THROUGH STRUCTURE.
- ALL OPENINGS THROUGH RATED WALLS SHALL BE SEALED WITH AN APPROVED FIREPROOFING TO MAINTAIN THE INTEGRITY OF THE WALL.
- PROVIDE MANUFACTURED COMPATIBLE PIPE HANGERS, RODS AND INSERTS, OR CLAMPS FOR THE PROPER SUPPORT OF ALL CONDUIT. NO BAND IRON, TIE WIRE, METAL STRAPPING OR WIRE STRAPPING WILL BE PERMITTED.
- UPON COMPLETION OF THE WORK COVERED BY THIS CONTRACT, FURNISH THE OWNER WITH ONE (1) SET OF REPRODUCIBLE RECORD DOCUMENTS WHICH SHOW ALL ELECTRICAL INSTALLED UNDER THIS CONTRACT.

1 FLOOR PLAN - POWER & SYSTEMS
E1.2 Scale: 1/4" = 1'-0"

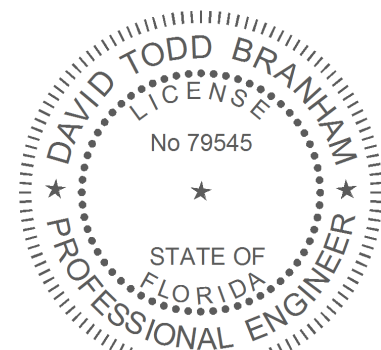

ELECTRICAL SPECIFICATIONS

PART 1 GENERAL

1. FURNISH ALL MATERIALS, LABOR, TOOLS, TRANSPORTATION AND INCIDENTALS TO COMPLETE IN EVERY DETAIL, AND LEAVE IN WORKING ORDER ITEMS SHOWN ON THE CONTRACT DOCUMENTS.
2. INSTALLATION AND COORDINATION OF HIS WORK WITH OTHER TRADES. CONTRACTOR SHALL COORDINATE AND MAKE MINOR ADJUSTMENTS IN COORDINATION.
3. LAYOUT SHOWN IN DRAWINGS IS BASED ON A PARTICULAR MAKE OF EQUIPMENT. CONTRACTOR SHALL PROVIDE SIX SUBMITTAL SETS OF INDICATED PRODUCTS SHOP DRAWINGS TO THE ENGINEER FOR APPROVAL PRIOR TO STARTING WORK. PANEL SCHEDULES SHALL BE REJECTED WITHOUT DIMENSIONED LAYOUT OF ELECTRICAL ROOM(S), IF ANOTHER MAKE OF EQUIPMENT IS DESIRED, THESE SUBMITTALS SHALL ALSO SHOW ALL REQUIRED MODIFICATIONS AND CHANGES, INCLUDING THOSE INVOLVING CONTRACTOR MUST RECEIVE APPROVED SUBMITTAL COPY, SIGNED BY ENGINEER BEFORE PROCEEDING WITH ANY MODIFICATIONS. WORK INSTALLED USING UNAPPROVED SUBSTITUTIONS SHALL BE REPLACED AT NO ADDITIONAL COST TO THE OWNER.
4. CONTRACTOR SHALL VISIT THE SITE AND FULLY INFORM HIMSELF CONCERNING ALL CONDITIONS AFFECTING SCOPE OF WORK. FAILURE TO DO SO SHALL NOT RELIEVE CONTRACTOR OF ANY RESPONSIBILITY IN THE PERFORMANCE OF HIS WORK. ALL WORKMANSHIP SHALL BE OF THE HIGHEST QUALITY IN ACCORDANCE WITH THE BEST PRACTICES OF THE TRADE BY CRAFTSMEN SKILLED IN THIS PARTICULAR WORK.
5. COMPLETED INSTALLATION SHALL CONFORM TO ALL APPLICABLE FEDERAL, STATE AND LOCAL CODES AND ORDINANCE, INCLUDING BUT NOT LIMITED TO THE LATEST APPROVED EDITIONS OF THE FOLLOWING:
- NFPA-70- NATIONAL ELECTRICAL CODE
 - NFPA-72- PROTECTIVE SIGNALING SYSTEMS
 - NFPA-101- LIFE SAFETY CODE
 - INTERNATIONAL BUILDING CODE
6. CONTRACTOR SHALL MAINTAIN LIGHTING AND POWER AND SHALL PROVIDE MATERIALS NECESSARY FOR TEMPORARY LIGHTS AND POWER. POWER CONSUMPTION WILL BE PAID FOR BY THE CONTRACTOR.
7. OBTAIN PERMITS AND CERTIFICATES OF APPROVAL FROM ALL AUTHORITIES HAVING JURISDICTION OVER THE INSTALLATION AND PAY ALL FEES REQUIRED.

PART 2 PRODUCTS

1. CONDUIT
- A. PROVIDE A COMPLETE CONDUIT SYSTEM WITH ASSOCIATED COUPLINGS, CONNECTORS, AND FITTINGS.
- B. CONDUIT SHALL BE AS MANUFACTURED BY ALLIED, WHEATLAND OR REPUBLIC FOR GALVANIZED RIGID/EMT AND ANACONDA, ALFLEX OR INTERNATIONAL FOR FLEXIBLE STEEL CONDUIT.
- C. FOR EMT PROVIDE STEEL SET SCREW TYPE COUPLINGS, CONNECTORS, AND FITTINGS WITH NYLON INSULATED THROATS AND CASE HARDENED LOCKNUTS.
- D. RIGID NONMETALLIC (PVC) CONDUIT: CARLON SCHEDULE 40, HEAVY WALL OR APPROVED EQUAL.
- E. RUN CONCEALED CONDUITS IN AS DIRECT LINE AS POSSIBLE BETWEEN OUTLETS. RUN EXPOSED CONDUITS AT RIGHT ANGLES WITH BUILDING STRUCTURE.
- F. MAINTAIN INTEGRITY OF FIRE PARTITIONS AND FLOOR SLABS WHERE CONDUITS PASS THROUGH SLEEVES FROM ONE AREA TO ANOTHER WITH U.L. LISTED FIRE AND SMOKE STOP FITTINGS.
- G. COMPLETE ALL CONDUIT SYSTEMS BEFORE INSTALLING CONDUCTORS.
- H. INSTALL COPPER, GROUND WIRE IN ALL FLEXIBLE CONDUIT.
- I. ALLOW SUFFICIENT SLACK IN FLEXIBLE CONDUIT TO REDUCE VIBRATION EFFECT. USE LIQUIT-TIGHT FLEXIBLE CONDUIT FOR FINAL CONNECTION TO MOTORS AND WHERE SUBJECTED TO DAMP AND WET LOCATION.
- J. SUPPORT CONDUIT WITH APPROVED STRAPS AND HANGERS AT INTERVALS REQUIRED BY N.E.C.
- K. USE ELECTRICAL METALLIC TUBING WHERE DRAWINGS CALL FOR CONDUIT TO BE CONCEALED IN WALLS OR ABOVE CEILINGS.
- L. USE GALVANIZED RIGID WHERE CONDUITS ARE RUN EXPOSED ABOVE FINISHED FLOOR OR GRADE.
- M. USE PVC SCHEDULE 40 WHERE RUN IN SLAB (ON FIRST FLOOR ONLY) AND BELOW GRADE WITH TRANSITION BEING MADE TO GALVANIZED RIGID BEFORE TURNING UP OUT OF SLAB OR GRADE.
- N. MINIMUM CONDUIT SIZE SHALL BE 1/2".
2. WIRE AND CABLE
- A. PROVIDE A COMPLETE SYSTEM OF CONDUCTORS FOR LIGHTING AND POWER SYSTEMS THROUGHOUT THE PROJECT
- B. ALL CONDUCTORS SHALL BE 98 PERCENT CONDUCTIVITY COPPER WITH 600 VOLT MINIMUM INSULATION. 75 DEGREE C
- C. ALL CONDUCTORS NO. 8 AND SMALLER SHALL HAVE TYPE THHN OR THWN INSULATION AND SHALL BE SOLID UNLESS NOTED OTHERWISE ON PLANS.
- D. ALL CONDUCTORS NO. 6 AND LARGER SHALL HAVE TYPE THHN OR THWN INSULATION AND SHALL BE STRANDED UNLESS NOTED OTHERWISE ON PLANS.
- E. CONDUCTORS SHALL BE AS MANUFACTURED BY ANACONDA, GENERAL CABLE, HABIRSHAW, OKONITE, ROME, TRIANGLE OR SOUTHWIRE UNLESS NOTED OTHERWISE.
- F. MAKE ALL SPLICES OR CONNECTIONS ONLY AT OUTLET OR JUNCTION BOXES.
- G. USE ONLY APPROVED (SOAPSTONE) OR OTHER LUBRICANT WHERE REQUIRED.
- H. USE APPROVED SCOTCHLOCK OR T&B CONNECTORS FOR INTENDED APPLICATION WHERE CONNECTORS ARE REQUIRED.
- I. CONDUCTORS ARE TO BE COLOR CODED WITH A DIFFERENT COLOR FOR EACH PHASE, NEUTRAL, AND GROUND AS FOLLOWS:
120/208V CIRCUITS: PHASE A, B, AND C: BLACK, RED, AND BLUE RESPECTIVELY. NEUTRAL, WHITE. GROUND, GREEN.
- J. CONDUCTORS ARE TO BE COLOR CODED WITH A DIFFERENT COLOR FOR EACH PHASE, NEUTRAL, AND GROUND AS FOLLOWS:
277/480V CIRCUITS: PHASE A, B, AND C: BROWN, ORANGE, AND YELLOW RESPECTIVELY. NEUTRAL, WHITE. GROUND, GREEN.
3. OUTLET AND JUNCTION BOXES
- A. PROVIDE EACH FIXTURE, SWITCH, RECEPTACLE, AND OTHER DEVICE WITH A GALVANIZED STEEL OUTLET BOX OF APPROPRIATE SIZE AND DEPTH FOR ITS PARTICULAR LOCATION AND PROVIDE PULL AND JUNCTION BOXES WHERE REQUIRED.
- B. CEILING OUTLET BOXES SHALL BE 4" OCTAGON AND WALL BOXES TO BE 4" SQUARE WITH RAISED PLASTER RINGS OR DEVICE RINGS. PROVIDE FIXTURE STUDS IN CENTER OF BOXES USED FOR SUPPORT OF FIXTURES.
- C. OUTLET AND JUNCTION BOXES SHALL BE AS MANUFACTURED BY NATIONAL APPLETON, GENERAL ELECTRIC, RACO, OR STEEL CITY.
- D. INSTALL PULL BOXES IN ALL CIRCUITS OR FEEDERS OVER 100 FEET LONG.
- E. OUTLET BOXES SHALL BE SECURELY ANCHORED, SET TRUE AND PLUMB AND NO PART OF BOX OR COVER SHALL EXTEND BEYOND FINISHED WALL OR CEILING. FLUSH MOUNTED BOXES SHALL BE SET TO WITHIN 1/8" OF FINISHED WALL AND A PLASTER RING USED TO MAKE COVER FLUSH WITH WALL. PLASTER RING NOT REQUIRED FOR EXPOSED LOCATIONS.

- F. OUTLET BOXES SHALL NOT BE LOCATED ON OPPOSITE SIDES OF THE SAME FIRE OR SMOKE RATED WALL WITHIN THE SAME STUD COMPARTMENT. BOXES SHALL BE OFFSET AS REQUIRED TO PREVENT THIS AND TO MAINTAIN WALL RATINGS.
4. WIRING DEVICES AND PLATES
- A. PROVIDE SUBMITTALS.
- B. PROVIDE SWITCHES, RECEPTACLES, AND OTHER WIRING DEVICES AS INDICATED ON DRAWINGS.
- C. PROVIDE IVORY DEVICE PLATES ON ALL WIRING DEVICES. UNLESS DIRECTED OTHERWISE BY OWNER. FIELD COORDINATE DEVICE AND DEVICE PLATE COLOR TO MATCH WALL COVERINGS AS DIRECTED BY OWNER.
- D. SWITCHES (LEVITON NO. USED; P&S, LUTRON OR HUBBLE ACCEPTABLE).
- 1) 20AMP, 120/277V, AC:
CSB1-201 SINGLE POLE
CSB4-201 THREE WAY
- E. RECEPTACLES:
- 1) 20-AMP, 125 V, AC:
BR20-1 DUPELEX TYPE
68991 GF1
- F. MISCELLANEOUS DEVICES:
- 1) MANUAL MOTOR STARTER: BRYANT NO. 10004 OR SQUARE D, CLASS 2150.
- G. MOUNT ALL SWITCHES 48" ABOVE FINISHED FLOOR UNLESS NOTED OTHERWISE.
- H. MOUNT ALL RECEPTACLES 18" ABOVE FINISHED FLOOR UNLESS NOTED OTHERWISE OR OTHERWISE REQUIRED TO MATCH EXISTING DEVICES IN SAME ROOM.
- I. CHECK ARCHITECTURAL DRAWINGS FOR SPECIAL MOUNTING CONDITIONS FOR CASEWORK AND IN SPECIAL AREAS
- J. INSTALL DEVICE PLATES IN FULL CONTACT WITH WALL.
5. PANELBOARDS
- A. PROVIDE SUBMITTALS SHOWING CIRCUIT BREAKER SIZES, AIC RATINGS, BUS AND NEUTRAL SIZES, PROVIDE ROOM DIMENSIONS IF APPLICABLE.
- B. PANELBOARDS SHALL BE OF THE CIRCUIT BREAKER TYPE AS MANUFACTURED BY SQUARE "D", SIEMENS, GENERAL ELECTRIC, CUTLER-HAMMER OR APPROVED EQUAL.
- C. PANELBOARDS SHALL BE RATED FOR 120/208 VOLT 3 PHASE, 4 WIRE, AND 277/480 VOLT 3 PHASE, 4 WIRE AS INDICATED ON SCHEDULE.
- D. ALL PANELBOARDS SHALL HAVE ISOLATED NEUTRAL BUS.
- E. ALL PANELS SHALL HAVE SEPARATE GROUND BUS CONNECTED WITH A GREEN GROUNDING CONDUCTOR BACK TO THE SOURCE OF ITS PARTICULAR FEED.
- F. ALL PANELBOARDS SHALL HAVE TYPED DIRECTORY CARDS EXCEPT THAT POWER PANELS WILL BE ENGRAVED PHENOLIC NAMEPLATES ATTACHED TO THE INDIVIDUAL BREAKERS INDICATING THE PANELBOARD OR DEVICE BEING SERVED.
- G. INSTALL FLUSH MOUNTED PANELBOARDS WHERE INDICATED SO THAT THE PANEL BOX WILL BE FLUSH WITH THE WALL SURFACE AND THE PANELBOARD FRONT WILL BE IN FULL CONTACT WITH THE WALL. STUB OUT INTO CEILING SPACE A MINIMUM OF ONE 3/4" EMPTY CONDUIT PER EACH 3 POLES OF SPARES OR SPACES.
- H. SURFACE MOUNTED PANELBOARDS SHALL BE FIRMLY ATTACHED TO THE WALL ON WHICH IT IS BEING MOUNTED.
- I. ALL PANELBOARDS SHALL HAVE A COPPER BUS.
6. SAFETY SWITCHES
- A. PROVIDE SUBMITTALS
- B. SAFETY SWITCHES SHALL BE AS MANUFACTURED BY SQUARE D, SIEMENS, GENERAL ELECTRIC, CUTLER-HAMMER OR APPROVED EQUAL.
- C. SAFETY SWITCHES SHALL BE OF THE HEAVY DUTY TYPE WITH ARC SHIELDS AND GROUND LUG AND SHALL BE RATED FOR THE VOLTAGE OF THE SYSTEM TO WHICH IT IS BEING USED.
- D. PROVIDE NEMA 1 ENCLOSURES FOR INTERIOR APPLICATIONS AND NEMA 3R FOR EXTERIOR APPLICATIONS OR IN WET LOCATIONS.
- E. FUSES FOR SAFETY SWITCHES SHALL BE AS MANUFACTURED BY BUSSMAN OR LITTELFUSE AND SHALL BE DUAL ELEMENT FUSETRONS FOR MOTORS AND "LOW PEAK" FOR OTHER LOADS.
7. SERVICE ENTRANCE AND GROUNDING
- A. ALL CURRENT CONSUMING DEVICES SHALL HAVE A GROUND WIRE INSTALLED IN THE SAME CONDUIT AS THE PHASE CONDUCTORS FROM THE PANEL TO THE DEVICE. THIS APPLIES TO RECEPTACLES, MOTORS, ETC.
- B. SERVICE ENTRANCE RACEWAYS, CONDUCTORS, TRENCHING, BACKFILL, ETC. SHALL BE INSTALLED AS INDICATED ON DRAWINGS AND PER NEC AND LOCAL CODE REQUIREMENTS INCLUDING LOCAL UTILITY COMPANY INSTALLATION SPECIFICATIONS.
- C. ALL GROUND WIRE SHALL BE COPPER WITH A GREEN INSULATION OR IF A GREEN INSULATION IS NOT AVAILABLE, THEN GREEN IDENTIFYING TAPE WILL BE INSTALLED AT BOTH TERMINATION POINTS.
- D. ALL MATERIALS SHALL BE AS SPECIFIED ON DRAWINGS OR AS SPECIFIED BY LOCAL UTILITY COMPANY FOR SERVICE EQUIPMENT INSTALLATIONS.
- E. PROVIDE GROUND WIRES THROUGHOUT DISTRIBUTION SYSTEM AND TO ALL UTILIZATION EQUIPMENT, SUCH AS RECEPTACLES, MOTORS, AND OTHER REQUIREMENT LOCATIONS PER NATIONAL ELECTRICAL CODE ARTICLE 250.
- F. PROVIDE SERVICE INSTALLATION PER DRAWINGS. CONTRACTOR SHALL FIELD COORDINATE EXACT LOCATION AND POINT OF SERVICE INSTALLATION WITH UTILITY COMPANY INCLUDING PROVIDING FINAL BROKEN DOWN LISTING OF LOADS FOR UTILITY COMPANY USE IN DETERMINING SERVICE EQUIPMENT SIZES AND TYPES.
8. LIGHTING FIXTURES
- A. PROVIDE SUBMITTALS
- B. PROVIDE LIGHTING FIXTURES AS INDICATED ON LIGHTING FIXTURE SCHEDULE ON DRAWINGS. EQUAL TO BE BY LITHONIA, BENJAMIN-DAYBRITE, HUBBELL, METALUX OR LIGHTOLIER.
- C. FLUORESCENT BALLASTS SHALL BE ELECTRONIC AS MANUFACTURED BY ADVANCE, MOTOROLA OR MAGNETEC.
- D. FLUORESCENT LAMPS SHALL BE RAPID START COOL WHITE UNLESS NOTED OTHERWISE.
- E. LED FIXTURES SHALL BE 4000K MINIMUM.
- F. HID LAMPS SHALL BE RATED AT VOLTAGE INDICATED ON DRAWINGS. HID FIXTURES SHALL BE FURNISHED WITH REGULATING, HPF BALLASTS AND WHERE RECESSED, SHALL HAVE INTEGRAL THERMAL PROTECTION.
- G. LAMPS SHALL BE AS MANUFACTURED BY GENERAL ELECTRIC, SYLVANIA, OR PHILIPS.
- H. TIME SWITCHES OR PHOTOCELLS SHALL BE TORK, INTERMATIC OR PARAGON OF TYPES SHOWN ON DRAWINGS.

- I. JOINTS AND FIXTURE WIRING SHALL BE MADE USING WIRE NUTS, PREINSULATED SCOTCH LOCKS OR OTHER APPROVED MECHANICAL MEANS OF CONNECTION.
- J. COORDINATE FIXTURE LOCATIONS TO CLEAR DIFFUSERS, DUCTWORK, PIPING, ETC.
- K. COORDINATE FIXTURE TYPES WITH CEILING TYPES BEING INSTALLED.
- L. ADJUST FIXTURES TO LIGHT INTENDED AREA WHERE ADJUSTABLE.
9. TELEPHONE/DATA RACEWAY SYSTEM
- A. PROVIDE CONDUIT STUB UP AS INDICATED ON THE DRAWINGS AT EACH DEVICE.
- B. TERMINATE CONDUITS ABOVE DROPPED CEILING USING NYLON INSULATED BUSHINGS.
- C. OUTLET BOXES SHALL BE 411/16" SQUARE BOXES WITH PLASTER RING AND COVER AS REQUIRED BY TELEPHONE VENDOR.
- D. PROVIDE SERVICE CONDUITS, OUTLET CONDUITS, BACK BOXES, COVER PLATES, JUNCTION BOXES, AND TERMINAL BOARDS OR CABINETS AS REQUIRED BY DRAWINGS AND TELEPHONE/ DATA VENDOR.
- E. LEAVE NYLON PULLSTRING IN ALL EMPTY CONDUITS.
- F. PROVIDE METALLIC CONDUIT SLEEVES WHEREVER CABLES PASS THROUGH FIRE OR SMOKE RATED WALL ASSEMBLIES.
- G. OWNER VENDOR TO PROVIDE CABLE, PULL CABLE AND MAKE TERMINATIONS.
- H. SERVICE ENTRANCE CONDUITS AND FIREPROOF 4 x 4" x 3/4" TERMINAL BOARDS SHALL BE FURNISHED AS SHOWN ON DRAWINGS. CONTRACTOR SHALL FIELD COORDINATE ACTUAL LOCATION OF TERMINATION WITH LOCAL UTILITY PRIOR TO ROUGH-IN. GROUND WITH BARE #6 AWG THROUGH GROUND BUSHINGS.

PART 3 EXECUTION

- 1) CONTRACTOR SHALL BE RESPONSIBLE FOR ALL DEFECTS, REPAIRS, MATERIALS AND WORKMANSHIP FOR A PERIOD OF ONE (1)YEAR AFTER FINAL PAYMENT IS APPROVED. CONTRACTOR SHALL HONOR FACTORY WARRANTIES ON ALL EQUIPMENT PROVIDED.
- 2) UPON COMPLETION OF PROJECT, ALL EQUIPMENT AND MATERIALS SHALL BE IN NEW, CLEAN CONDITIONS WITH ALL DAMAGE RESTORED TO ACCEPTABLE CONDITION. ALL EQUIPMENT SHALL BE INSPECTED AND THOROUGHLY CLEANED, READY FOR USE. AT COMPLETIONS OF JOB, ALL MISCELLANEOUS TOOLS, SCAFFOLDING, SURPLUS MATERIALS, RUBBISH AND DEBRIS SHALL BE REMOVED BY CONTRACTOR.
3. WHERE CONDUITS ARE TO PASS THROUGH WALLS, FLOORS, ETC. SLEEVES SHALL BE PROVIDED PRIOR TO WALL CONSTRUCTION. SLEEVES SHALL BE OF RIGID METAL WHERE SLEEVES PENETRATE EXTERIOR SURFACES, VOIDS SHALL BE SEALED WATER TIGHT. WHERE SLEEVES PASS THROUGH RATED PARTITIONS, SLEEVE PACKING SHALL BE OF U.L. LISTED FIRE SAFE TYPE.
4. CONTRACTOR SHALL SUBMIT THREE SETS (3) OF INSTRUCTION BOOKS, INCLUDING INSTALLATION, OPERATION AND MAINTENANCE INSTRUCTIONS, PAMPHLETS OR PROCEDURES AND ALL EQUIPMENT WARRANTIES OBTAINED FROM EACH MANUFACTURER OF EQUIPMENT.
5. CONTRACTOR SHALL MAINTAIN ONE SET OF BLUE LINES AT THE CONSTRUCTION SITE. THESE BLUE LINES SHALL BE MARKED FOR CHANGES AND SHALL BE USED FOR AS-BUILT DRAWINGS. TURN DRAWINGS OVER TO THE OWNER AT THE COMPLETION OF THE PROJECT.
6. ELECTRICAL DRAWINGS ARE DIAGRAMMATIC AND SHALL NOT BE SCALED FOR EXACT SIZES OR LOCATIONS.