

C:\PASTORIUS - 10:39 AM - E1.00 LEGEND AND NOTES.dwg

ELECTRICAL LEGEND

	A-1 ADJACENT TO ARROW INDICATES HOMERUN OF CIRCUIT NO. 1 TO PANEL A; "B" INDICATES FIXTURE TYPE, MARKS ACROSS RACEWAY RUN INDICATES THE NUMBER OF NO. 12 CONDUCTORS, UNLESS NOTED OTHERWISE NO MARKS INDICATES TWO NO. 12 CONDUCTORS AND ONE NO. 12 GREEN GROUND CONDUCTOR IN 1/2" CONDUIT (2#12 & 1#12 GND-1/2"C)
	CEILING FIXTURE
	WALL BRACKET FIXTURE
	2' X 2' FIXTURE; CEILING MOUNTED
	2' X 2' FIXTURE WITH INTEGRAL EMERGENCY BATTERY; CEILING MOUNTED
	1' X 4' FIXTURE; CEILING MOUNTED
	1' X 4' FIXTURE WITH INTEGRAL EMERGENCY BATTERY; CEILING MOUNTED
	EXIT SIGN; CEILING MOUNTED; ARROWS AS NOTED; SHADED SECTION INDICATES LIGHTED FACE OF EXIT SIGN
	EXIT SIGN; BACK MOUNTED; ARROWS AS NOTED; SHADED SECTION INDICATES LIGHTED FACE OF EXIT SIGN
	JUNCTION BOX; MOUNTED ABOVE CEILING
	JUNCTION BOX; MOUNTED FLUSH IN WALL WITH BLANK COVER
	DUPLEX RECEPTACLE; 125V; 20A; 3 POLE GND; MT 18" AFF TO C/L UNLESS NOTED OTHERWISE; NEMA 5-20R; HUBBELL SERIES HBL5352
	CEILING MOUNTED DUPLEX RECEPTACLE; 125V; 20A; 3 POLE GND; MT FLUSH IN CEILING UNLESS NOTED OTHERWISE; NEMA 5-20R; HUBBELL SERIES HBL5352
	FLOOR MOUNTED DUPLEX RECEPTACLE; 125V; 20A; 3 POLE GND; MT FLUSH IN FLOOR UNLESS NOTED OTHERWISE; NEMA 5-20R; HUBBELL SERIES HBL5352
	QUAD RECEPTACLE; 125V; 20A; 3 POLE GND; MT 18" AFF TO C/L UNLESS NOTED OTHERWISE; NEMA 5-20R; HUBBELL SERIES HBL5352
	DUPLEX RECEPTACLE; 125V; 20A; 3 POLE GND; GF; MT 18" AFF TO C/L UNLESS NOTED OTHERWISE; NEMA 5-20R; HUBBELL SERIES GF5362
	LETTERS "WP" ADJACENT TO SYMBOL INDICATES GF1 WEATHER RESISTANT RECEPTACLE; HUBBELL HBLGFBHP20 SERIES WITH WEATHERPROOF COVER; HUBBELL ATYMAC MR420CW COVER.
	DUPLEX RECEPTACLE FOR TELEVISION WITH TVSS PROTECTION, LED AND ALARM; 125V; 20A; 2 POLE; 3 WIRE; GND; SEE TELECOM PLANS FOR MOUNTING DETAILS. NEMA 5-20R; HUBBELL SERIES HBL5362SA
	LETTERS "+XX" ADJACENT TO SYMBOL INDICATES RECEPTACLE MOUNTING HEIGHT. +AC" = ABOVE COUNTER +DF" = VERIFY HEIGHT FOR DRINKING FOUNTAIN WITH MECHANICAL CONTRACTOR +TV" = VERIFY HEIGHT OF TV WITH OWNER.
	SPECIAL TYPE RECEPTACLE; "X" DENOTES NEMA TYPE; VERIFY MOUNTING REQUIREMENTS WITH EQUIPMENT CONTRACTOR. A - 250V, 20A, 2P, 3W, NEMA L6-20R; HUBBELL SERIES HBL2320
	THREE GANG COMBINATION POWER/TELECOM FLOOR BOX; ONE DUPLEX RECEPTACLE; 125V; 20A; 3 POLE GND; NEMA 5-20R; CARLON E976RFB. REFER TO FLOOR BOX DETAIL FOR SPECIFIC INFORMATION. 1-GANG IS FOR THE DUPLEX RECEPTACLE, 1-GANG IS FOR THE OWNER PROVIDED DUPLEX TELECOM OUTLET, 1-GANG IS SPARE FOR FUTURE USE.
	WALL SWITCH; 120/277V; 20A; 1 POLE; A.C. ONLY; MT 48" AFF TO C/L; HUBBELL SERIES HBL1221
	WALL SWITCH; 120/277V; 20A; VACANCY SENSOR DUAL TECHNOLOGY MULTI-WAY TYPE; MT 48" AFF TO C/L; REFER TO SPECS; WATTSTOPPER #DWS-301-W.
	2 POLE, 600V, 30A TOGGLE DISCONNECT SWITCH WITH LOCKABLE ENCLOSURE
	PHOTOCELL; REFER TO LIGHTING CONTROL DIAGRAM
	PANEL; 120/208V; MT 72" AFF TO TOP
	EXHAUST FAN; FURNISHED BY OTHERS
	NON-FUSED DISCONNECT SWITCH; AMP SIZE AS NOTED
	RACEWAY INSTALLED CONCEALED IN WALLS AND/OR ABOVE CEILING
	RACEWAY INSTALLED CONCEALED IN FLOOR SLAB AND/OR BELOW GRADE
	RACEWAY INSTALLED EXPOSED
	FLEXIBLE CONDUIT CONNECTION
	CONDUIT STUB UP WITH FLEXIBLE CONDUIT CONNECTION TO EQUIPMENT
	DATA SYSTEM WALL OUTLET WITH ONE(1) RJ-45 JACK AND COVERPLATE; MT 18" AFF TO C/L UNLESS NOTED OTHERWISE - INSTALL 3/4"C WITH PULLRIBBON UP INTO NEAREST ACCESSIBLE CEILING SPACE.
	DATA SYSTEM WIFI OUTLET WITH ONE(1) RJ-45 JACK AND COVERPLATE; MT ABOVE CEILING UNLESS NOTED OTHERWISE - INSTALL 3/4"C WITH PULLRIBBON TO NEAREST ACCESSIBLE CEILING SPACE.
	FIRE SPRINKLER SYSTEM FLOW/TAMPER SWITCH
	FIRE ALARM SYSTEM AUTOMATIC AIR DUCT SMOKE DETECTOR

Sheet Index	
Sheet Number	Sheet Title
E1.00	LEGEND AND NOTES
E2.00	SITE PLAN ELECTRICAL
E3.00	SALES BLDG. FLOOR PLAN - ELECTRICAL
E3.01	SALES BLDG. FLOOR PLAN - LIGHTING
E3.02	SALES BLDG. 2ND FLOOR PLAN - LIGHTING
E3.03	SALES BLDG. FLOOR PLAN - MISC. SYSTEMS
E4.00	SHOP BLDG. FLOOR PLAN - ELECTRICAL
E4.01	SHOP BLDG. FLOOR PLAN - HVAC POWER
E4.02	SHOP BLDG. FLOOR PLAN - LIGHTING
E4.03	SHOP BLDG. FLOOR PLAN - MISC. SYSTEMS
E5.00	ELECTRICAL DETAILS
E5.01	ELECTRICAL DETAILS
E6.00	LIGHTING CONTROLS DETAILS
E7.00	SCHEDULES
E7.01	SLPR & GROUNDING DETAILS
D1.00	SALES BLDG. DEMOLITION
D2.00	SHOP BLDG. DEMOLITION

ABBREVIATIONS


AFF - ABOVE FINISHED FLOOR
C. - CONDUIT
C/L - CENTERLINE
EC - ELECTRICAL CONTRACTOR
EF - EXHAUST FAN
EMT - ELECTRICAL METALLIC TUBING
GND - GROUND CONDUCTOR
GFI - GROUND FAULT PROTECTION
IMC - INTERMEDIATE METAL CONDUIT
LSI - INDICATES BREAKER SETTING (LONG, SHORT, INSTANTANEOUS)
LTG - LIGHTING
LTS - LIGHTS
PVC - POLYVINYL CHLORIDE CONDUIT
REC - RECEPTACLE
UNO - UNLESS NOTED OTHERWISE
EWH - ELECTRIC WATER HEATER
WP - WEATHERPROOF
RTU - ROOFTOP AIR CONDITIONER
NEC - NATIONAL ELECTRIC CODE (NFPA-70)
NFPA - NATIONAL FIRE PROTECTION ASSOCIATION

ELECTRICAL DEMOLITION NOTES

1. PLANNED INTERRUPTIONS OF UTILITY SERVICE TO ANY FACILITY OR AREAS WITHIN ANY FACILITY AFFECTED BY THIS CONTRACT, SHALL BE CAREFULLY PLANNED AND COORDINATED WITH THE FACILITY PERSONNEL IN ADVANCE OF THE REQUESTED INTERRUPTION. THE CONTRACTOR SHALL NOT INTERRUPT SERVICES UNTIL SPECIFIED APPROVAL HAS BEEN GRANTED. THE REQUEST SHALL INDICATE SERVICES AND AREAS TO BE AFFECTED, DATE AND TIME OF INTERRUPTION AND DURATION OF OUTAGE. REQUEST FOR INTERRUPTION OF SERVICE WILL NOT BE APPROVED UNTIL ALL EQUIPMENT AND MATERIAL REQUIRED FOR THE COMPLETION OF THAT PARTICULAR PHASE OF WORK ARE ON THE JOB SITE.
2. ALL DEMOLITION WORK REQUIRED SHALL BE PERFORMED WITH CARE SO AS NOT TO INTERRUPT OTHER EXISTING SERVICES (WATER, GAS, ELECTRICAL, SEWER, SPRINKLERS, ETC.). IF ACCIDENTAL UTILITY INTERRUPTION, DAMAGE, ETC., RESULTS FROM WORK PERFORMED BY THE CONTRACTOR, THE AFFECTED UTILITY OR SERVICE SHALL BE RETURNED TO ITS ORIGINAL CONDITION WITHOUT DELAY, BY AND AT THE EXPENSE OF THE CONTRACTOR, USING SKILLED WORKMEN OF THE TRADE INVOLVED.
3. REMOVE ALL OUTLETS, PULL BOXES, JUNCTION BOXES, ETC., AS REQUIRED TO COMPLETELY REMOVE THE ELECTRICAL ITEMS SHOWN FOR DEMOLITION UNLESS NOTED TO REMAIN. DISCONNECT AND REMOVE ALL ELECTRICAL PROVISIONS TO EQUIPMENT BEING REMOVED.
4. REMOVE ALL WIRING, CONDUIT, RACEWAYS, OUTLET BOXES, SUPPORTING APPARATUS ETC., AS REQUIRED.
5. SYMBOLS SHOWN ARE TYPICAL AND LOCATIONS ARE APPROXIMATE AND ARE NOT INTENDED TO LIMIT THE AMOUNT OF DEMOLITION. COORDINATE WITH EXISTING CONDITIONS AND THESE NOTES AND REMOVE ALL APPLICABLE SYSTEMS AND COMPONENTS CONFLICTING WITH FINISHED DESIGN INTENT.
6. EXISTING BRANCH WIRING SHOWN IS DIAGRAMMATICAL ONLY AND IS BASED UPON EXISTING AS-BUILT DRAWINGS AND SURVEYS. COORDINATE WITH ACTUAL EXISTING CONDITIONS FOR NUMBER OF CONDUCTORS PER CONDUIT AND EXACT LOCATIONS OF CONDUIT RUNS AND EQUIPMENT.
7. ALL FEEDERS, SYSTEMS, CONTROL WIRING, MISCELLANEOUS AUXILIARY SYSTEMS, ETC., PASSING THROUGH THE AREA OF WORK SHALL BE MAINTAINED AT ALL TIMES, REMAIN IN SERVICE, CONTINUOUS AND UNINTERRUPTED. ANY DAMAGE, DISRUPTION OR DISCONNECTION SHALL BE IMMEDIATELY REPAIRED, REPLACED AND/OR REROUTED AS REQUIRED TO MAINTAIN CONTINUITY OF SYSTEMS. ANY EXISTING SERVICE OR OPERATING SYSTEM WHICH MUST BE INTERRUPTED SHALL BE SUPPLIED WITH A TEMPORARY SERVICE FOR CONTINUATION OF THE NORMAL OPERATIONS OF THE FACILITY.
8. ANY EQUIPMENT THAT REQUIRES REMOVAL FROM EXISTING LOCATION FOR RE-USE OR TO BE RETURNED TO OWNER SHALL BE INSPECTED AND TESTED TO CONFIRM EQUIPMENT OPERATES AS INTENDED. OWNER SHALL BE NOTIFIED OF ANY EQUIPMENT THAT DOES NOT OPERATE AS INTENDED BEFORE REMOVAL.
9. CONCEALED CONDUIT THAT CANNOT BE REMOVED DUE TO INACCESSIBILITY MAY BE ABANDONED. CONDUCTORS SHALL BE REMOVED AND CONDUIT CUT FLUSH WITH SURFACE. INSTALL PLUG 6" INTO CONDUIT AND FILL REMAINING CONDUIT WITH CONCRETE, GROUT, OR OTHER PERMANENT FILLER FLUSH WITH SURFACE.
10. OUTLET BOXES THAT CANNOT BE REMOVED DUE TO FLUSH MOUNTING IN PARTITIONS SHALL BE FILLED WITH GROUT, PATCHED AND FINISHED FLUSH TO MATCH EXISTING WALL CONDITIONS.
11. IN GENERAL, THE WORK SHALL INCLUDE BUT NOT BE LIMITED TO THE FOLLOWING:
 - a. PROVIDE ALL DEMOLITION AS REQUIRED OF EXISTING SYSTEMS REMOVING ALL ITEMS THAT CONFLICT WITH FINISHED DESIGN INTENT AS INDICATED ABOVE.
 - b. MODIFY, REPLACE, REPAIR, REVISE ETC., EXISTING SYSTEMS AND/OR EQUIPMENT.
 - c. EXTEND EXISTING SYSTEMS AS REQUIRED TO FUNCTION AS SPECIFIED AND IN ACCORDANCE WITH SYSTEM REQUIREMENTS.
 - d. NEW SYSTEM COMPONENTS SHALL MATCH EXISTING SYSTEMS PROVISIONS AND BE COMPLETELY COMPATIBLE AND IN ACCORDANCE WITH THE MANUFACTURER'S REQUIREMENTS. WHEN REQUIRED, APPROVAL FROM A SYSTEM MANUFACTURER SHALL BE OBTAINED BY THE CONTRACTOR PRIOR TO INSTALLING ANY NEW EQUIPMENT OR DEVICES TO AN EXISTING SYSTEM.
 - e. ALL EQUIPMENT, DEVICES, OUTLETS, COMPONENTS, ETC., TO BE REUSED SHALL BE CLEANED, REPAIRED AND PLACED IN OPERATING CONDITION. LUMINARIES NOTED TO BE REUSED SHALL BE CLEANED, REPAIRED, PROVIDED WITH NEW LAMPS AND PLACED IN OPERATING CONDITION.
 - f. EXISTING OUTLET BOXES MAY BE USED AS NOTED IF OF THE PROPER CONFIGURATION AND SIZE REQUIRED. MODIFICATIONS SHALL BE MADE WHEN REQUIRED SUCH AS PROVIDING EXTENSION RINGS, LOCKNUTS, BUSHINGS, ETC.
 - g. EXISTING PANELBOARDS SHALL BE UTILIZED TO THE EXTENT SHOWN ON THE DRAWINGS AND MODIFIED AS REQUIRED TO FACILITATE THE NEW REQUIREMENTS AS INDICATED HEREIN OR SHOWN ON THE DRAWINGS. NEW CIRCUIT BREAKERS SHALL BE OF THE SAME MANUFACTURER, FRAME SIZE, SHORT CIRCUIT RATING AND TYPE AS EXISTING. WHERE APPLICABLE, THE CONTRACTOR SHALL BE REQUIRED TO FURNISH AND INSTALL ADDITIONAL MOUNTING HARDWARE AS REQUIRED BY THE MANUFACTURER.
 - h. WHEN EXISTING DEVICES, SWITCHES, EQUIPMENT ETC., ARE NOTED TO BE REMOVED AND THE CIRCUIT(S) SERVING SUCH ITEMS SERVES OTHER ITEMS OR DEVICES WHICH ARE TO BE MAINTAINED, THE CONTRACTOR SHALL REROUTE, EXTEND, MODIFY, ETC., EXISTING CIRCUITS AS REQUIRED TO MAINTAIN COMPLETE AND OPERATING SYSTEMS.

ELECTRICAL GENERAL NOTES

- A. CONTRACTOR SHALL COORDINATE ALL WORK WITH OTHER TRADES PRIOR TO INSTALLATION. REFER TO MECHANICAL AND PLUMBING DRAWINGS FOR EXACT SIZE AND LOCATION OF EQUIPMENT WHICH IS FURNISHED BY OTHERS AND CONNECTED BY ELECTRICAL.
- B. RECEPTACLES, SWITCHES AND COVERPLATES COLOR SHALL BE SELECTED BY THE ARCHITECT FROM STANDARD COLORS.
- C. VERIFY ALL DOOR SWINGS WITH ARCHITECTURAL DRAWINGS PRIOR TO ROUGHING-IN WALL FOR SWITCHES.
- D. LOCATION OF LIGHTING FIXTURES, DISCONNECT SWITCHES, ETC. FOR MECHANICAL EQUIPMENT/ROOM SHALL BE COORDINATED WITH FINAL MECHANICAL EQUIPMENT LOCATION TO PROVIDE NATIONAL ELECTRIC CODE REQUIRED ACCESS SPACE.
- E. FINAL CONNECTION TO ALL MOTORS SHALL BE WITH FLEXIBLE CONDUIT CONNECTION.
- F. ALL EXIT AND EMERGENCY FIXTURES SHALL BE CONNECTED TO LIGHT CIRCUIT AHEAD OF LOCAL SWITCH.
- G. ALL PANELBOARDS, BACKBOARDS, TERMINAL CABINETS, ETC SHALL HAVE CUSTOM ENGRAVED MICARTA NAMEPLATE MECHANICALLY AFFIXED IDENTIFYING SYSTEM.
- H. PROVIDE GREEN GROUND CONDUCTOR IN ALL CIRCUITS - SIZE PER N.E.C.
- I. ALL EXPOSED CONDUITS, BOXES, STRAPS AND HANGERS IN THE CONTRACT AREA WHETHER NEW OR EXISTING THAT ARE PART OF THE ELECTRICAL SYSTEM SHALL BE PAINTED TO MATCH ADJACENT FINISH.
- J. GENERAL CONTRACTOR SHALL FIELD-VERIFY ALL EXISTING CONDITIONS PRIOR TO BEGINNING ANY WORK, AND SHALL IMMEDIATELY NOTIFY THE ARCHITECT OF ANY DISCREPANCIES. FAILURE TO DO SO INDICATES THAT THE CONTRACTOR ACCEPTS THE CONDITIONS AS THEY EXIST, AND SHALL PERFORM THE WORK REQUIRED AS SHOWN AND SPECIFIED.
- K. THE ELECTRICAL CONTRACTOR SHALL OBTAIN AND REVIEW THE MECHANICAL AND SPECIAL EQUIPMENT SUBMITTALS PRIOR TO SUBMITTING THE ELECTRICAL SUBMITTALS. ANY ELECTRICAL EQUIPMENT, CONDUIT, AND WIRE SIZE CHANGES RESULTING FROM THIS REVIEW SHALL ALSO BE SUBMITTED FOR APPROVAL.
- L. THE ELECTRICAL CONTRACTOR SHALL PROVIDE FAULT CURRENT CALCULATIONS FOR THE SERVICE EQUIPMENT AND SHALL MARK THE EQUIPMENT WITH THE AVAILABLE FAULT CURRENT AND DATE OF THE CALCULATION PER NEC 110.24. REFER TO TYPICAL SERVICE EQUIPMENT FAULT CURRENT LABEL DETAIL.
- M. THE ELECTRICAL CONTRACTOR SHALL PROVIDE ARC FAULT LABELS PER NFPA 70E ARTICLE 110.16 FOR NEW EQUIPMENT. THE OWNER SHALL PROVIDE AVAILABLE CALCULATION DATA FOR THE EXISTING EQUIPMENT IN THE ELECTRICAL SYSTEM. REFER TO TYPICAL ARC FLASH HAZARD LABEL DETAIL.
- N. PROVIDE NEUTRAL AT ALL LINE VOLTAGE SWITCH LOCATIONS PER N.E.C. 404.2(C).
- O. PROVIDE 'LSI' TRIP UNITS FOR ALL BREAKERS GREATER THAN OR EQUAL TO 200A.
- P. PROVIDE BUSHINGS ON ALL CONDUIT.
- Q. COMPLY WITH ALL LOCAL CODE, LAWS, AND ORDINANCES APPLICABLE TO ELECTRICAL WORK, THE STATE BUILDING CODE AND THE NATIONAL ELECTRIC CODE. OBTAIN ALL PERMITS REQUIRED BY LOCAL ORDINANCES.
- R. OBTAIN ARCHITECTS APPROVAL OF ALL LIGHT FIXTURES, SWITCHES, RECEPTACLES, PANELBOARDS, ETC. PRIOR TO PURCHASING.
- S. THE ELECTRICAL WORK SHALL BE INSTALLED IN A NEAT AND WORKMANLIKE MANNER. ALL NOT SO INSTALLED SHALL BE REMOVED AND REPLACED AT NO COST TO THE OWNER.
- T. ALL WORK SHALL BE INSTALLED IN CONCEALED TYPE CONSTRUCTION. UNDERGROUND CONDUITS UP TO FIRST BOX IN CONCEALED CONSTRUCTION MAY BE SCH 40 PVC, EXTERIOR EXPOSED WORK SHALL BE I.M.C. BRANCH CIRCUIT CONDUIT RUN IN OPEN SPACES ABOVE CEILING OR IN WALLS MAY BE THINWALL (E.M.T.) CONDUIT 1/2" MIN. SIZE.
- U. ALL CONDUCTORS LESS THAN 100A. SHALL BE COPPER #12 & #10 SOLID, #8 AND LARGER STRANDED, #6 AND SMALLER TO BE TYPE THWN, 600 VOLT INSULATION AND TYPE THWN OR THHN FOR #4 AND LARGER. ALUM. CONDUCTORS MAY BE USED FOR 100A. AND LARGER ONLY WHERE USED WITH COMPRESSION TERMINATIONS.
- V. PROVIDE GROUNDING PER NATIONAL ELECTRIC CODE.
- W. THE CONTRACTOR SHALL LEAVE THE ENTIRE ELECTRICAL SYSTEM INSTALLED IN PROPER WORKING ORDER, AND SHALL REPLACE WITHOUT ADDITIONAL COST, ALL WORK OR MATERIAL WHICH MAY DEVELOP DEFECTS, (ORDINARY WEAR AND TEAR OR DAMAGE RESULTING FROM IMPROPER HANDLING EXCEPTED) WITHIN A PERIOD OF ONE (1) YEAR FROM THE DATE OF FINAL ACCEPTANCE BY THE OWNER.

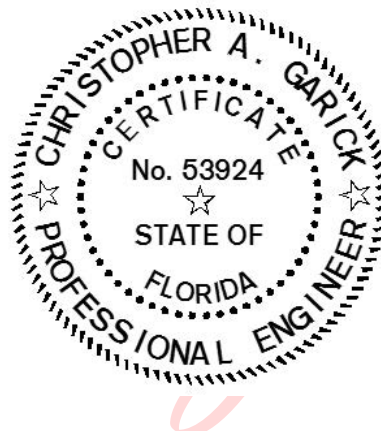

Digitally signed
by Christopher
A Garick
Date:
2026.09.02
12:08:38 -05'00'



HG Engineers
142 Eglin Parkway SE
Fort Walton Beach, Florida, 32548
E-mail: office@hgengineers.com
Ph: 850.243.6723
FL Authorization No.00006680

Christopher A. Garick, FL PE No.53924
Thomas A. Alexander, FL PE No.73172
Daniel J. White, FL PE No.73790
Caleb W. Leonard, FL PE No.91782


25024
Job No.

LEGEND AND NOTES

E1.00

Step One Automotive Group
CDJR Renovation

541 MARY ESTHER CUT-OFF NW
FOR WALTON BEACH, FLORIDA

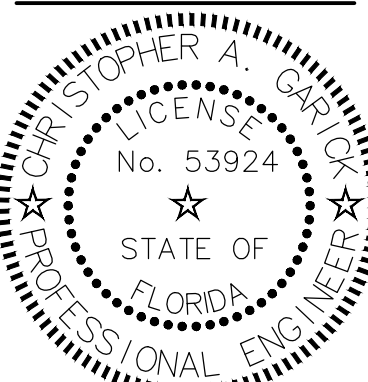


DATE: JUL 16, 2026	DRAWN BY: R.ENGLE / C.PASTORIUS	PROJECT NO: 2519	REVISIONS:						

SCHEMATIC REVIEW

16 JUL 2026 FOR PERMIT

These plans and the ideas and concepts contained herein including digital information are the property of Jdf architecture and are not to be reproduced, copied, modified, or changed in any form or manner without the express written permission and consent of Jdf architecture. copyright © 2026.

jdf+
architecture llc
201 hollywood blvd ne | ft. walton beach | florida | 32548
850.496.2166 | www.jdfarchitecture.com | 4A06002602

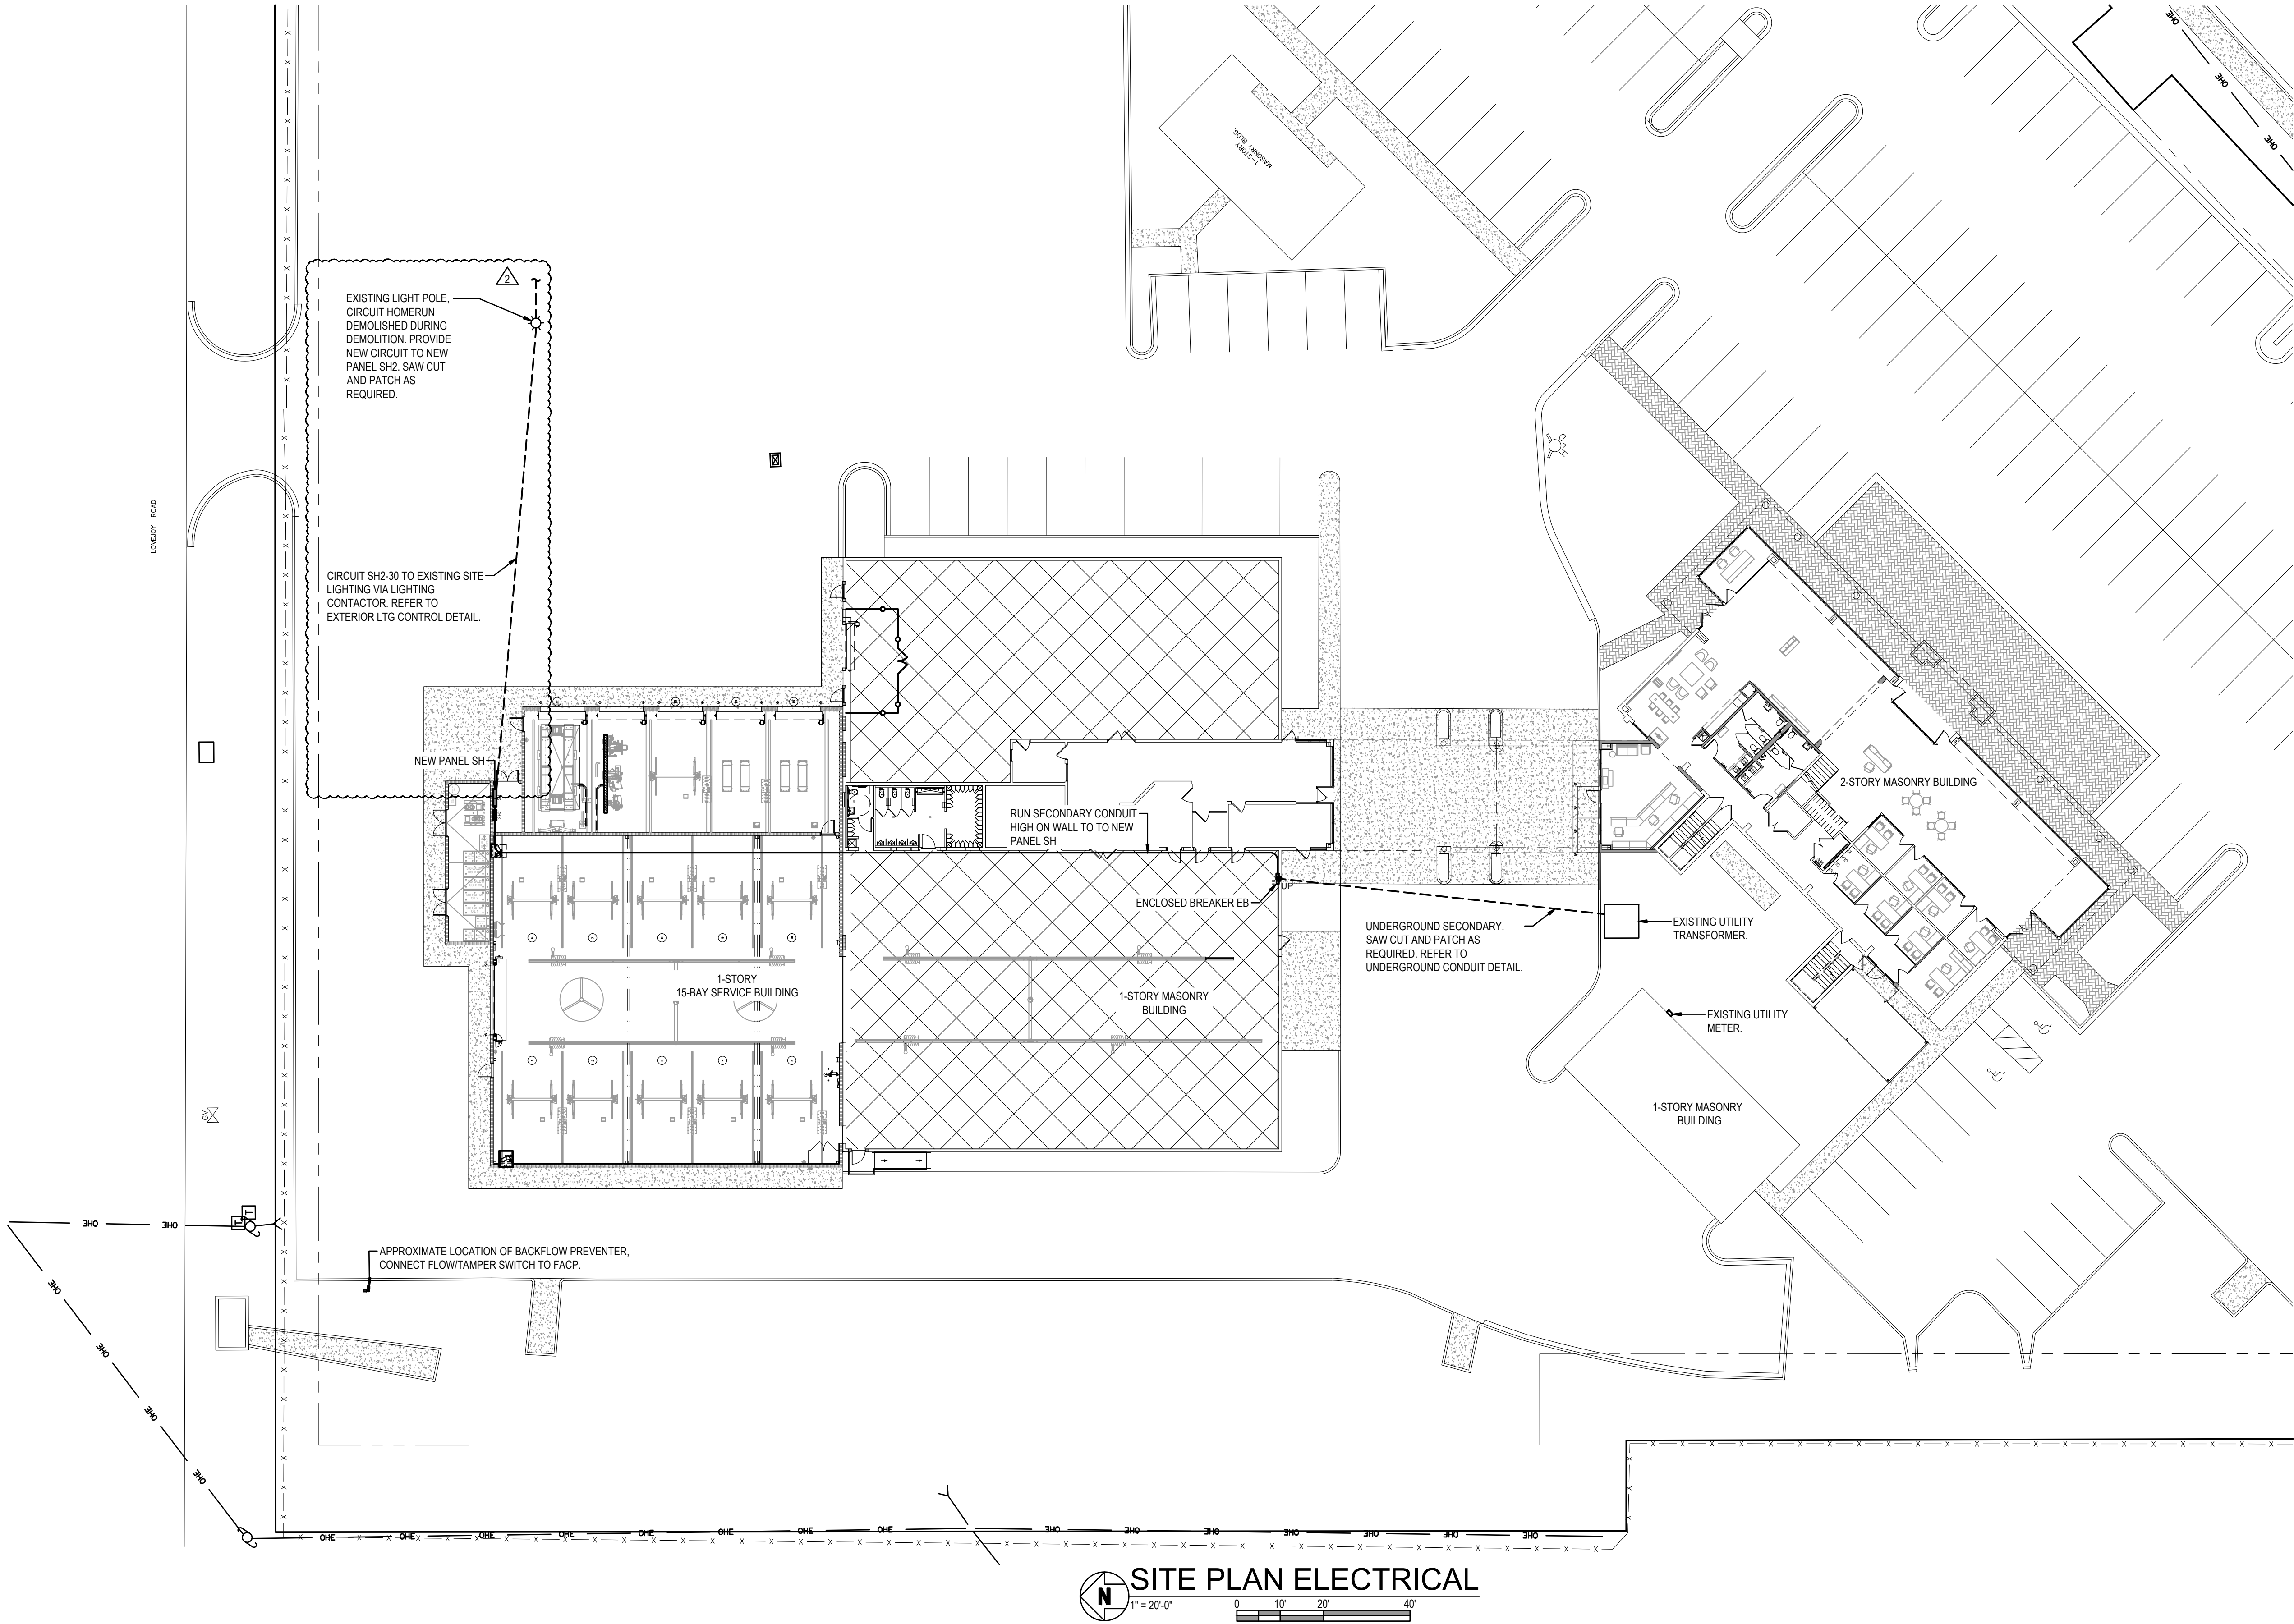

SITE PLAN ELECTRICAL
1" = 20'-0"




HG Engineers
142 Egin Parkway SE
Fort Walton Beach, Florida, 32548
E-mail: office@hgengineers.com
Ph: 850.243.6723
FL Authorization No.00006680
Christopher A. Garick, FL PE No.53924
Thomas A. Alexander, FL PE No.73172
Daniel J. White, FL PE No.73790
Caleb W. Leonard, FL PE No.91782

25024
Job No.

16 JUL 2026 FOR PERMIT

SITE PLAN ELECTRICAL

E2.00

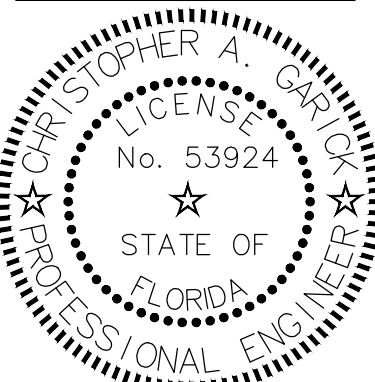


**Step One Automotive Group
CDJR Renovation**

541 MARY ESTHER CUT-OFF NW
FOR WALTON BEACH, FLORIDA

jdf+ architecture llc
201 hollywood blvd ne | ft. walton beach | florida | 32548
850.496.2166 | www.jdfarchitecture.com | A06002502

These plans and the ideas and concepts contained herein including digital information are the property of jdf architecture and are not to be reproduced, copied, modified, or changed in any form or manner without the express written permission and consent of jdf architecture. copyright © 2026.

C:\PASTORIUS - 10:39 AM - E3.00 SALES BLDG. FLOOR PLAN - ELECTRICAL.dwg

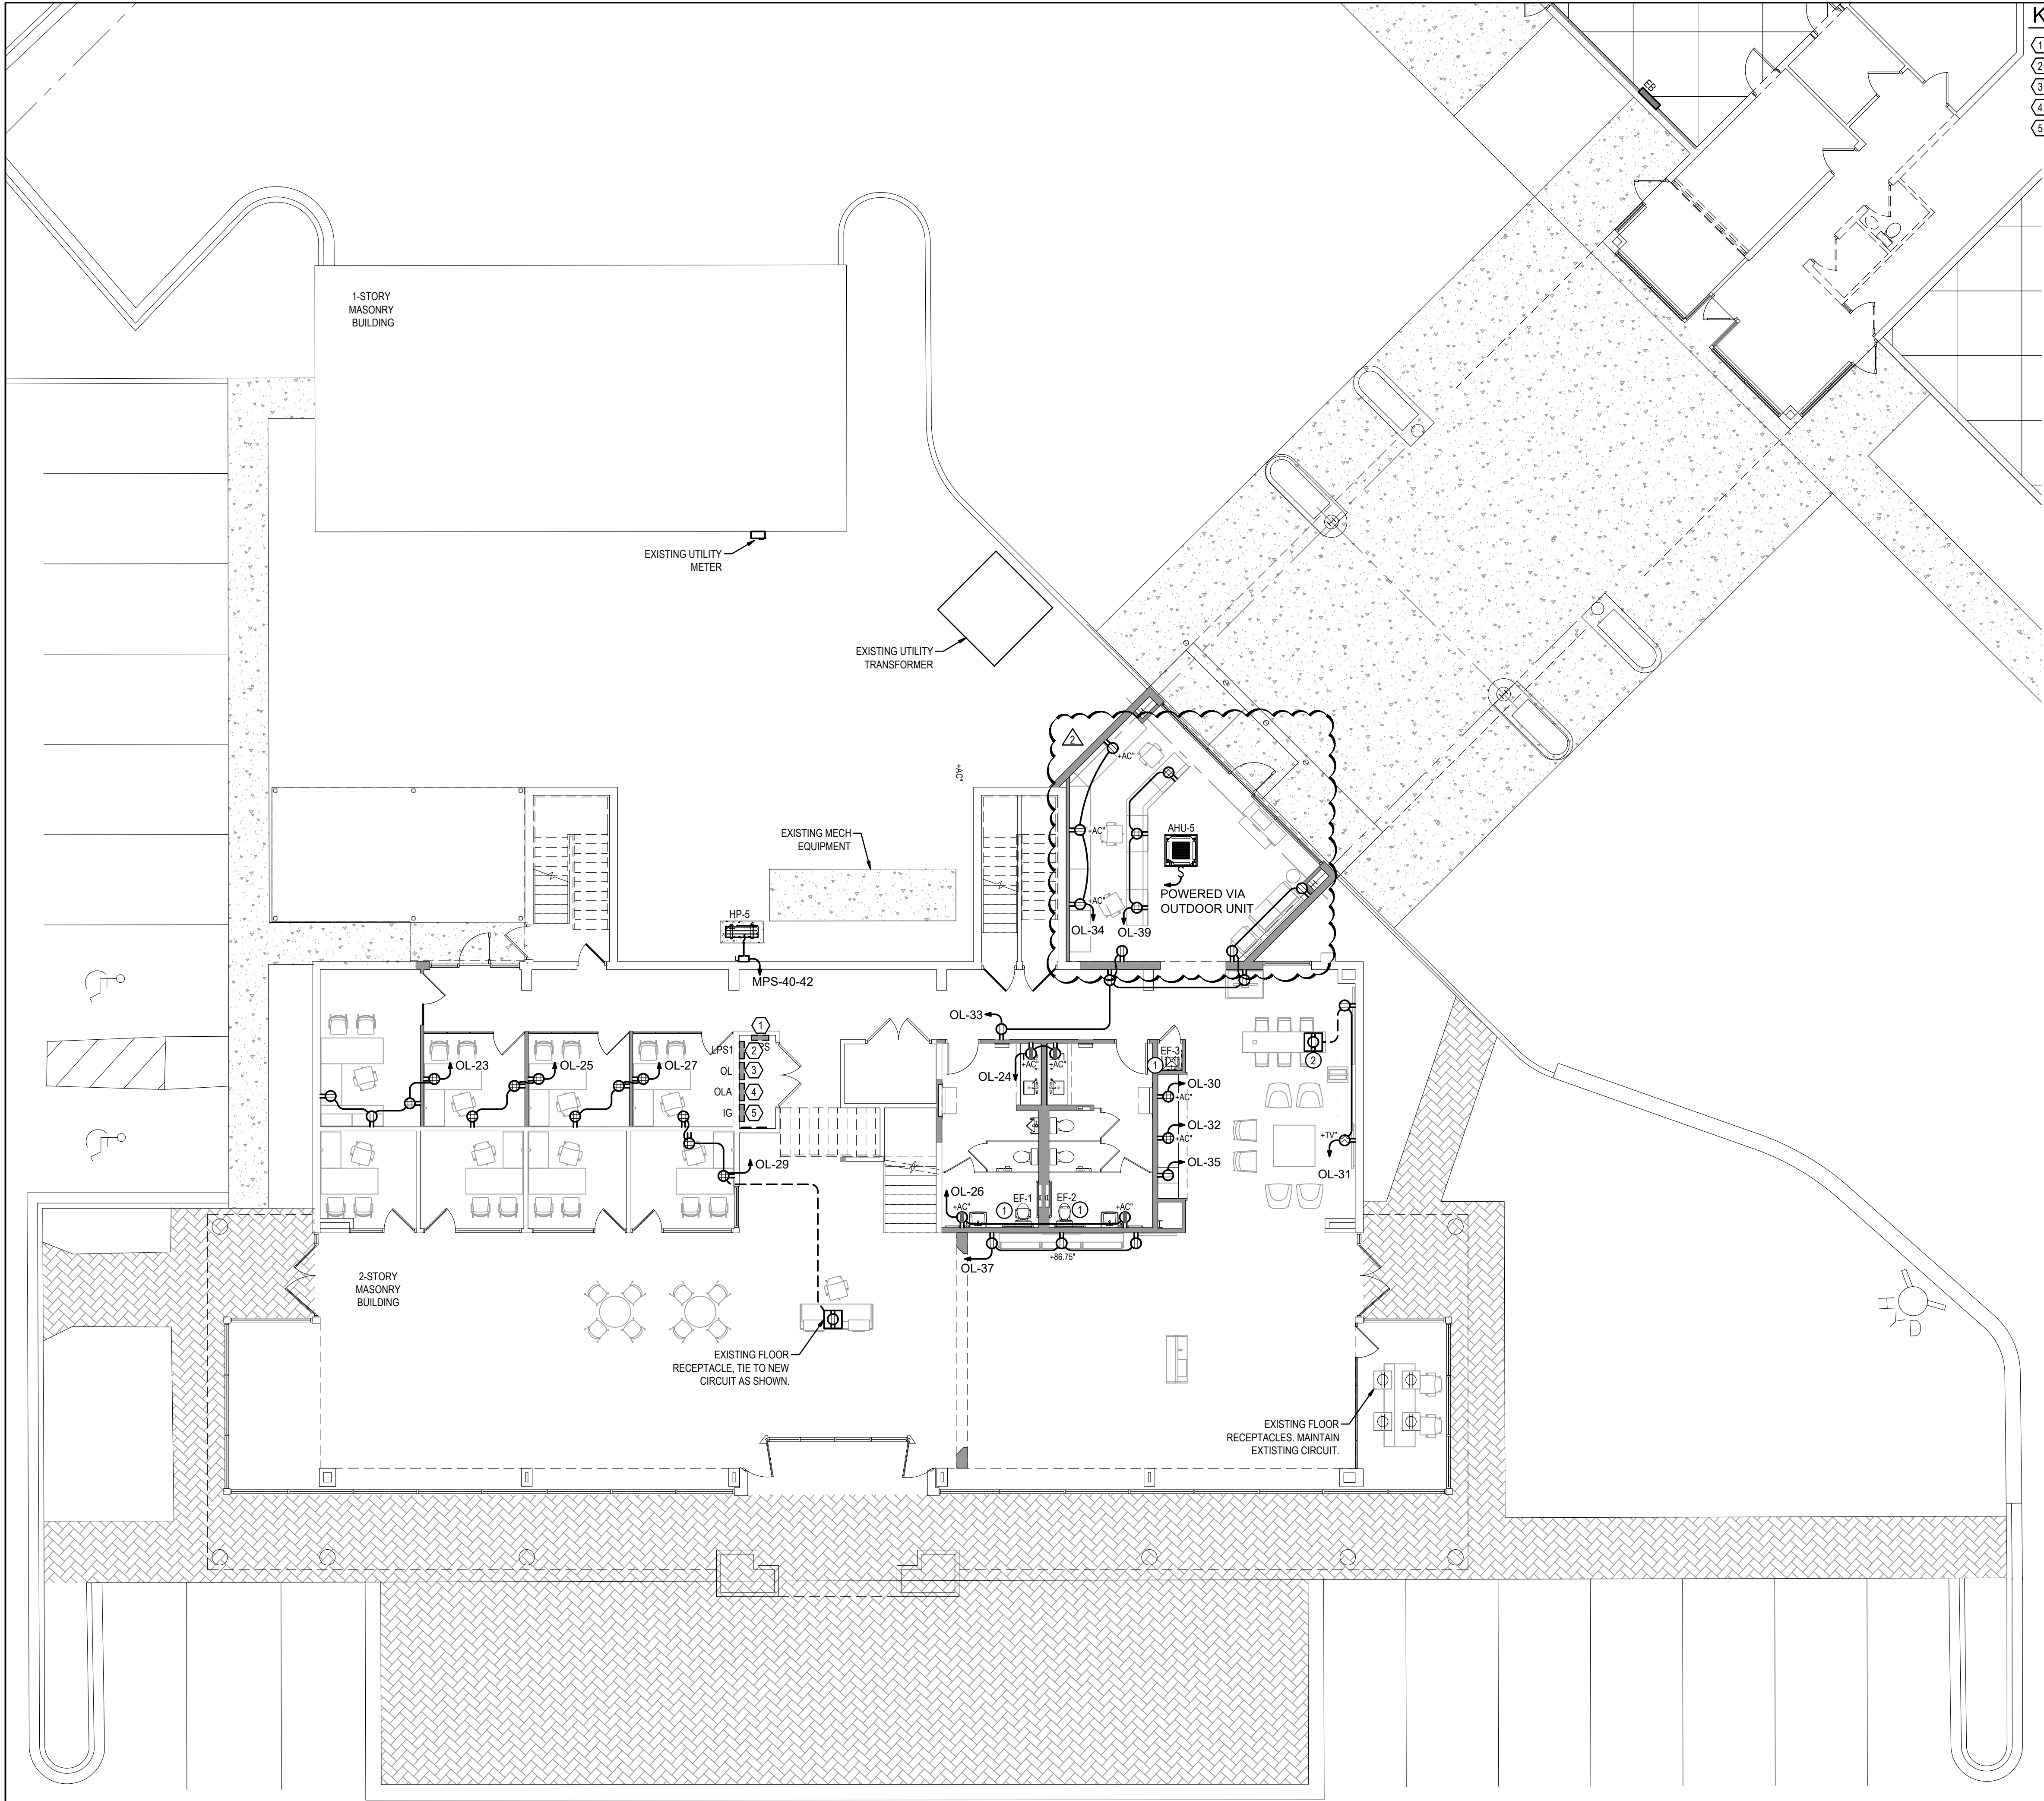

KEYNOTES

- 1 EX. PANEL-MPS
- 2 EX. PANEL-LPS1
- 3 EX. PANEL-OL
- 4 EX. PANEL-OLA
- 5 EX. PANEL-IG

 
NOTES:

- 1 REFER TO LIGHTING PLANS FOR EXHAUST FAN CONNECTION.
- 2 INSTALL NEW FLOOR BOX FOR CONNECTION TO "TECH BAR". COORDINATE LOCATION WITH OWNER PRIOR TO ROUGHING IN FRO LOCATION. SAW,CUT AND PATCH EXISTING FLOOR AND CONNECT TO NEAREST RECEPTACLE AS INDICATED.



SALES BLDG. FLOOR PLAN - ELECTRICAL

1/8" = 1'-0"



HG Engineers
142 Eglon Parkway SE
Fort Walton Beach, Florida, 32548
E-mail: office@hgenr.com
Ph: 850.243.0733
FL Authorization No.00006680
Christopher A. Garick, FL PE No.53924
Thomas A. Alexander, FL PE No.73172
Daniel J. White, FL PE No.73790
Caleb W. Leonard, FL PE No.91782

25024

Job No.


16 JUL 2026 FOR PERMIT

SALES BLDG. FLOOR
PLAN - ELECTRICAL

E3.00

Step One Automotive Group
CDJR Renovation

541 MARY ESTHER CUT-OFF NW
FOR WALTON BEACH, FLORIDA

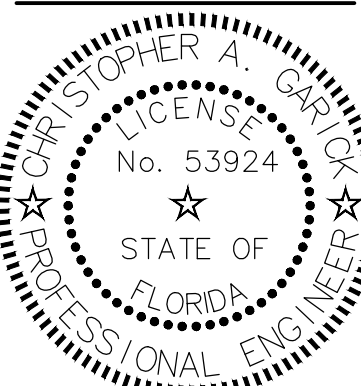


DATE:	JUL 16, 2026
DRAWN BY:	RENGLE / C.PASTORIUS
PROJECT NO:	2519
REVISIONS:	
Δ	2026-07-27
Δ	2026-08-21
SCHEMATIC REVIEW	

These plans and the ideas and concepts contained herein including digital information are the property of jdf architecture and are not to be reproduced, copied, modified, or changed in any form or manner without the express written permission and consent of jdf architecture. copyright © 2026.

jdf+
architecture
llc

201 hollywood blvd ne | ft. walton beach | florida | 32548
850.496.2166 | www.jdfarchitecture.com | #JDF002502

C:\PASTORIUS - 10:39 AM - E3.01 SALES BLDG. FLOOR PLAN - LIGHTING.dwg

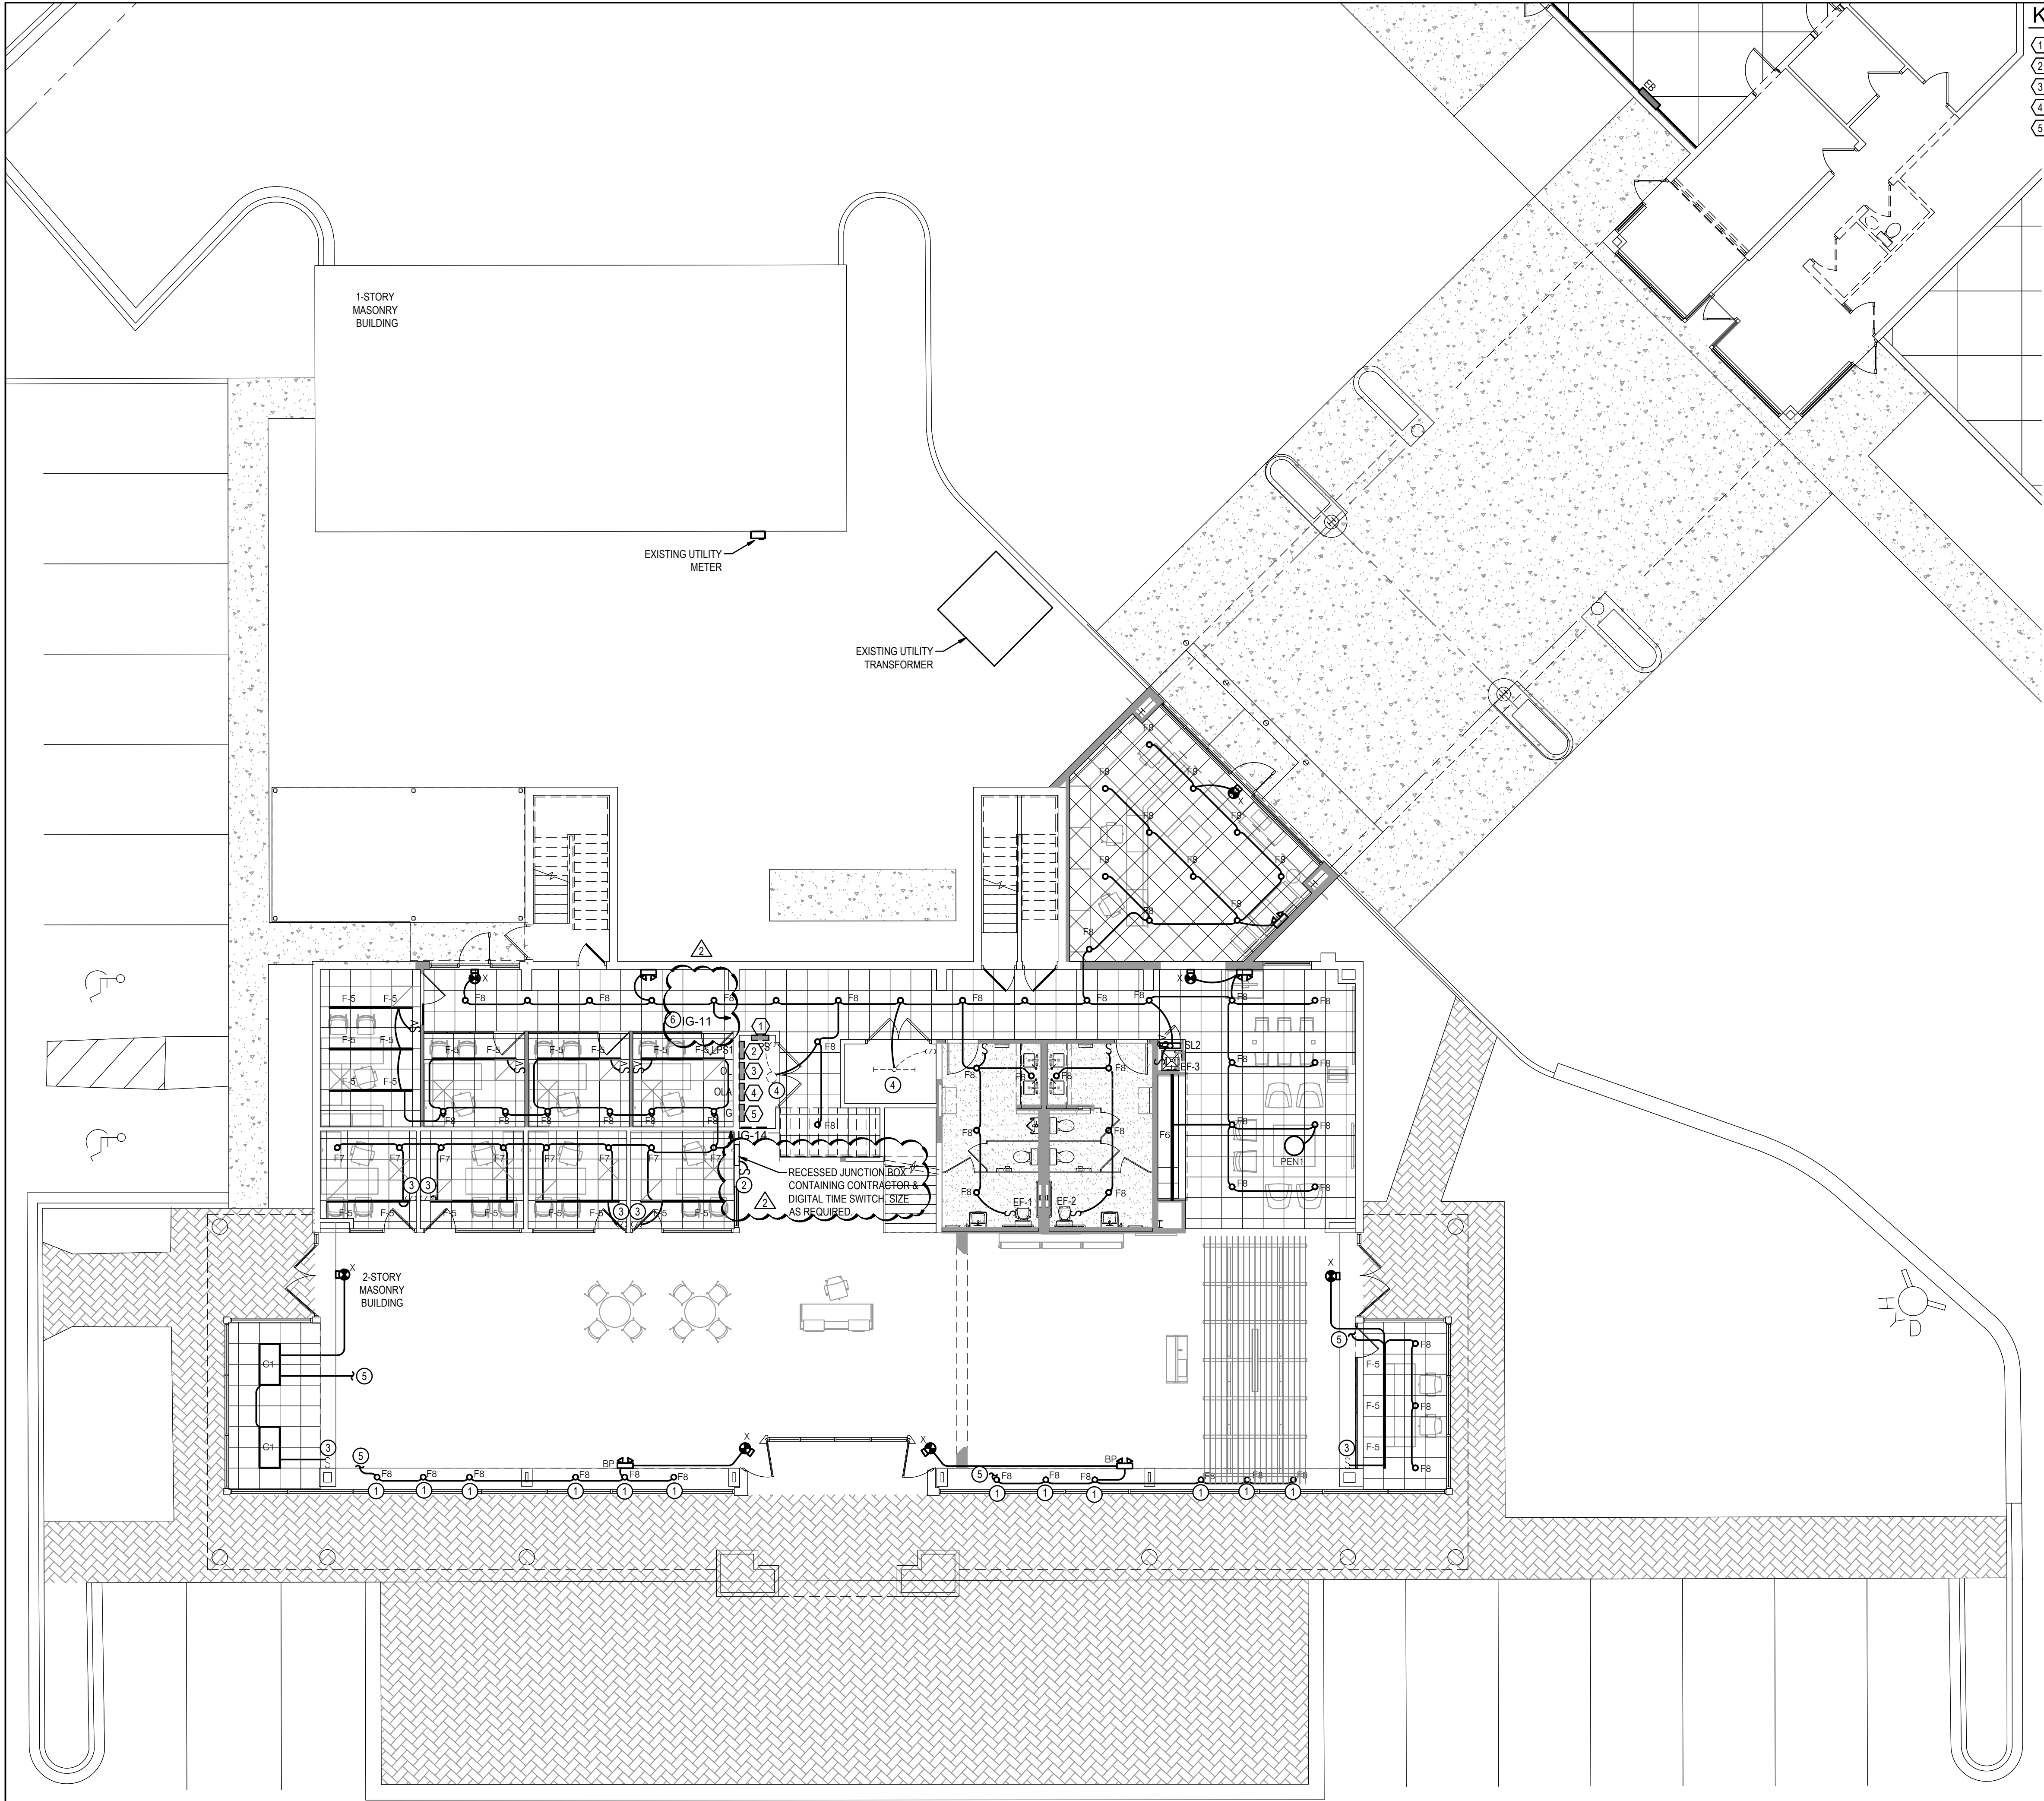

KEYNOTES

- 1 EX. PANEL-MPS
- 2 EX. PANEL-LPS1
- 3 EX. PANEL-OL
- 4 EX. PANEL-OLA
- 5 EX. PANEL-IG

 
NOTES:

- 1 DOWNLIGHTS TO BE REPLACED ARE LOCATED IN SOFFIT AT 8' AFG. PROVIDE GOOF RING.
- 2 MANUAL OVERRIDE TOGGLE SWITCH CONTROLLING ALL FIXTURES IN SALES FLOOR, CUSTOMER LOUNGE, & BACK HALLWAY. REFER TO LIGHTING CONTROL FOR THE SALES AREA.
- 3 RECONNECT NEW LIGHTS IN THIS SPACE TO SWITCH PREVIOUSLY SERVING SPACE.
- 4 EXISTING LIGHTING AND CONTROLS TO REMAIN. CONNECT SPACE TO NEW LIGHTING CIRCUIT AS INDICATED.
- 5 EXTEND TO LIGHTING CIRCUIT ABOVE. REFER TO 2ND FLOOR LIGHTING PLAN.
- 6 LIGHTING CIRCUIT TO LAND ON CONTACTOR BEFORE CONTINUING TO PANEL.



SALES BLDG. FLOOR PLAN - LIGHTING

1/8" = 1'-0"



HG Engineers
142 Egin Parkway SE
Fort Walton Beach, Florida, 32548
E-mail: office@hgengineers.com
Ph: 850.243.0723
FL Authorization No.00006680
Christopher A. Canick, FL PE No.53924
Thomas A. Alexander, FL PE No.73172
Daniel J. White, FL PE No.73790
Caleb W. Leonard, FL PE No.91782

25024

Job No.


16 JUL 2026 FOR PERMIT

SALES BLDG. FLOOR
PLAN - LIGHTING

E3.01

Step One Automotive Group
CDJR Renovation


541 MARY ESTHER CUT-OFF NW
FOR WALTON BEACH, FLORIDA

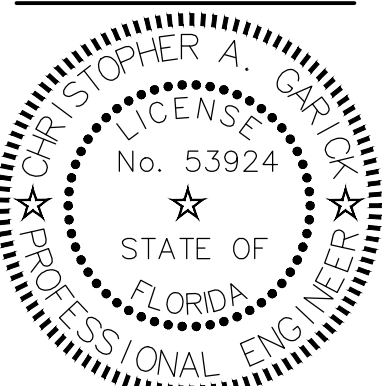

DATE:	JUL 16, 2026
DRAWN BY:	RENGLE / C.PASTORIUS
PROJECT NO:	2519
REVISIONS:	
Δ	2025-07-27
Δ	2026-08-21
SCHEMATIC REVIEW	

These plans and the ideas and concepts contained herein building, design information are the property of jdf architecture and are not to be reproduced, copied, modified, or changed in any form or manner without the express written permission and consent of jdf architecture. copyright © 2026.

jdf+
architecture llc
201 hollywood blvd ne | ft. walton beach | florida | 32548
850.496.2166 | www.jdfarchitecture.com | A06002502

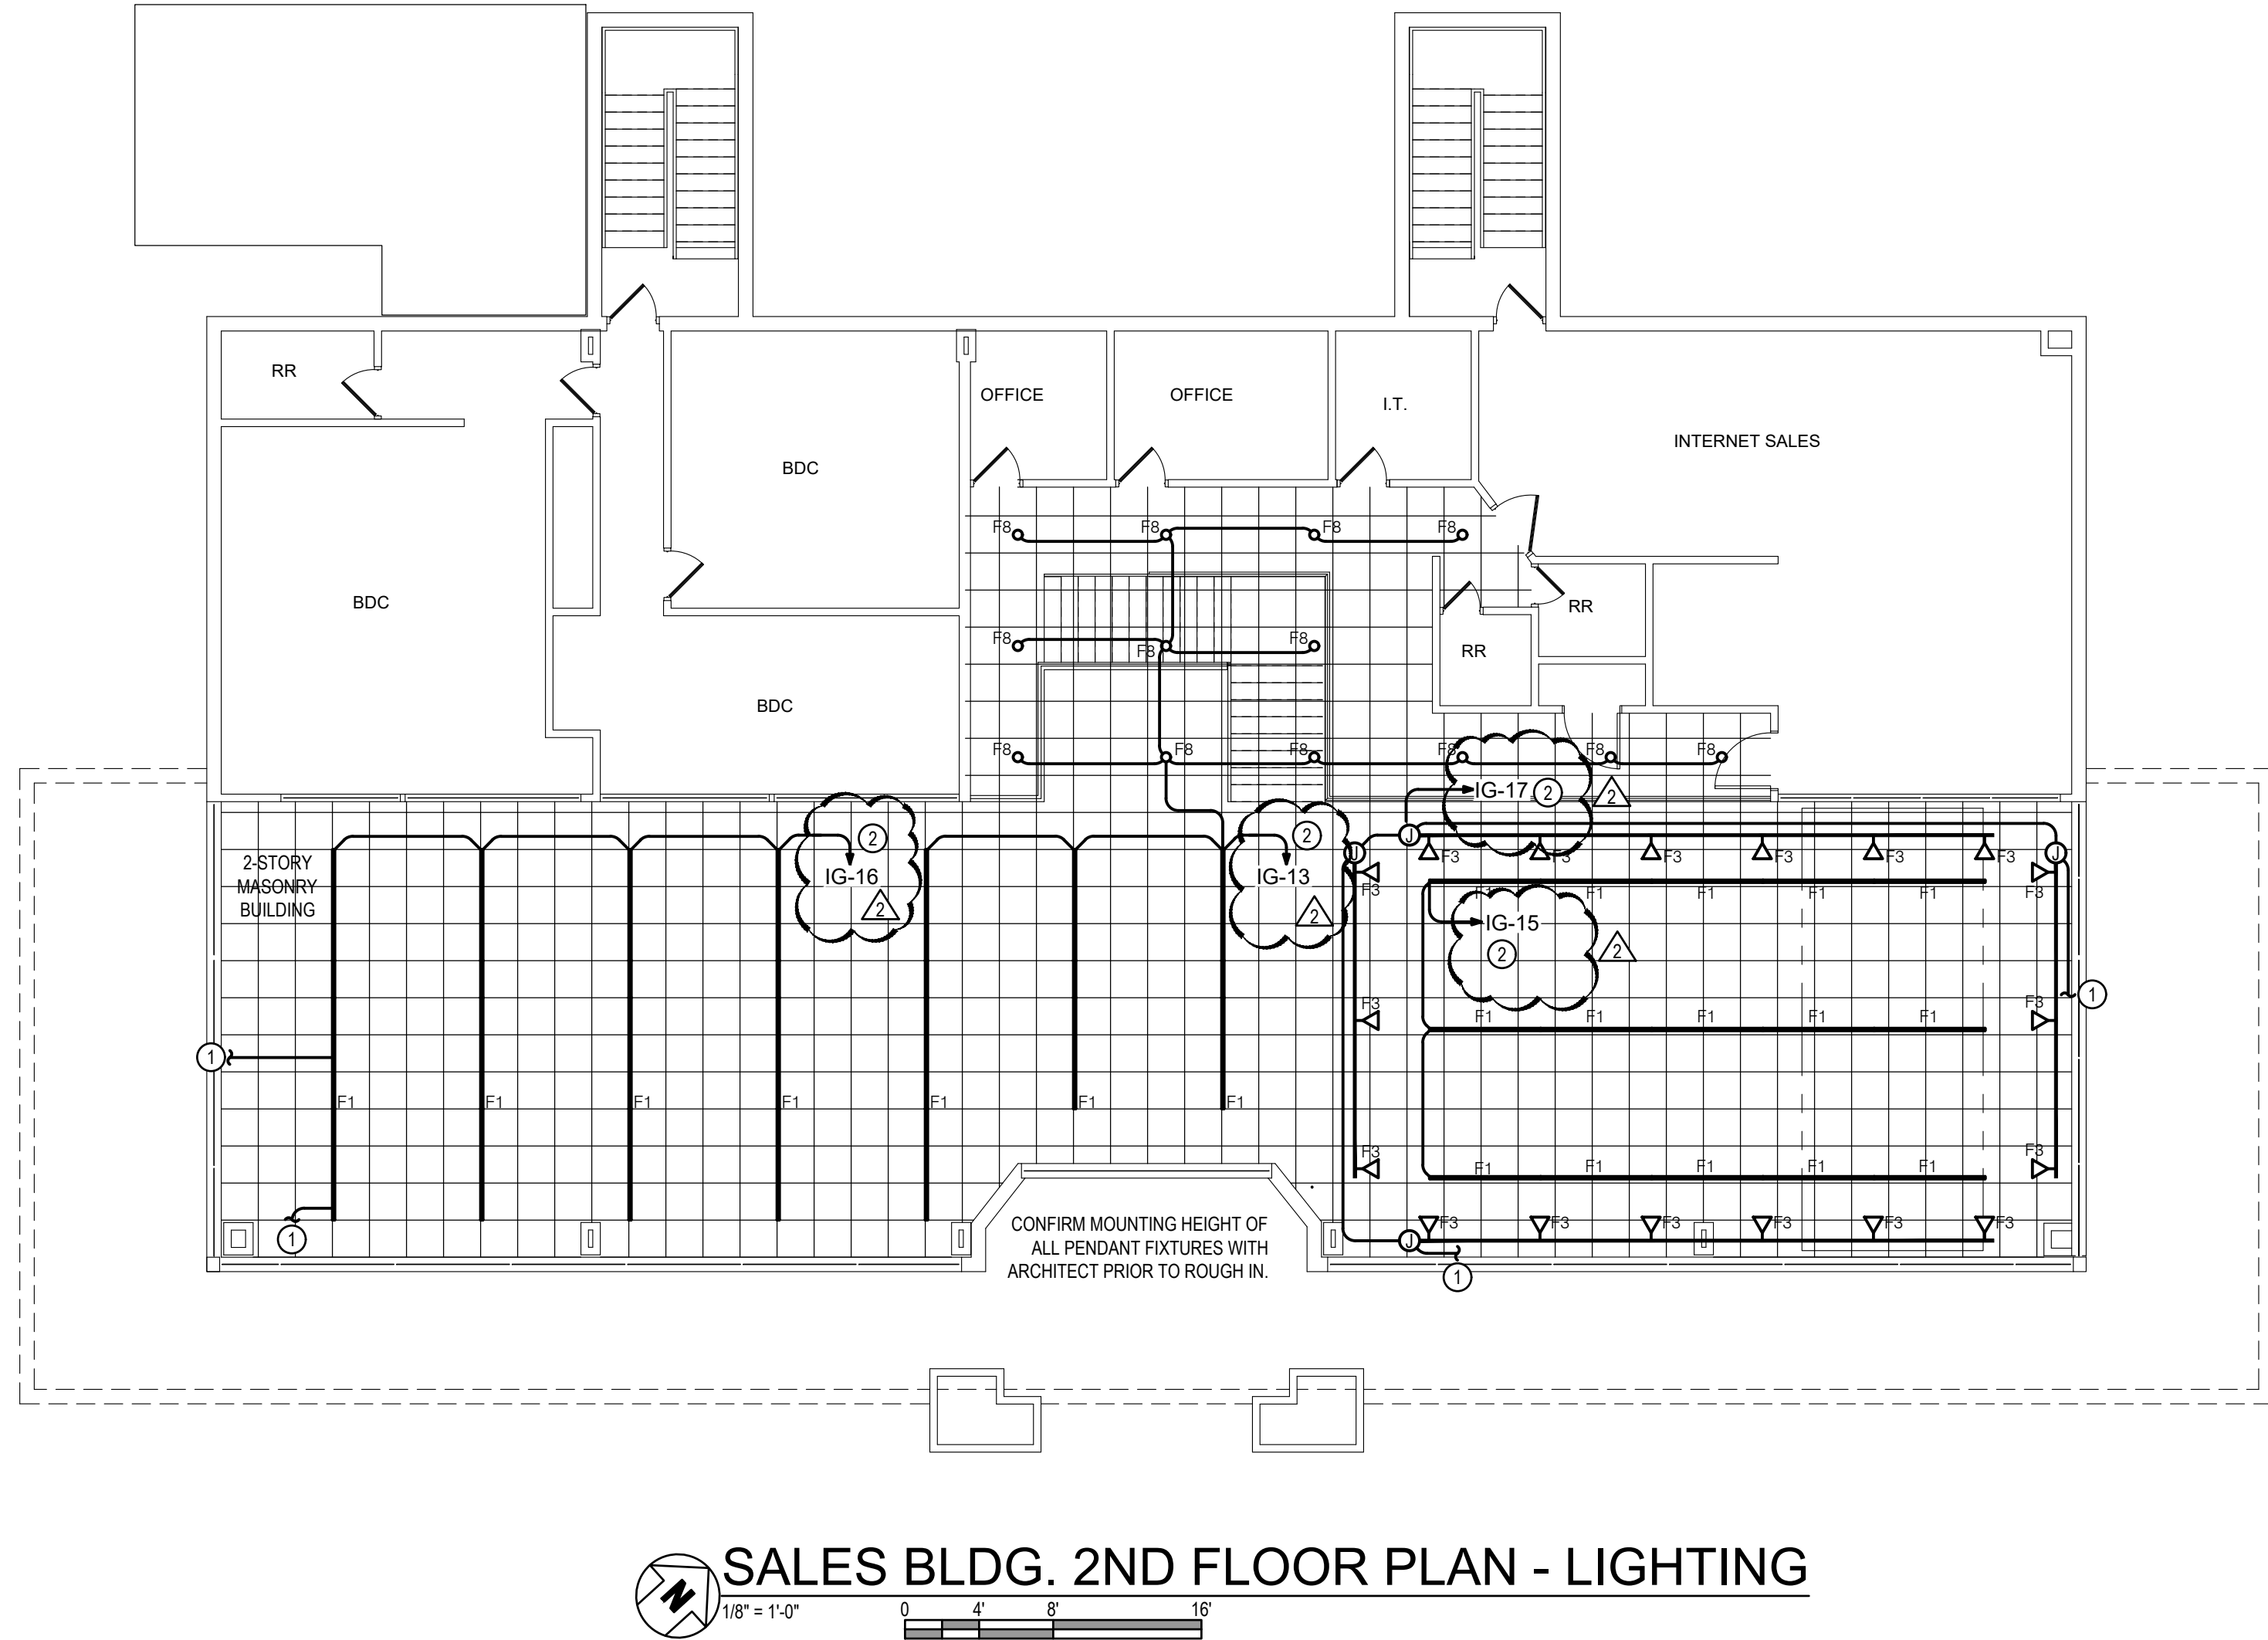

- NOTES:
- ① EXTEND TO LIGHTING CIRCUIT BELOW. REFER TO 1ST FLOOR LIGHTING PLAN.
 - ② LIGHTING CIRCUIT TO LAND ON CONTACTOR BEFORE CONTINUING TO PANEL.




HG Engineers
142 Egin Parkway SE
Fort Walton Beach, Florida, 32548
E-mail: office@hgengineers.com
Ph: 850.243.0723
FL Authorization No.00006680
Christopher A. Garick, FL PE No.53924
Thomas A. Alexander, FL PE No.73172
Daniel J. White, FL PE No.73790
Caleb W. Leonard, FL PE No.91782

25024
Job No.

16 JUL 2026 FOR PERMIT

SALES BLDG. 2ND FLOOR
PLAN - LIGHTING

E3.02

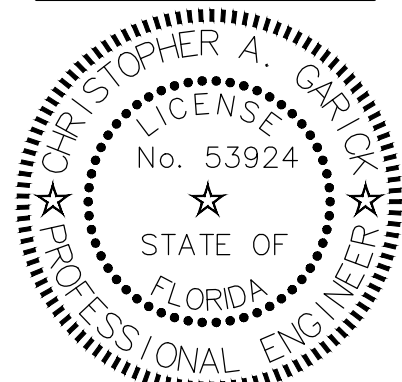

Step One Automotive Group
CDJR Renovation

541 MARY ESTHER CUT-OFF NW
FOR WALTON BEACH, FLORIDA

jdf+
architecture llc

201 hollywood blvd ne | ft. walton beach | florida | 32548
850.496.2166 | www.jdfarchitecture.com | A06002502

1/8" = 1'-0"

- 1 EX. PANEL-MPS
- 2 EX. PANEL-LPS
- 3 EX. PANEL-OL
- 4 EX. PANEL-OLA
- 5 EX. PANEL-IG

HG Engineers
 142 Eglin Parkway SE
 Fort Walton Beach, Florida, 32548
 E-mail: office@hgeengineers.com
 Ph: 850.243.6723
 Fl. Authorization No.00006680
 Christopher A. Garick; FL. PE No.53
 Thomas A. Alexander; FL. PE No.73
 Daniel J. White; FL. PE No.73790
 Caleb W. Leonard; FL. PE No.91782

25024
Job No.

SALES BLDG. FLOOR
PLAN - MISC. SYSTEMS

E3.03

Step One Automotive Group CDJR Renovation

541 MARY ESTHER CUT-OFF NW
FOR WALTON BEACH, FLORIDA


A circular professional engineer seal for Christopher A. Garlick. The outer ring contains the text "CHRISTOPHER A. GARLICK" at the top and "PROFESSIONAL ENGINEER" at the bottom, separated by two stars. The inner circle contains the text "LICENSE" at the top, "No. 53924" in the center, and "STATE OF FLORIDA" at the bottom, also separated by two stars. The seal is surrounded by a dashed border.

DATE:	JUL 16 2026	
DRAWN BY:	RENGLE / C PASTORIUS	
PROJECT NO:	2519	
REVISIONS:		
1	2026-07-27	
2	2026-08-21	

these plans and the ideas and concepts contained herein including digital information are the property of jdf architecture and are not to be reproduced, copied, modified, or changed in any form or manner without the express written permission and consent of jdf architecture. copyright © 2026

jd f+ architecture llc

201 hollywood blvd ne | ft walton beach | florida | 32548
850.496.2166 | www.jdfarchitecture.com | AA26002502

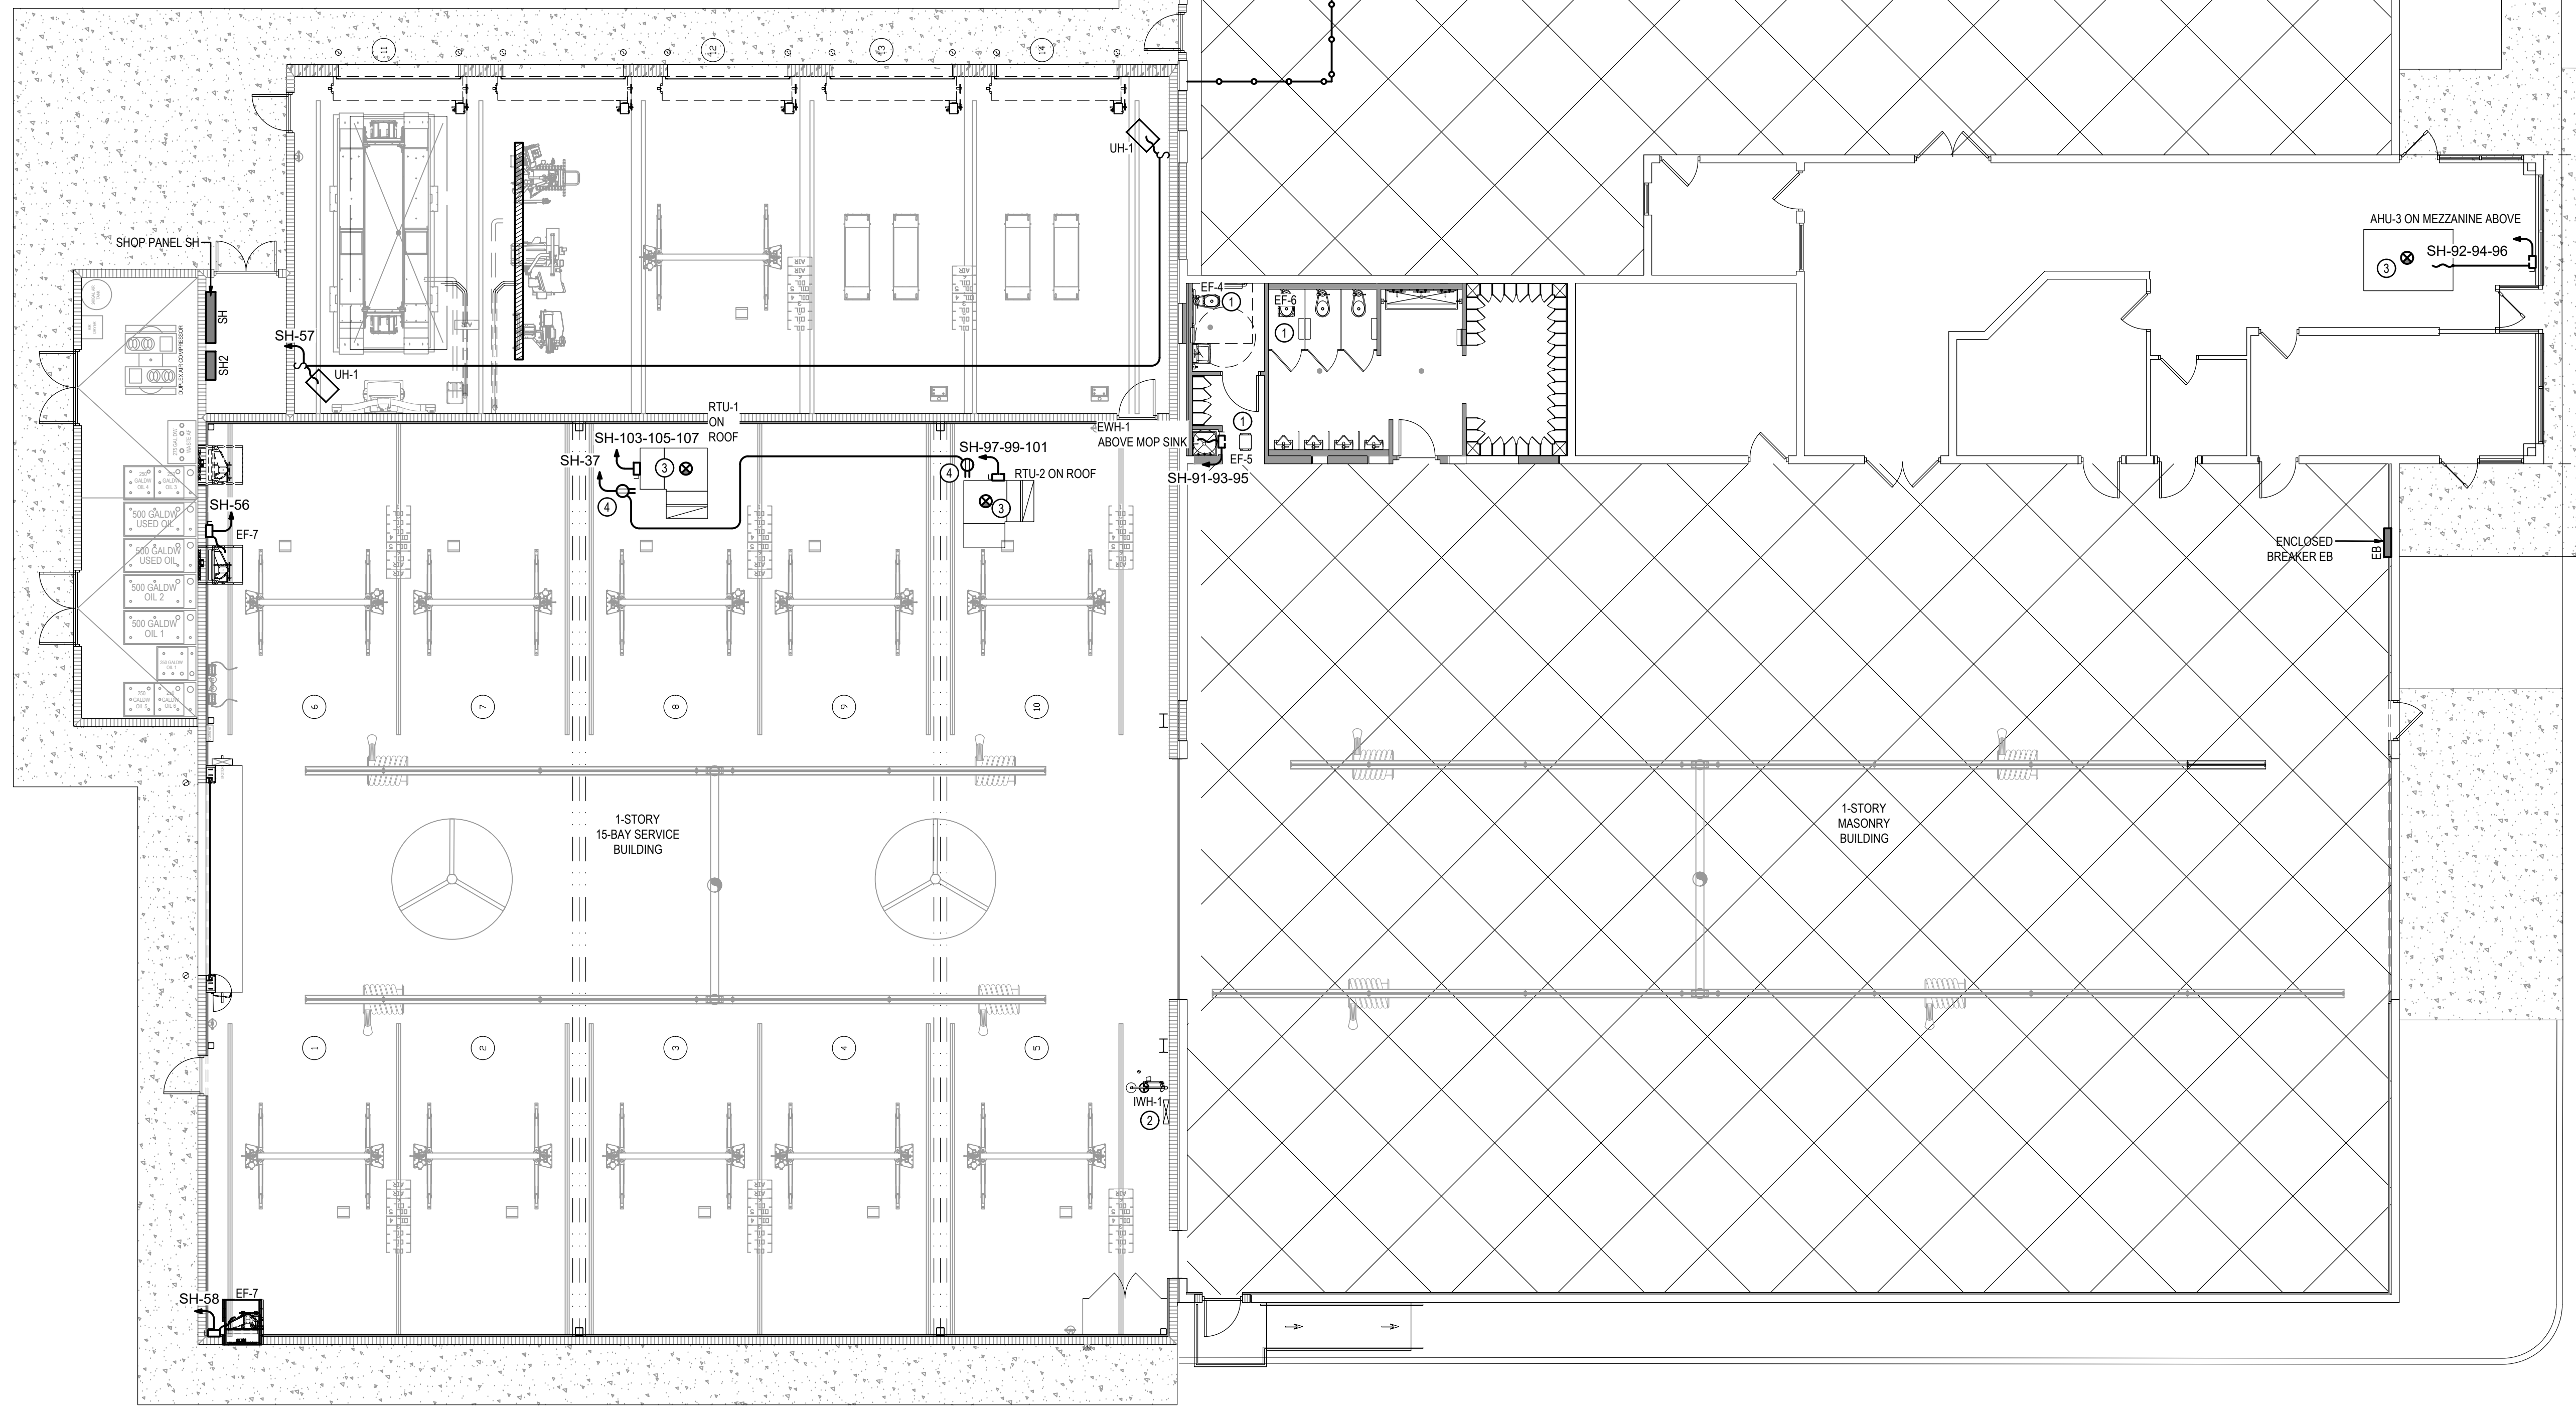

- NOTES:**
- REFER TO LIGHTING PLANS FOR EXHAUST FAN CONNECTION.
 - REFER TO ELECTRICAL FLOOR PLAN FOR IWH-1 CONNECTION.
 - PROVIDE SUPPLY SIDE SMOKE DETECTOR FOR RTU-1, RTU-2, & AHU-3, CONNECT TO FIRE ALARM CONTROL PANEL LOCATED IN NEW SHOP. DEVICE TO AUTOMATICALLY SHUT DOWN EQUIPMENT UPON ACTIVATION
 - REFER TO ROOF MOUNTED DISCONNECT SWITCH DETAIL.

these plans and the ideas and concepts contained herein, including digital information are the property of Jiff Architecture and are not to be reproduced, copied, modified, or changed in any form or manner without the express written permission and consent of Jiff Architecture. Copyright © 2026

SHOP BLDG. FLOOR
PLAN - HVAC POWER

E4.01

Step One Automotive Group CDJR Renovation

541 MARY ESTHER CUT-OFF NW
FOR WALTON BEACH, FLORIDA

A circular professional engineer seal for Christopher A. Garity. The outer ring contains the text "CHRISTOPHER A. GARTY" at the top and "PROFESSIONAL ENGINEER" at the bottom, separated by three stars. The inner circle contains the text "LICENSE No. 53924" and "STATE OF FLORIDA" with a star above the state name.

DATE:	JUL 16, 2026
DRAWN BY:	R.ENGLE / C.PASTORIUS
PROJECT NO:	2519
REVISIONS:	

SCHEMATIC REVIEW

16 JUL 2026 FOR PERMIT

25024
Job No.



HCG
ENGINEERS

HG Engineers
 142 Eglin Parkway SE
 Fort Walton Beach, Florida, 32548
 E-mail: office@hgengineers.com
 Ph: 850.243.6723
 Fl. Authorization No.00006680
 Christopher A. Garick; FL. PE No.53
 Thomas A. Alexander; FL. PE No.73
 Daniel J. White; FL. PE No.73790

25024
Job No.



these plans and the ideas and concepts contained herein including digital information are the property of jdf architecture and are not to be reproduced, copied, modified, or changed in any form or manner without the express written permission and consent of jdf architecture. copyright © 2026


A circular professional engineer seal for Christopher A. Garlick. The outer ring contains the text "CHRISTOPHER A. GARLICK" at the top and "PROFESSIONAL ENGINEER" at the bottom, separated by two stars. The inner circle contains the text "LICENSE No. 53924" at the top, a star in the center, and "STATE OF FLORIDA" at the bottom.

541 MARY ESTHER CUT-OFF NW
FOR WALTON BEACH, FLORIDA

jldf+
architecture llc
201 hollywood blvd ne | ft. walton beach | florida | 32548
850.495.2166 | www.jldfarchitecture.com | A426002502

E4.02

25024 Job No.

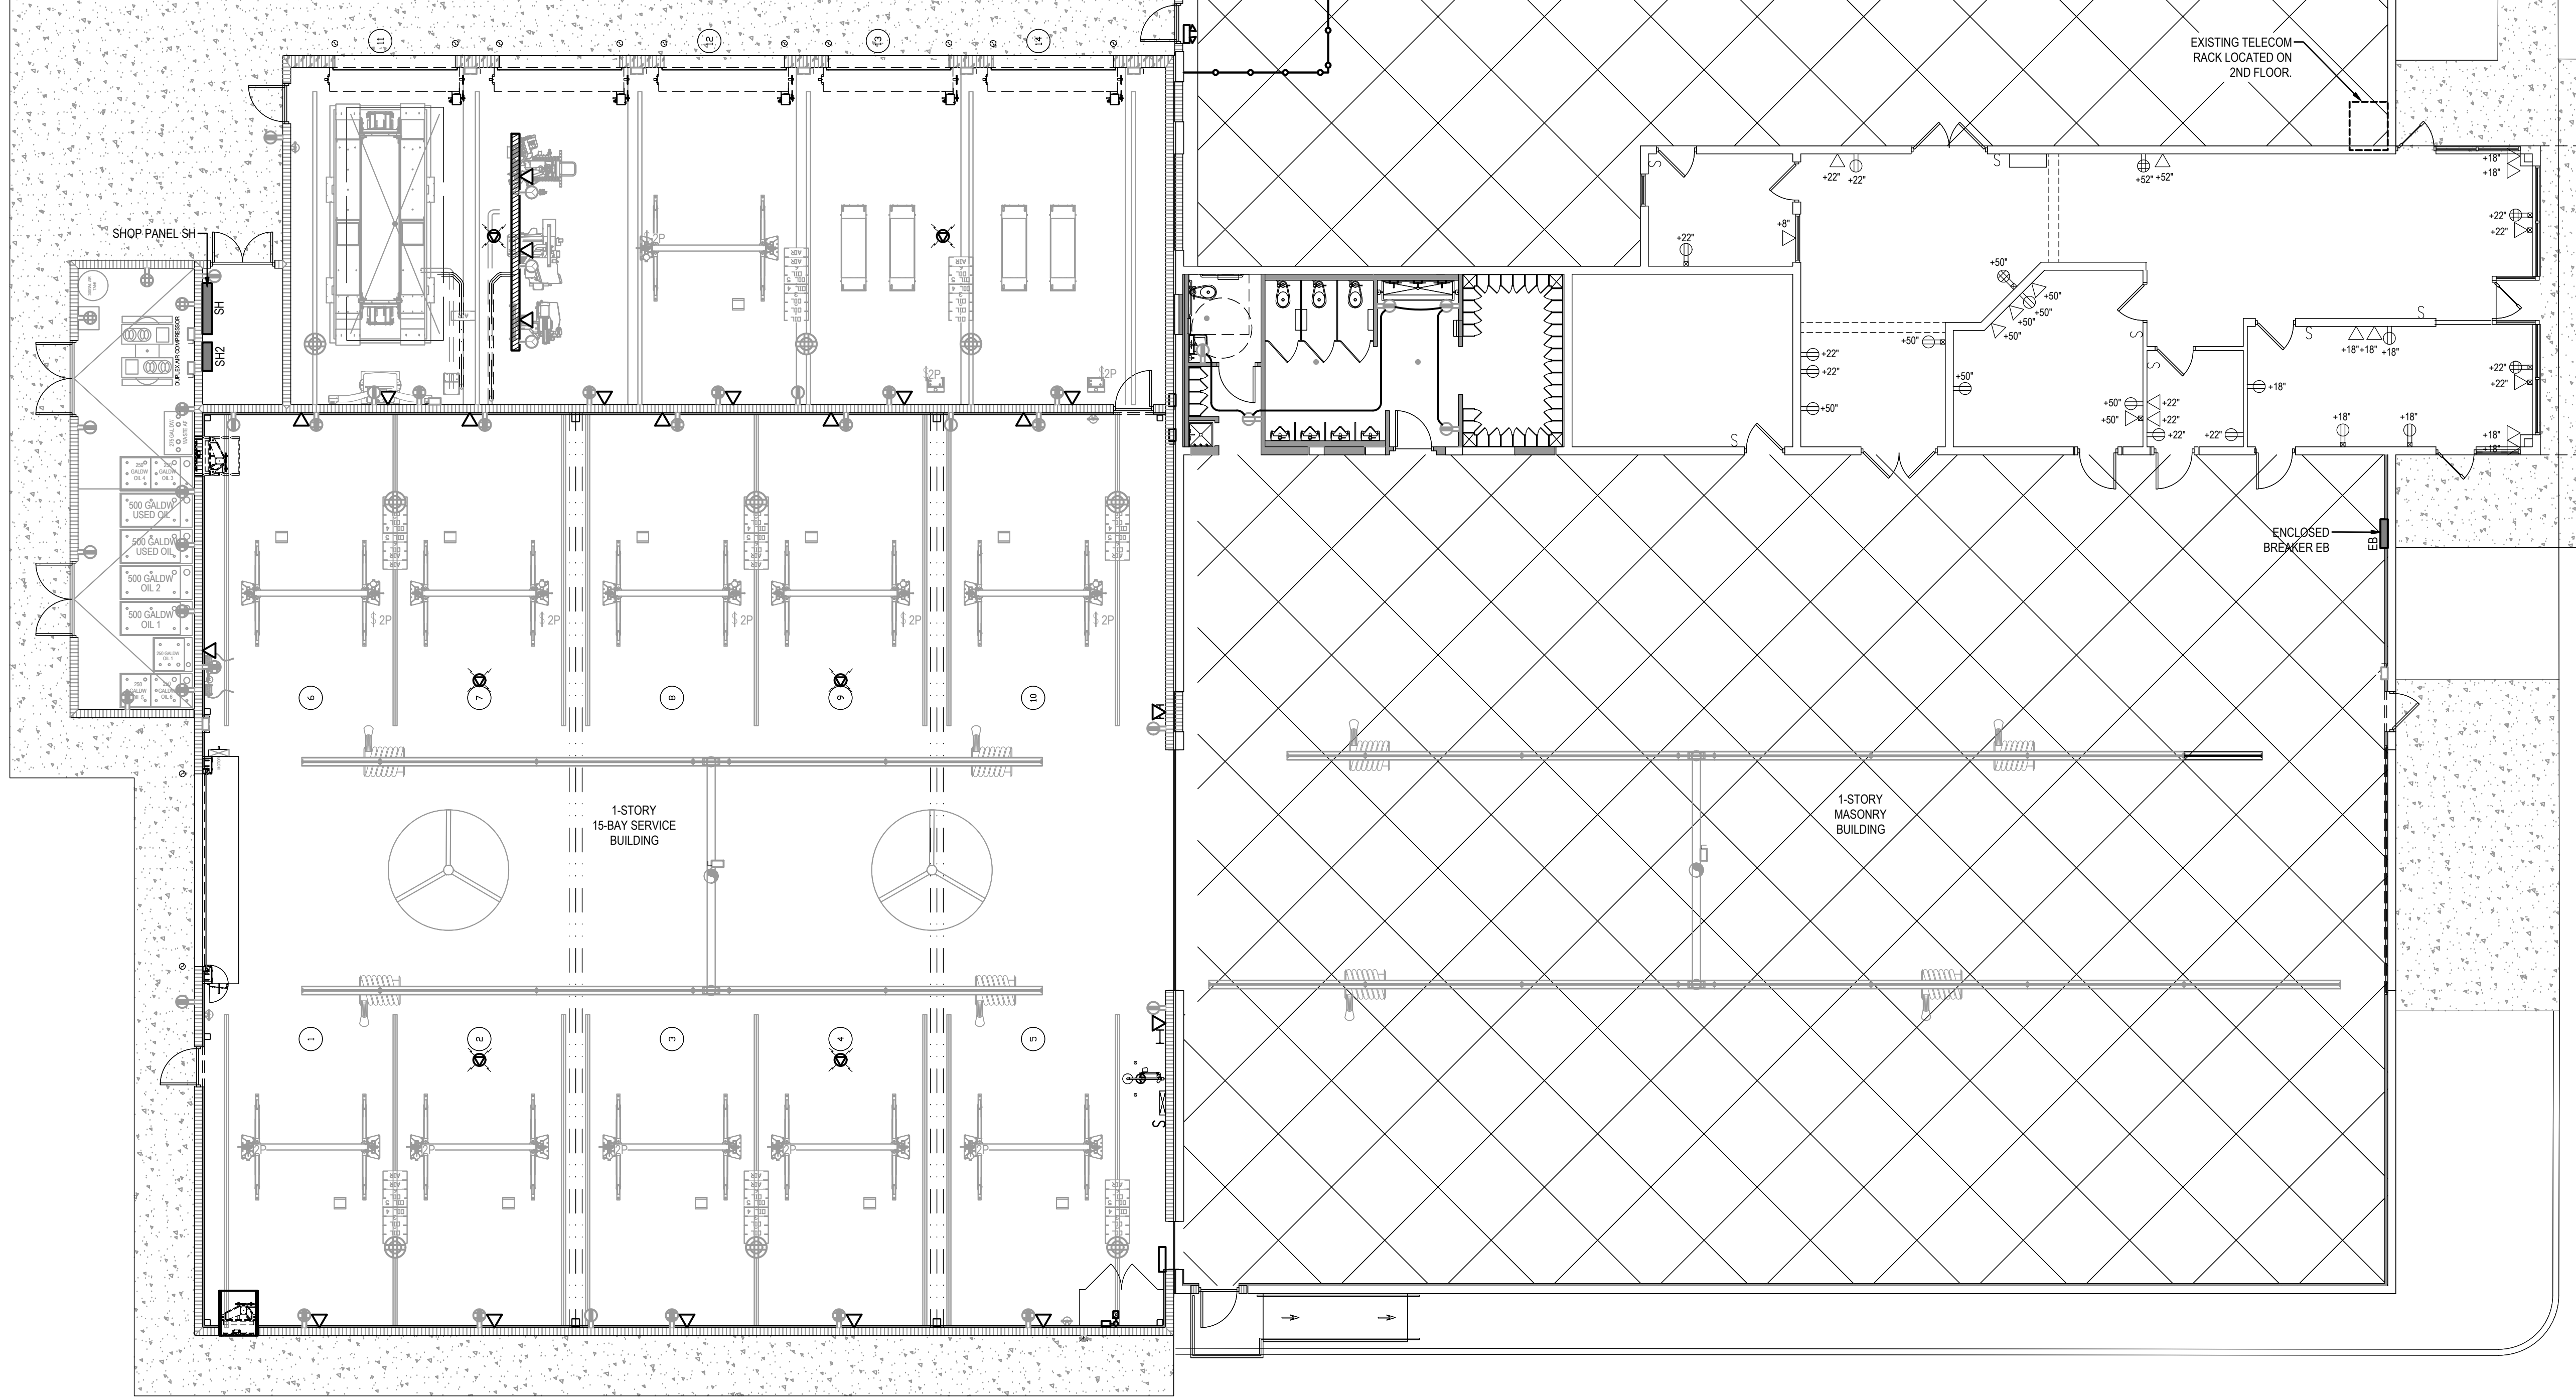

SHOP BLDG. FLOOR PLAN - MISC. SYSTEMS

1/8" = 1'-0" 0 4' 8' 16'




HG Engineers
142 Egin Parkway SE
Fort Walton Beach, Florida, 32548
E-mail: office@hgengineers.com
Ph: 850.243.6723
FL Authorization No.00006680
Christopher A. Garick, FL PE No.53924
Thomas A. Alexander, FL PE No.73172
Daniel J. White, FL PE No.73790
Caleb W. Leonard, FL PE No.91782

25024
Job No.

16 JUL 2026 FOR PERMIT

SHOP BLDG. FLOOR
PLAN - MISC. SYSTEMS

E4.03

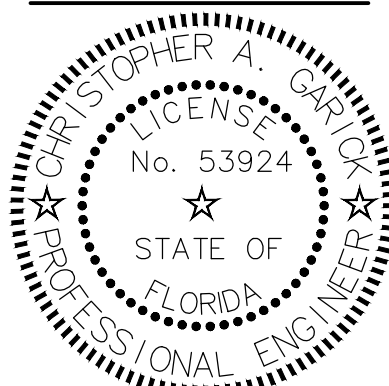


DATE:	JUL 16, 2026
DRAWN BY:	RENGLE / C.PASTORIUS
PROJECT NO:	2519
REVISIONS:	
Δ	2026-08-21
SCHEMATIC REVIEW	


Step One Automotive Group
CDJR Renovation

541 MARY ESTHER CUT-OFF NW
FOR WALTON BEACH, FLORIDA


jdf+
architecture llc
201 hollywood blvd ne | ft. walton beach | florida | 32548
850.496.2166 | www.jdfarchitecture.com | A06002502

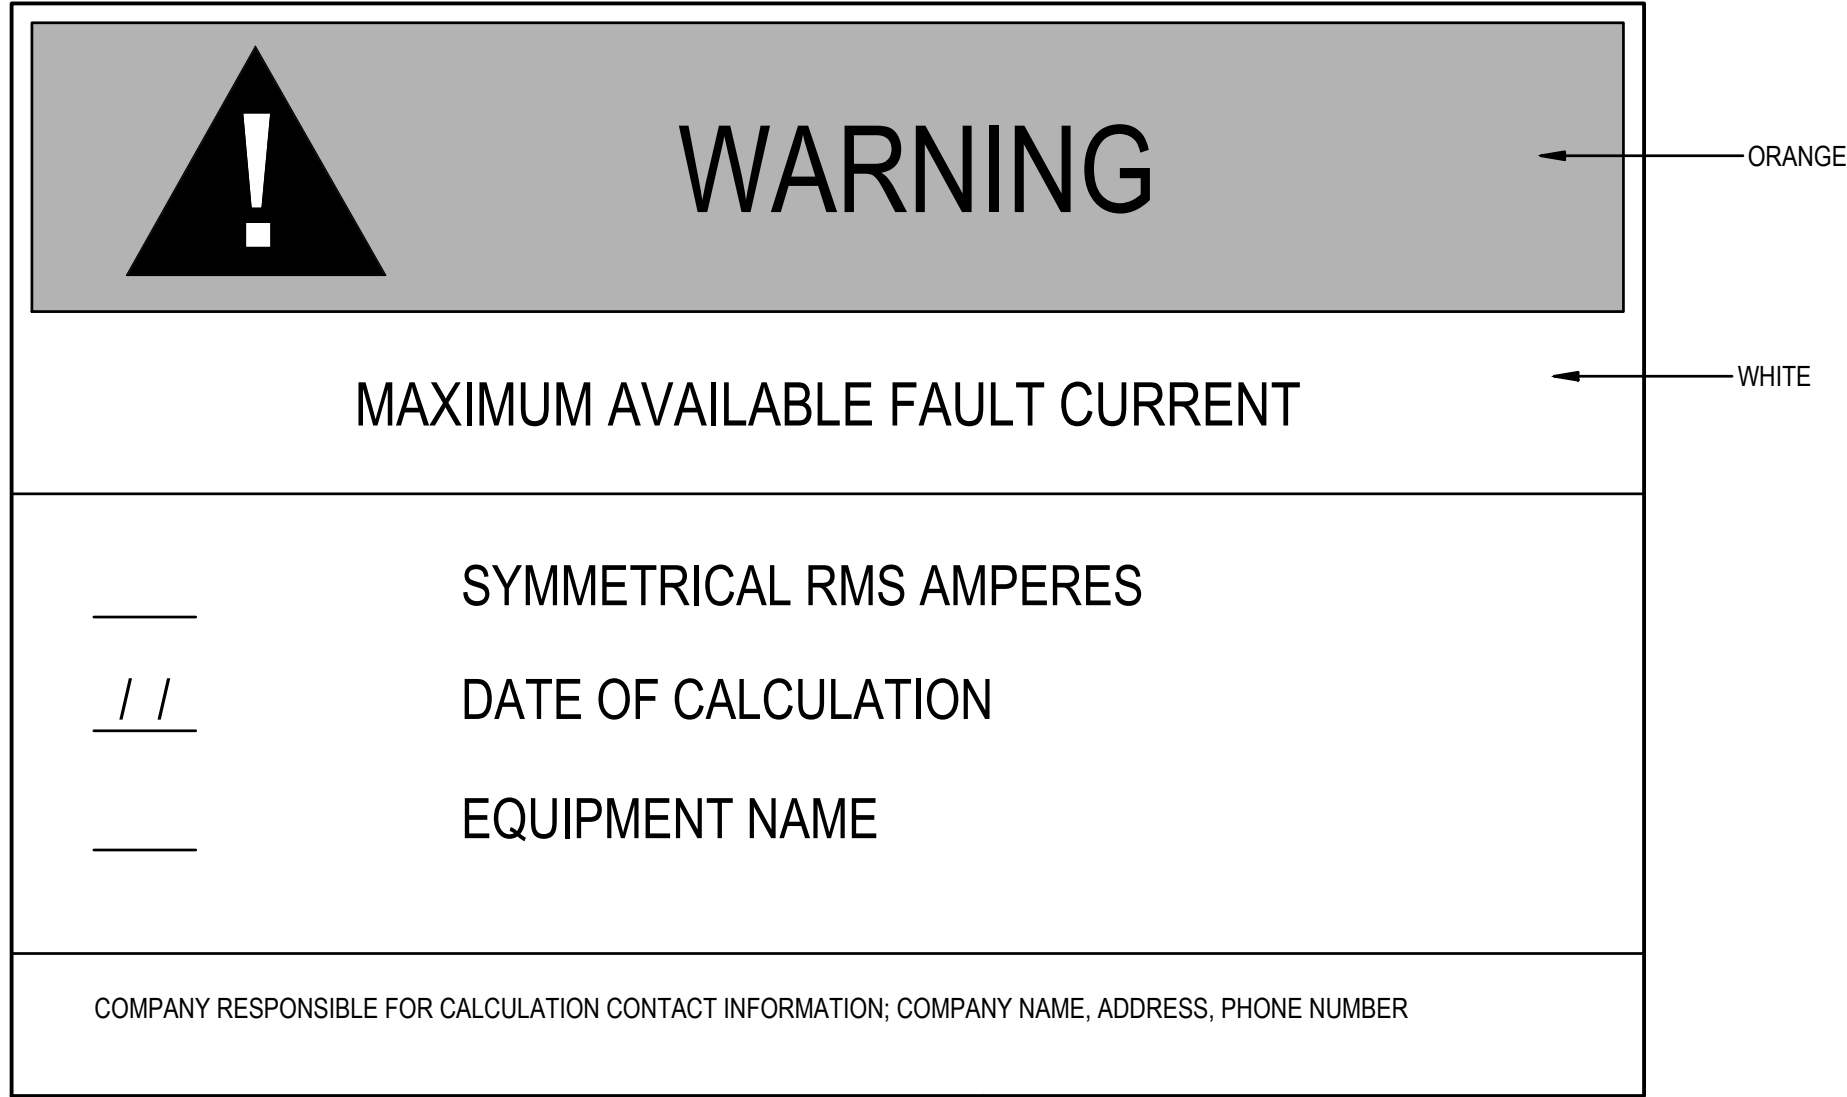


TYPICAL SERVICE EQUIPMENT FAULT CURRENT LABEL DETAIL
NOT TO SCALE

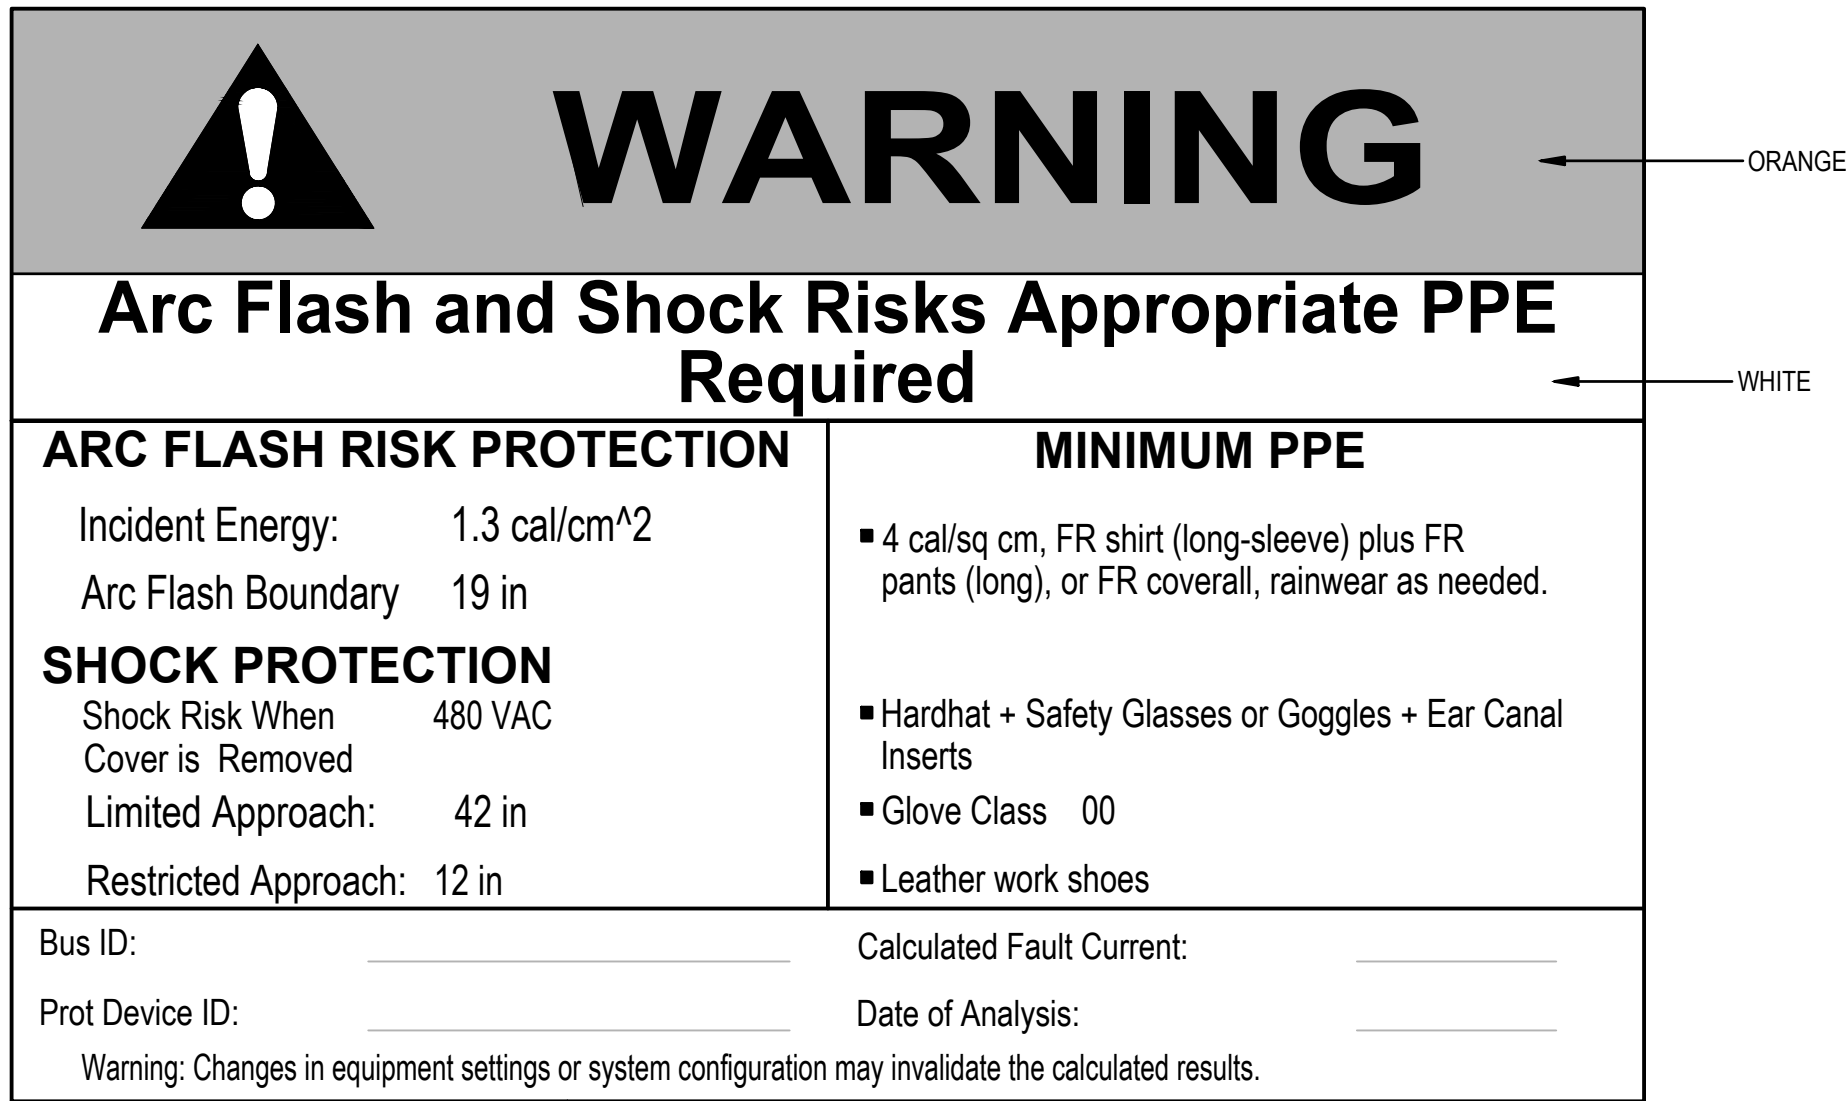


TYPICAL ARC FLASH HAZARD LABEL DETAIL
NOT TO SCALE

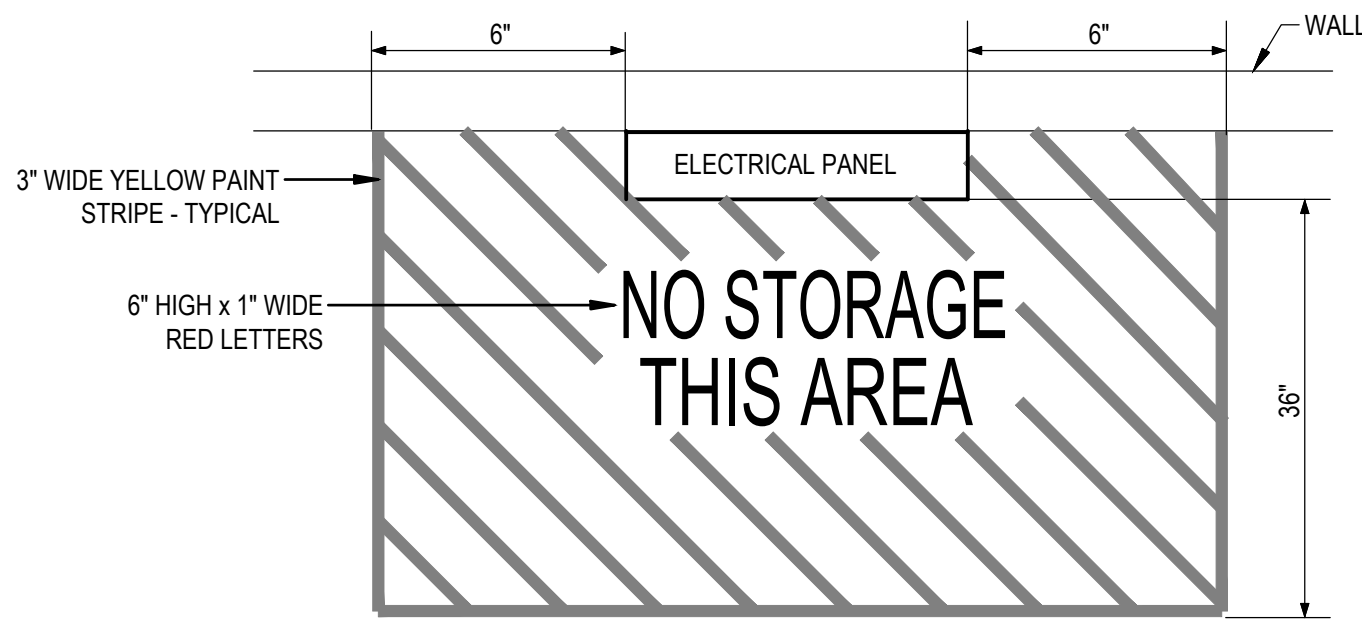



TYPICAL FLOOR MARKING AT ELECTRICAL PANELS
NOT TO SCALE

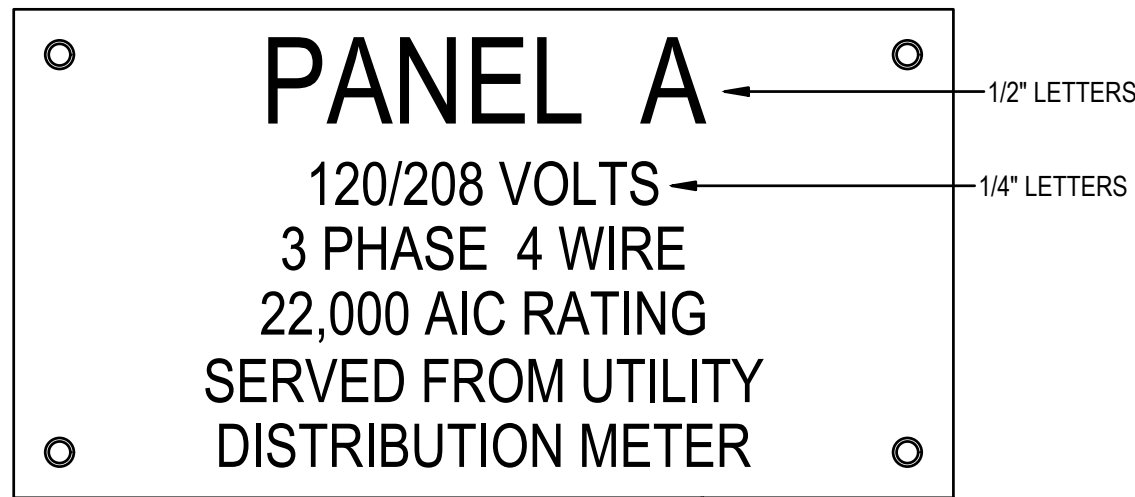


TYPICAL ELECTRICAL EQUIPMENT NAMEPLATE
NOT TO SCALE

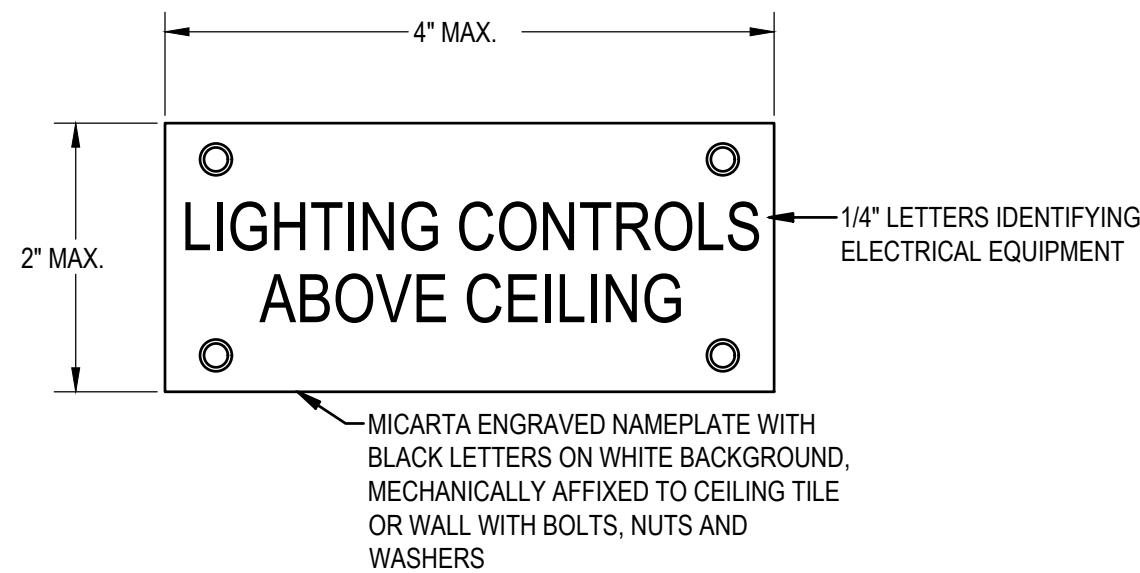


TYPICAL ELECTRICAL EQUIPMENT ABOVE CEILING NAMEPLATE
NOT TO SCALE

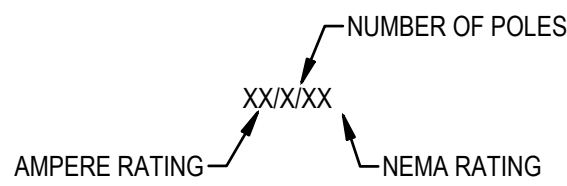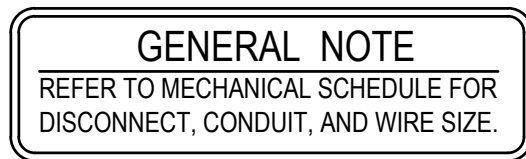

DISCONNECT SWITCH DESCRIPTION NOMENCLATURE

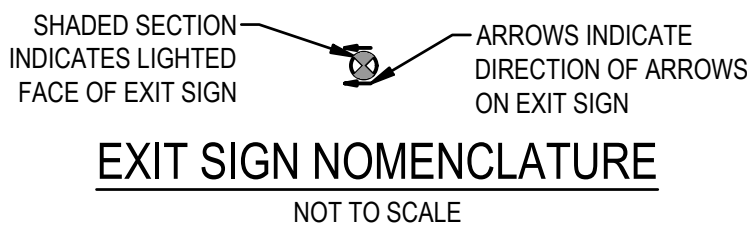

EXIT SIGN NOMENCLATURE
NOT TO SCALE

 


LIGHTING FIXTURE NOMENCLATURE
NOT TO SCALE




NOTES
1. PROVIDE LABEL IF NOT PROVIDED BY MANUFACTURER.
2. 3/8" WHITE LETTERS ON BLACK PANEL

SERVICE EQUIPMENT MARKING

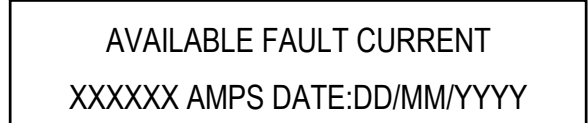


NOTES
1. REQUIRED IN ADDITION TO ARC FLASH LABEL
2. 1/4" WHITE LETTERS ON BLACK PANEL

AVAILABLE FAULT CURRENT

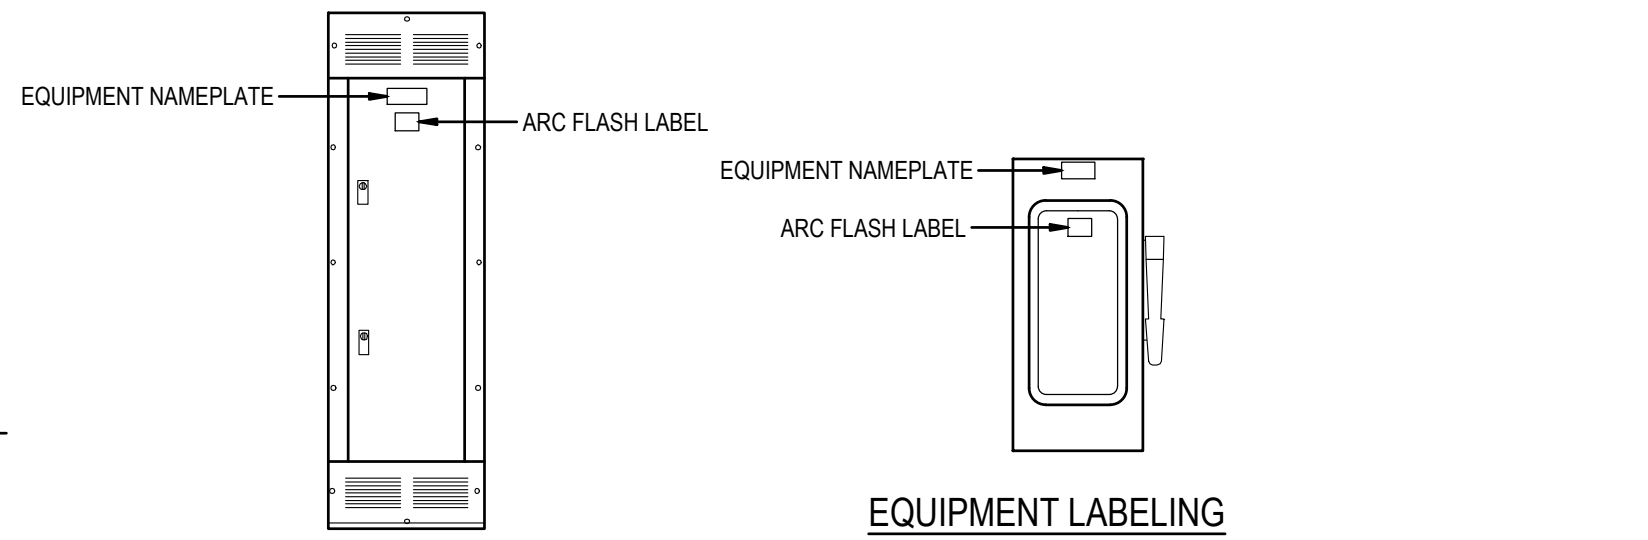


PANELBOARD LABELING

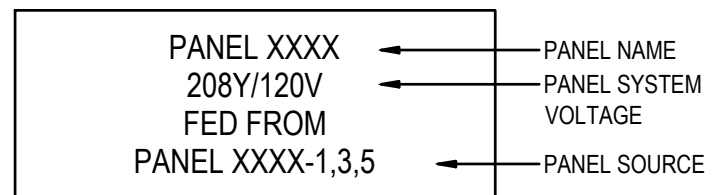


NOTES
1. PROVIDE LABEL FOR ALL PANELS FED FROM A FEEDER
2. NORMAL POWER - 1/4" BLACK LETTERS ON WHITE PANEL
3. EMERGENCY POWER - 1/4" WHITE LETTERS ON RED PANEL

PANELBOARD NAMEPLATES


EQUIPMENT LABELING DETAILS
NOT TO SCALE

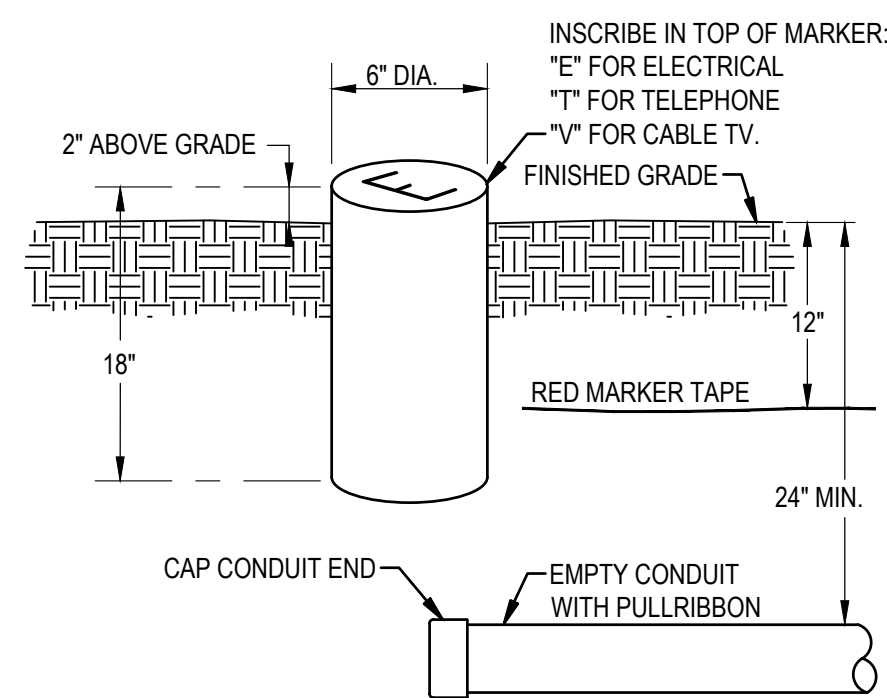


CONDUIT MARKER DETAIL
NOT TO SCALE

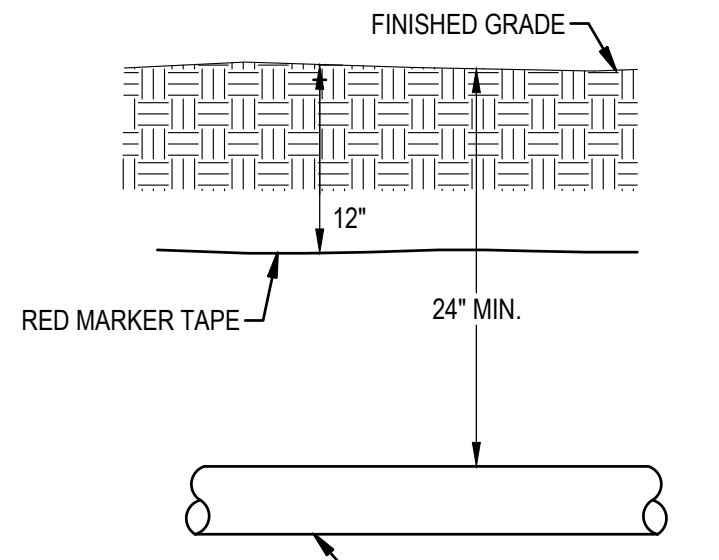

UNDERGROUND CONDUIT DETAIL
NOT TO SCALE

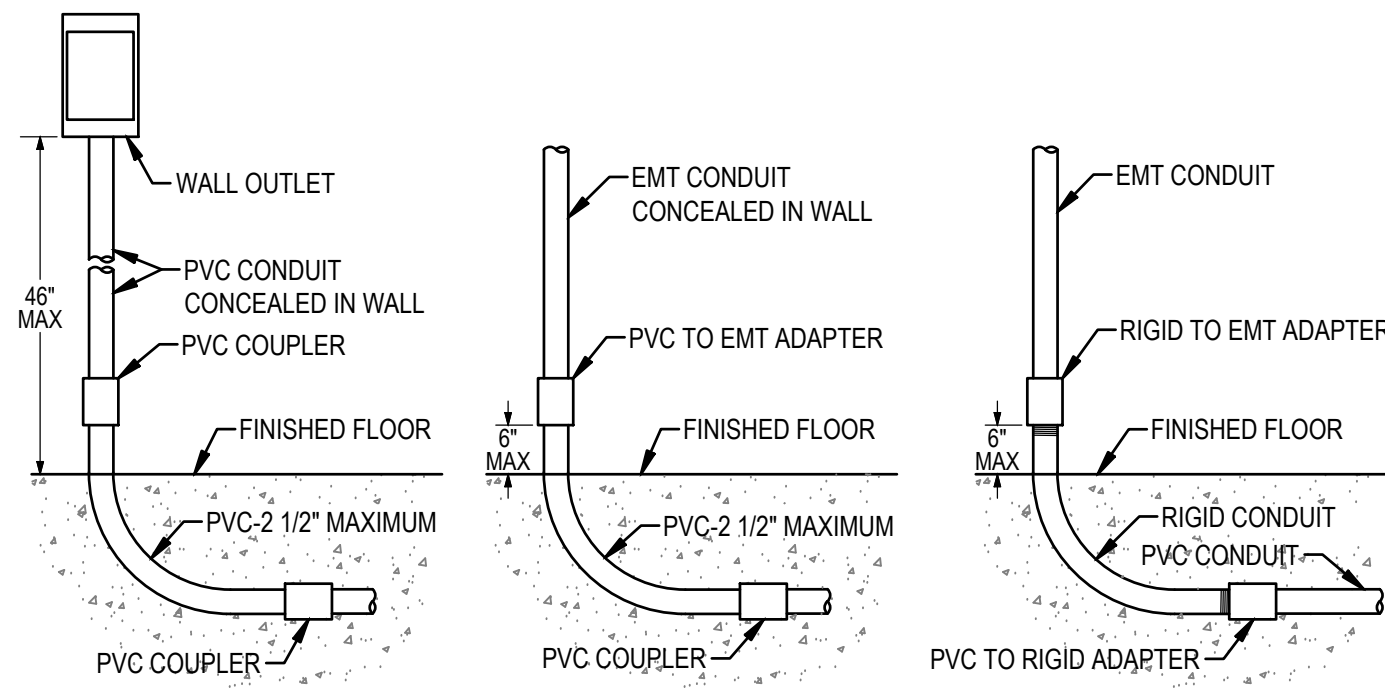

PVC STUB-UP DETAILS
NOT TO SCALE

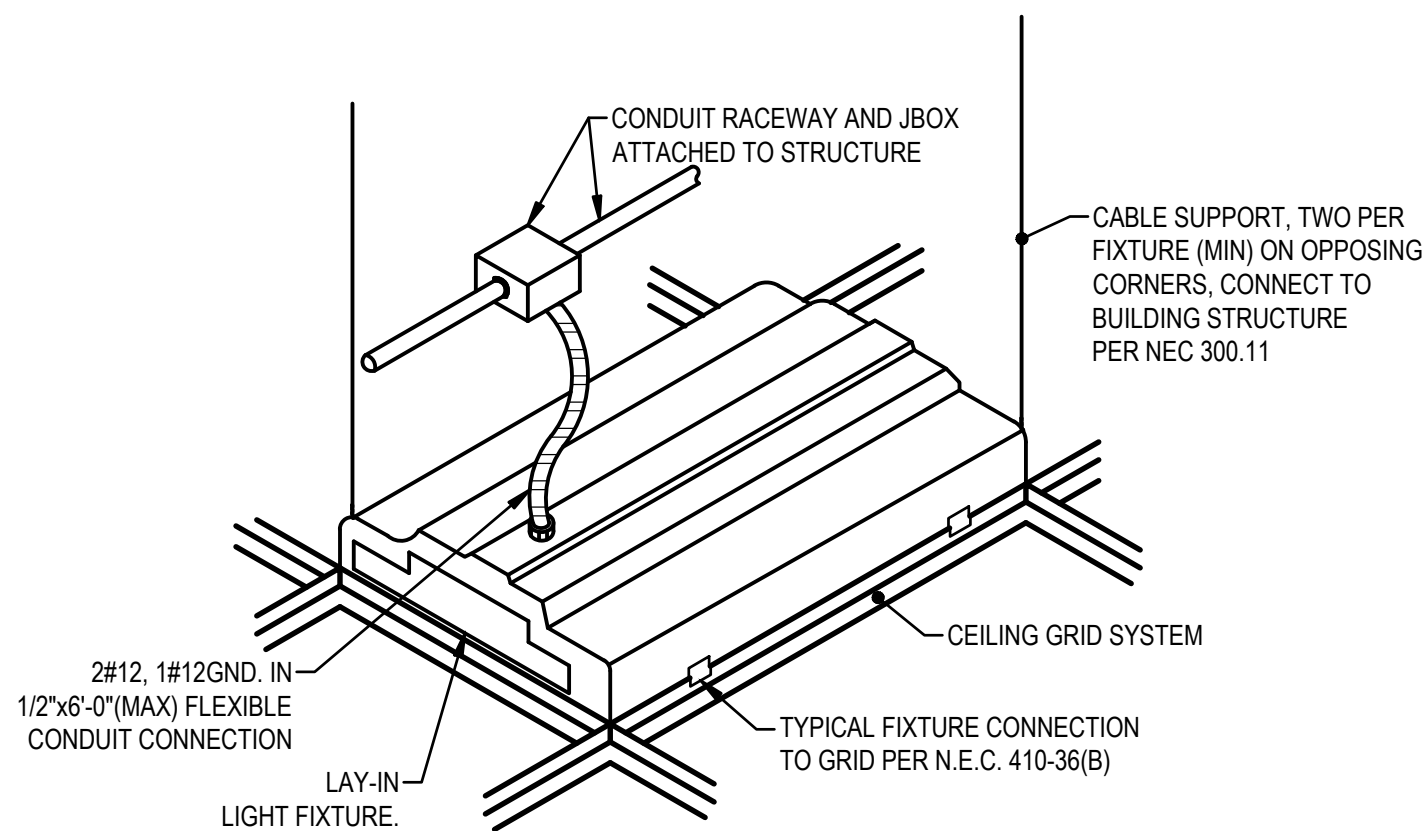

LAY-IN FIXTURE CABLE SUPPORT DETAIL
NOT TO SCALE



- ① FLOOR BOX FLANGED COVER WITH FLOORING INSERT, BY ELECTRICAL CONTRACTOR.
- ② POWER/COMMUNICATIONS PARTITION PLATE BY ELECTRICAL CONTRACTOR.
- ③ EMPTY 1" COMMUNICATIONS CONDUIT WITH PULL/BURR, RUN UNDER FLOOR TO NEAREST ACCESSIBLE WALL. STUB 3/4" UP INTO ACCESSIBLE CEILING SPACE.
- ④ POWER CONDUIT WITH WATER/TIGHT FITTINGS, BY ELECTRICAL CONTRACTOR. RUN UNDER FLOOR TO NEAREST POWERED CIRCUIT. REFER TO ELECTRICAL FLOOR PLANS.
- ⑤ CONCRETE FLOOR SLAB, MAINTAIN THICKNESS AND CONSTRUCTION ABOVE AND UNDER FORM BOX AS REQUIRED BY ARCHITECTURAL/STRUCTURAL DRAWINGS FOR STANDARD FLOOR CONSTRUCTION.

TYPICAL FLOOR BOX INSTALLATION DETAIL

NOT TO SCALE



- ① MULTI-GANG FLOORBOX, USING CARLON E976RFB FLOOR BOXES; FLANGE COLOR SELECTED BY ARCHITECT.
- ② POWER/COMMUNICATIONS PARTITION PLATE, PART OF CARLON E976AK2.
- ③ DUPLEX RECEPTACLE PLATE, PART OF CARLON E976AK2, AND DUPLEX OUTLET BY ELECTRICAL CONTRACTOR.
- ④ BLANK PLATE, PART OF CARLON E976AK2, FURNISHED BY ELECTRICAL CONTRACTOR.
- ⑤ COMMUNICATIONS PLATE, PART OF CARLON E976AK2, FURNISHED BY ELECTRICAL CONTRACTOR.
- ⑥ REMAINING OWNER FOR SPECIFIC PLATE SELECTIONS.
- ⑦ HINGED ACCESS DOOR & WIRE SHIELD FOR POWER EXTENSION CORD AND COMMUNICATIONS PATCH CORD.
- ⑧ FLOOR BOX COVER, SIZED FOR NUMBER OF BOXES. SELECTION OF MATERIAL & COLOR BY ARCHITECT. FURNISHED AND INSTALLED BY ELECTRICAL CONTRACTOR. CARLON E976 SERIES.



TYPICAL FLOOR BOX DETAIL (OPEN/CLOSED)
NOT TO SCALE



WALL DETAILS - ELECTRICAL BOX INSTALLATION



ADJACENT ELECTRICAL BOXES



WALL PENETRATIONS -APPLIES TO ALL CORRIDOR, SMOKE AND FIRE RATED WALLS
NOT TO SCALE



HG Engineers
 142 Eglin Parkway SE
 Fort Walton Beach, Florida, 32548
 E-mail: office@hgenr.com
 Ph: 850.243.6723
 Fl. Authorization No.00006680
 Christopher A. Garick; FL. PE No.53
 Thomas A. Alexander; FL. PE No.73
 Daniel J. White; FL. PE No.73790
 Caleb W. Leonard; FL. PE No.91782

25024
Job No.


16 JUL 2026 FOR PERMIT

ELECTRICAL DETAILS

Step One Automotive Group CDJR Renovation

541 MARY ESTHER CUT-OFF NW
FOR WALTON BEACH, FLORIDA

jldf+
architecture llc
201 hollywood blvd ne | ft. walton beach | florida | 32548
850.486.2166 | www.jldfarchitecture.com | AIA26002502

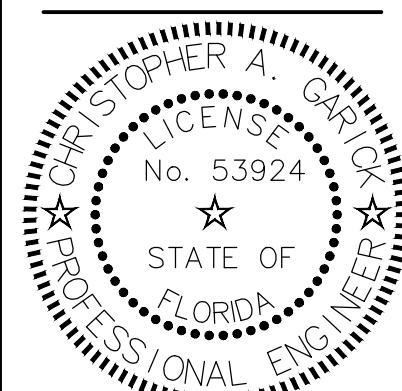
[illegible]

E5.01

CPASTORIUS - 10:40 AM - E5.01 ELECTRICAL DETAILS.dwg


LIGHTING CONTROL GENERAL NOTES

- THE DIAGRAMS ARE NOT INTENDED TO SHOW EXACT QUANTITIES OF DEVICES. REFER TO PLAN FOR ESTIMATED DEVICE QUANTITIES AND LOCATIONS.
- COLORS FOR ALL DEVICES AND DEVICE COVERS SHALL BE SELECTED BY THE ARCHITECT.
- PROVIDE ADDITIONAL POWER AND CONTROL MODULES AS RECOMMENDED BY THE SYSTEM SUPPLIER.
- THE DIAGRAMS REPRESENT A TYPICAL SYSTEM AND ARE NOT INTENDED FOR INSTALLATION. SYSTEM SUPPLIER SHALL PROVIDE INSTALLATION DRAWINGS AND WIRING DIAGRAMS.
- E.C. SHALL COORDINATE FIELD PROGRAMMING OF LIGHTING CONTROL SYSTEM WITH SYSTEM PROGRAMMER, SPECIFYING ENGINEER, AND OWNER TO ENSURE PROPER OPERATION AND TIME SCHEDULES.
- ALL EMERGENCY AND EXIT LIGHTING CIRCUITS SHALL BE CONNECTED TO CONTINUOUS POWER SOURCE AHEAD OF RELAY PANEL OR INDIVIDUAL RELAY COMPONENTS.

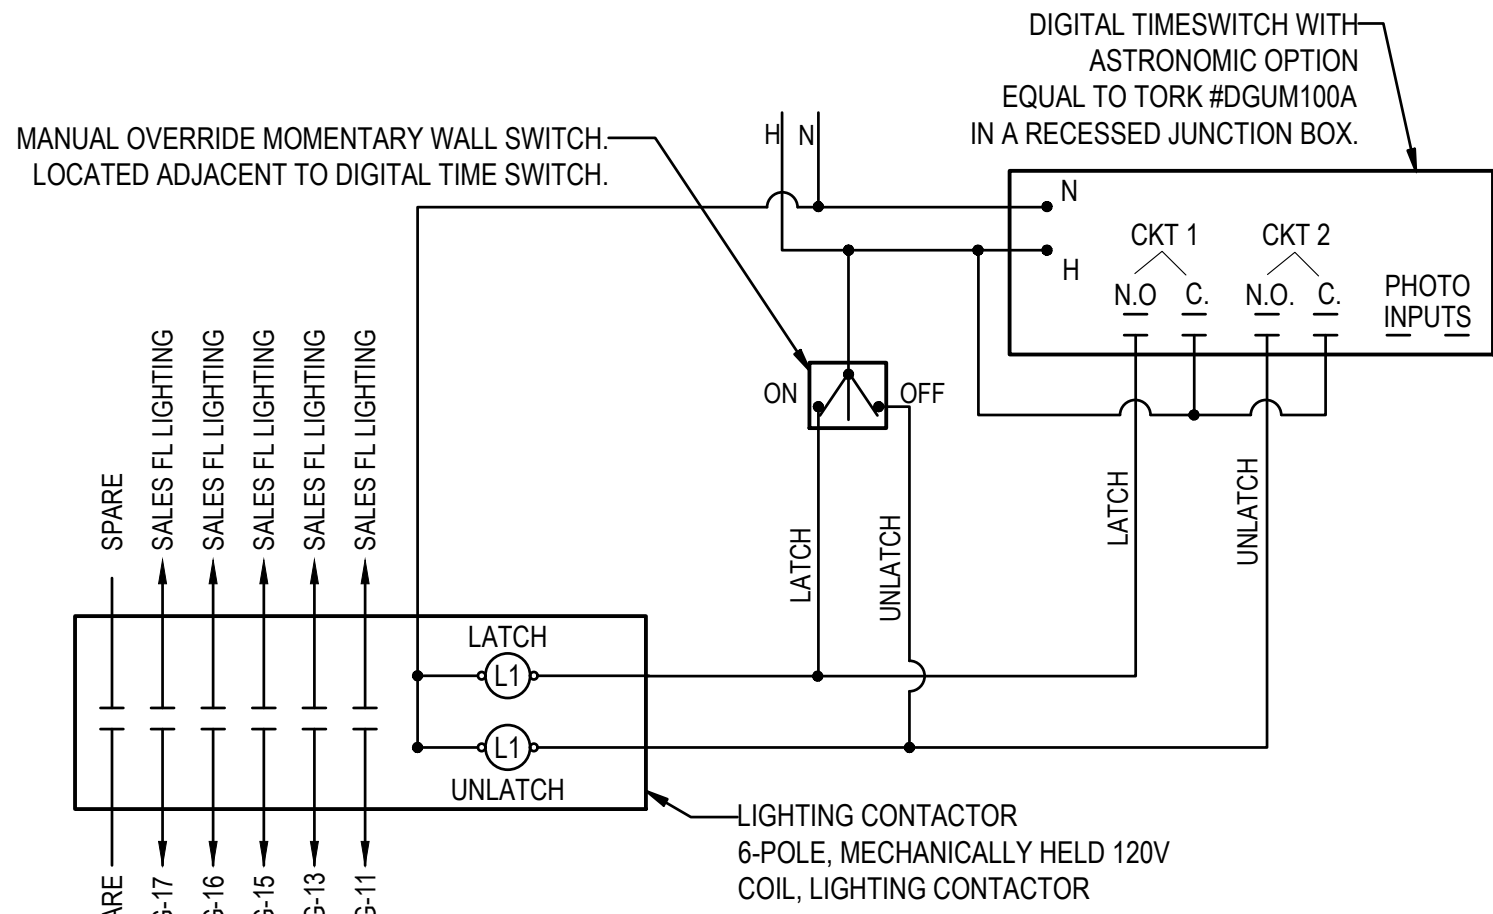

LIGHTING CONTROL DESIGNATOR SF

NTS

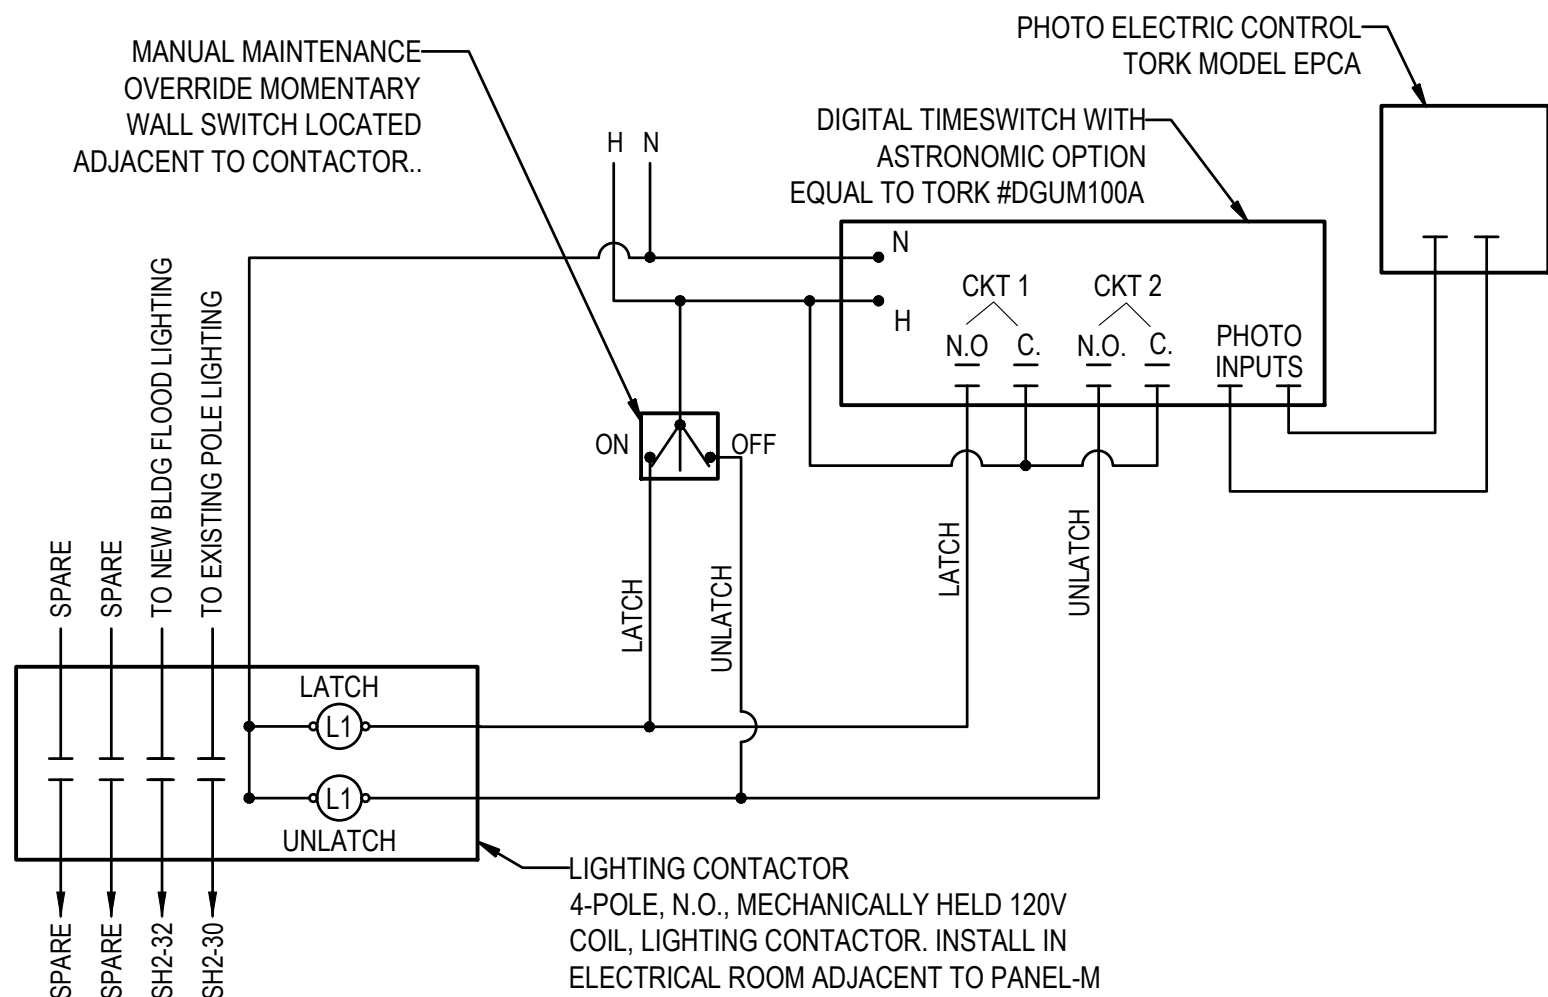


EXTERIOR LIGHTING CONTROL

NTS


LIGHTING FIXTURE SCHEDULE										
Project: 25024 - Shop One Chrysler-Jeep										
Note: Per electrical specifications, required alternate fixtures shall be submitted to the engineer for prior approval a minimum of (10) ten business days prior to bid date. Any required alternate fixtures not submitted for prior approval will not be reviewed.										
Luminaire Designation	Manufacturer	Catalog Number	Connected Voltage	Luminaire Load (va)	Lamping Source	Color Rendering Index (CRI)	Kelvin Temperature	Mounting	Comments	Prior Approved Equal Required
C1	TECHOLED	B-2x4-C-U-A-DM-L-W	120	50	LED	>80	4000	RECESSED GRID	RECESSED 2X4 TROFFER	YES
C1S	TECHOLED	B-2x4-C-U-A-DM-SM-W	120	50	LED	>80	4000	RECESSED GRID	SURFACE MOUNT 2X4 TROFFER	YES
BP	H.E. WILLIAMS	EMERLED-WHT-D	120	3	LED	N/A	N/A	WALL MOUNT 7'-0" UNLESS NOTED OTHERWISE	BATTERY PACK	YES
C2	TECHOLED	DLR-6-CR-C-20-40-U-SFW-CB-DM	120	20	LED	>80	4000	RECESSED GRID	6" RECESSED DOWNLIGHT	YES
F1	TECHOLED	BX-2U-DI-C-HI-40-U-WP-DM	120	17WFT	LED	>80	4000	REFER TO DID	INDIRECT/DIRECT SUSPENDED LINEAR	YES
F3	TECHOLED	XC-HI-36-40-W-J TRACK - XT-C-120-W-P-X	120	30	LED	>80	4000	SUSPENDED X-X-X	TRACK LIGHT	YES
F5	TECHOLED	BX-2-RBW-4-ME-40-U-W-TG-DM-X-X	120	29	LED	>80	4000	LINEAR RECESSED	2'x4' RECESSED LINEAR	YES
F6	TECHOLED	BX-4-R-D-12-LO-40-U-W-RP-DM	120	72	LED	>80	4000	DRYWALL RECESSED	RECEESSED LINEAR	YES
F7	TECHOLED	DLA-6-A-30-40-64-U-W-WT-DM	120	30	LED	>80	4000	RECESSED GRID	4" SQUARE DOWNLIGHT WALL WASH	YES
F8	TECHOLED	DLR-6-CR-C-20-40-U-SFW-CB-DM	120	20	LED	>80	4000	RECESSED GRID	6" RECESSED DOWNLIGHT	YES
F9	TECHOLED	B-2X2-C-U-A-DM-L-W	120	40	LED	>80	4000	RECESSED GRID	RECEESSED 2X2 TROFFER	YES
F9S	TECHOLED	B-2X2-C-U-A-DM-SM-W	120	40	LED	>80	4000	RECESSED GRID	SURFACE MOUNT 2X2 TROFFER	YES
FL	GARCO	CSPM-A14740-RMF-SLF-UNV-FAWS-FINISH	120	180	LED	>70	4000	WALL MOUNT 16'-0"	FLOOD LIGHT FOR DRIVE AROUND NEW SHOP BLDG.	YES
PEN1	ET2 CONTEMPORARY LIGHTING	ORB II 9 LIGHT PENDANT E24059-9IPC	120	45	LED	>80	3000	CEILING SURFACE	DECORATIVE PENDANT FIXTURE	YES
SH1	TECHOLED	PHB-D-LUX403-200-40-U-S-P-DM-X-X	120	200	LED	>80	4000	SURFACE MOUNT TO STRUCTURE	HIGH-BAY FIXTURE	YES
SL	TECHOLED	VTD-40W-40-SF-U-F-F-DM-X	120	40	LED	>80	4000	SURFACE OR CHAIN HUNG	VAPOR-TIGHT LINEAR	YES
SL2	H.E. WILLIAMS	75R-2L25-840-DIM-UNV	120	19	LED	>80	4000	6" ABOVE DOOR	LINEAR	YES
X	H.E. WILLIAMS	EXTR-REM-WHT	120	3	LED	N/A	N/A	WALL MOUNT 6" ABOVE DOOR	EGRESS SIGNAGE	YES

Lighting Space and Zones			Sequence of Operations												Low Voltage Switch Matrix (Button Labels to be designated by owner during installation)					Remarks			
Space Type	ZONE OF CONTROL		CONTROL SCENARIOS												CONNECT TO ROOM CONTROLLER						Line Voltage Switches		
	Description	Designator	Manual On	Manual Off	Dimming	Multi-Level Control	Time-Lock On	Time-Lock Off	Occupancy Sensor On	Vacancy Sensor Off	Daylight Harvesting	Photo Sensor On	Fire Alarm System Override to 'On'	Security System Override to 'Off'	SL1 (1-Button)	SL2 (2-Button)	SL3 (3-Button)	SL4 (4-Button)	SL5 (5-Button)		SV (Toggle Switch)	SV (Key-Toggle Switch)	SV (Integral Sensor, Line Voltage)
Sales Floor/Customer Lounge/Back Hallway		SF	X	X			X	X												X	X		
Restroom		SF	X	X			X	X												X			
Shop Floor		SH	X	X																			
New Office			X	X						X												X	

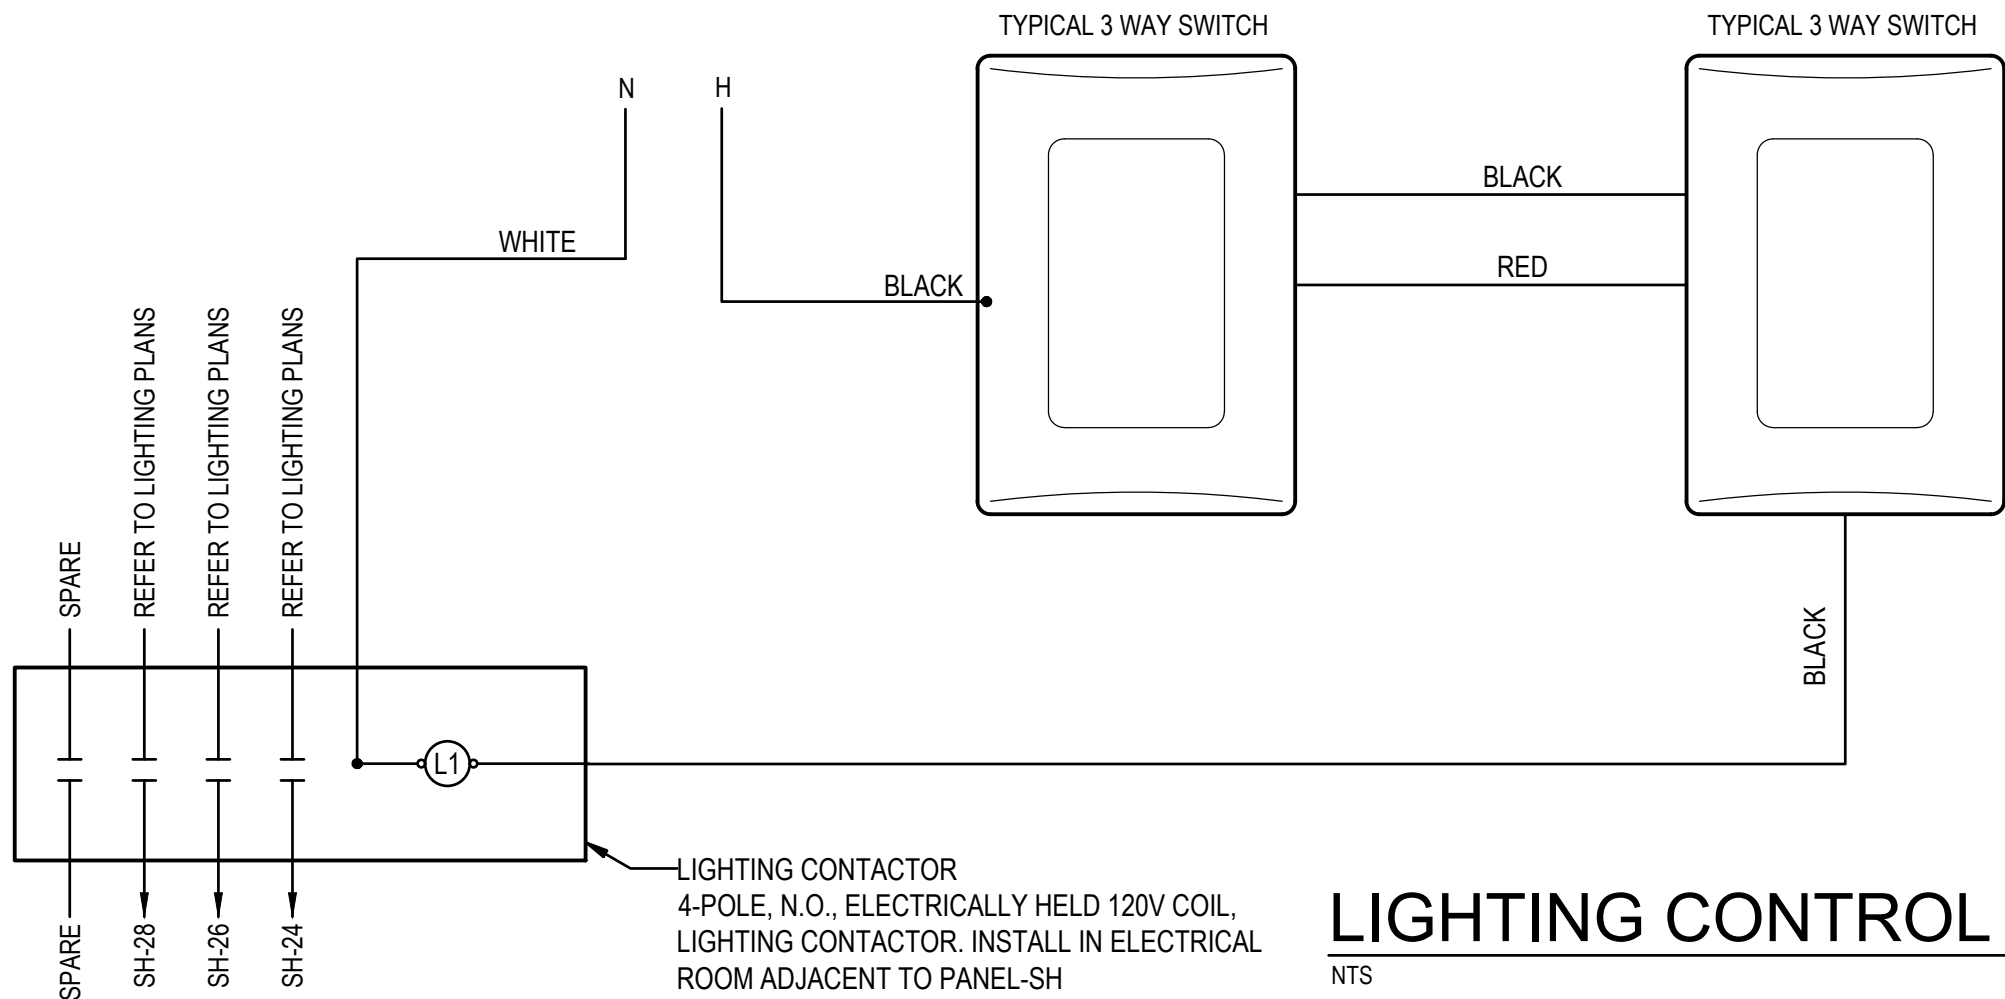

LIGHTING CONTROL DESIGNATOR SH

NTS

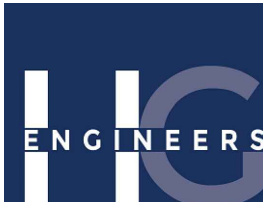


HG Engineers
142 Eglon Parkway SE
Fort Walton Beach, Florida, 32548
E-mail: office@hgengineers.com
Ph: 850.243.6723
FL Authorization No.00006680
Christopher A. Garick, FL PE No.53924
Thomas A. Alexander, FL PE No.73172
Daniel J. White, FL PE No.73790
Caleb W. Leonard, FL PE No.91782

25024
Job No.

16 JUL 2026 FOR PERMIT

LIGHTING CONTROLS
DETAILS

E6.00

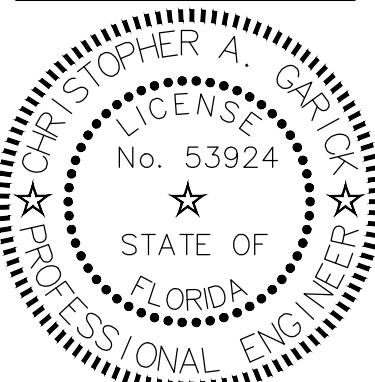

DATE: JUL 16, 2026
DRAWN BY: RENGLE / C/PASTORIUS
PROJECT NO: 2519
REVISIONS:
2026-08-21
SCHEMATIC REVIEW

Step One Automotive Group
CDJR Renovation

541 MARY ESTHER CUT-OFF NW
FOR WALTON BEACH, FLORIDA

jdf+ architecture llc
201 hollywood blvd ne | ft. walton beach | florida | 32548
850.496.2166 | www.jdfarchitecture.com | A45602502

These plans and the ideas and concepts contained herein including digital information are the property of jdf architecture and are not to be reproduced, copied, modified, or changed in any form or manner without the express written permission and consent of jdf architecture. copyright © 2026.

1. BOND HOT AND COLD WATER PIPING SYSTEMS.
2. CONDUCTOR SIZES SHOWN ARE MINIMUM AND MAY BE LARGER THAN THE MINIMUM SIZES REQUIRED BY NEC.
3. INSTALL GROUNDING CONNECTIONS TO BUILDING STRUCTURE AND WATER PIPES AT LOCATIONS THAT ARE VISIBLE AND ACCESSIBLE FOR INSPECTION, MAINTENANCE, AND TESTING.
4. INSTALL AN INSULATED THROAT GROUNDING BUSHING ON EACH METALLIC SERVICE ENTRANCE CONDUIT. BOND TO GROUND BUS USING CONDUCTOR THAT IS SIZED BASED ON NEC TABLE 250-66 USING THE SERVICE PHASE CONDUCTOR SIZE.
5. INSTALL AN INSULATED THROAT GROUNDING BUSHING ON EACH METALLIC FEEDER CONDUIT. BOND TO GROUND BUS USING CONDUCTOR THAT IS SIZED BASED ON NEC TABLE 250-122 USING THE FEEDER CIRCUIT OVERCURRENT DEVICE SIZE OR THE SEPARATELY DERIVED SYSTEM OVERCURRENT DEVICE SIZE.



- ① INSTALL GROUNDED (NEUTRAL) CONDUCTOR SAME SIZE AS THE LARGEST PHASE CONDUCTOR IN THE LINE-TO-NEUTRAL LOAD EXCEEDS 5% OF THE CONNECTED LOAD. IF NEUTRAL LOAD IS SMALLER, INSTALL THE NEC MINIMUM GROUNDED CONDUCTOR.
- ② INSTALL GROUNDED ELECTRODE CONDUCTOR, SIZED BASED ON NEC TABLE 250-66 USING THE SERVICE PHASE CONDUCTOR SIZE, BUT NOT SMALLER THAN NO. 4.
- ③ INSTALL EQUIPMENT GROUNDING CONDUCTOR SIZED BASED ON NEC TABLE 250-122 USING THE FEEDER OVERCURRENT DEVICE SIZE.
- ④ 10 FOOT MINIMUM X 3/4" DIAMETER COPPER CLAD STEEL SECTIONAL DRIVEN GROUND ROD.
- ⑤ INSTALL BONDING JUMPER WIRE THAT IS SIZED BASED ON NEC TABLE 250-66 OR 250.28(D)(1) USING THE SERVICE OR SEPARATELY-DERIVED SYSTEM PHASE CONDUCTOR SIZE.
- ⑥ INSTALL A "MAIN GROUND ELECTRODE GROUND BAR" FOR SINGLE POINT GROUNDING. LOCATE AT AN ACCESSIBLE POINT NEAR THE SERVICE ENTRANCE EQUIPMENT. MAKE CONNECTIONS TO THE GROUND ELECTRODE CONDUCTOR USING IRREVERSIBLE CONNECTORS OR EXOTHERMIC WELDS. MAKE OTHER CONNECTIONS TO THE GROUND BAR USING TWO-HOLE COMPRESSION SPADE LUGS THAT MEET IEEE 837 REQUIREMENTS. LABEL EACH CONNECTION TO THE GROUND BAR.
- ⑦ FIRE ALARM CONTROL PANEL GROUND - #6 COPPER CONDUCTOR.
- ⑧ INSTALL A COPPER GROUNDING BAR IN EACH TELECOMMUNICATIONS ROOM. CONNECT TO THE "MAIN GROUNDING ELECTRODE GROUND BAR" USING 600V INSULATED #4 COPPER CABLE AND COMPRESSION SPADE LUGS.



- ① INSTALL SURGE PROTECTIVE DEVICE IN BREAKER POSITION NEAREST TO NEUTRAL BAR WITH #46, 1#10 GND IN 34°C; LEAD LENGTH CANNOT EXCEED UL 1449 4TH EDITION TEST OF 14" - REFER TO SPECS. PROVIDE INTERNAL 60A. FUSING.
- ② INSTALL SURGE PROTECTIVE DEVICE IN BREAKER POSITION NEAREST TO NEUTRAL BAR WITH #410, 1#10 GND IN 34°C; LEAD LENGTH CANNOT EXCEED UL 1449 5TH EDITION TEST OF 14" - REFER TO SPECS. PROVIDE INTERNAL 30A. FUSING.
- ③ REFER TO GROUNDING DETAIL SHEET FOR MORE INFORMATION.

FEEDER SCHEDULE													
DESIGNATION (F)	EQUIPMENT NAME	FED FROM	BREAKER RATING	BREAKER POLES	PARALLEL RUNS	CONDUIT	PH + N	CONDUCTOR	PHASE & GROUND (IN)	EQUIPMENT GROUND	SUPPLY SIZE	BONDING CONDUCTOR	MATERIAL
1	EB	UTILITY XF	800	3	3	2-1/2"	4	300 KCMIL	N/A	N/A	N/A	N/A	CUT
2	SH	EB	800	3	3	3"	4	400 KCMIL	1/0 AWG	N/A	N/A	N/A	CUT
3	SH2	SH	100	3	1	1-1/4"	3	3 AWG	8 AWG	N/A	N/A	N/A	CUT



HG Engineers
 142 Eglin Parkway SE
 Fort Walton Beach, Florida, 32548
 E-mail: office@hgengineers.com
 Ph: 850 243.6723
 Fl. Authorization No.00006680

Christopher A. Garick; FL PE No.5333
 Thomas A. Alexander; FL PE No.7373
 Daniel J. White; FL PE No.73790
 Caleb W. Leonard; FL PE No.91782

25024
Job No.

16 JUL 2026 FOR PERMIT


SLPR & GROUNDING DETAILS

E7.01

Step One Automotive Group CDJR Renovation


541 MARY ESTHER CUT-OFF NW
FOR WALTON BEACH, FLORIDA

jdf+
architecture llc
201 hollywood blvd ne | ft. walton beach | florida | 32548
850.496.2166 | www.jdfarchitecture.com | AA26002502

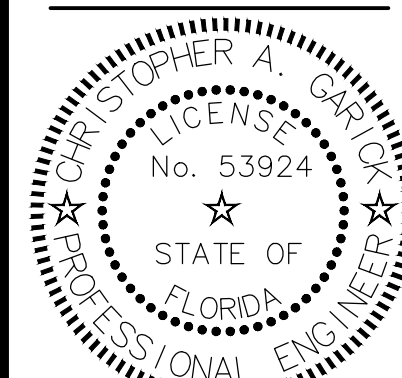

DECLASSIFICATION AUTHORITY

CPASTORIUS - 10:41 AM - E7.01 SLPR & GROUNDING DETAILS.dwg

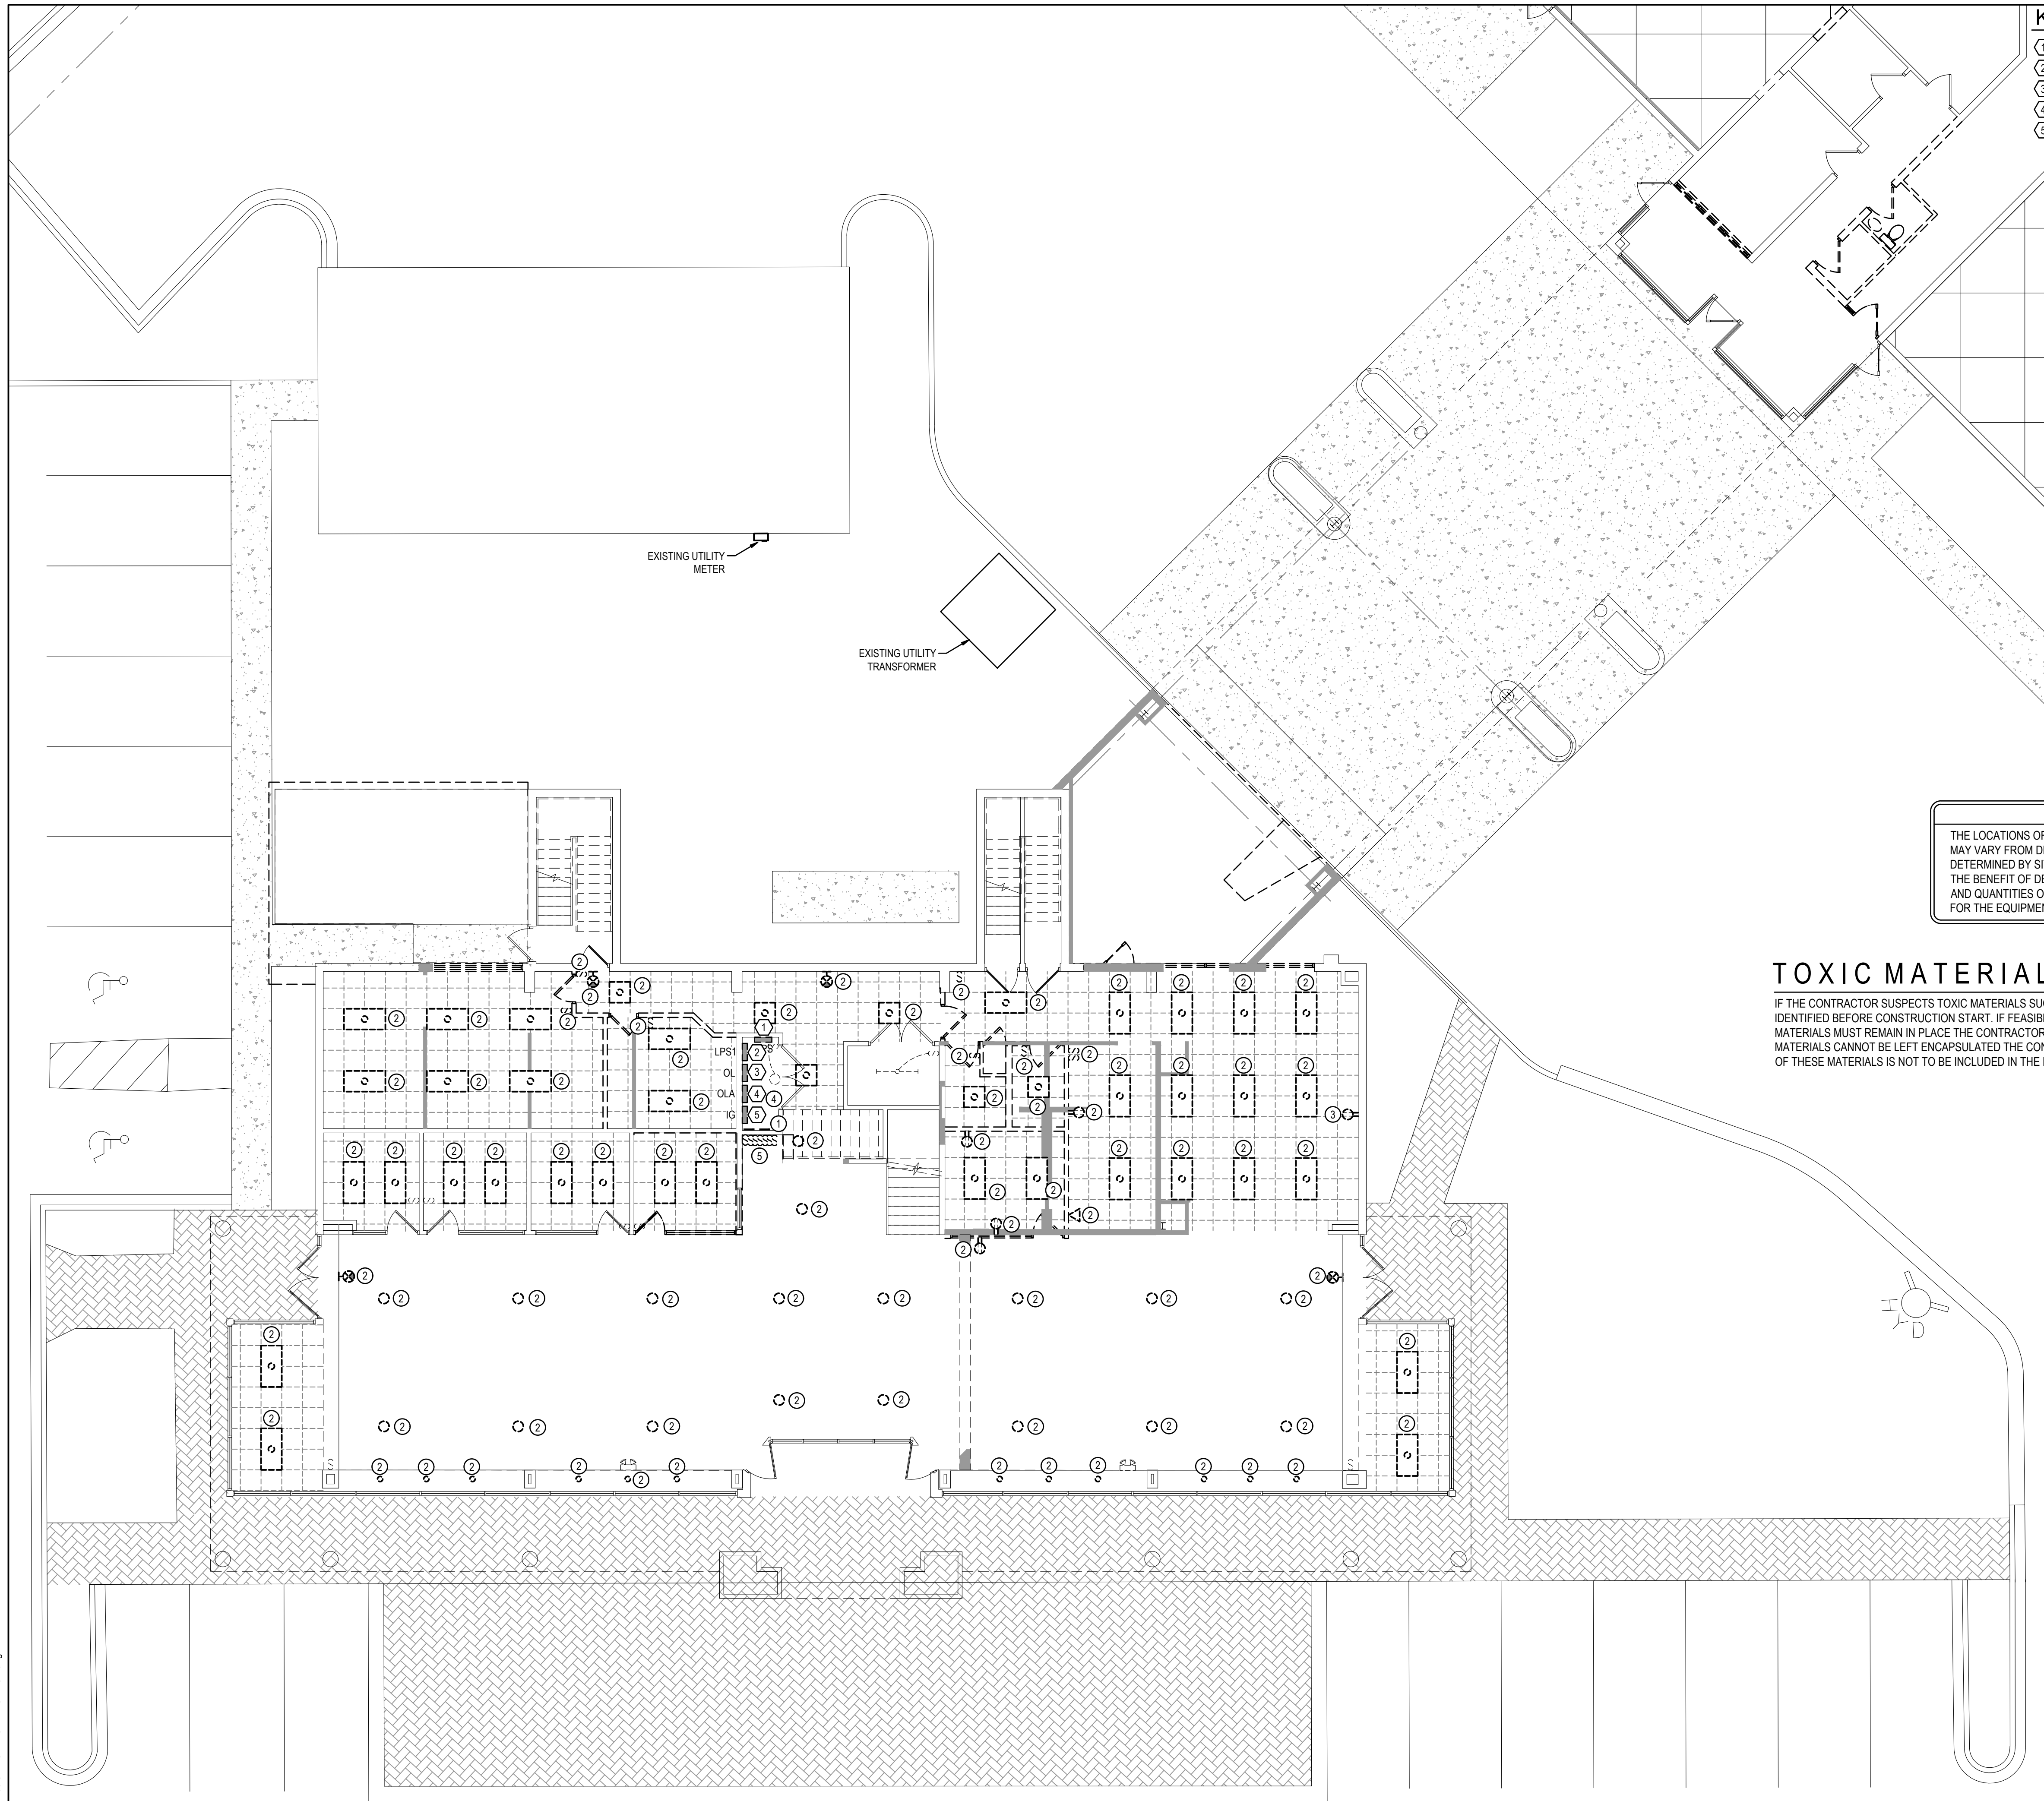

KEYNOTES

- 1 EX. PANEL-MPS
- 2 EX PANEL-LPS1
- 3 EX PANEL-OL
- 4 EX PANEL-OLA
- 5 EX PANEL-IG

NOTES:

- ① EXISTING TELECOM EQUIPMENT TO REMAIN.
- ② EXISTING DEVICE TO BE REMOVED: IF END OF LINE DEVICE, REMOVE CONDUCTORS AND CONDUIT BACK TO NEXT DEVICE OR EXISTING PANEL AND LABEL BREAKER AS SPARE; IF DEVICE BEING REMOVED IS NOT END-OF-LINE, MAINTAIN EXISTING CIRCUIT CONTINUITY.
- ③ REMOVE EXISTING DEVICE AND REPLACE WITH NEW TVSS RECEPTACLE AS INDICATED ON NEW WORK PLANS.
- ④ EXISTING PANELBOARDS TO REMAIN, ANY CIRCUITS VACATED DURING DEMOLITION TO BE LABELED AS "SPARE".
- ⑤ BANK OF 7 SWITCHES CONTROLLING SALES FLOOR LIGHTING: REMOVE SWITCHES AND THE CONDUCTORS BACK TO SOURCE.

 
SPECIAL DEMOLITION NOTE

THE LOCATIONS OF ALL ELECTRICAL EQUIPMENT INDICATED (FIXTURES & DEVICES) MAY VARY FROM DRAWING. EXISTING CONDITIONS AND DEMOLITION WORK WAS DETERMINED BY SITE OBSERVATION AND REVIEW OF EXISTING DOCUMENTS WITHOUT THE BENEFIT OF DESTRUCTIVE INVESTIGATION. VERIFY ACTUAL LOCATIONS, TYPES, AND QUANTITIES OF EQUIPMENT AND APPLY DEMOLITION NOTES AS APPROPRIATE FOR THE EQUIPMENT AND ROOM OR AREA.

TOXIC MATERIAL DEMOLITION NOTE

IF THE CONTRACTOR SUSPECTS TOXIC MATERIALS SUCH AS ASBESTOS AND/OR LEAD-BASED PAINT WILL BE AFFECTED AS PART OF THIS PROJECT THESE SHALL BE IDENTIFIED BEFORE CONSTRUCTION START. IF FEASIBLE, OTHERS WILL TEST FOR AND REMOVE THESE MATERIALS PRIOR TO CONSTRUCTION START. IF THESE MATERIALS MUST REMAIN IN PLACE THE CONTRACTOR WILL MINIMIZE THE DISTURBANCE OF SUCH MATERIALS LEAVING THEM ENCAPSULATED. WHERE SUCH MATERIALS CANNOT BE LEFT ENCAPSULATED THE CONTRACTOR SHALL INCLUDE TESTING OF THESE SPECIFIED AREAS AS PART OF THE PROJECT SCOPE. REMOVAL OF THESE MATERIALS IS NOT TO BE INCLUDED IN THE PROJECT SCOPE.

SALES BLDG. DEMOLITION



HG Engineers
 142 Eglin Parkway SE
 Fort Walton Beach, Florida, 32548
 E-mail: office@hgengineers.com
 Ph: 850.243.6723
 Fl. Authorization No.00006680
 Christopher A. Garick; FL. PE No.53
 Thomas A. Alexander; FL. PE No.7
 Daniel J. White; FL. PE No.73790
 Caleb W. Leonard; FL. PE No.9178


25024
Job No.

Job No.

16 JUL 2026 FOR PERMIT

SALES BLDG.
DEMOLITION

1.00

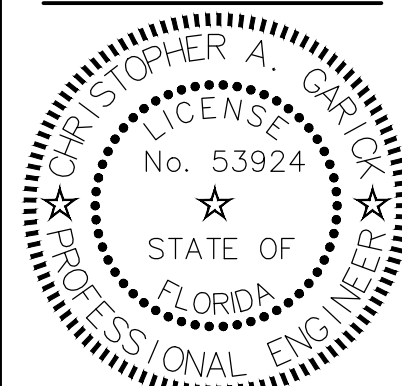

DATE: JUL 16, 2026
DRAWN BY: R.ENGLE / C.PASTORIUS

PROJECT NO: 2519

REVISIONS:

--	--

A blank coordinate plane with a horizontal x-axis and a vertical y-axis intersecting at the origin. The axes are represented by thin black lines.

SCHEMATIC REVIEW


Step One Automotive Group CDJR Renovation

541 MARY ESTHER CUT-OFF NW
FOR WALTON BEACH, FLORIDA

jdf+
architecture llc

201 hollywood blvd ne | ft walton beach | florida | 32548
850.496.2166 | www.jdfarchitecture.com | AA26002502

 These plans and the ideas and concepts contained herein including digital information are the property of jdf architecture and are not to be reproduced, copied, modified, or changed in any form or manner without the express written permission and consent of jdf architecture. copyright © 2026



SPECIAL DEMOLITION NOTE

THE LOCATIONS OF ALL ELECTRICAL EQUIPMENT INDICATED (FIXTURES & DEVICES) MAY VARY FROM DRAWING. EXISTING CONDITIONS AND DEMOLITION WORK WAS DETERMINED BY SITE OBSERVATION AND REVIEW OF EXISTING DOCUMENTS WITHOUT THE BENEFIT OF DESTRUCTIVE INVESTIGATION. VERIFY ACTUAL LOCATIONS, TYPES, AND QUANTITIES OF EQUIPMENT AND APPLY DEMOLITION NOTES AS APPROPRIATE FOR THE EQUIPMENT AND ROOM OR AREA.


TOXIC MATERIAL DEMOLITION NOTE

IF THE CONTRACTOR SUSPECTS TOXIC MATERIALS SUCH AS ASBESTOS AND/OR LEAD-BASED PAINT WILL BE AFFECTED AS PART OF THIS PROJECT THESE SHALL BE IDENTIFIED BEFORE CONSTRUCTION START. IF FEASIBLE, OTHERS WILL TEST FOR AND REMOVE THESE MATERIALS PRIOR TO CONSTRUCTION START. IF THESE MATERIALS MUST REMAIN IN PLACE THE CONTRACTOR WILL MINIMIZE THE DISTURBANCE OF SUCH MATERIALS LEAVING THEM ENCAPSULATED. WHERE SUCH MATERIALS CANNOT BE LEFT ENCAPSULATED THE CONTRACTOR SHALL INCLUDE TESTING OF THESE SPECIFIED AREAS AS PART OF THE PROJECT SCOPE. REMOVAL OF THESE MATERIALS IS NOT TO BE INCLUDED IN THE PROJECT SCOPE.

SHOP BLDG. DEMOLITION

1/8" = 1'-0"

0 4' 7'-11 255/256" 15'-11 127/128"

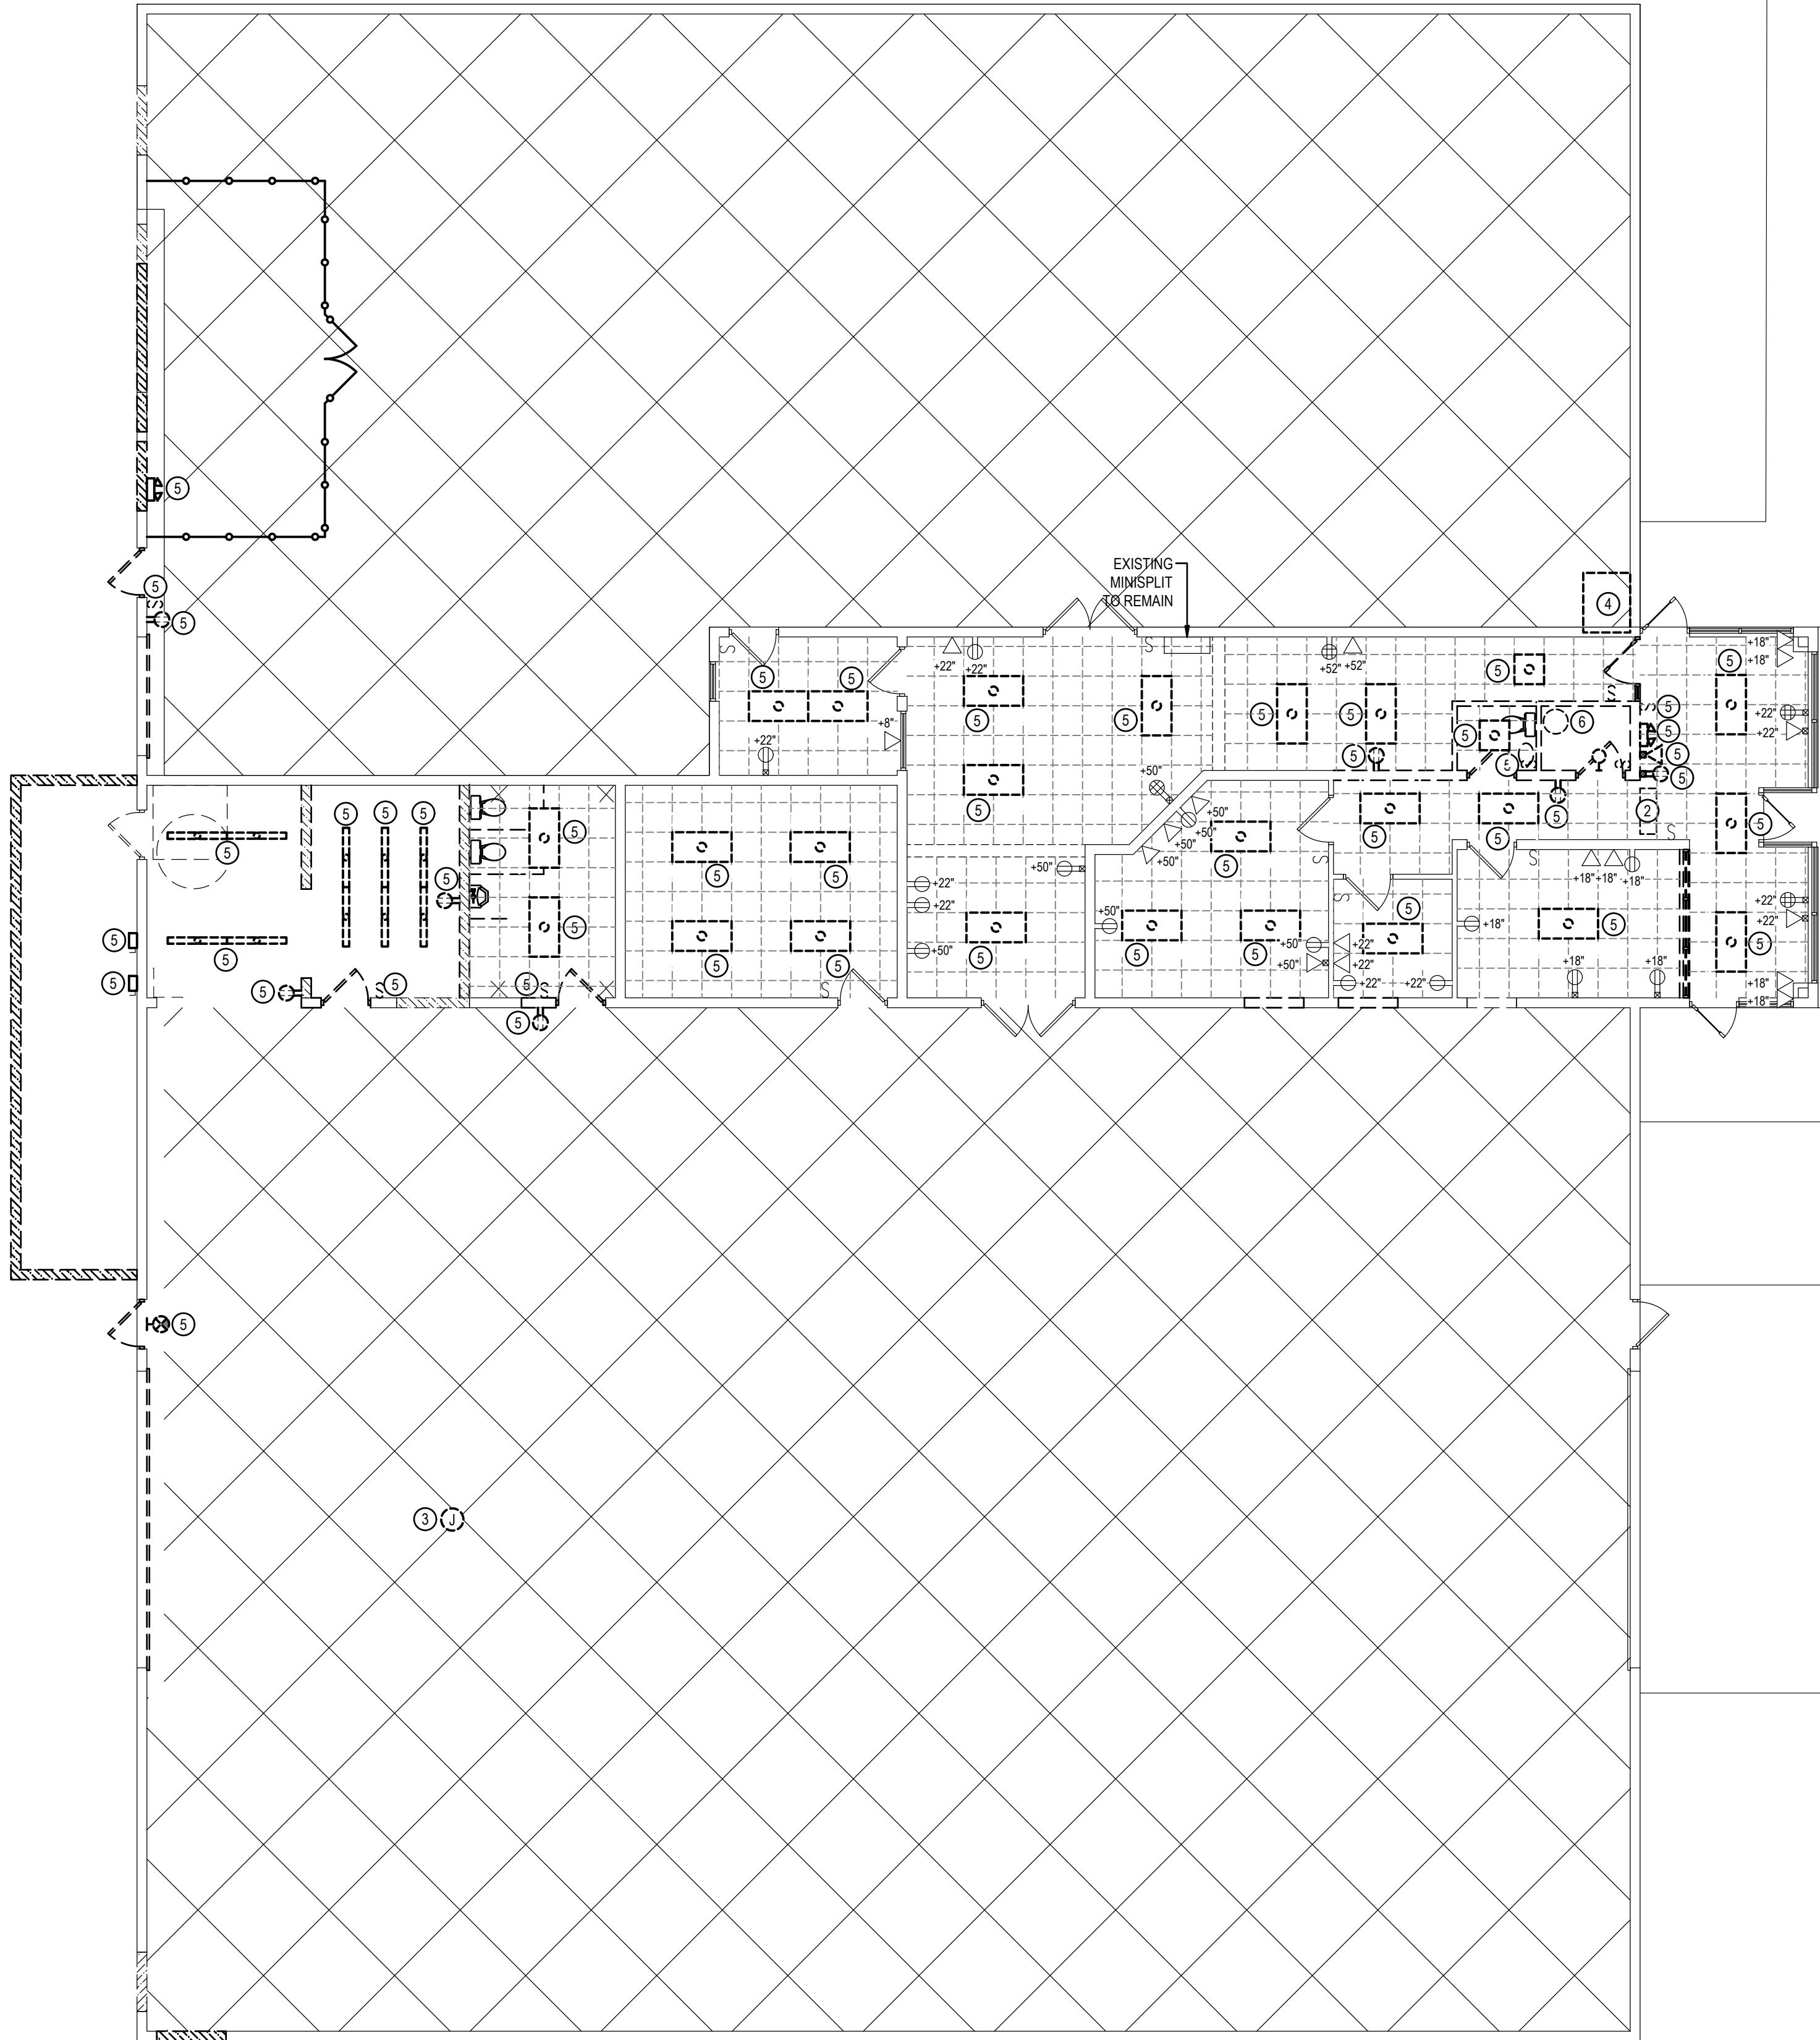

- NOTES:**
- 1 REMOVE EXISTING POLE LIGHT. REMOVE EXISTING CONDUCTORS TO SOURCE, LABEL BREAKER AS SPARE.
 - 2 REMOVE EXISTING CONDUCTORS TO EXISTING MINI-SPLIT MECHANICAL UNIT.
 - 3 REMOVE EXISTING ROLL-UP DOOR MOTOR/CONDUCTORS, AND CONTROLS. LABEL EXISTING BREAKER AS "SPARE".
 - 4 EXISTING TELECOM EQUIPMENT LOCATED ON 2ND FLOOR TO REMAIN.
 - 5 EXISTING DEVICE TO BE REMOVED. IF END OF LINE DEVICE, REMOVE CONDUCTORS AND CONDUIT BACK TO NEXT DEVICE OR EXISTING PANEL AND LABEL BREAKER AS SPARE. IF DEVICE BEING REMOVED IS NOT END-OF-LINE, MAINTAIN EXISTING CIRCUIT CONTINUITY.
 - 6 REMOVE EXISTING CONDUCTORS TO EXISTING WATER HEATER MECHANICAL UNIT.

- GENERAL NOTES**
1. CEILING GRID IN SHOP BLDG TO BE REMOVED BY OTHERS.
 2. REMOVE ALL ELECTRICAL CONDUIT AND CONDUCTORS ABOVE EXISTING CEILING GRID BEING REMOVED.
 3. ALL ORIGINAL PANEL CIRCUIT ORIGINATIONS ARE TO BE REUSED IN THESE SPACES FOR NEW WORK.
 4. CONNECT NEW LIGHTS AND NEW POWER / COMMUNICATION DEVICES WITH NEW CONDUCTORS IN 1/2" EMT CONDUIT (UPSIZED CONDUIT AS REQUIRED) AS INDICATED ON NEW WORK PLANS.
 5. PAINT ALL CONDUIT TO MATCH ADJACENT CEILING FINISH.
 6. PROVIDE NEW POWER/TELECOM DEVICES IN EXISTING LOCATIONS AS INDICATED ON NEW WORK PLANS.

16 JUL 2026 FOR PERMIT



HG Engineers
142 Eglon Parkway SE
Fort Walton Beach, Florida, 32548
E-mail: office@hgengineers.com
Ph: 850.243.6723
FL Authorization No.00006680


25024
Job No.

SHOP BLDG. DEMOLITION

DATE: JUL 16, 2026
DRAWN BY: R.ENGLE / C.PASTORIUS

PROJECT NO: 2519

REVISIONS:

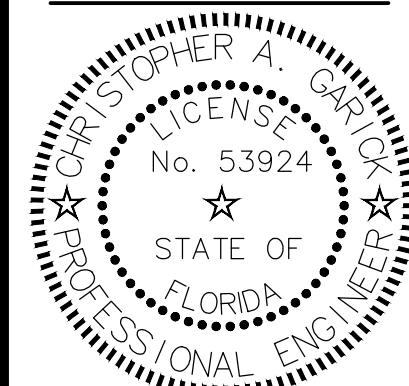

**Step One Automotive Group
CDJR Renovation**

541 MARY ESTHER CUT-OFF NW
FOR WALTON BEACH, FLORIDA

D2.00

**Step One Automotive Group
CDJR Renovation**

jdf+ architecture llc

201 hollywood blvd ne | ft. walton beach | florida | 32548
850.496.2166 | www.jdfarchitecture.com | A456002502

These plans and the ideas and concepts contained herein including digital information are the property of jdf architecture and are not to be reproduced, copied, modified, or changed in any form or manner without the express written permission and consent of jdf architecture. copyright © 2026.