
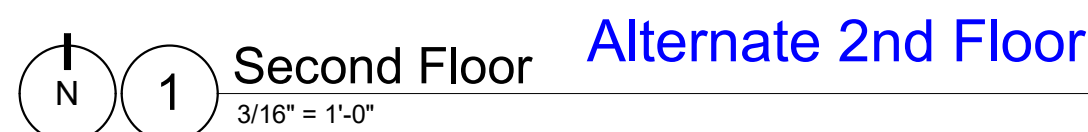


[illegible]

THESE DRAWINGS AND RENDERINGS ARE INSTRUMENTS OF SERVICE. THE DRAWINGS AND ASSOCIATED COPIES THEREOF INCLUDING ELECTRONIC MEDIA AND CADD FILES ARE THE PROPERTY OF AIA. THEIR USE, REPRESENTATION OR REPRODUCTION FOR ANY PURPOSE EXCEPT BY WRITTEN AGREEMENT WITH THE ARCHITECT IS PROHIBITED. THIS COPYRIGHT NOTIFICATION SHALL BE TRUE AS IF DIRECTLY PLACED ON EACH DRAWING, EXHIBIT, OR RENDERING ON THIS DOCUMENT AND SHALL NOT BE REMOVED FROM THESE DOCUMENTS.

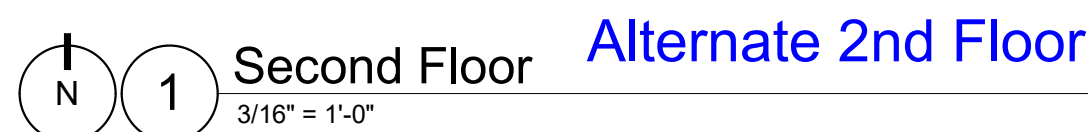

What

[illegible]

Client:	Florida State University Tallahassee, Florida
Job Title:	Kellogg Building Remodeling Phase 2, Volume 3 (of 3)



Seal:

ALW

Architects Lewis + Whitlock
206 West Virginia St.
Tallahassee, Florida 32301
850.942.1718
www.think3d.net

Description:
Second Floor Plan

Sheet No.:

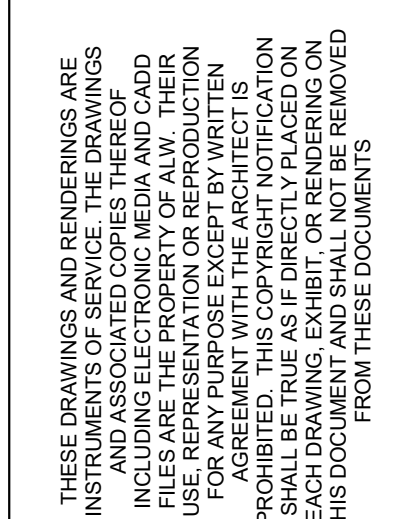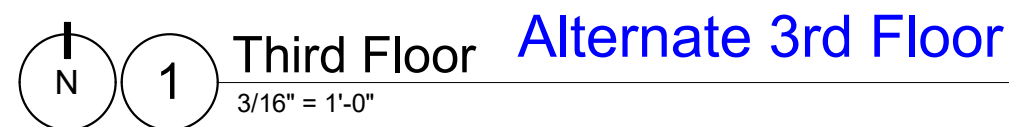

Client: **Florida State University**
Tallahassee, Florida

Job Title: **Kellogg Building Remodel
Phase 2, Volume 3 (of 3)**

Consultant:	Project #: 22470
	Phase: 100% Construction Documents

Seal:




Architects Lewis + Whitlock 206 West Virginia St. Tallahassee, Florida 32301 850.942.1718 www.think3d.net	
Description: Third Floor Plan	

Sheet No.:

M103

1.1
1
2
3
4
5
5.1

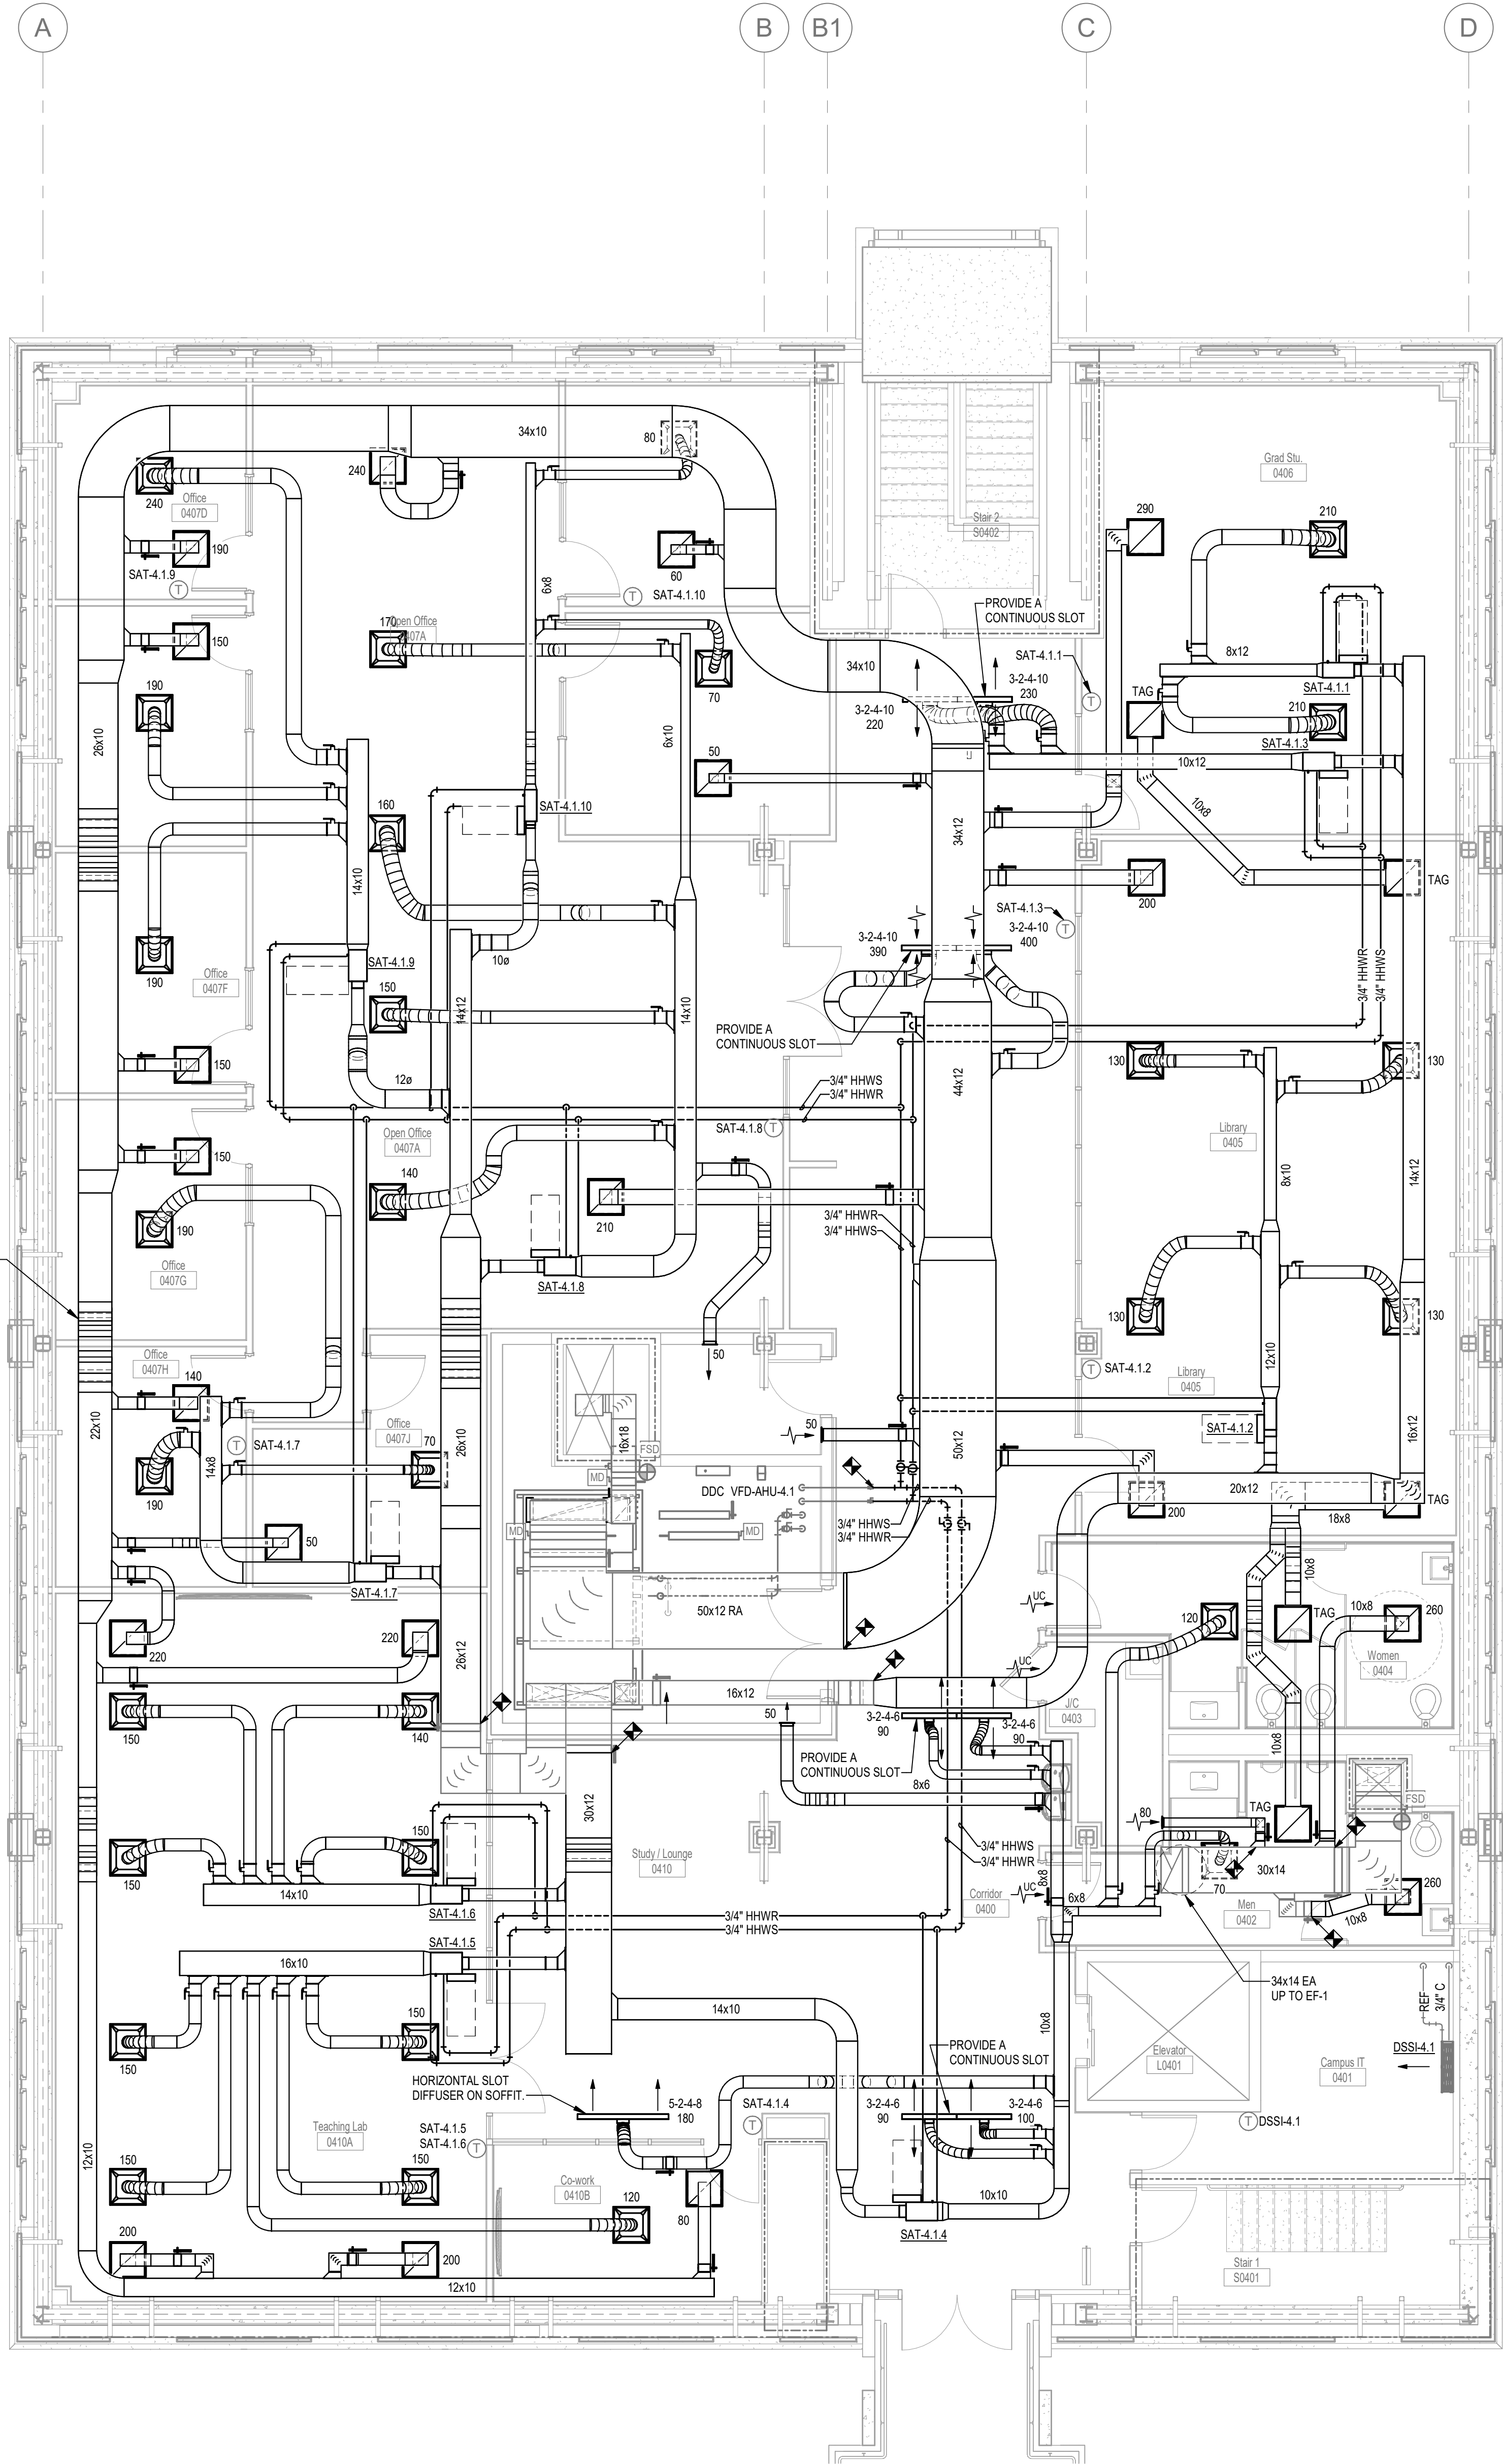

DUCTLESS SPLIT SYSTEM TYPES			
TYPE			D1
DESCRIPTION			COOLING ONLY
PERFORMANCE - (NOTES 1 & 2)			
	NOMINAL CAPACITY	TONS	2
	TOTAL COOLING CAPACITY	BTUH	22,400
	SENSIBLE COOLING CAPACITY	BTUH	16,360
	HEATING CAPACITY @ 47°F	BTUH	N/A
	HEATING CAPACITY @ 17 °F	BTUH	N/A
	AIR FLOW RATE (HIGH - LOW)	CFM	716 - 467
	SEER	BTU / W•HR	21.0
	HSPF	BTU / W•HR	N/A
INDOOR UNIT DATA			
	FILTERS		1" WASHABLE
	CONDENSATE DRAIN SIZE		3/4
	ELECTRICAL CHARACTERISTICS	V / PH	N/A
	MINIMUM CIRCUIT AMPACITY	AMPS	N/A
	MAXIMUM OVERLOAD PROTECTION	AMPS	N/A
	WEIGHT	LBS.	30.5
OUTDOOR UNIT DATA			
	COMPRESSOR TYPE		INVERTER
	ELECTRICAL CHARACTERISTICS	V / PH	208 / 1
	MINIMUM CIRCUIT AMPACITY	AMPS	16.3
	MAXIMUM OVERLOAD PROTECTION	AMPS	20
	WEIGHT	LBS.	101
MAX REFRIGERANT LINE LENGTH		FT	99
REFRIGERANT TYPE			R32
MANUFACTURER			DAIKIN
MODEL NUMBER (INDOOR UNIT)			FTXF24AXVJU
MODEL NUMBER (OUTDOOR UNIT)			RKF24AXVJU
DETAIL REFERENCE			F_HJM501
NOTES:			
1	COOLING CAPACITY RATED @ 95 °F AMBIENT, 80 °Fdb / 67 °Fwb ENTERING AIR TEMPERATURE.		
2	HEATING CAPACITY RATED @ 47 °Fdb / 43 °Fwb AMBIENT, 70 °Fdb ENTERING AIR TEMPERATURE.		
3	UNIT SHALL BE CAPABLE OF OPERATION FOR AMBIENT TEMPERATURES DOWN TO 14°F		
4	REFRIGERANT PIPING SHALL BE SIZED BY MANUFACTURER.		
5	PROVIDE INTEGRAL CONDENSATE SENSOR TO SHUT UNIT OFF IF HIGH CONDENSATE LEVELS ARE DETECTED IN THE DRAIN PAN.		

DUCTLESS SPLIT SYSTEMS

INDOOR UNIT DESIGNATION		DSSI-1.2
OUTDOOR UNIT DESIGNATION		DSSO-1.2
	SCHEDULED TYPE	D
	DESCRIPTION	COOLING ONLY
	FAN SPEED	MEDIUM
	NOTES	1, 3, 4
NOTES: 1 PROVIDE ELECTRONIC PROGRAMMABLE THERMOSTAT. 3 PROVIDE CONDENSATE PUMP. 4 INDOOR UNIT RECEIVES POWER FROM OUTDOOR UNIT. PROVIDE FIELD SUPPLIED INTERCONNECTED WIRING PER MANUFACTURER'S INSTRUCTIONS.		




BUILDING AIR BALANCE - EQUIPMENT SUMMARY

OUTSIDE AIR SOURCE	CFM	EXHAUST SOURCE	CFM
DOAS-B.1	9,390	EF-5.1	3,000
AHU-FUTURE	-2,100		
TOTAL	7,290	TOTAL	3,000
BUILDING PRESSURIZATION			(+) 4,290




VENTILATION RATE

		EXHAUST AIR	OUTSIDE AIR	
TYPE OF SPACE		CFM / FT ²	CFM / PERSON	CFM / FT ²
B R E A K R O O M C O M M O N C O R R I D O R S C O N F E R E N C E / M E E T I N G C O R R I D O R S J A N I T O R / T R A S H L E C T U R E / C L A S S R O O M L I B R A R I E S O F F I C E / S P A C E R E C E P T I O N / A R E A S S T O R A G E / R O O M S / (U N O C C U P I E D) T O I L E T / (P U B L I C)	B R E A K R O O M S		5	0.06
	C O M M O N C O R R I D O R S		0	0.06
	C O N F E R E N C E / M E E T I N G		5	0.06
	C O R R I D O R S		0	0.06
	J A N I T O R / T R A S H	1	0	0.00
	L E C T U R E / C L A S S R O O M		7.5	0.06
	L I B R A R I E S		5	0.12
	O F F I C E / S P A C E		5	0.06
	R E C E P T I O N / A R E A S		5	0.06
	S T O R A G E / R O O M S / (U N O C C U P I E D)		0	0.00
	T O I L E T / (P U B L I C)	50/70	0	0.00
NOTES: 2 VENTILATION RATES CALCULATED PER REQUIREMENTS OF FBC, MECHANICAL 2023. 3 EXHAUST IS PER WATER CLOSET AND/OR URINAL. HIGHER RATE USED.				

SUPPLY AIR TERMINALS - SHUTOFF WITH HOT WATER REHEAT																								
Alternate Basement												Alternate 2nd Floor												
DESIGNATION		SAT-B.1.1	SAT-B.1.2	SAT-B.1.3	SAT-B.1.4	SAT-B.2.1	SAT-B.2.2	SAT-B.2.3	SAT-B.2.4	SAT-B.2.5	SAT-B.2.6	SAT-B.2.7	SAT-B.2.8	SAT-2.1.1	SAT-2.1.2	SAT-2.1.3	SAT-2.1.4	SAT-2.1.5	SAT-2.1.6	SAT-2.1.7	SAT-2.1.8	SAT-2.1.9	SAT-2.1.10	
AIR VALVE																								
	NOMINAL DIAMETER	IN.	6	8	6	8	8	6	8	10	12	6	8	10	8	8	8	6	8	6	6	8	6	8
	MAX TOTAL UNIT PRESSURE DROP	IN. WG	0.25	0.25	0.25	0.25	0.25	0.25	0.25	0.40	0.30	0.25	0.25	0.40	0.25	0.25	0.25	0.25	0.25	0.25	0.25	0.25	0.25	
AIR FLOW RATES																								
	MAXIMUM COOLING	CFM	370	710	190	700	520	310	550	1,090	1,480	250	550	1,000	440	660	450	380	610	250	290	420	240	460
	MINIMUM COOLING	CFM	120	220	80	210	160	100	170	330	450	80	170	300	150	200	150	120	190	80	90	150	80	150
	MAXIMUM HEATING	CFM	120	220	80	330	160	100	170	330	450	80	170	300	150	200	150	120	190	80	90	150	80	150
	MINIMUM HEATING	CFM	120	220	80	210	160	100	170	330	450	80	170	300	150	200	150	120	190	80	90	150	80	150
	UNOCCUPIED MINIMUM	CFM	80	150	80	240	150	80	150	240	400	80	150	240	150	150	150	150	150	80	80	150	80	80
HEATING COIL DATA - HYDRONIC																								
	HEATING CAPACITY	MBTUH	4.3	8.0	2.9	11.9	5.8	3.6	6.2	11.9	16.3	2.9	6.2	10.9	5.4	7.2	5.4	4.3	6.9	2.9	3.3	5.4	2.9	5.4
	AIR ENTERING HEATING COIL	°F	52	52	52	52	52	52	52	52	52	52	52	52	52	52	52	52	52	52	52	52	52	52
	AIR LEAVING HEATING COIL	°F	84.9	84.9	84.9	84.9	84.9	84.9	84.9	84.9	84.9	84.9	84.9	84.9	84.9	84.9	84.9	84.9	84.9	84.9	84.9	84.9	84.9	84.9
	HHW ENTERING & LEAVING TEMPERATURE	°F - °F	140 - 110	140 - 110		WATER FLOW	GPM	0.5	0.5	0.5	0.8	0.5	0.5	0.5	0.8	1.1	0.5	0.5	0.7	0.5	0.5	0.5	0.5	0.5	0.5	0.5	0.5	0.5	0.5
	RUNOUT PIPE SIZE	IN.	3/4	3/4	3/4	3/4	3/4	3/4	3/4	3/4	3/4	3/4	3/4	3/4	3/4	3/4	3/4	3/4	3/4	3/4	3/4	3/4	3/4	3/4
	MINIMUM # OF ROWS	#	1	1	1	1	1	1	1	1	1	1	1	1	1	1	1	1	1	1	1	1	1	1
	CONTROL VALVE TYPE		2-WAY	2-WAY	2-WAY	2-WAY	2-WAY	2-WAY	2-WAY	2-WAY	2-WAY	2-WAY	2-WAY	2-WAY	2-WAY	2-WAY	2-WAY	2-WAY	2-WAY	2-WAY	2-WAY	2-WAY	2-WAY	2-WAY
SOUND CRITERIA - (NOTE 1)																								
	INTEGRAL SILENCER		NO	NO	NO	NO	NO	NO	NO	NO	NO	NO	NO	NO	NO	NO	NO	NO	NO	NO	NO	NO	NO	NO
	MAX DISCHARGE SOUND RATING	NC	30	30	30	30	30	30	30	30	25	30	30	30	30	30	30	30	30	30	30	30	30	30
	MAX RADIATED SOUND RATING	NC	25	25	25	25	25	25	25	30	30	25	30	30	25	25	25	25	25	25	25	25	25	25
NOTES:																								
1	BASED ON 1.0 IN. WG PRESSURE DROP ACROSS UNIT																							

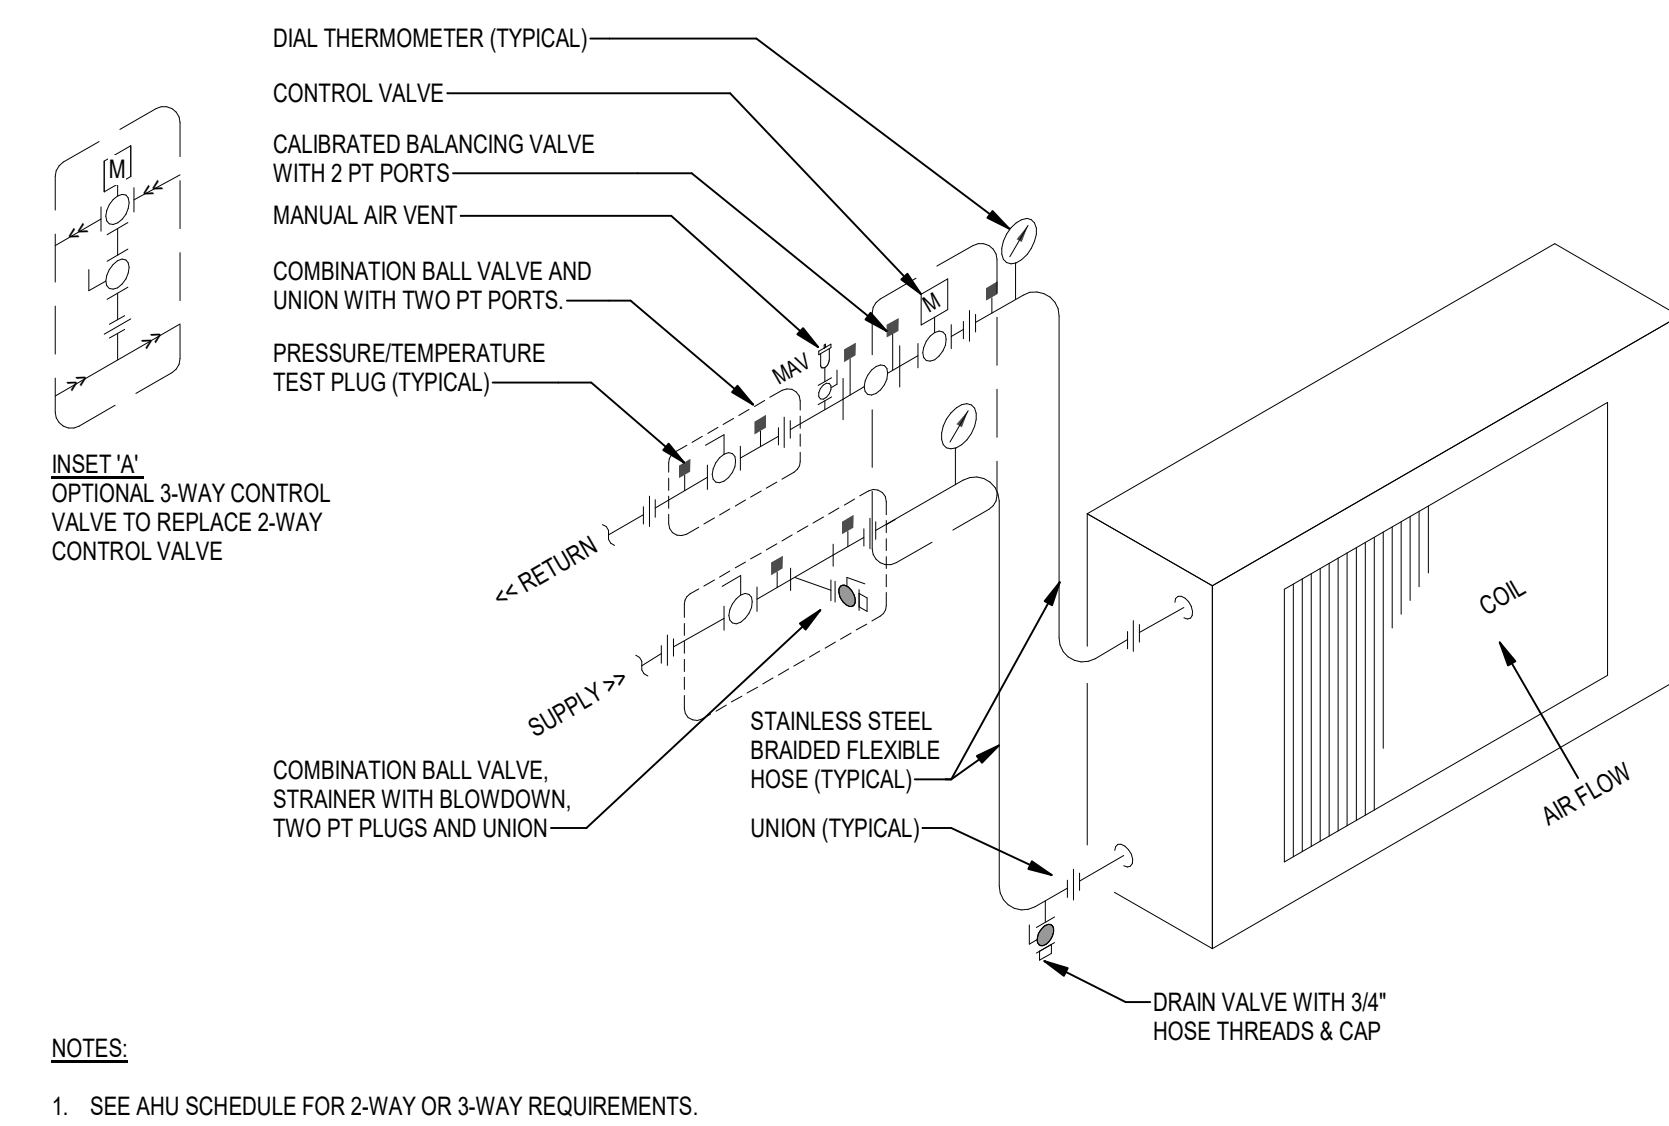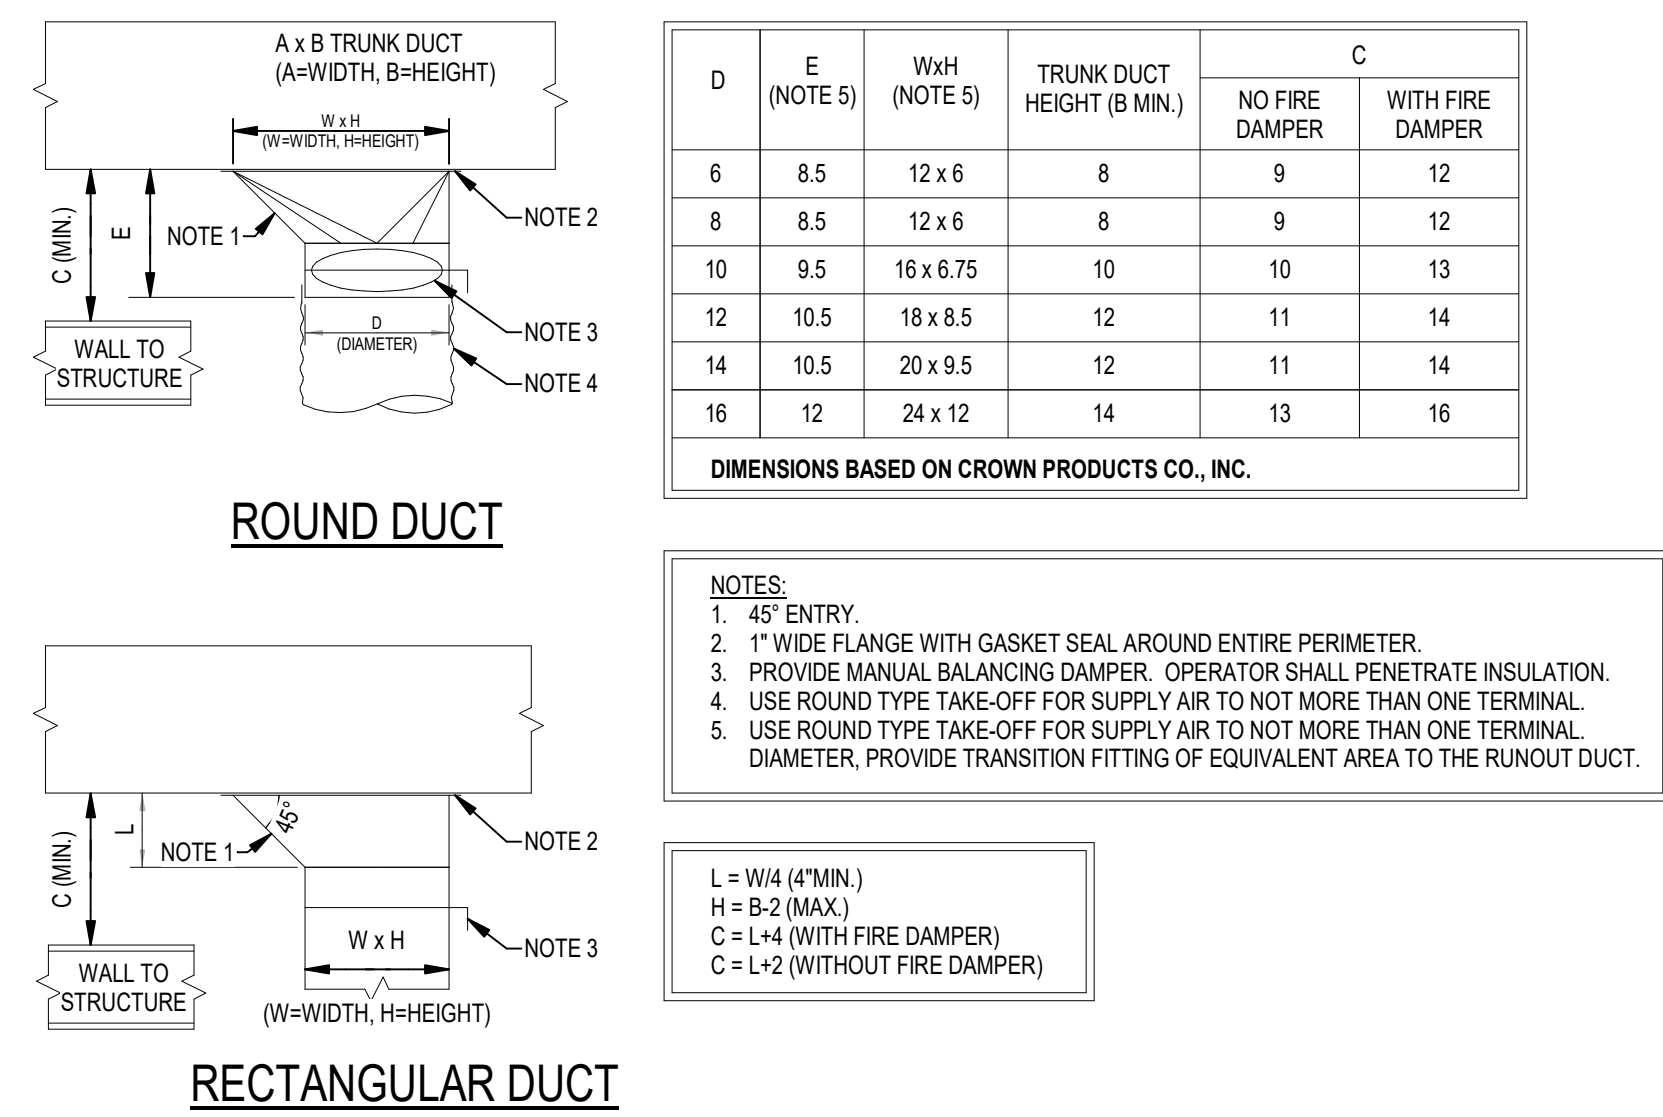
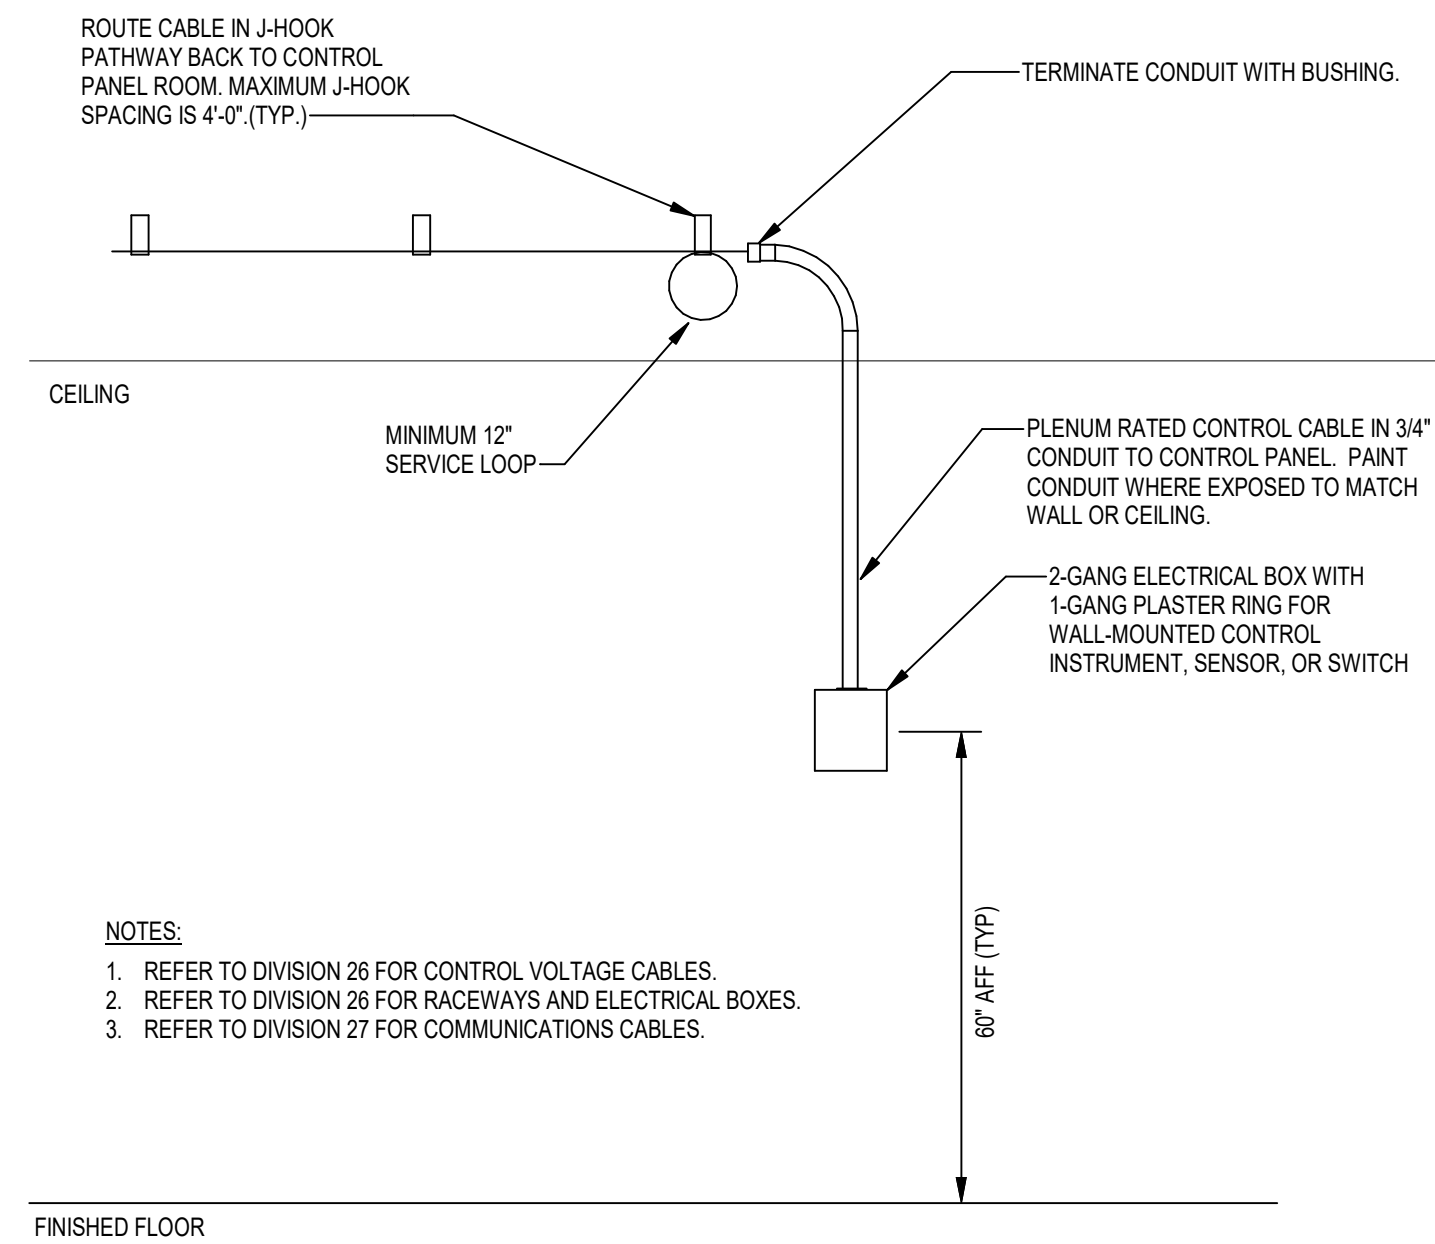


G	WALL-MOUNTED CONTROL DEVICE ROUGH-IN
----------	---

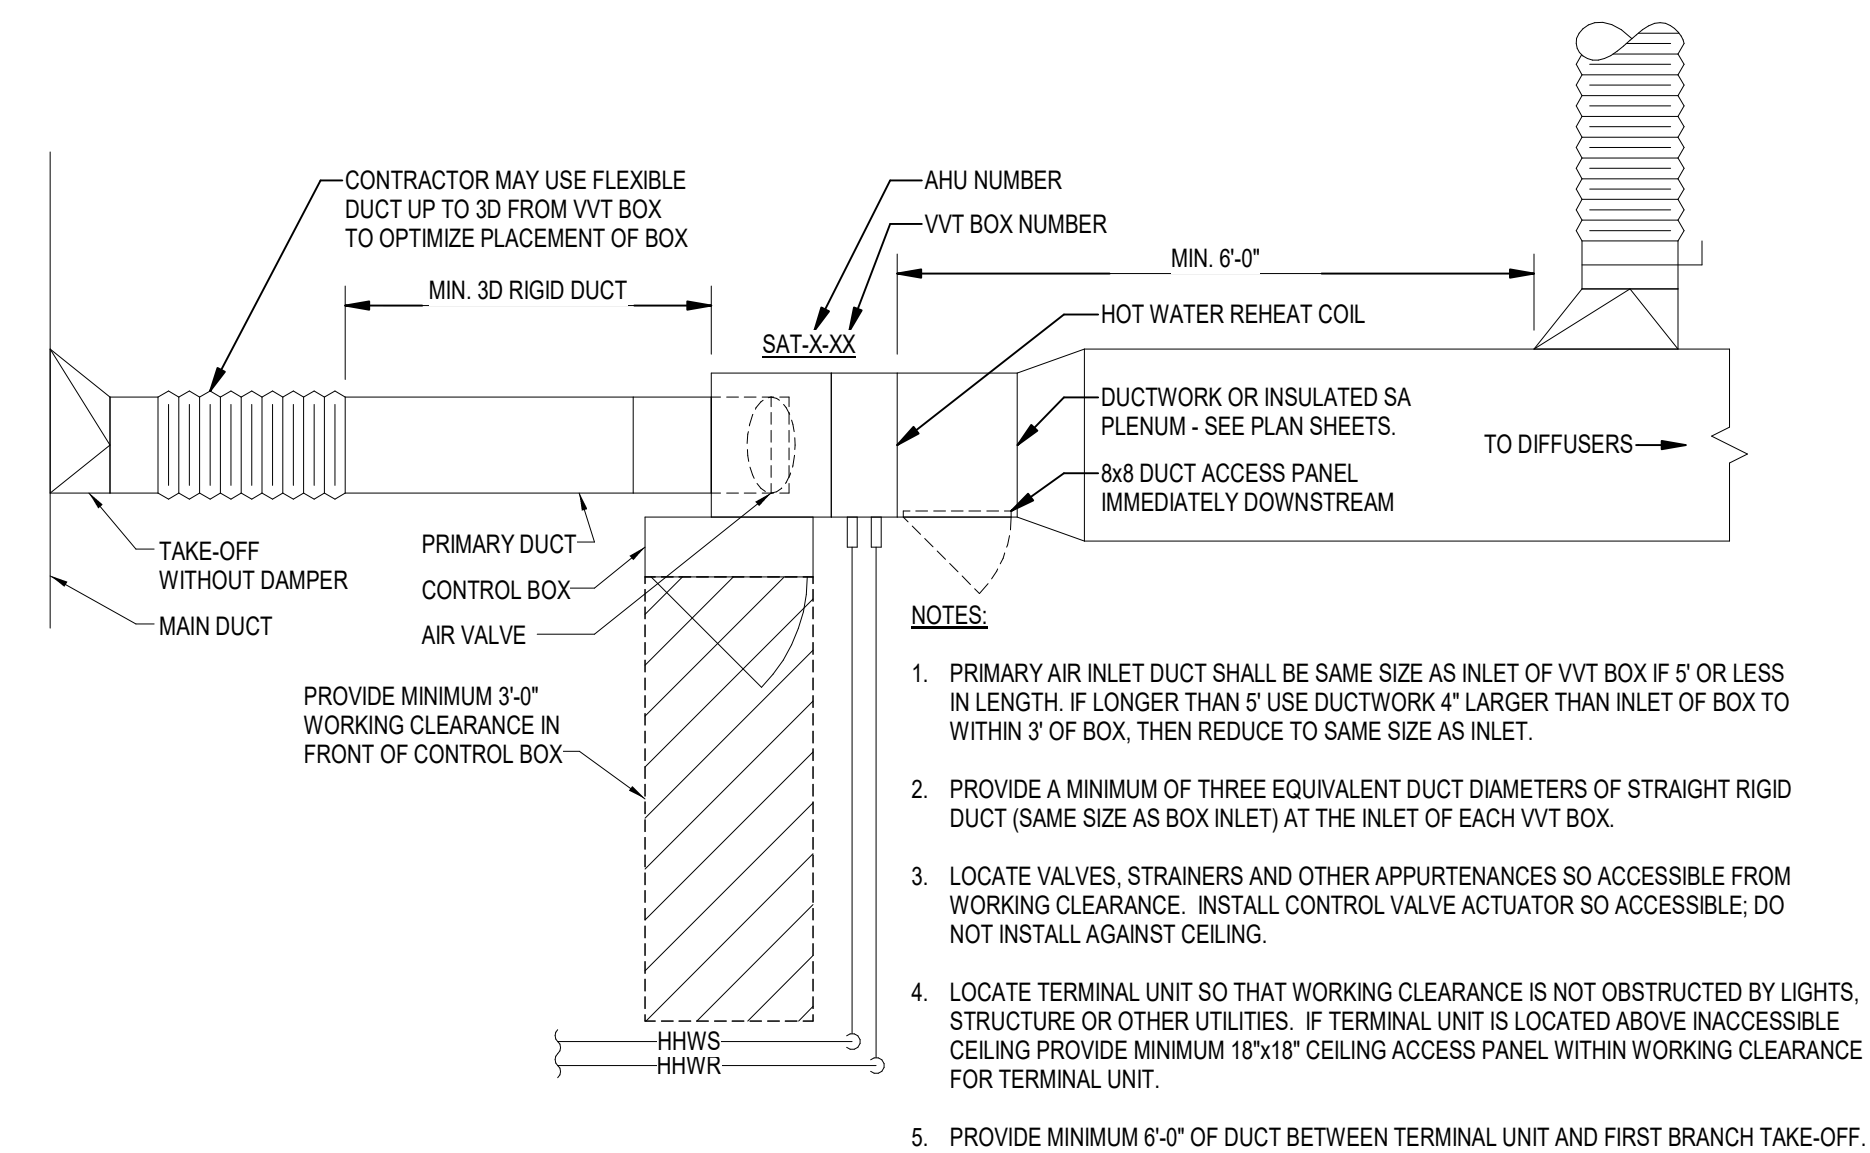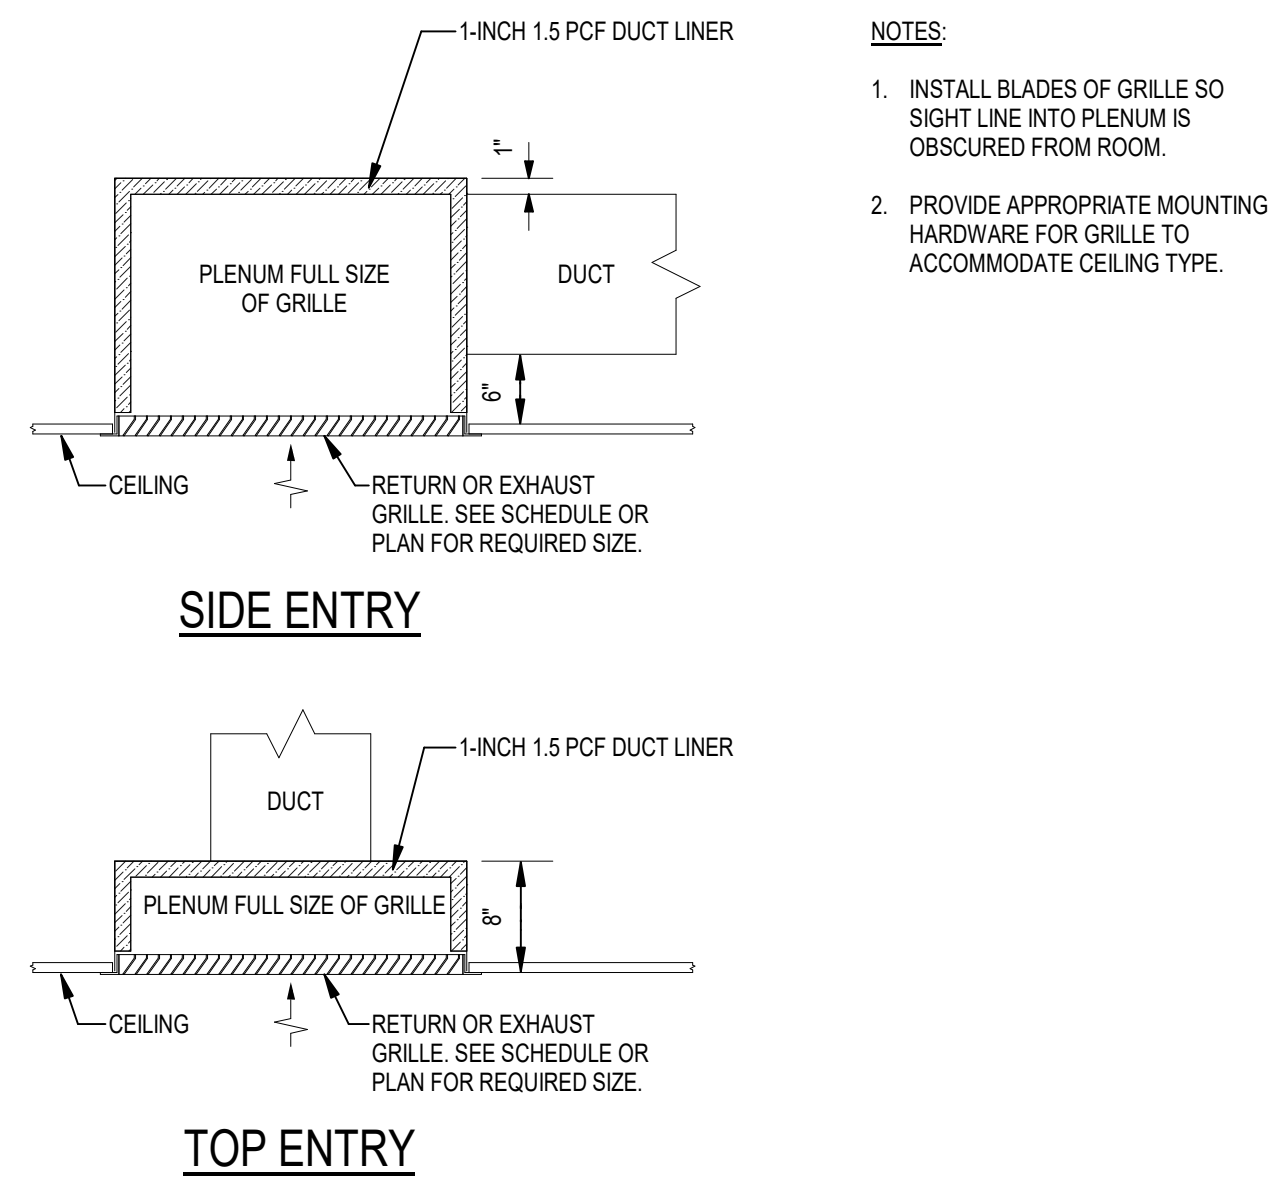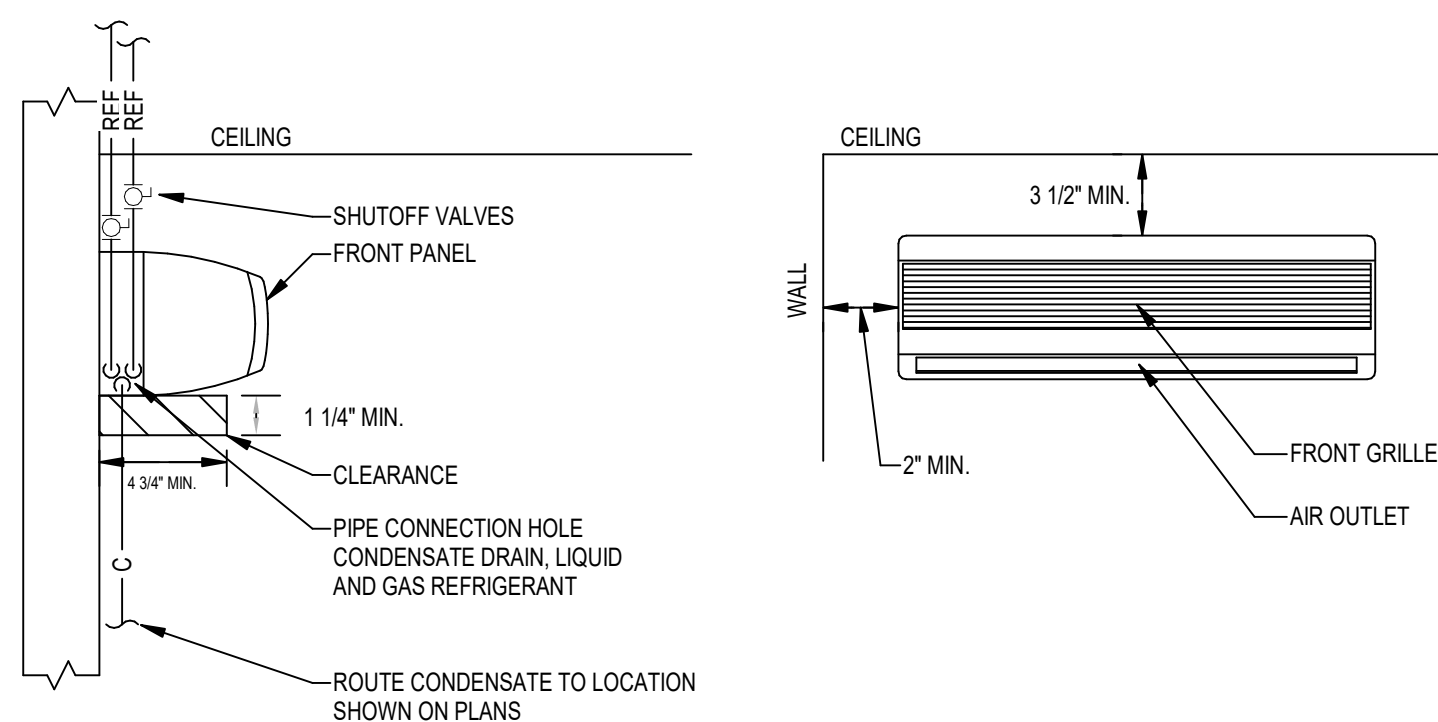


H	DUCTLESS - WALL MOUNTED INDOOR UNIT
---	-------------------------------------

E	RETURN OR EXHAUST CEILING GRILLE
---	----------------------------------

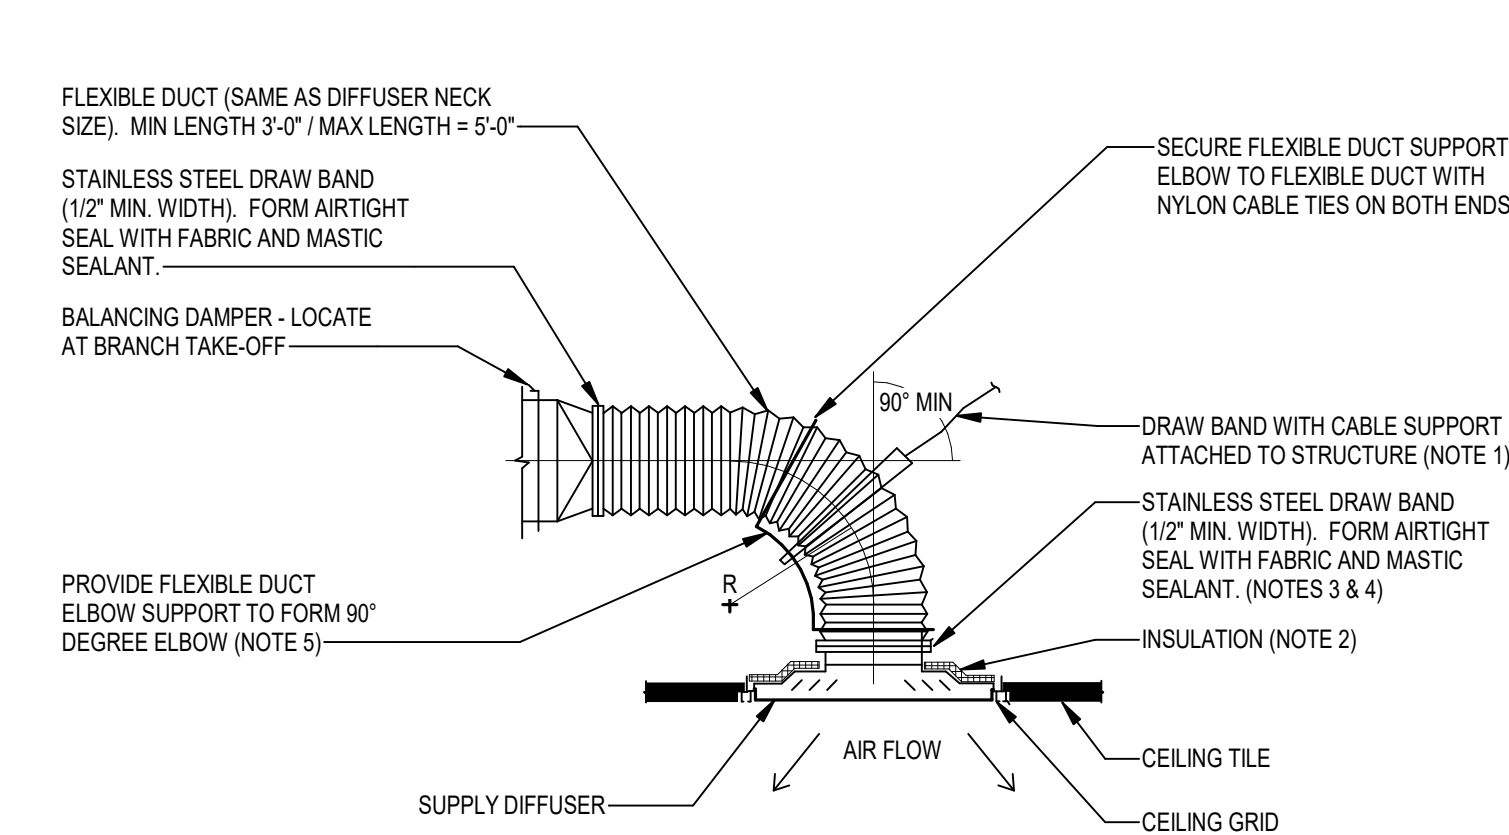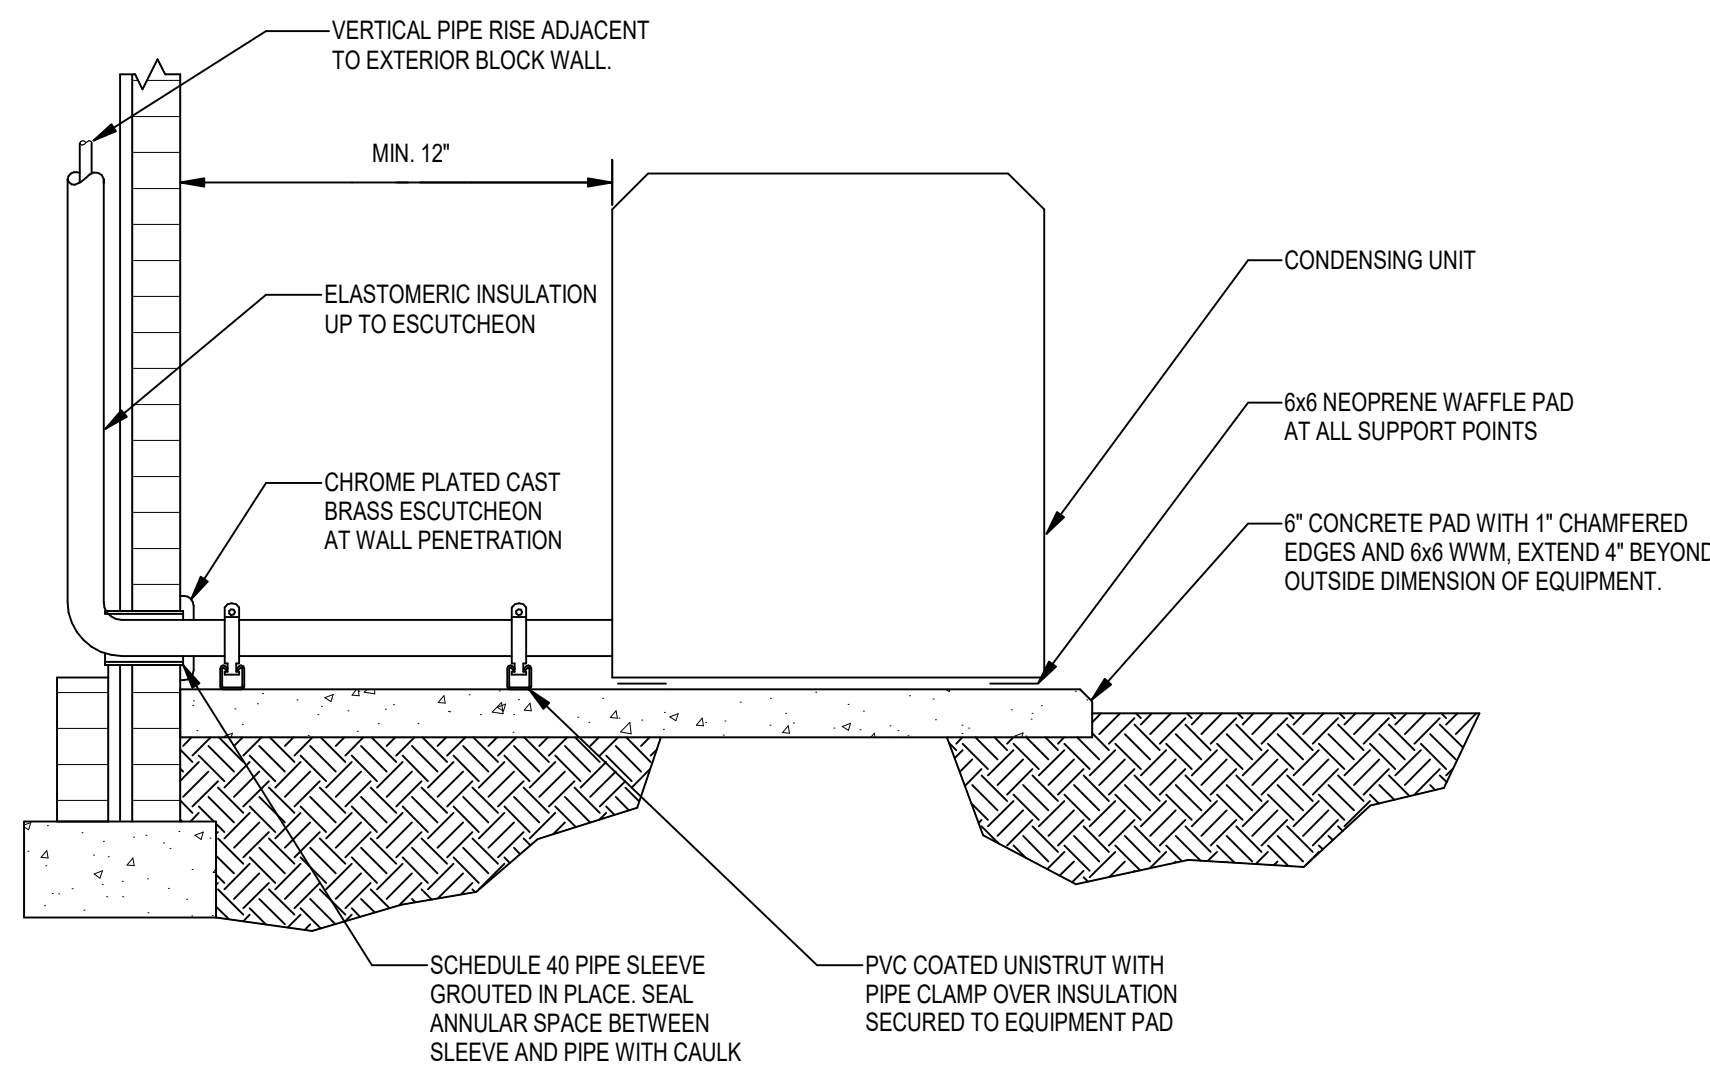

NOTES:

1. FLEXIBLE DUCT SHALL NOT HAVE MORE THAN 1/2" SAG PER FOOT.
2. PROVIDE INSULATION ON BACK OF DIFFUSERS (SEE SPECIFICATIONS). SEAL VAPOR TIGHT WITH FABRIC AND MASTIC.
3. PULL INNER LINER OF FLEXIBLE DUCT OVER DIFFUSER COLLAR AND SECURE WITH DRAW BAND.
4. SECURE FLEXIBLE DUCT INSULATION AND OUTER JACKET WITH DRAW BAND.
5. MAINTAIN MINIMUM RADIUS (R) OF 1.5 TIMES THE DUCT DIAMETER.

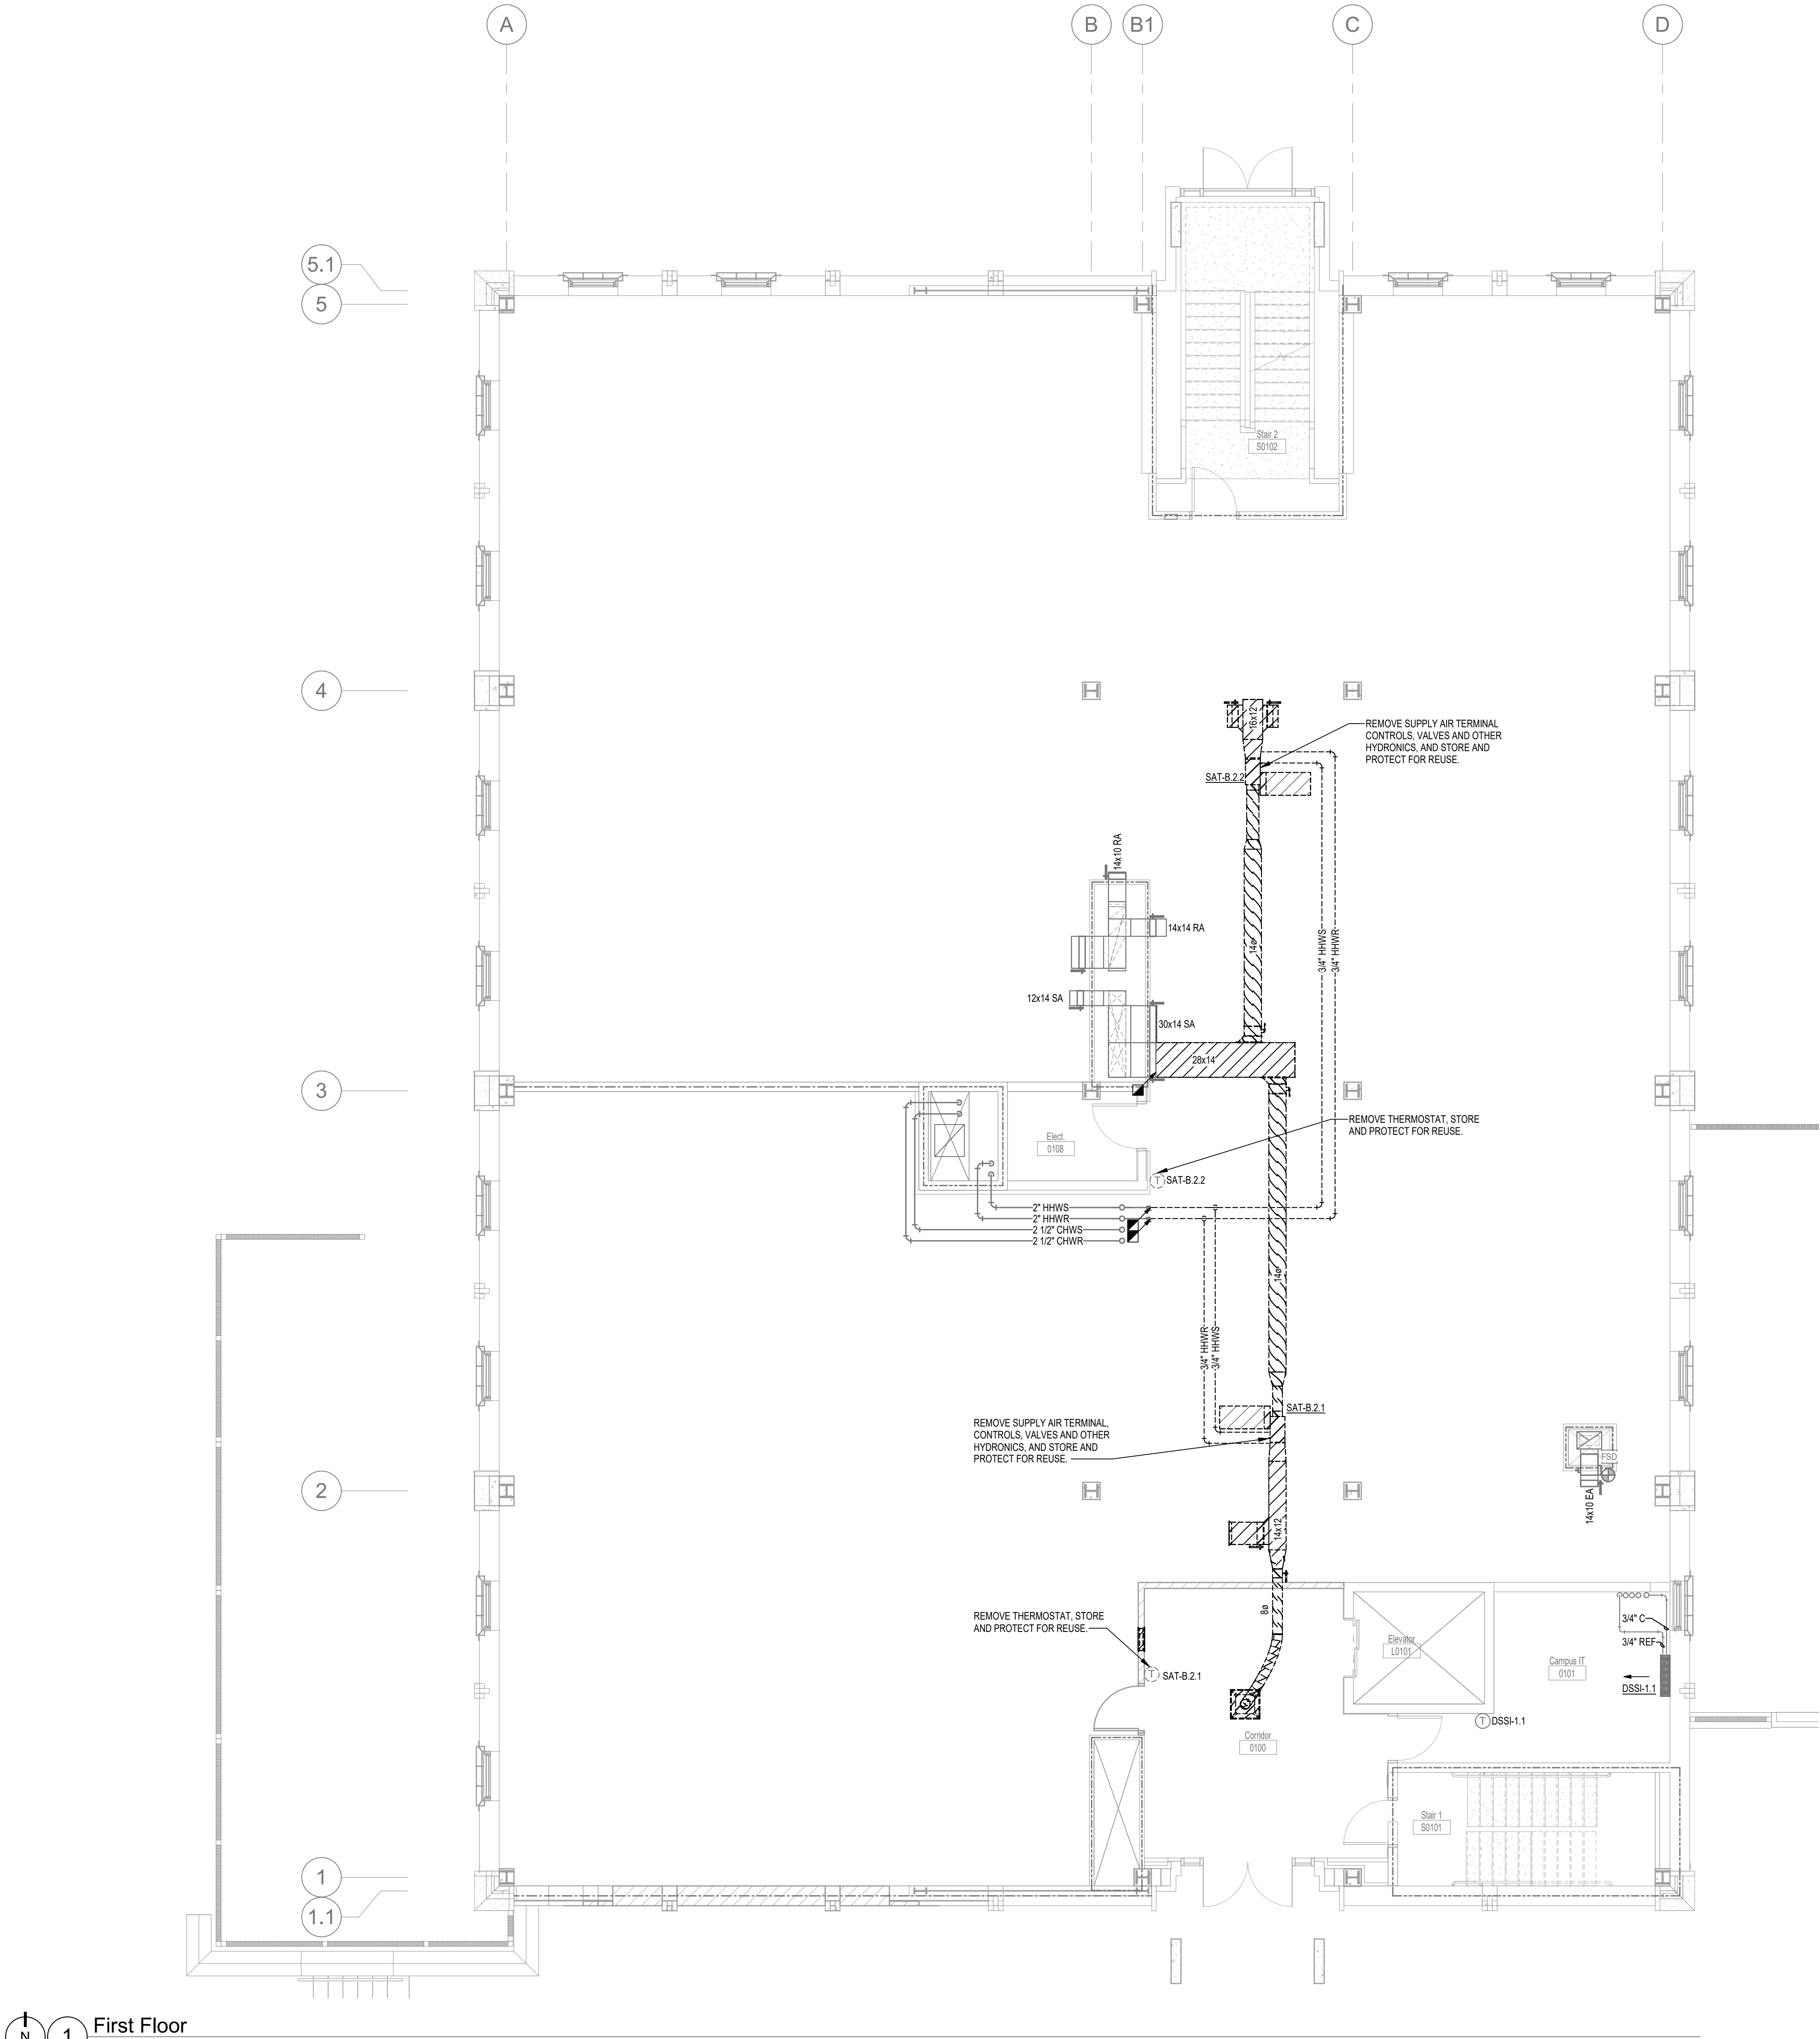

1 First Floor
3/16" = 1'-0"

THESE DRAWINGS AND REVISIONS ARE INSTRUMENTS OF SERVICE. THE DRAWINGS ARE THE PROPERTY OF ALW ENGINEERING, INC. AND ARE NOT TO BE REPRODUCED OR USED FOR ANY PURPOSE EXCEPT BY WRITTEN AGREEMENT. ANY REUSE OR REPRODUCTION WITHOUT WRITTEN PERMISSION IS PROHIBITED. THIS COPYRIGHT NOTIFICATION SHALL REMAIN ON EACH DRAWING EXHIBIT OR REVISION ON THIS DOCUMENT. ANY REUSE OR REPRODUCTION WITHOUT WRITTEN PERMISSION IS PROHIBITED.

DATE:	REVIEWED:	DRAWN:	REVISION:	ID:
08/28/2024	STC	EPH		
01/16/2025	STC	WVA		
09/16/2025	STC	WVA		

PHASE:	DRAWN:	REVIEWED:	DATE:
SCHEMATIC DESIGN	EPH	STC	08/28/2024
50% CONSTRUCTION DOCUMENTS	WVA	STC	01/16/2025
100% CONSTRUCTION DOCUMENTS	WVA	STC	09/16/2025

PHASE:	DRAWN:	REVIEWED:	DATE:
SCHEMATIC DESIGN	EPH	STC	08/28/2024
50% CONSTRUCTION DOCUMENTS	WVA	STC	01/16/2025
100% CONSTRUCTION DOCUMENTS	WVA	STC	09/16/2025

Client: Florida State University
Tallahassee, Florida
Job Title: Kellogg Building Remodeling
Phase 2, Volume 3 (of 3)


Consultant: Project #: 22470
Phase: 100% Construction Documents

Seal:


ALW
Architects Lewis + Whitlock
206 West Virginia St.
Tallahassee, Florida 32301
850.942.1718
www.think3d.net
Description:
Demolition - First Floor
Plan

Sheet No.: MD101

12
ENGINEERING
114 EAST 38th AVENUE TALLAHASSEE, FL 32301 PHONE 850.224.1712 WWW.THINK3D.NET
THIS DOCUMENT IS THE PROPERTY OF ALW ENGINEERING, INC. AND IS PREPARED AS AN INSTRUMENT OF SERVICE. ITS USE, REUSE OR REPRODUCTION WITHOUT WRITTEN AGREEMENT WITH ALW ENGINEERING, INC. IS PROHIBITED.
Florida Registry #2485
Scott T. Craig Jr., P.E. #73938

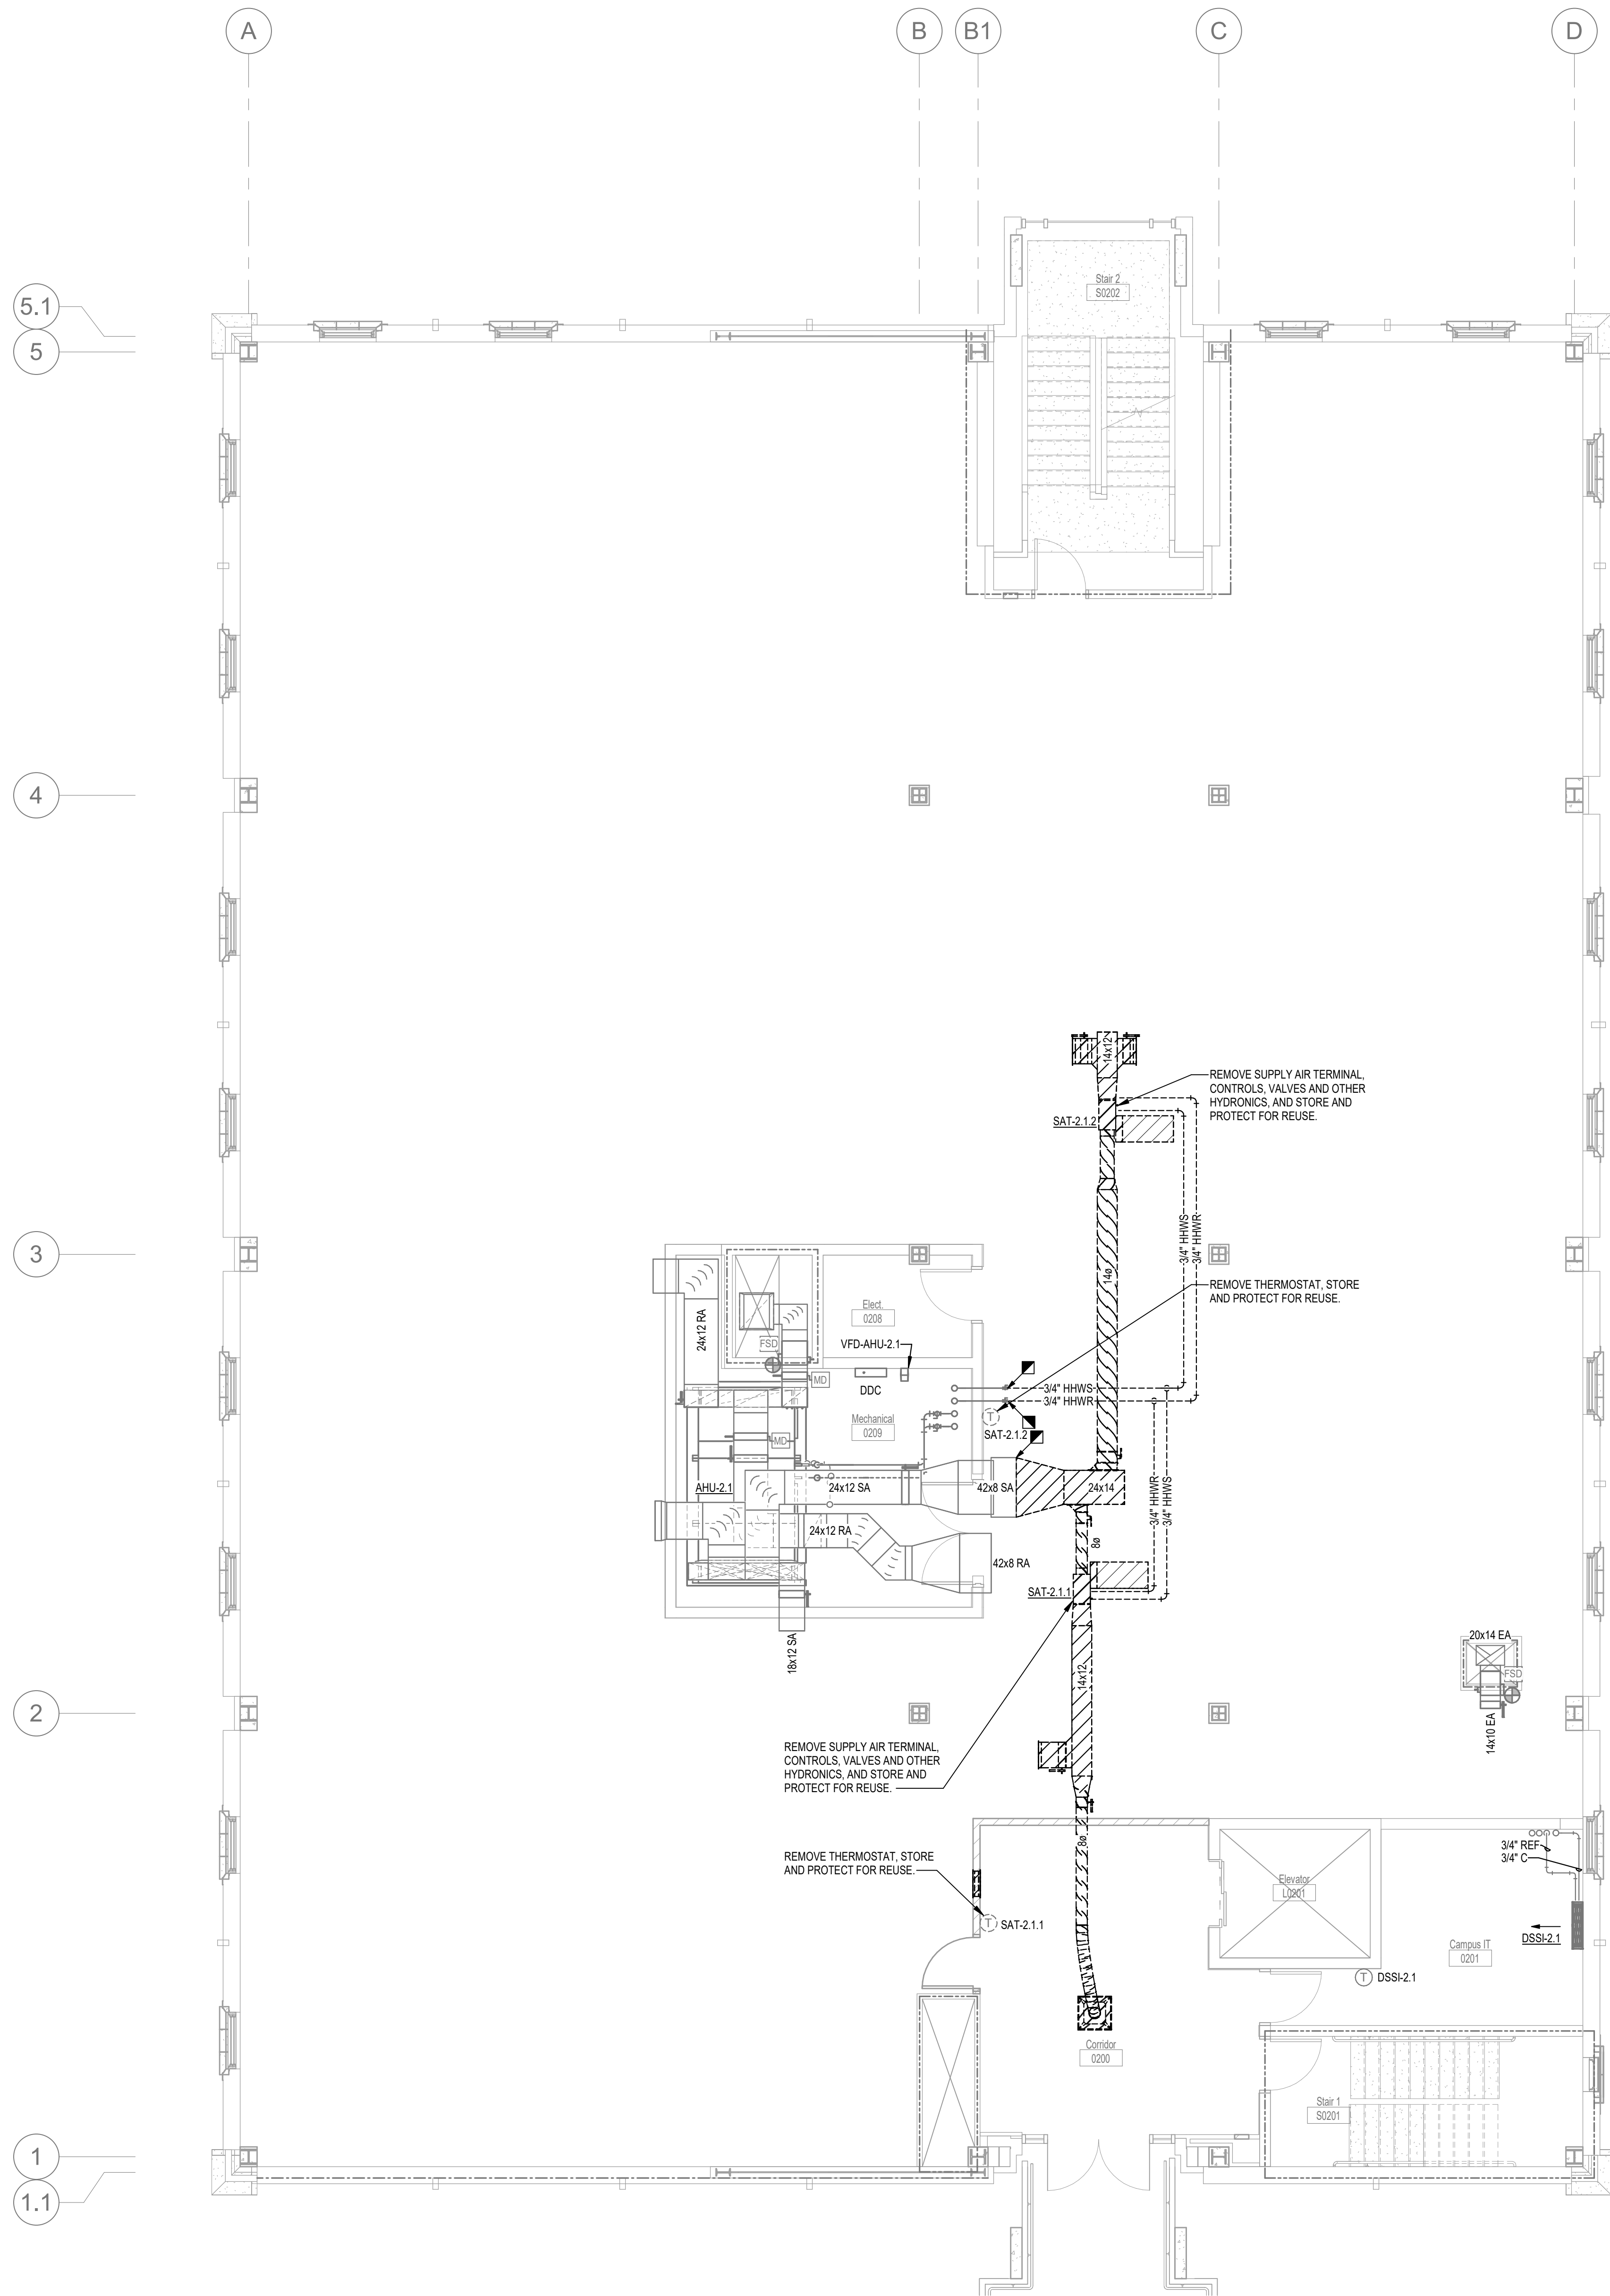

Third Floor **Alternate 3rd Floor**

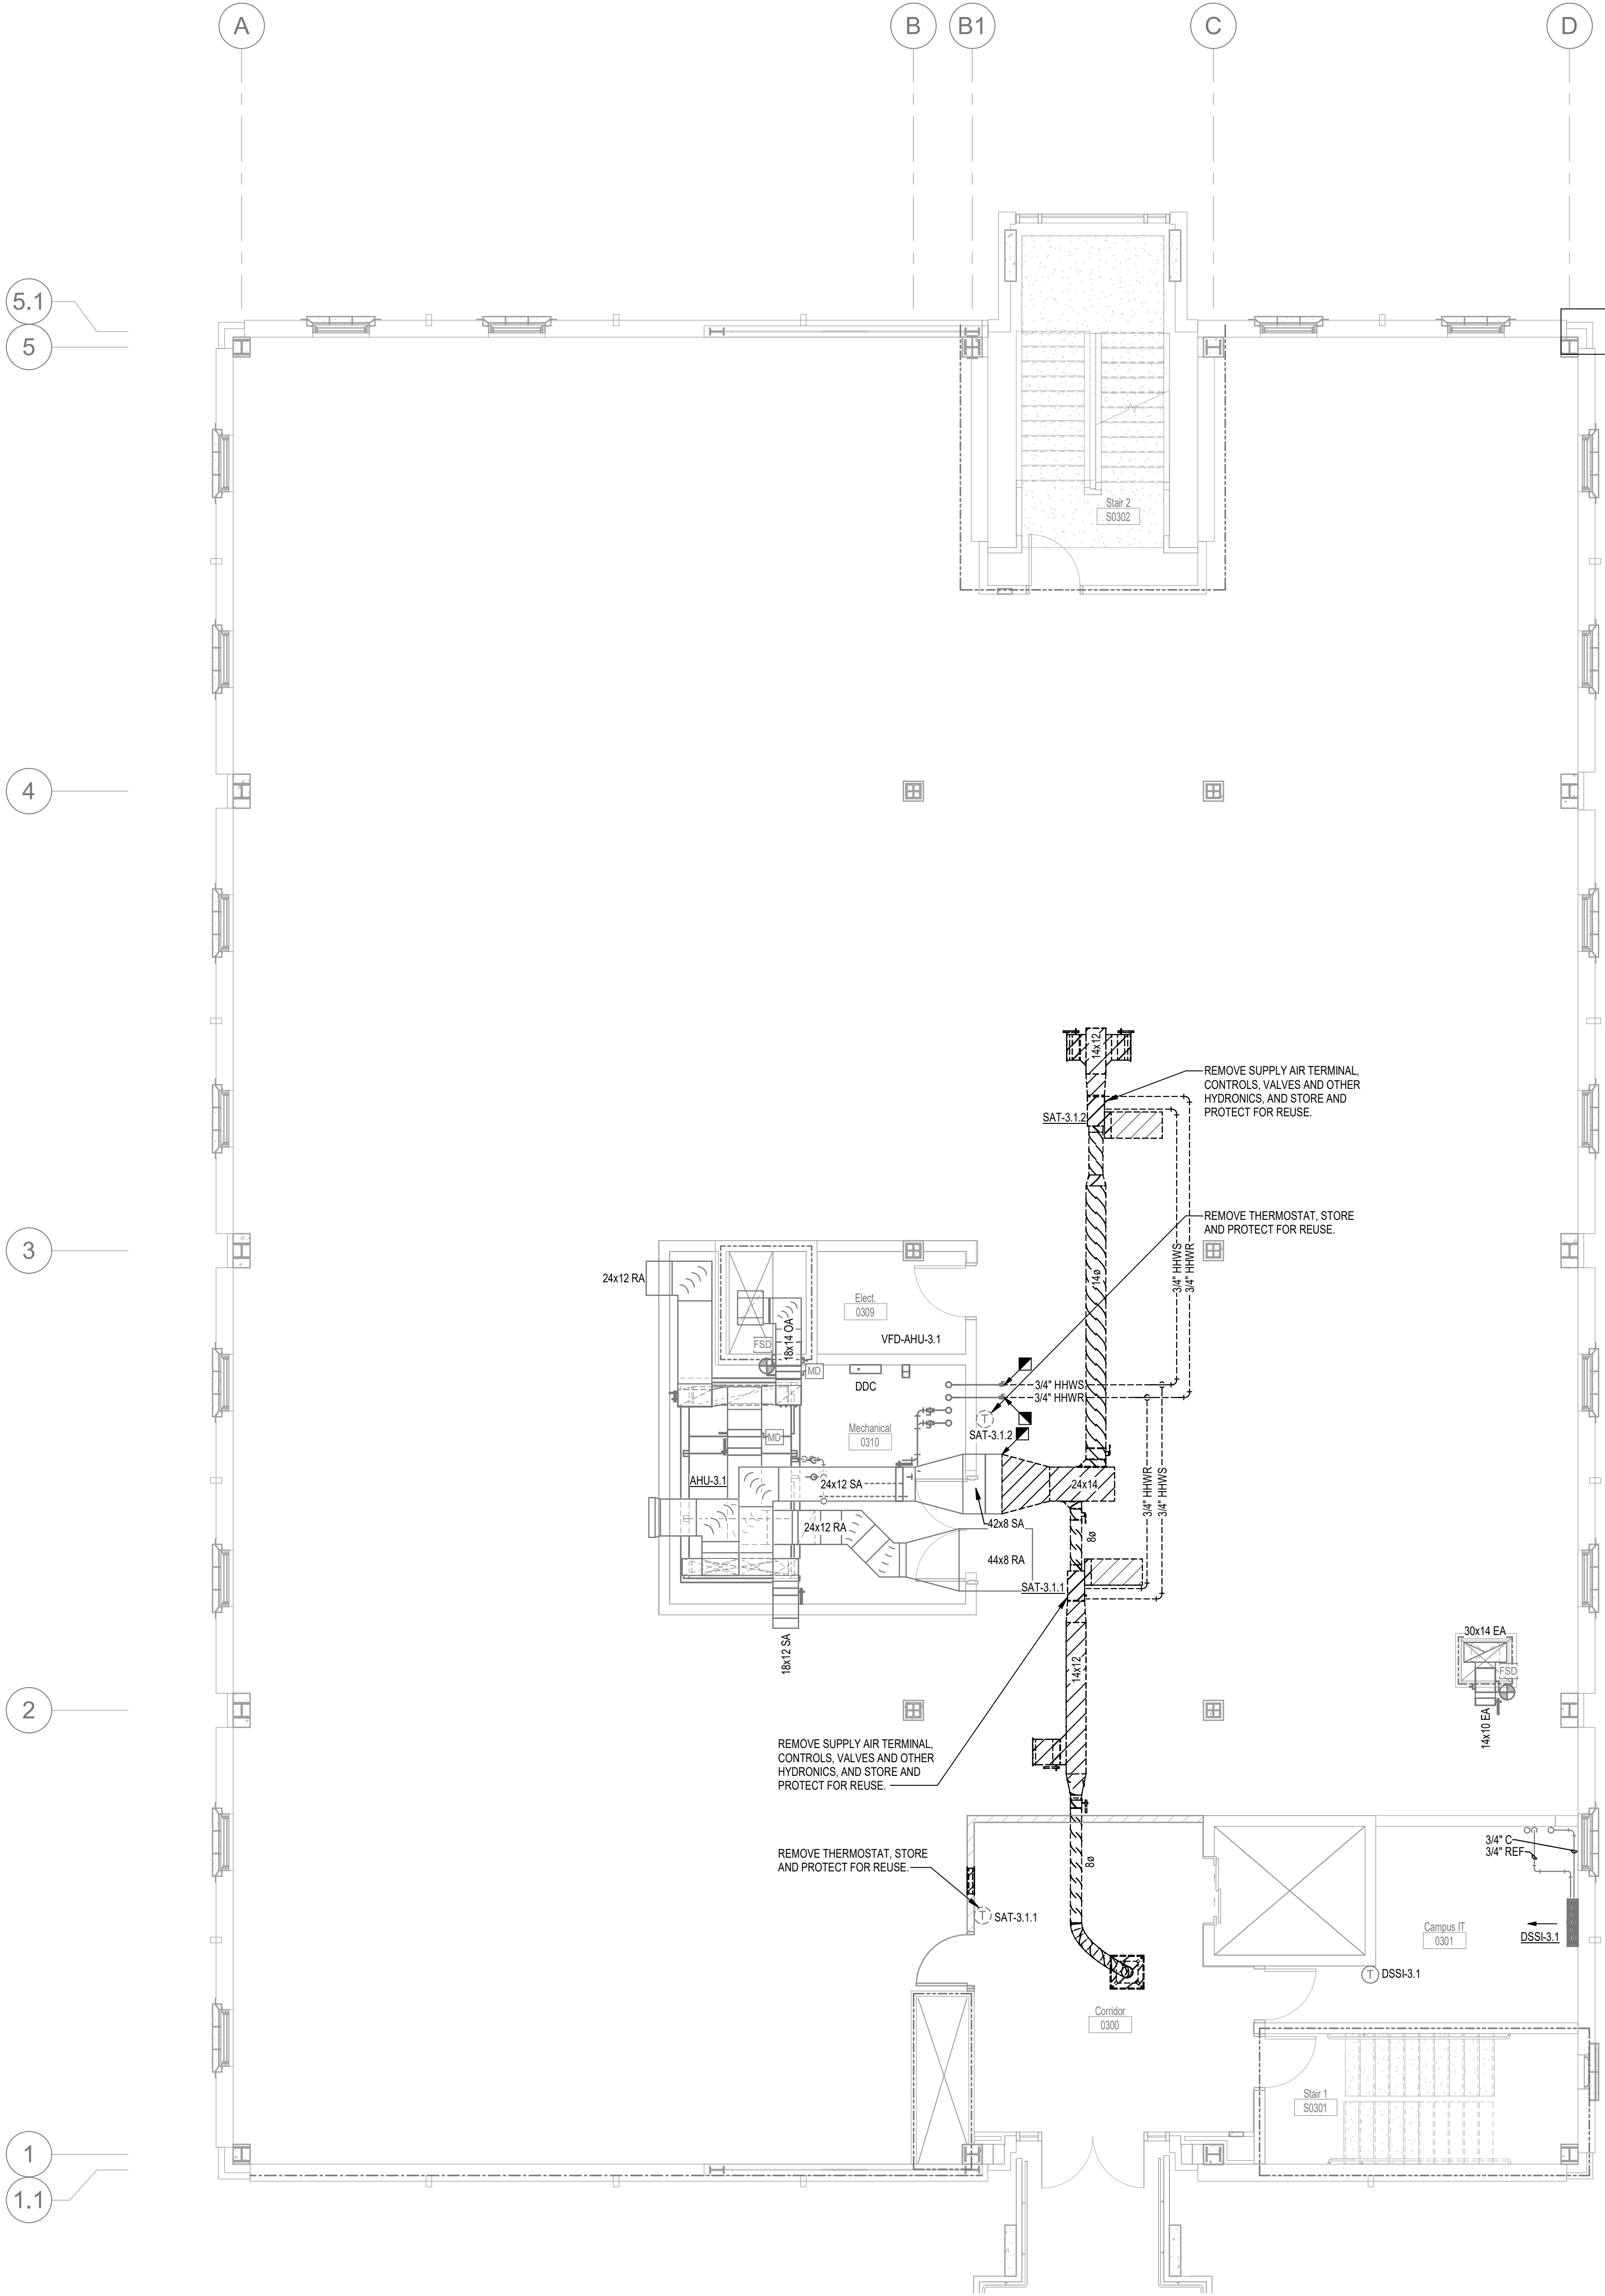

ALW
Architects Lewis + Whitlock
206 West Virginia St.
Tallahassee, Florida 32301
850.942.1718
www.think3d.net
Description:
Demolition - Third Floor
Plan
Sheet No.:
MD103

Client:	Florida State University Tallahassee, Florida
Consultant:	Project #: 22470 Phase: 100% Construction Documents
Job Title:	Kellogg Building Remodeling Phase 2, Volume 3 (of 3)
PHASE:	Schematic Design Design Development 50% Construction Documents 100% Construction Documents
DRAWN:	EPN JWA JWA
REVIEWED:	ETC ETC ETC
DATE:	08/28/2024 01/16/2025 09/16/2025
ID:	
REVISION:	
DRAWN:	
REVIEWED:	
DATE:	

THESE DRAWINGS AND REVISIONS ARE INSTRUMENTS OF SERVICE. THE DRAWINGS ARE THE PROPERTY OF ALW ENGINEERING, INC. AND ARE NOT TO BE REPRODUCED, COPIED, OR USED IN ANY MANNER WITHOUT THE WRITTEN PERMISSION OF ALW ENGINEERING, INC. FOR ANY PURPOSE EXCEPT BY WRITTEN PERMISSION OF ALW ENGINEERING, INC. PROHIBITED. THIS COPYRIGHT NOTIFICATION IS A CONDITION OF THE CONTRACT AND EACH DRAWING EXHIBIT OR REFERENCE TO THIS DOCUMENT SHALL BE REMOVED FROM THESE DOCUMENTS.



ALW
Architects Lewis & Whitlock
206 West Virginia St.
Tallahassee, Florida 32301
850.942.1718
www.think3d.net
Description:
Demolition - Fourth Floor
Demol

Sheet No.:
MD104

[illegible]

REVIEWED:	DATE:
STC	08/28/2024
STC	01/16/2026
STC	06/16/2026

Client:	Florida State University Tallahassee, Florida
Job Title:	Kellogg Building Remodeling Phase 2, Volume 3 (of 3)

Consultant: _____
Project #: 22470
Phase: 100% Construction Documents

Seal