
 



Autodesk Docs://24-194_COT UUP1 Sand PH24-194 MapCentral_Support Buildings 2 3 and 4_P25.rvt

1/9/2025 11:27:22 AM

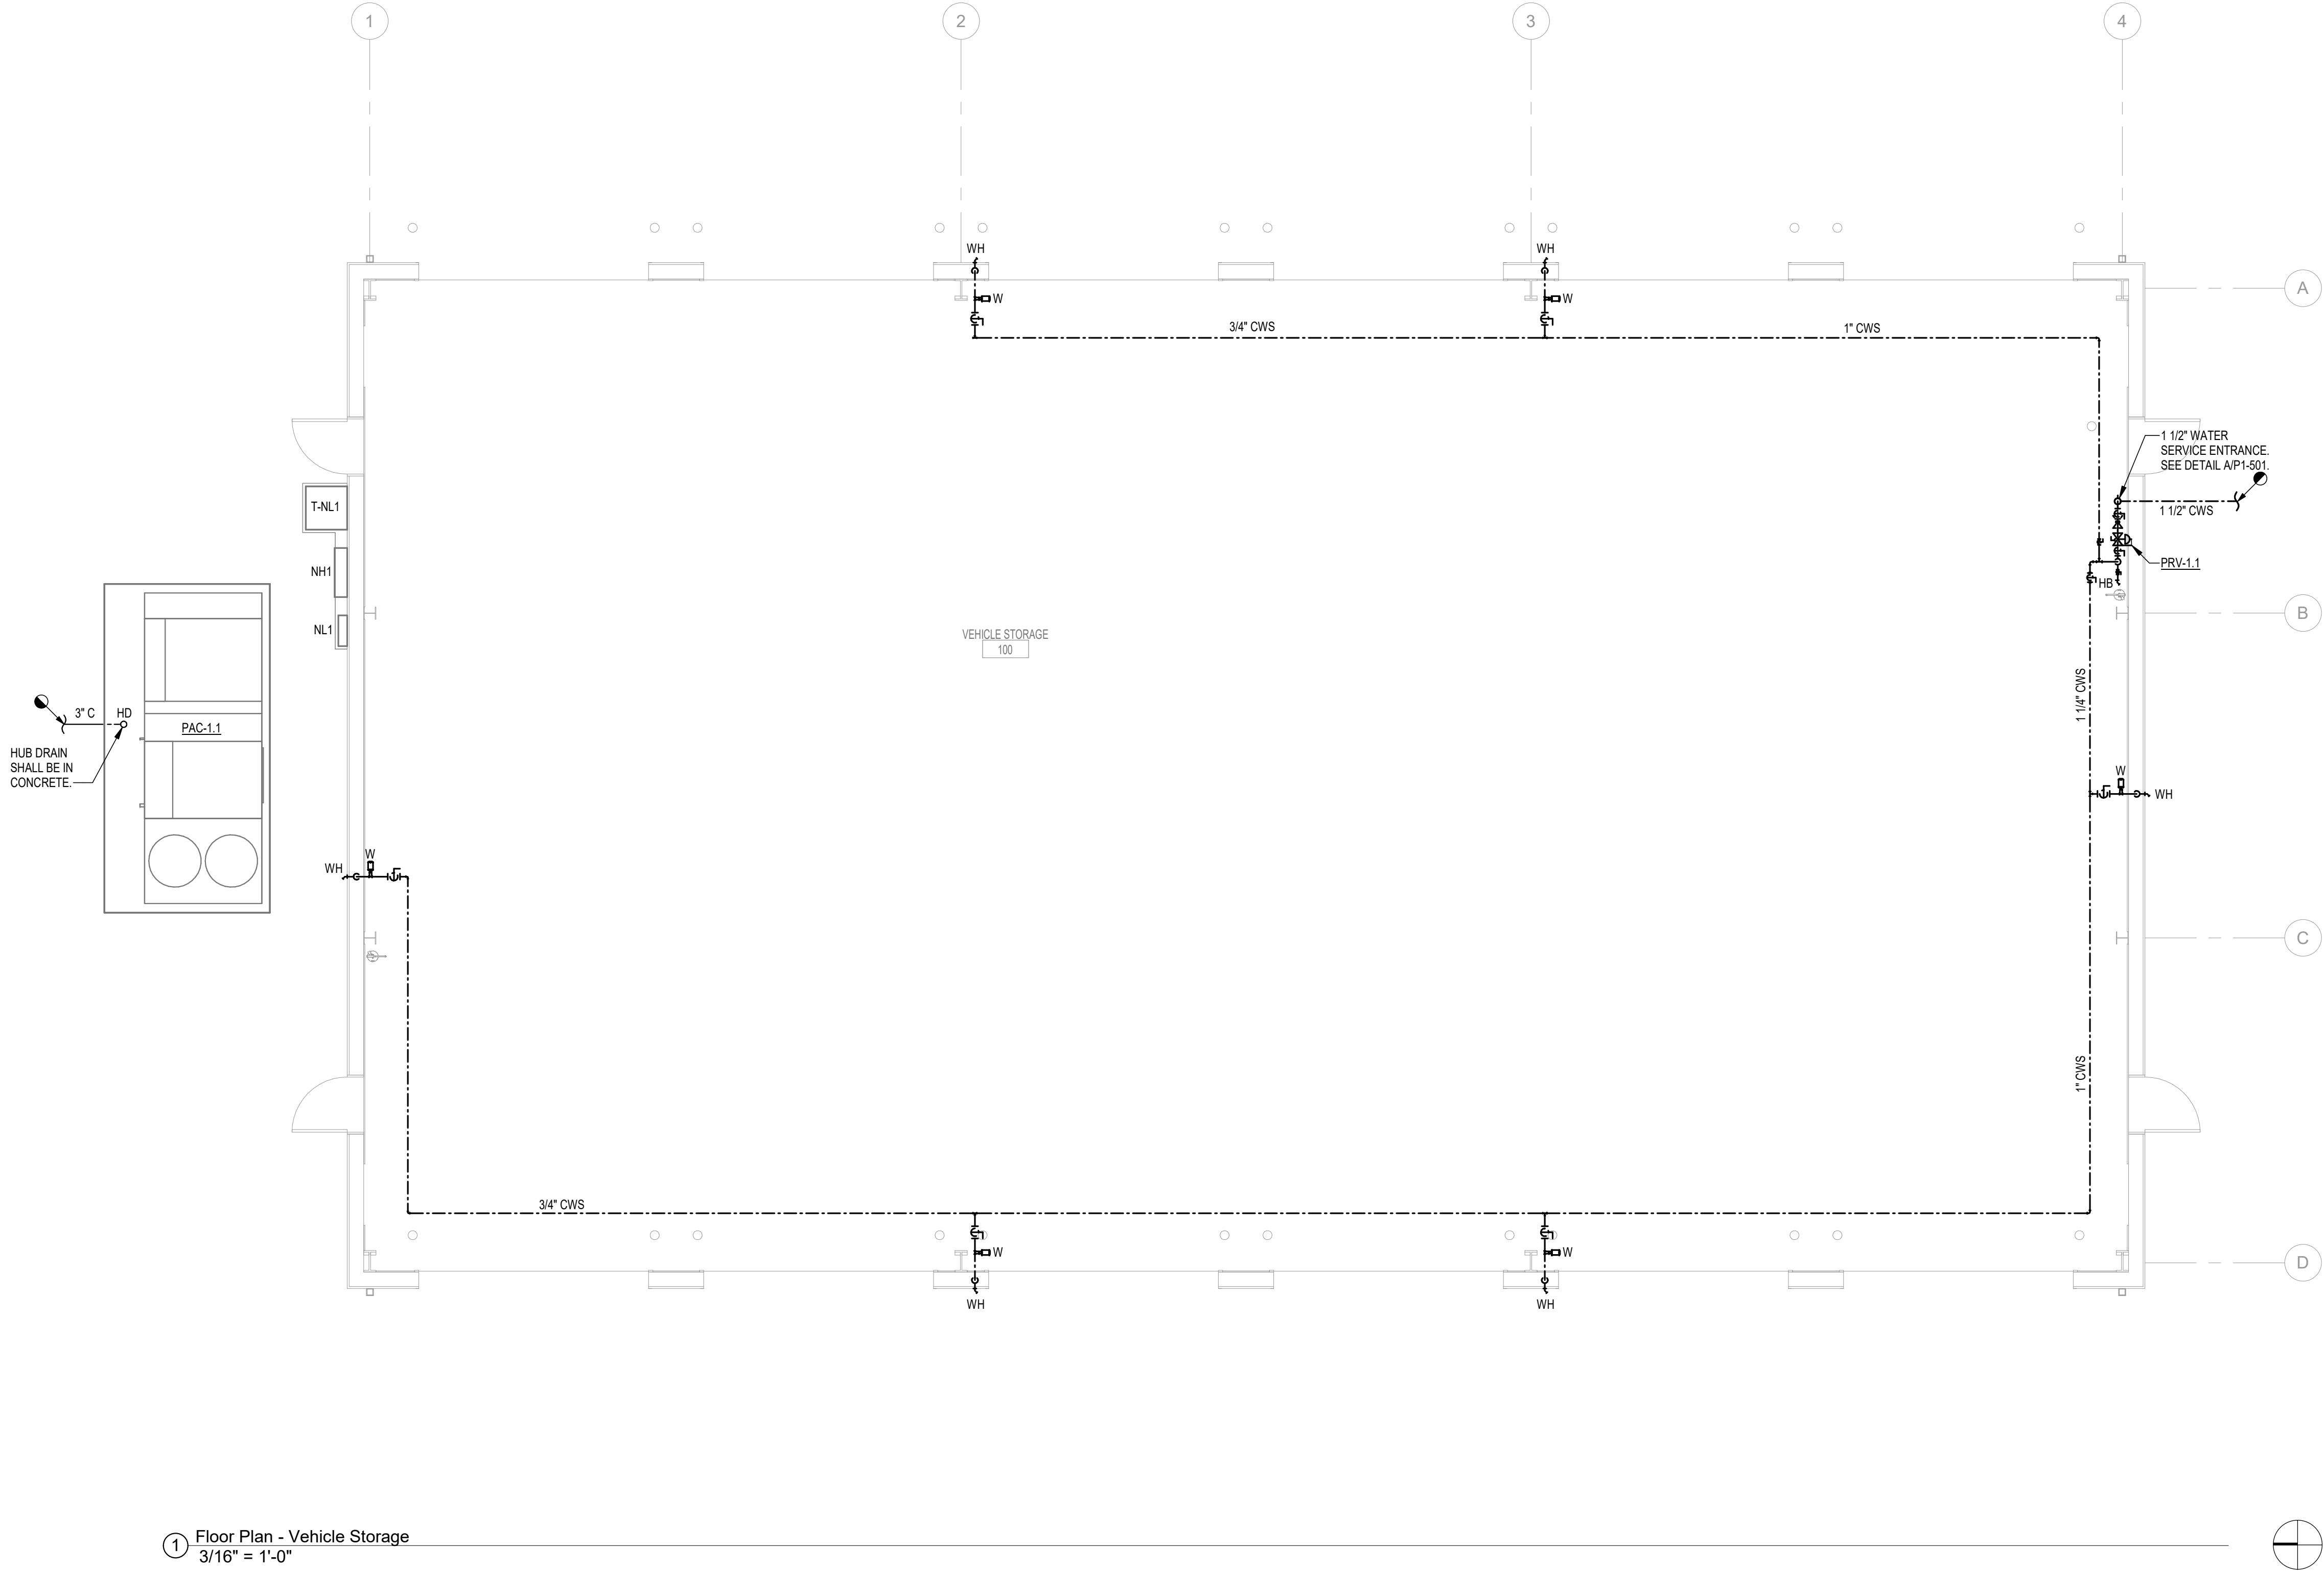

① Floor Plan - Vehicle Storage
3/16" = 1'-0"



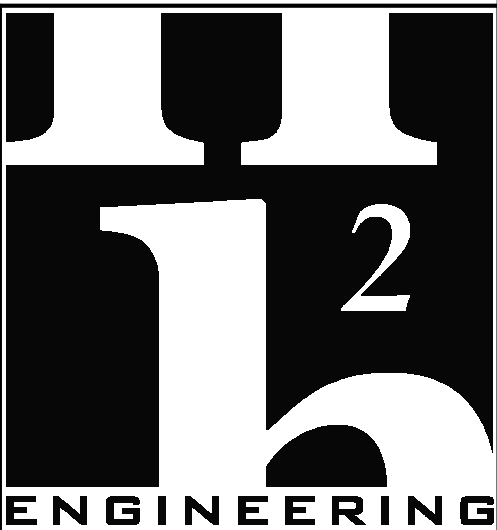

H2
ENGINEERING

114 EAST 5th AVENUE, TALLAHASSEE, FL 32303
PHONE 850.234.7102
www.H2Engineering.com

H2E PROJECT No. 24194

THIS DOCUMENT IS THE PROPERTY OF H2Engineering AND IS PREPARED AS AN INSTRUMENT OF SERVICE. ITS USE, REUSE OR REPRODUCTION, EXCEPT BY WRITTEN AGREEMENT WITH H2Engineering, IS PROHIBITED.

Florida Registry #2485
Mark P. Poindexter, P.E. #90615



bki
ARCHITECTURE

BKJ, Inc., Architecture
1621 Physicians Dr.
Tallahassee, Florida 32308
(P) 850.778.8007 (F) 850.548.6150
www.bkjarchitecture.com
FL Architecture Corporation AA260002280

SEAL:

PROJECT TITLE:

**UUPI - LBR Relocation
Support Structures For
City of Tallahassee**

1900 RANKIN AVE, Tallahassee, FL 32310



JOB NO.:	21.130
DESIGNED:	FPH
DRAWN:	FPH
CHECKED:	MPP
THIS DRAWING AND ANY REPRODUCTIONS ARE THE PROPERTY AND COPYRIGHT OF BKJ, INC. AND MAY NOT BE REPRODUCED, PUBLISHED, OR USED IN ANY MANNER WITHOUT WRITTEN PERMISSION OF THE ARCHITECT	
REVISIONS:	2
	01/09/25
Addendum 02	

DRAWING PHASE:
100% Construction Documents

DRAWING TITLE:
Vehicle Storage

SHEET NO.:
P1-101

  DATE:
October 03, 2025



PROJECT TITLE:

UUPI - LBR Relocation Support Structures For City of Tallahassee

2
1900 RANKIN AVE, Tallahassee, FL 32310

JOB NO.: 21.130

DESIGNED: WJA

DRAWN: WJA

CHECKED: MPP

THIS DRAWING AND ANY REPRODUCTIONS
ARE THE PROPERTY AND COPYRIGHT
OF BKJ, INC. AND MAY NOT BE
REPRODUCED, PUBLISHED, OR USED IN ANY
MANNER WITHOUT WRITTEN
PERMISSION OF THE ARCHITECT

[illegible]

DRAWING PHASE:
100% Construction Documents

DRAWING TITLE:


Fuel Canopy

SHEET NO.:


P3-101

DATE:


October 03, 2025

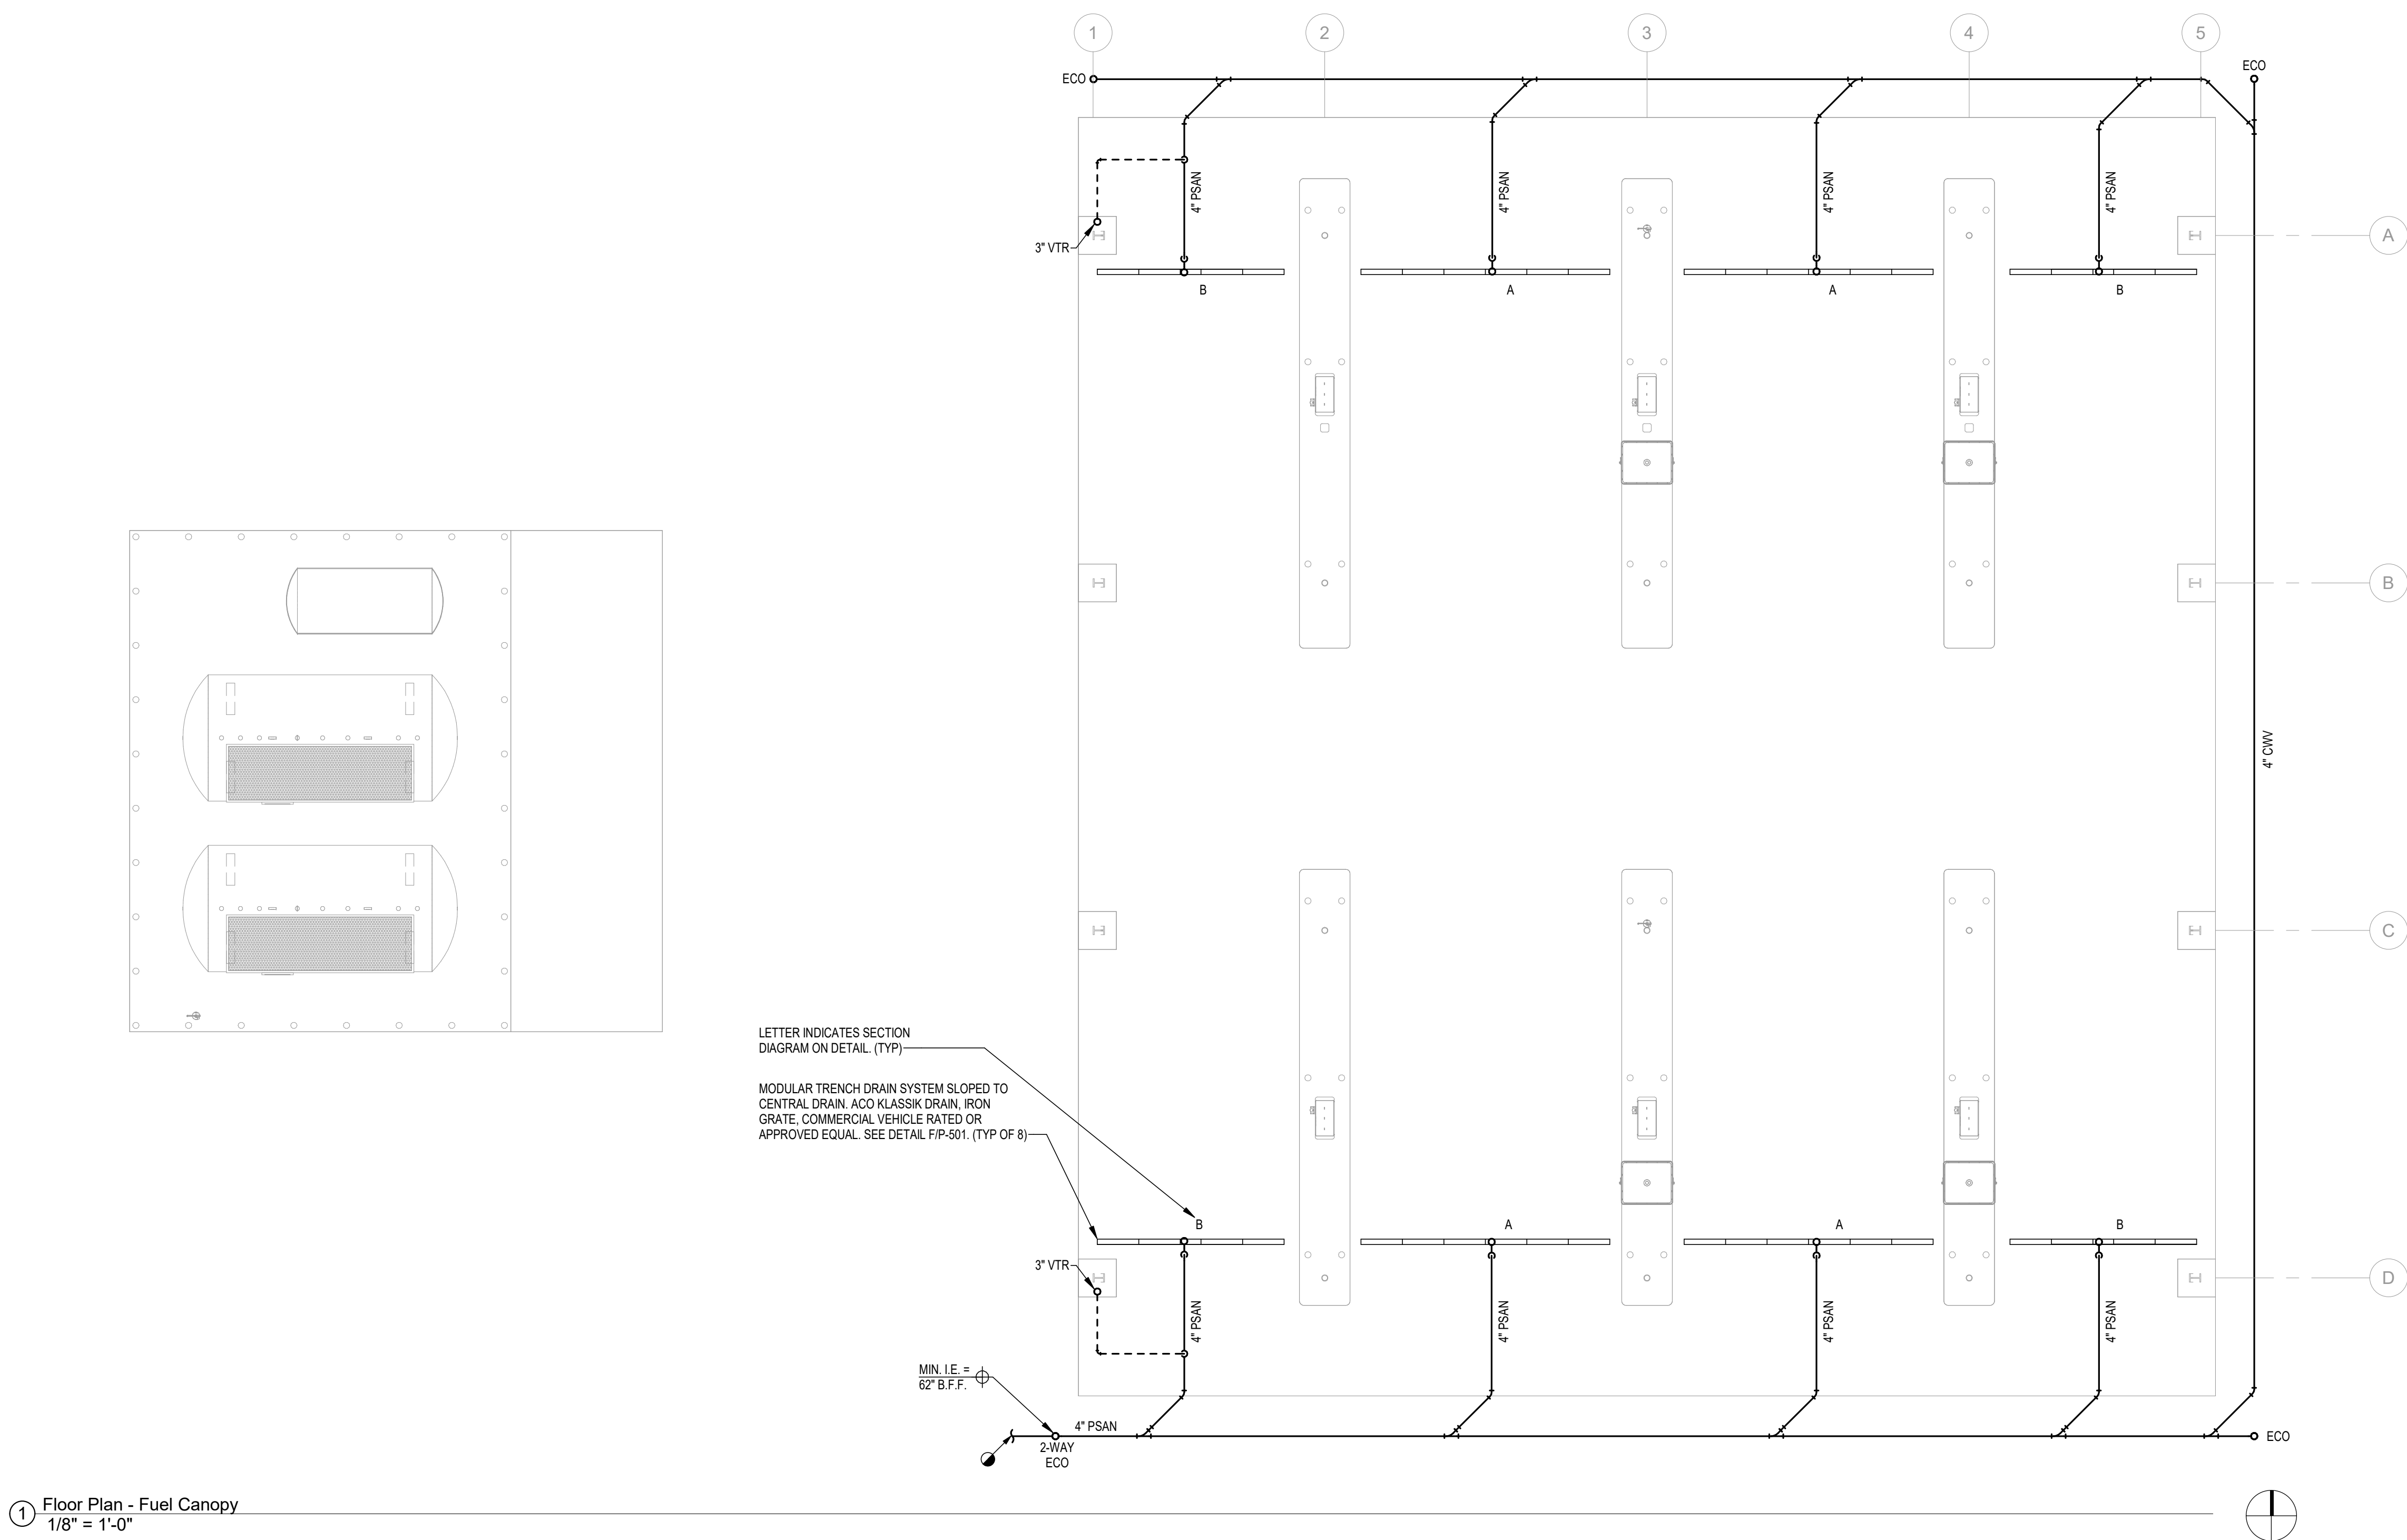

① Floor Plan - Fuel Canopy
1/8" = 1'-0"

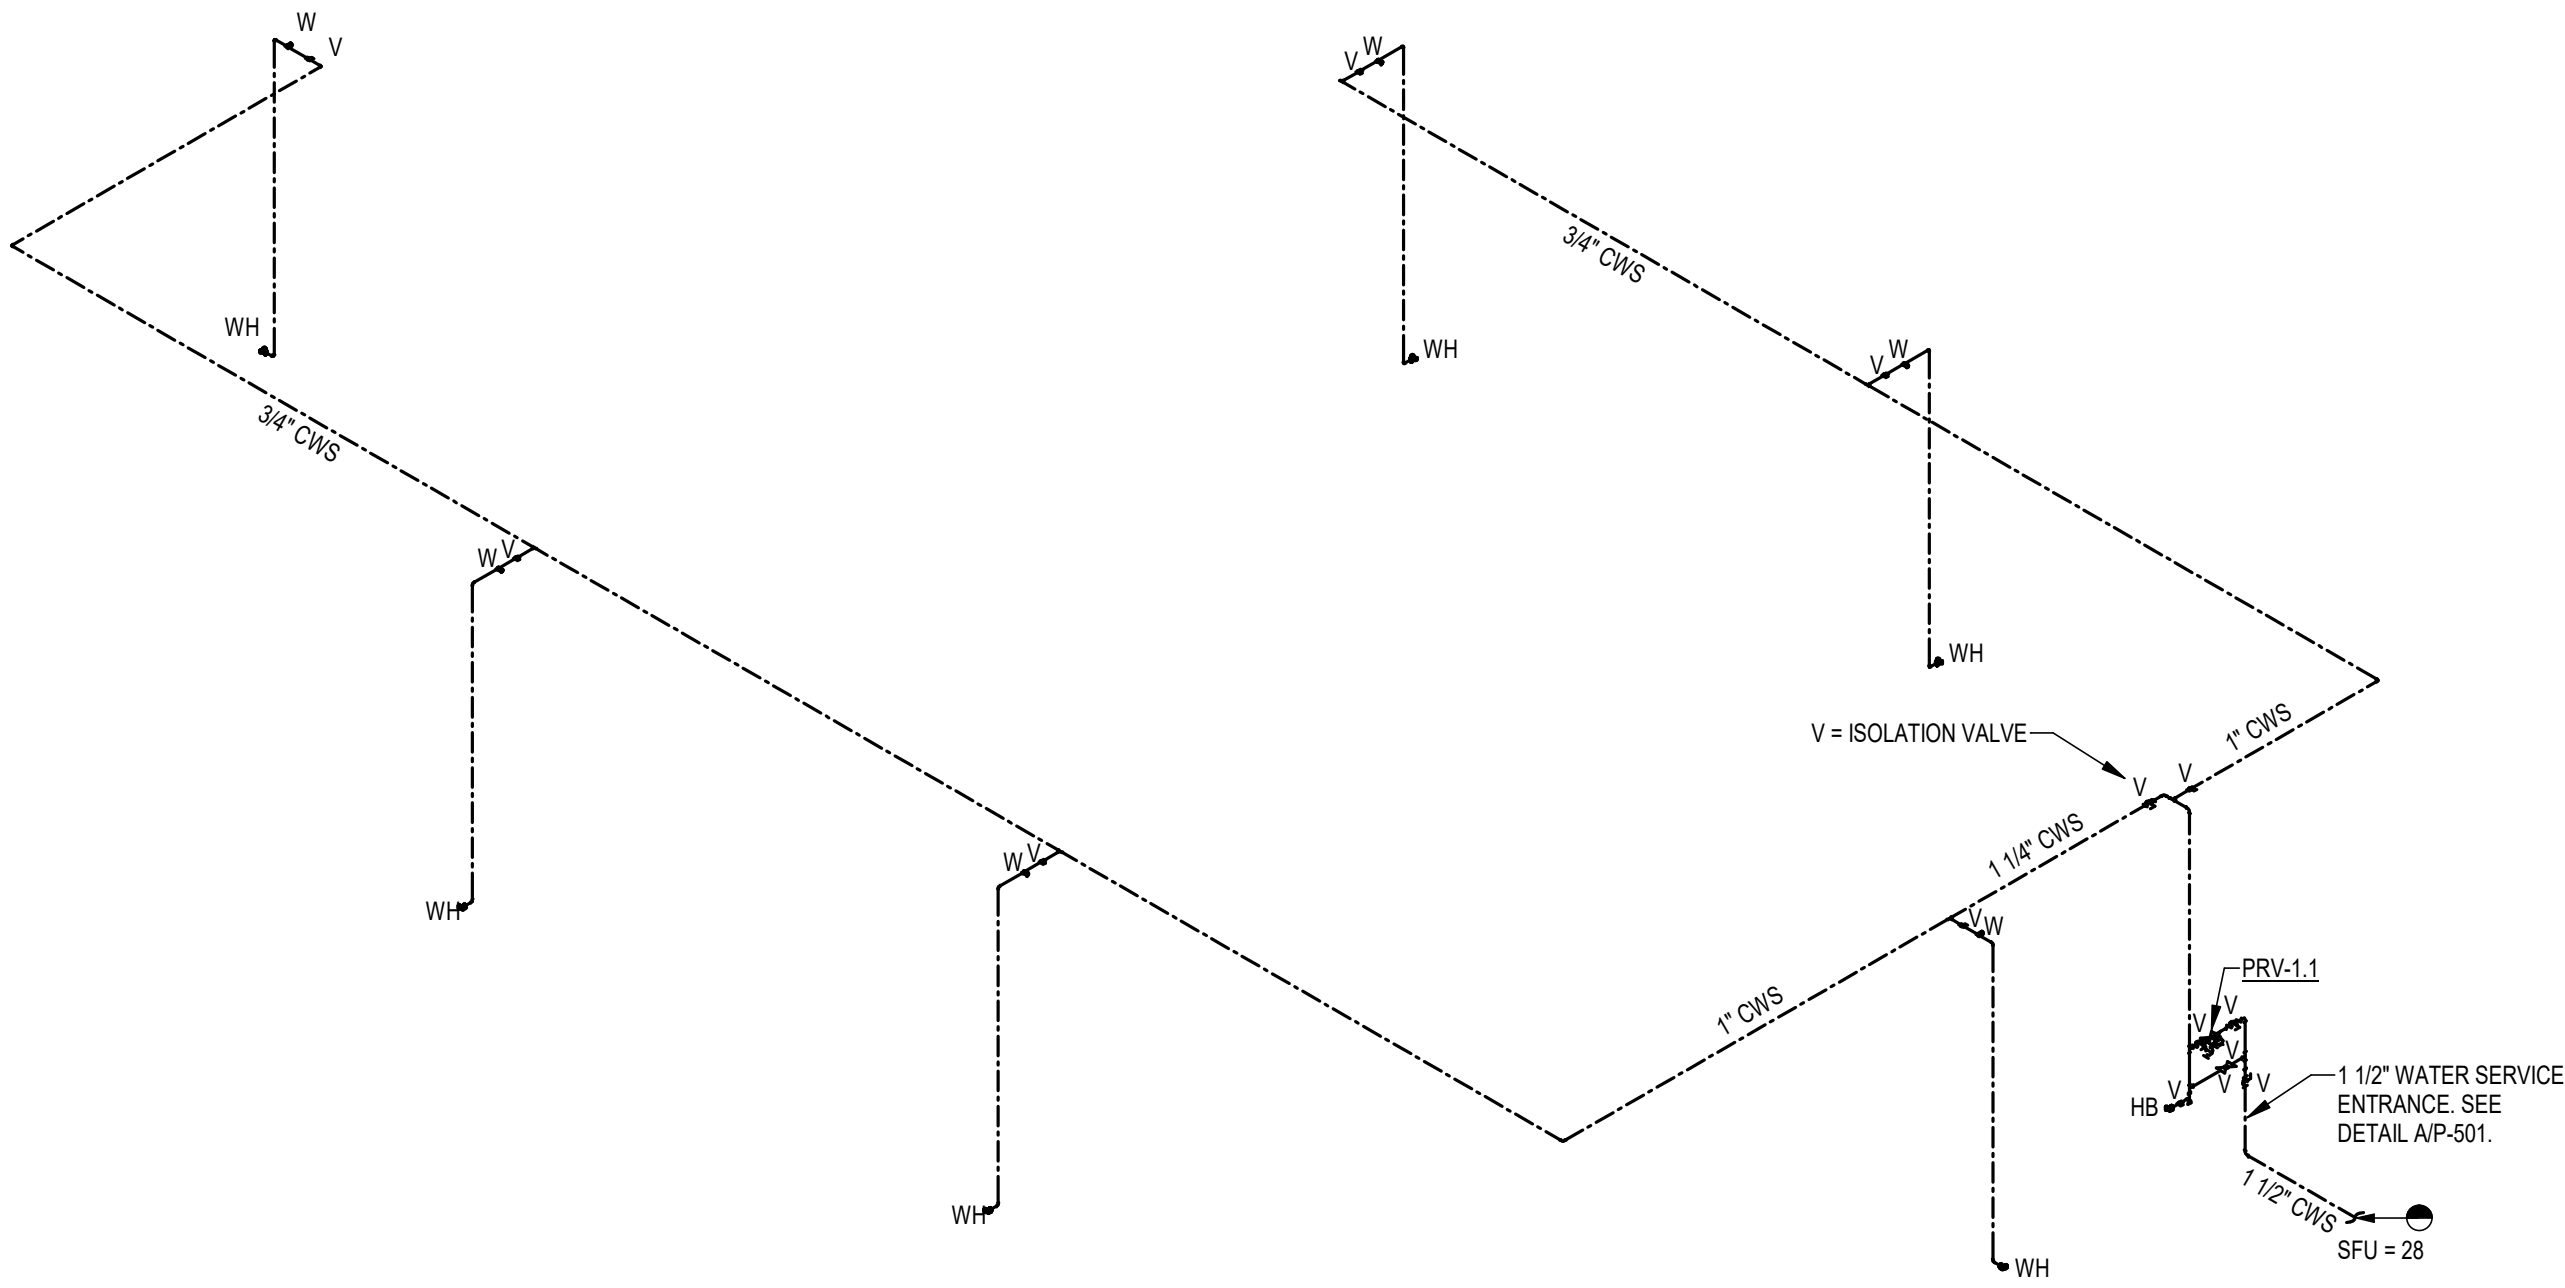

① Supply Riser- Vehicle Storage

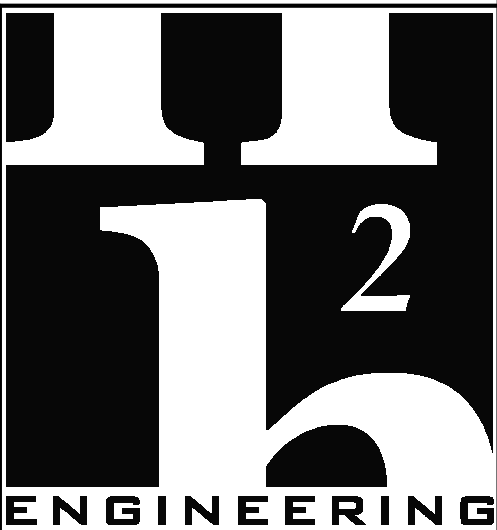

H2
ENGINEERING

114 EAST 5th AVENUE, TALLAHASSEE, FL 32303
PHONE 904.241.7102
WWW.H2ENGINEERING.COM

H2E PROJECT No. 24194

THIS DOCUMENT IS THE PROPERTY OF H2ENGINEERING AND IS PREPARED AS AN INSTRUMENT OF SERVICE. ITS USE, REUSE OR REPRODUCTION, EXCEPT BY WRITTEN AGREEMENT WITH H2ENGINEERING, IS PROHIBITED.

Florida Registry #2485
Mark P. Poindexter, P.E. #90615



bki
ARCHITECTURE

BKJ, Inc., Architecture
1621 Physicians Dr.
Tallahassee, Florida 32308
(P) 850.778.8007 | (F) 850.548.6150
www.bkjarchitecture.com
FL Architecture Corporation AA200002280

SEAL:

PROJECT TITLE:

**UUPI - LBR Relocation
Support Structures For
City of Tallahassee**

1900 RANKIN AVE, Tallahassee, FL 32310


JOB NO.:	21.130
DESIGNED:	FPH
DRAWN:	FPH
CHECKED:	MPP
THIS DRAWING AND ANY REPRODUCTIONS ARE THE PROPERTY AND COPYRIGHT OF BKJ, INC. AND MAY NOT BE REPRODUCED, PUBLISHED, OR USED IN ANY MANNER WITHOUT WRITTEN PERMISSION OF THE ARCHITECT	
REVISIONS:	2
	01/09/25
Addendum 02	

DRAWING PHASE:
100% Construction Documents

DRAWING TITLE:
Riser Diagrams

SHEET NO.:
P-301

DATE:
October 03, 2025

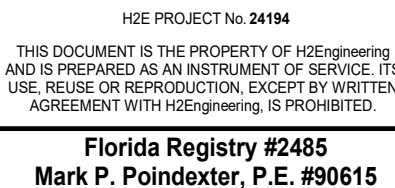

PROJECT TITLE:

2
1900 RANKIN AVE, Tallahassee, FL 32310

THIS DRAWING AND ANY REPRODUCTIONS
ARE THE PROPERTY AND COPYRIGHT
OF BKJ, INC. AND MAY NOT BE
REPRODUCED, PUBLISHED, OR USED IN ANY
MANNER WITHOUT WRITTEN
PERMISSION OF THE ARCHITECT

REVISIONS:		
2	01/09/26	Addendum 02


October 03, 2025

FIXTURE DESIGNATION	FIXTURE DESCRIPTION	A.D.A. COMPLIANT	MOUNTING METHOD	HEIGHT (A.F.F.)	ROUGH-IN PIPE SIZES				MANUFACTURER AND MODEL NUMBER	ACCESSORIES (SEE SCHEDULE)
					COLD WATER SUPPLY	HOT WATER SUPPLY	FIXTURE TRAP	FIXTURE DRAIN		
HB	ROUGH CHROME HOSE BIBB WITH VACUUM BREAKER, CROSS HANDLE, 3/4" HOSE THREAD OUTLET, 3/4" FEMALE INLET.	N/A	WALL SURFACE	--	3/4"	N/A	N/A	N/A	0	
WH	EXTERIOR WALL HYDRANT, NON-FREEZE, ANTI-SIPHON, AUTOMATIC DRAINING, WITH INTEGRAL BACKFLOW PREVENTER, ALL BRONZE INTERIOR PARTS, 3/4" INLET, 3/4" HOSE THREAD OUTLET, STAINLESS STEEL FACE AND OPERATING KEY.	N/A	WALL RECESSED	--	3/4"	N/A	N/A	N/A	0	

FIXTURE TYPE		QUANTITY	WASTE		SUPPLY					
					COLD		HOT		TOTAL	
			UNIT	TOTAL	UNIT	TOTAL	UNIT	TOTAL	UNIT	TOTAL
	HOSE BIBB / WALL HYDRANT	7			4	28			4	28
TOTAL FIXTURE UNITS				0		28		0		28
DOMESTIC WATER DEMAND (GPM)						22.6		0.0		22.6

FIXTURE TYPE		QUANTITY	WASTE		SUPPLY					
					COLD		HOT		TOTAL	
			UNIT	TOTAL	UNIT	TOTAL	UNIT	TOTAL	UNIT	TOTAL
	HOSE BIBB / WALL HYDRANT	5			4	20			4	20
TOTAL FIXTURE UNITS				0		20		0		20
DOMESTIC WATER DEMAND (GPM)						19.6		0.0		19.6

DESIGNATION	APPLICATION	PIPE SIZE (INCH DIA)	TOTAL DESIGN FLOW (GPM)	PRESSURE REDUCING VALVE QUANTITY	CAPACITY SPLIT (%)	PRESSURE REDUCING VALVE #1					DETAIL REFERENCE	
						VALVE SIZE (INCH DIA)	DESIGN FLOW (GPM)	PRESSURE DROP @ FLOW (PSIG)	OUTLET PRESSURE (PSIG)	MANUFACTURER		MODEL NUMBER
PRV-1.1	CWS	1 1/2	23	1	100	1 1/2	23	5.2	70	WATTS	LF223-S	B/P-501
PRV-2.1	CWS	1 1/2	20	1	100	1 1/2	20	4.5	70	WATTS	LF223-S	B/P-501

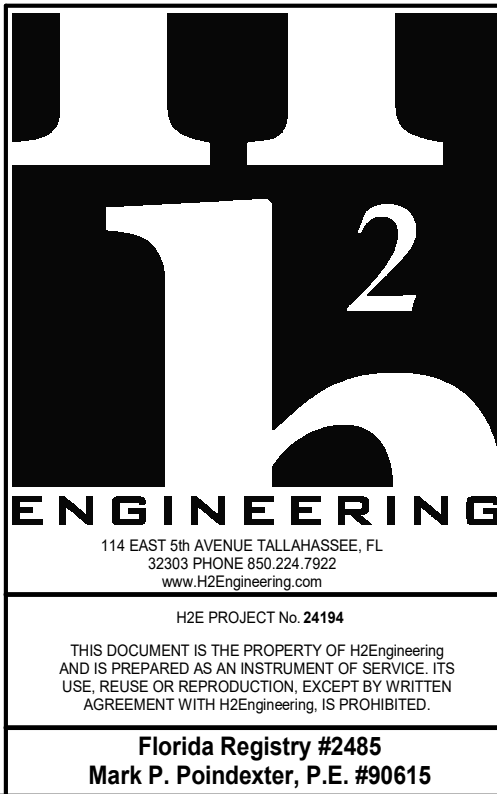

SEAL:

PROJECT TITLE:

**UUPI - LBR Relocation
Support Structures For
City of Tallahassee**

 1900 RANKIN AVE, Tallahassee, FL 32310

JOB NO.: 21.130

DESIGNED: FPH

DRAWN: FPH
CHECKED: MPP

THIS DRAWING AND ANY REPRODUCTIONS
ARE THE PROPERTY AND COPYRIGHT
OF BKJ, INC. AND MAY NOT BE
REPRODUCED, PUBLISHED, OR USED IN ANY
MANNER WITHOUT WRITTEN
PERMISSION OF THE ARCHITECT

[illegible]

DRAWING PHASE:
100% Construction Documents

DRAWING TITLE:




 


 

Schedules

SHEET NO.:
P-401

DATE:
October 03, 2025

Autodesk Docs://24-194_COT_UUP1_Sand_PH24-194_MapCentral_Support Buildings 2 3 and 4_P25.rvt

1/9/2026 11:27:31 AM

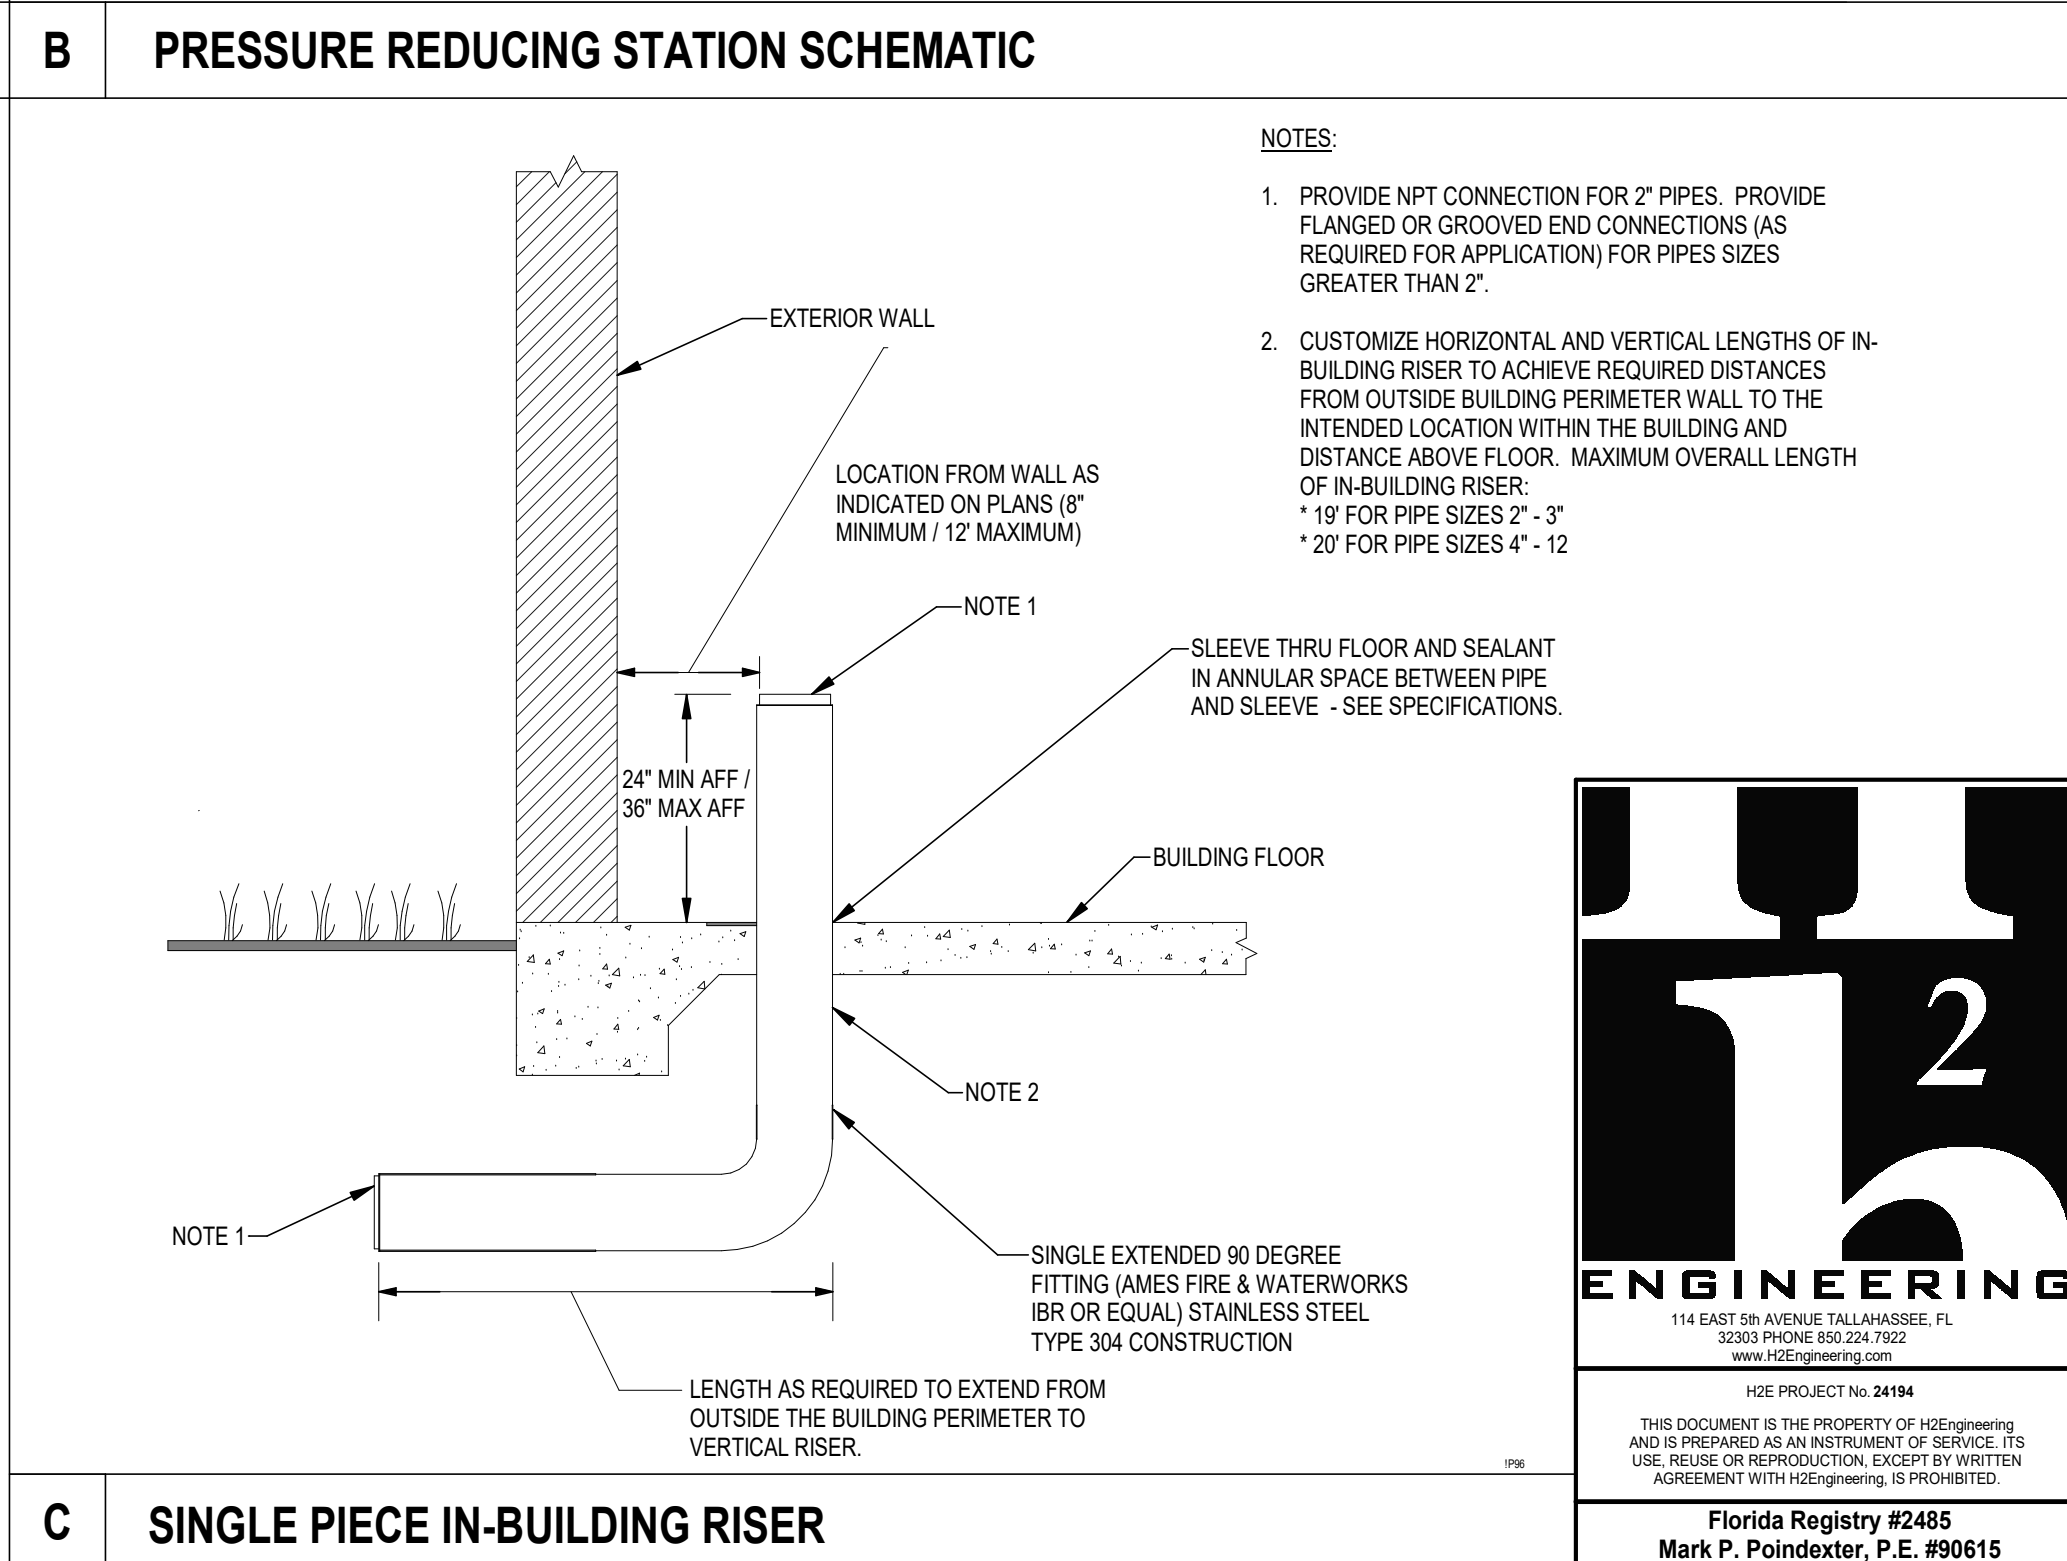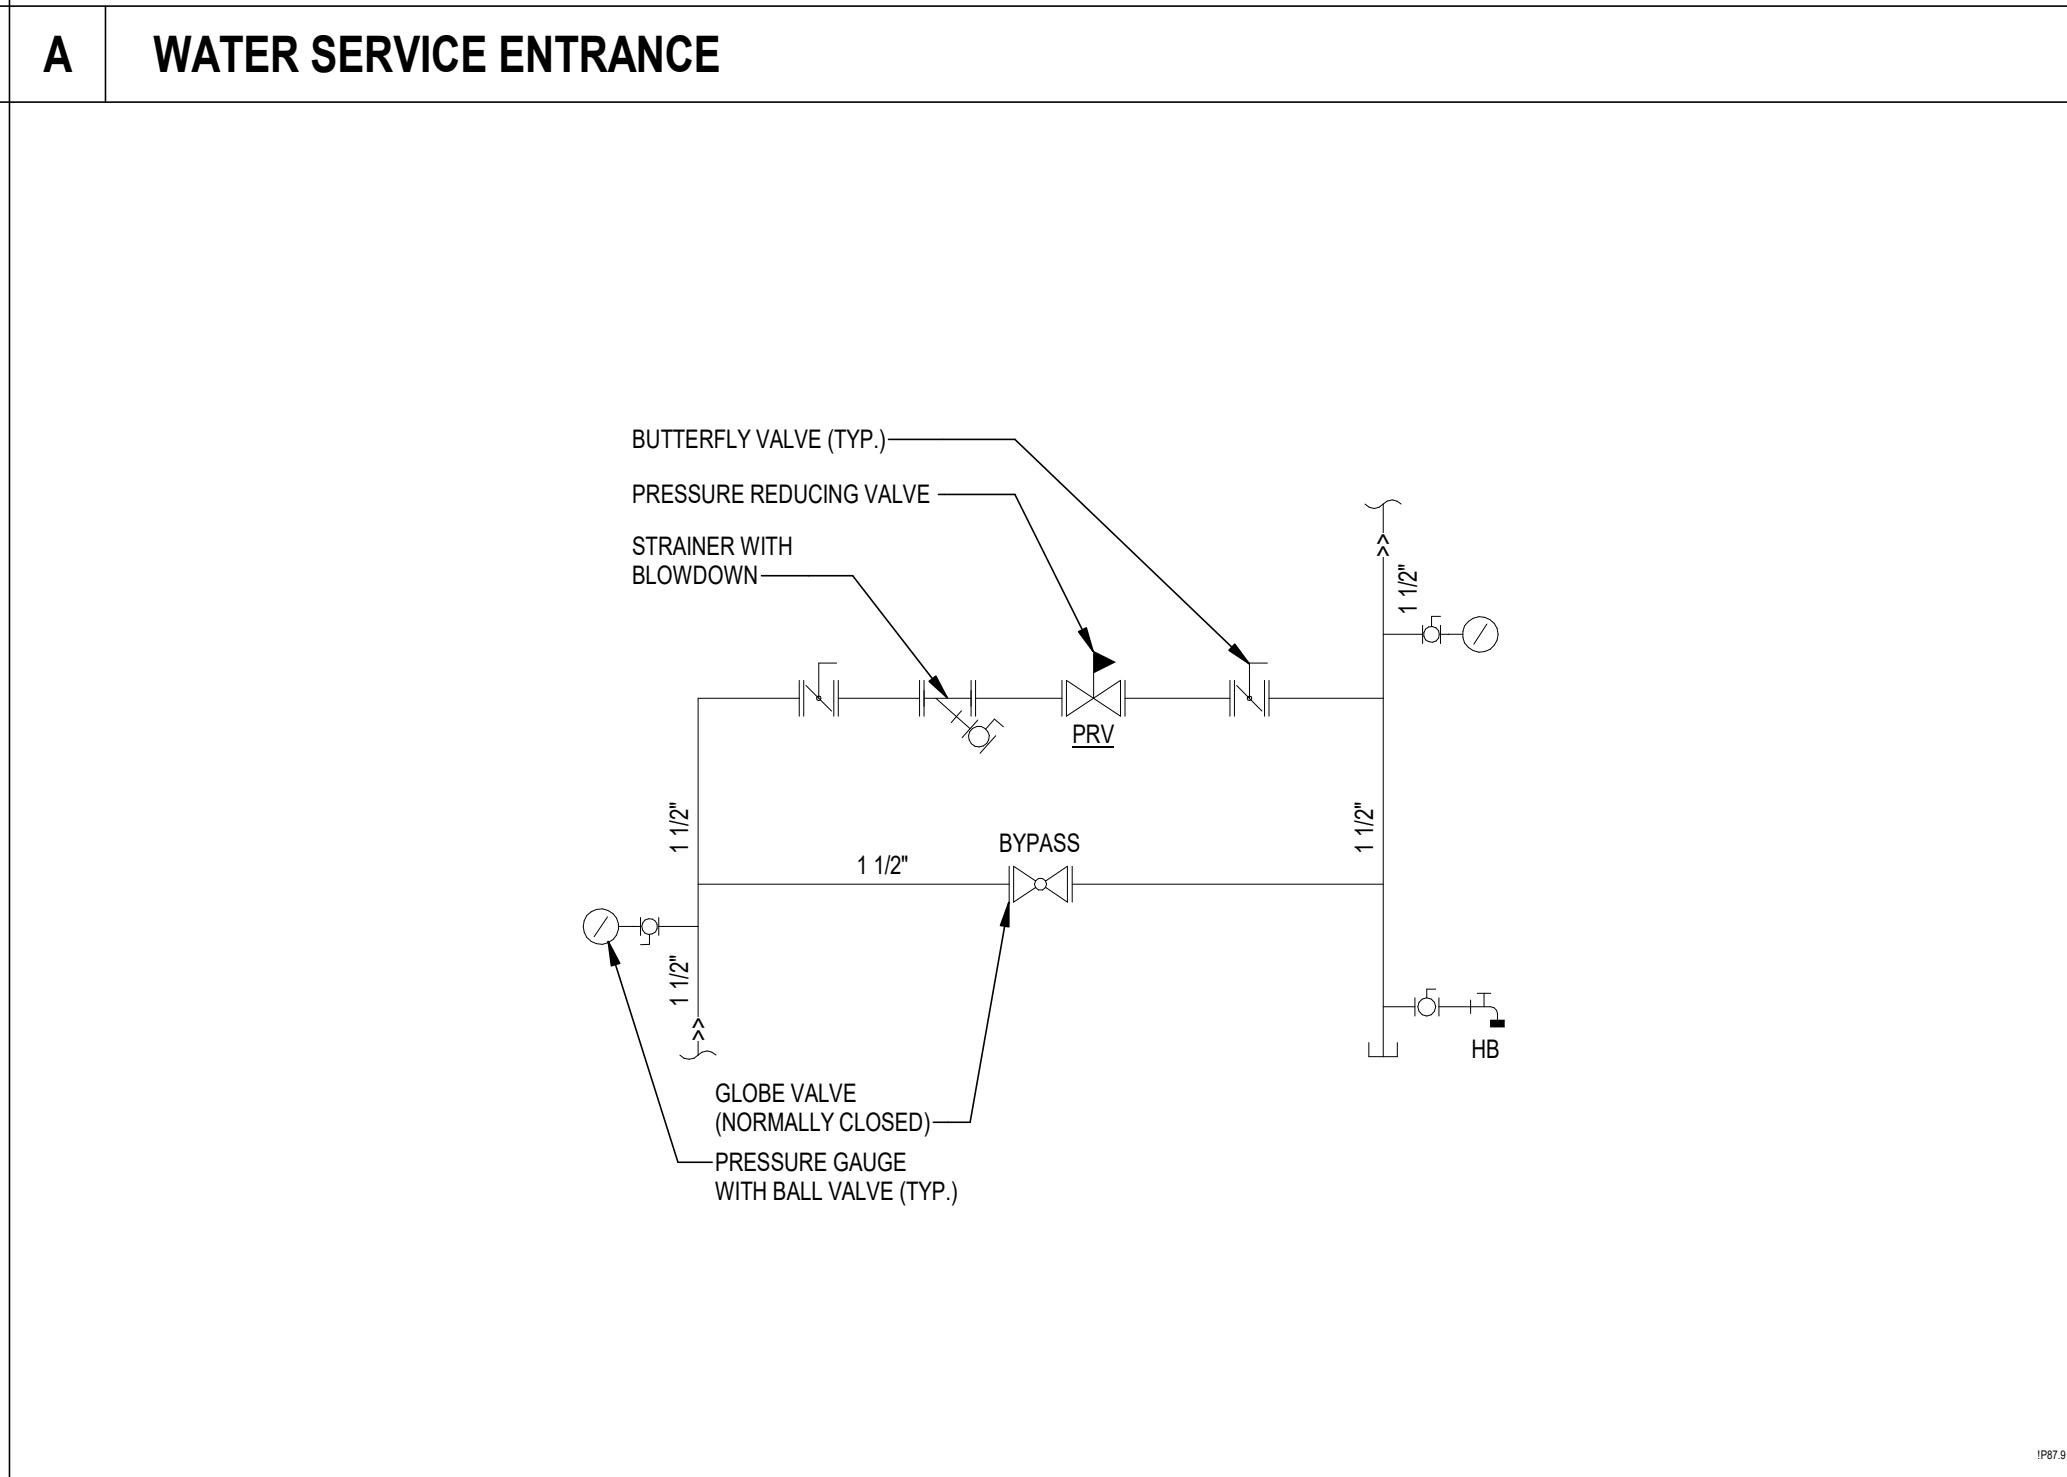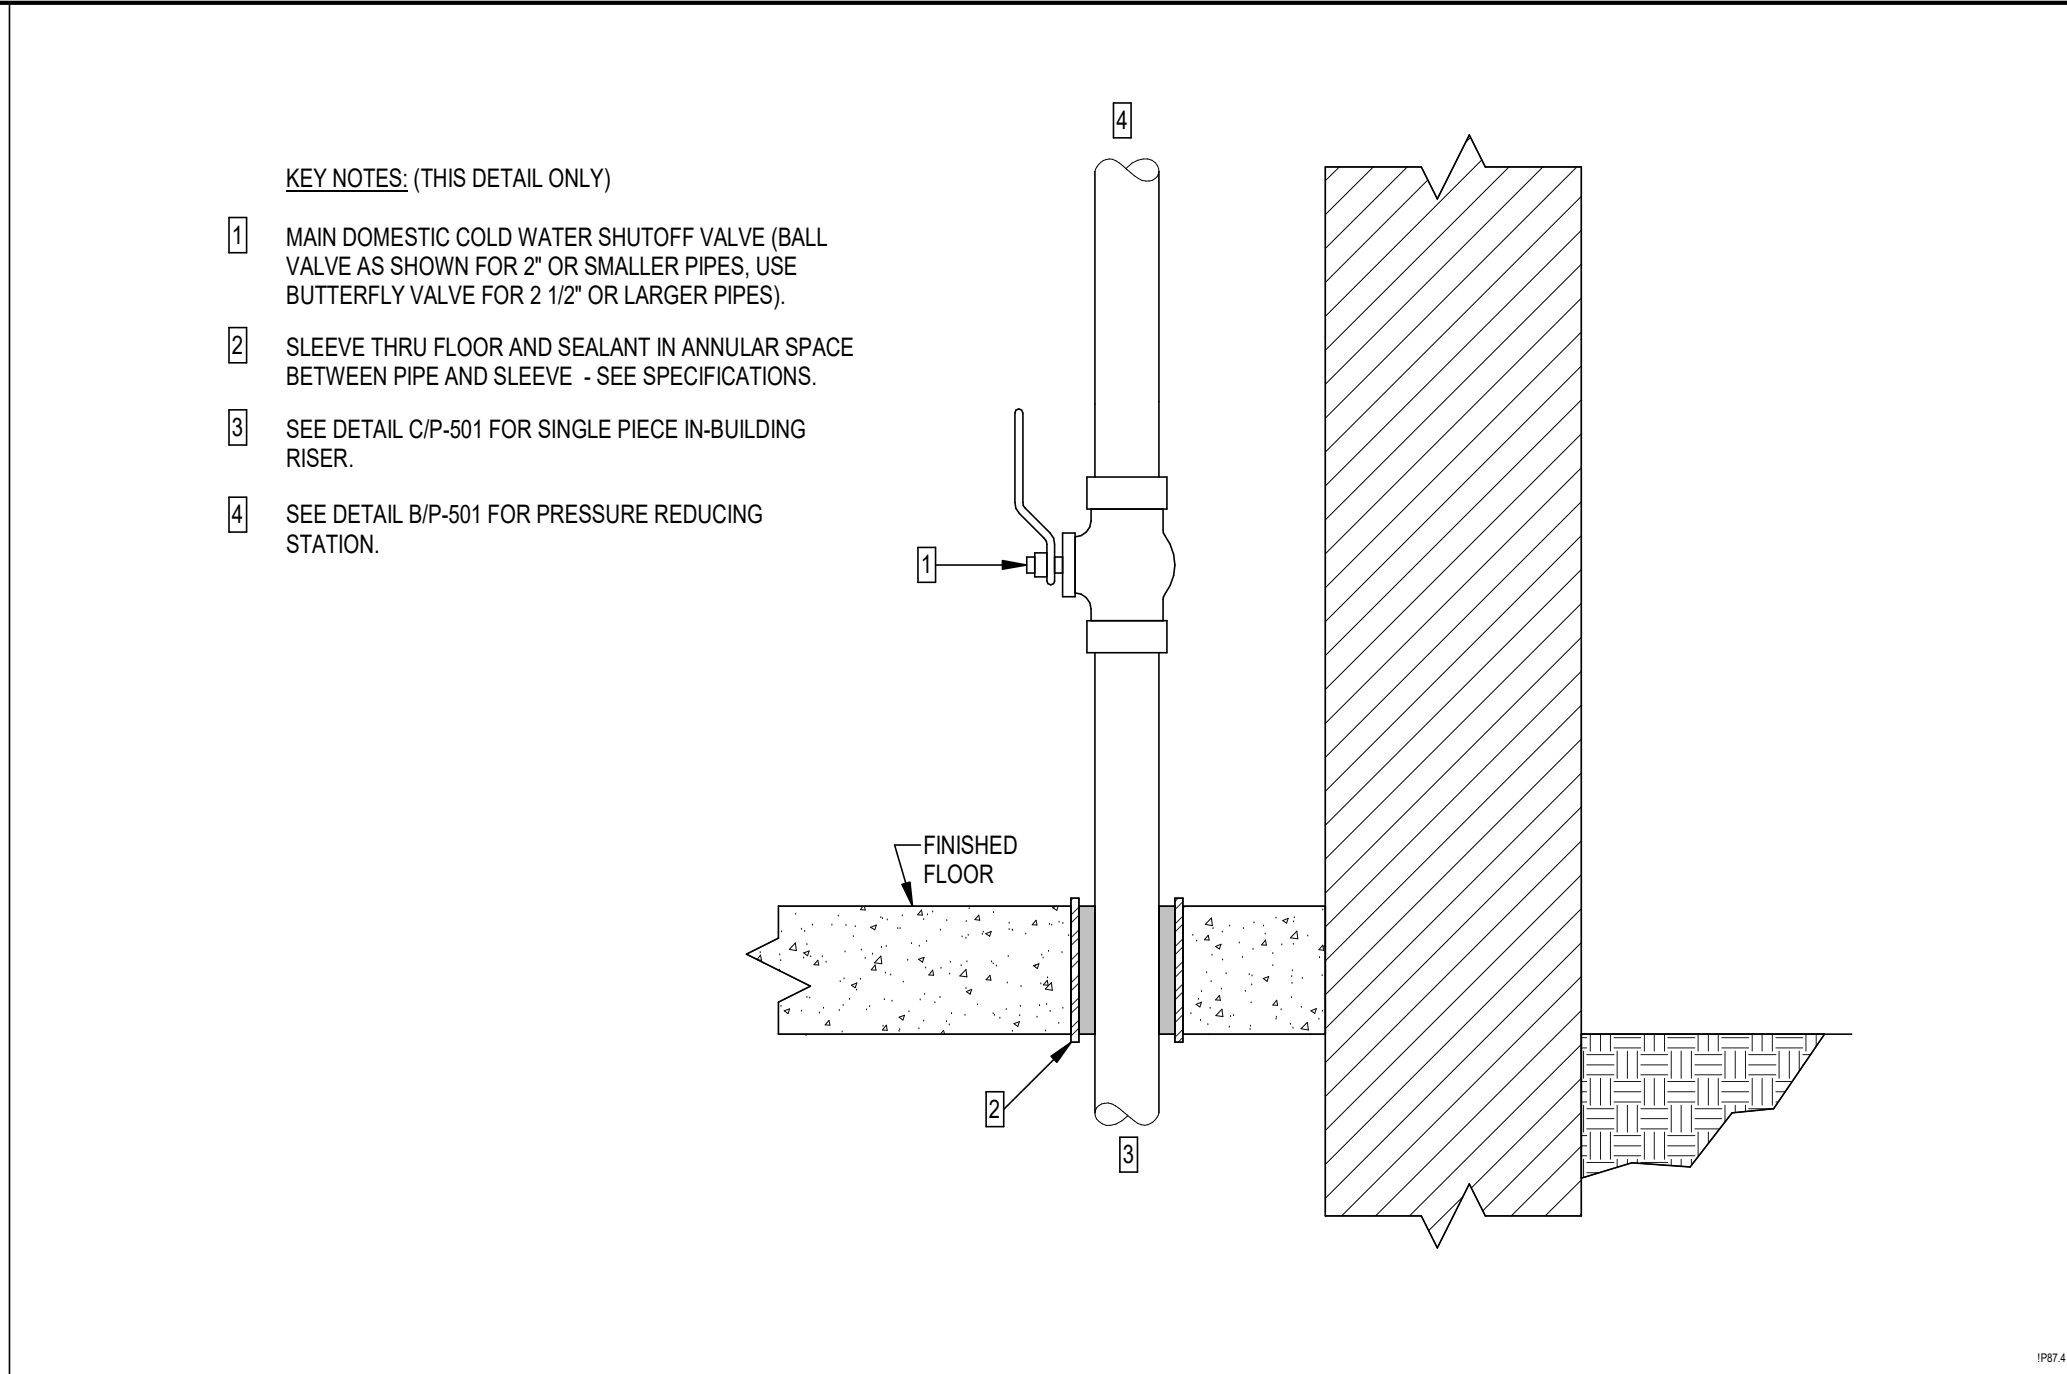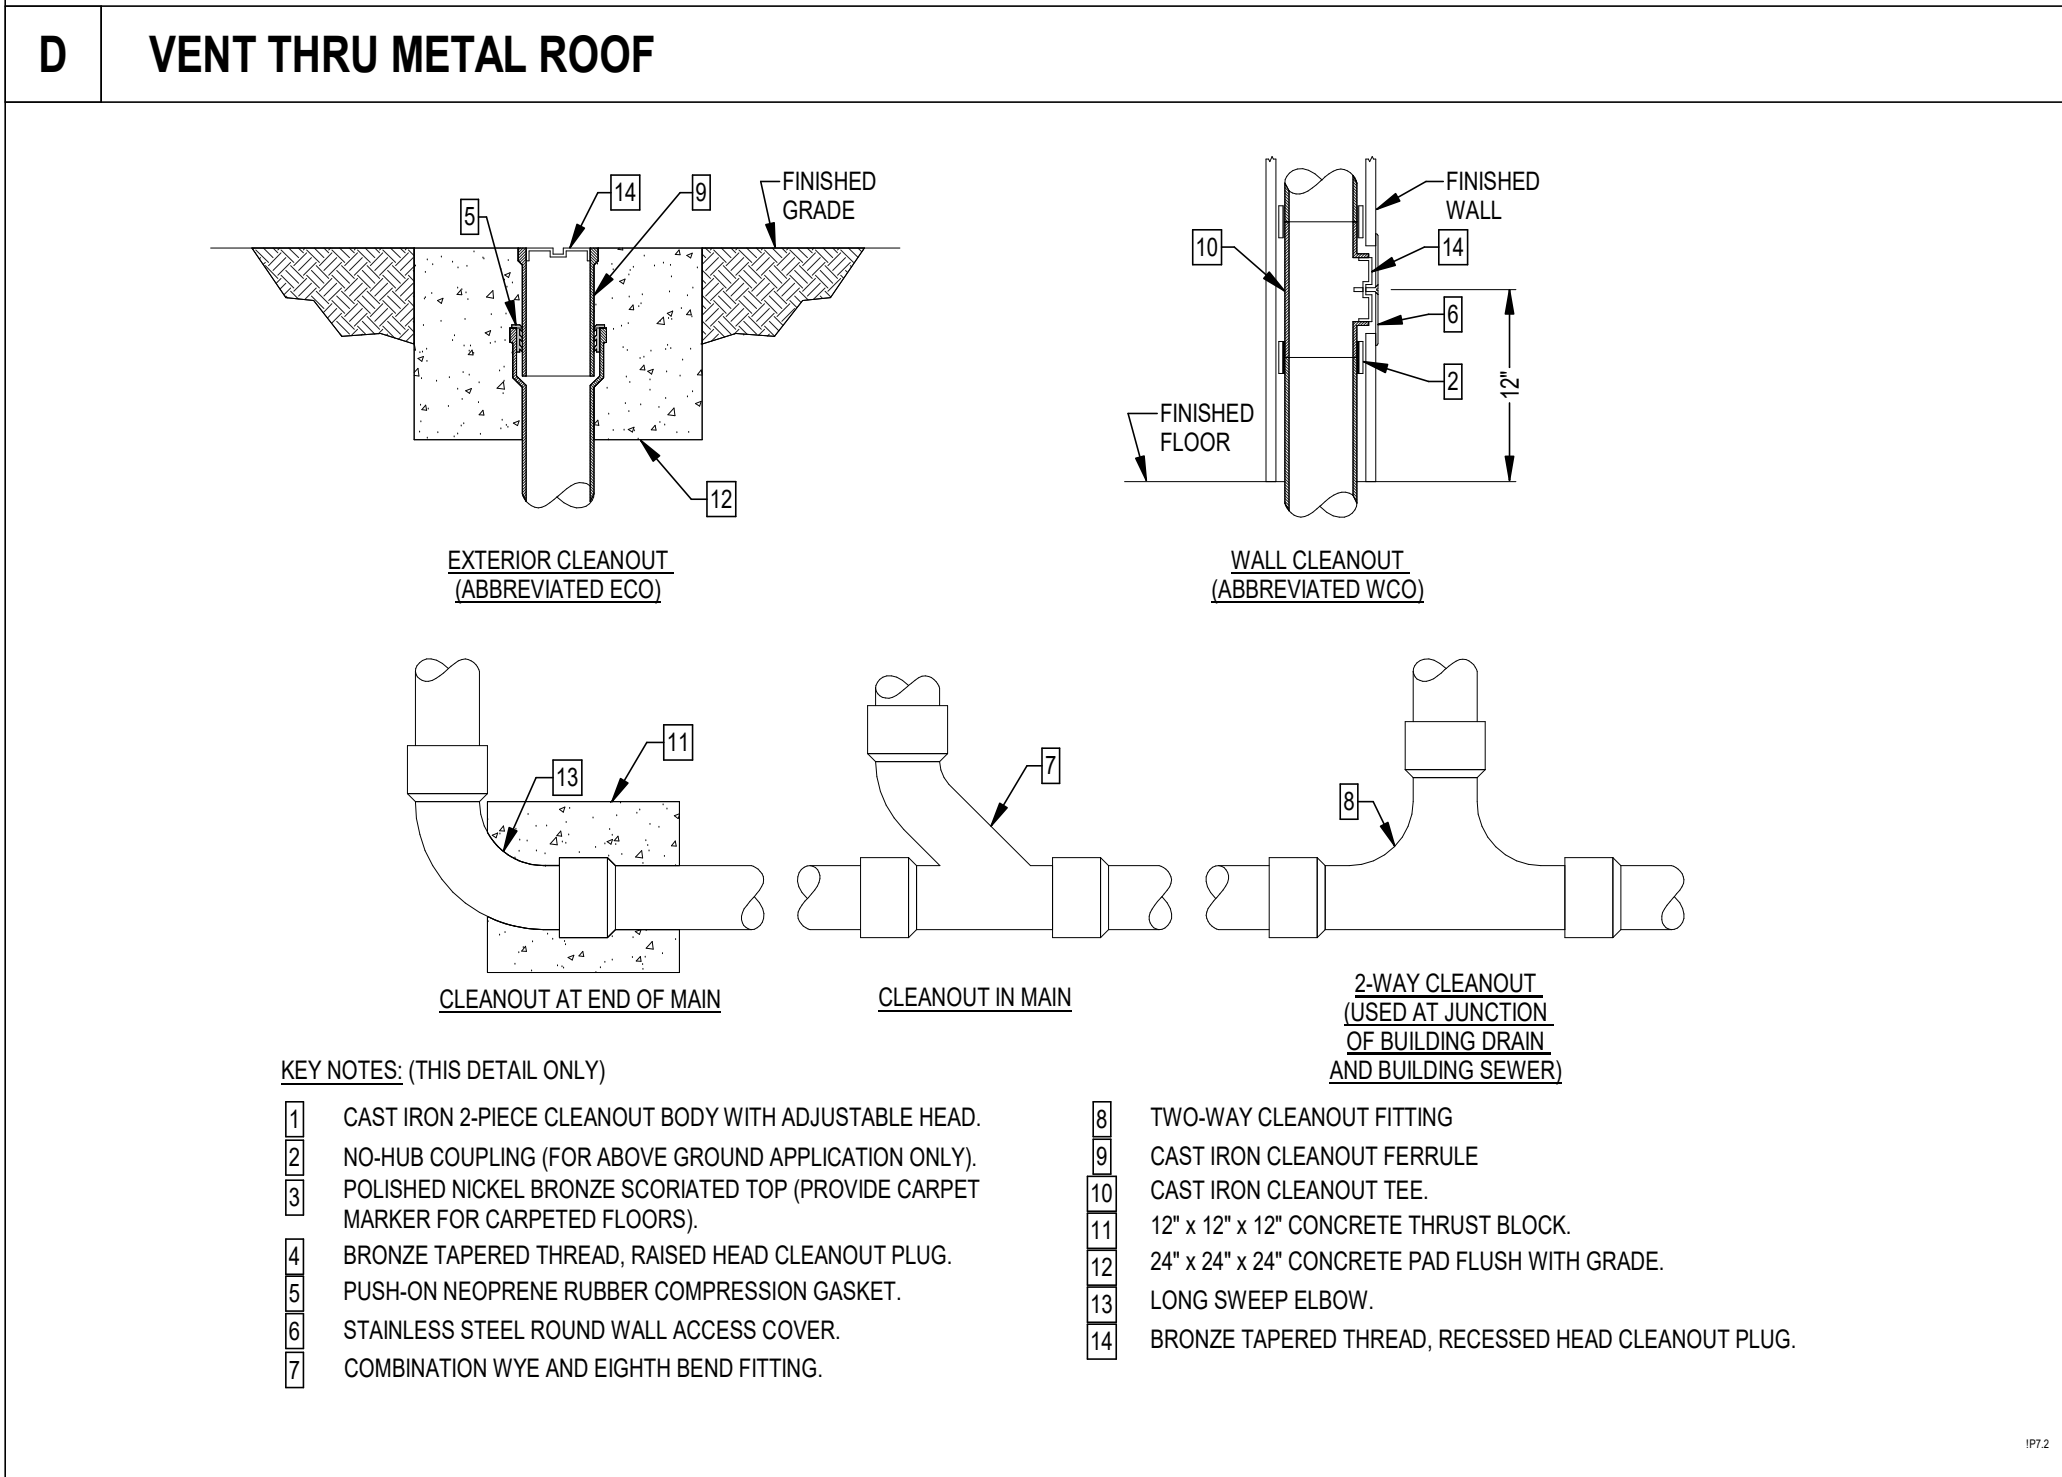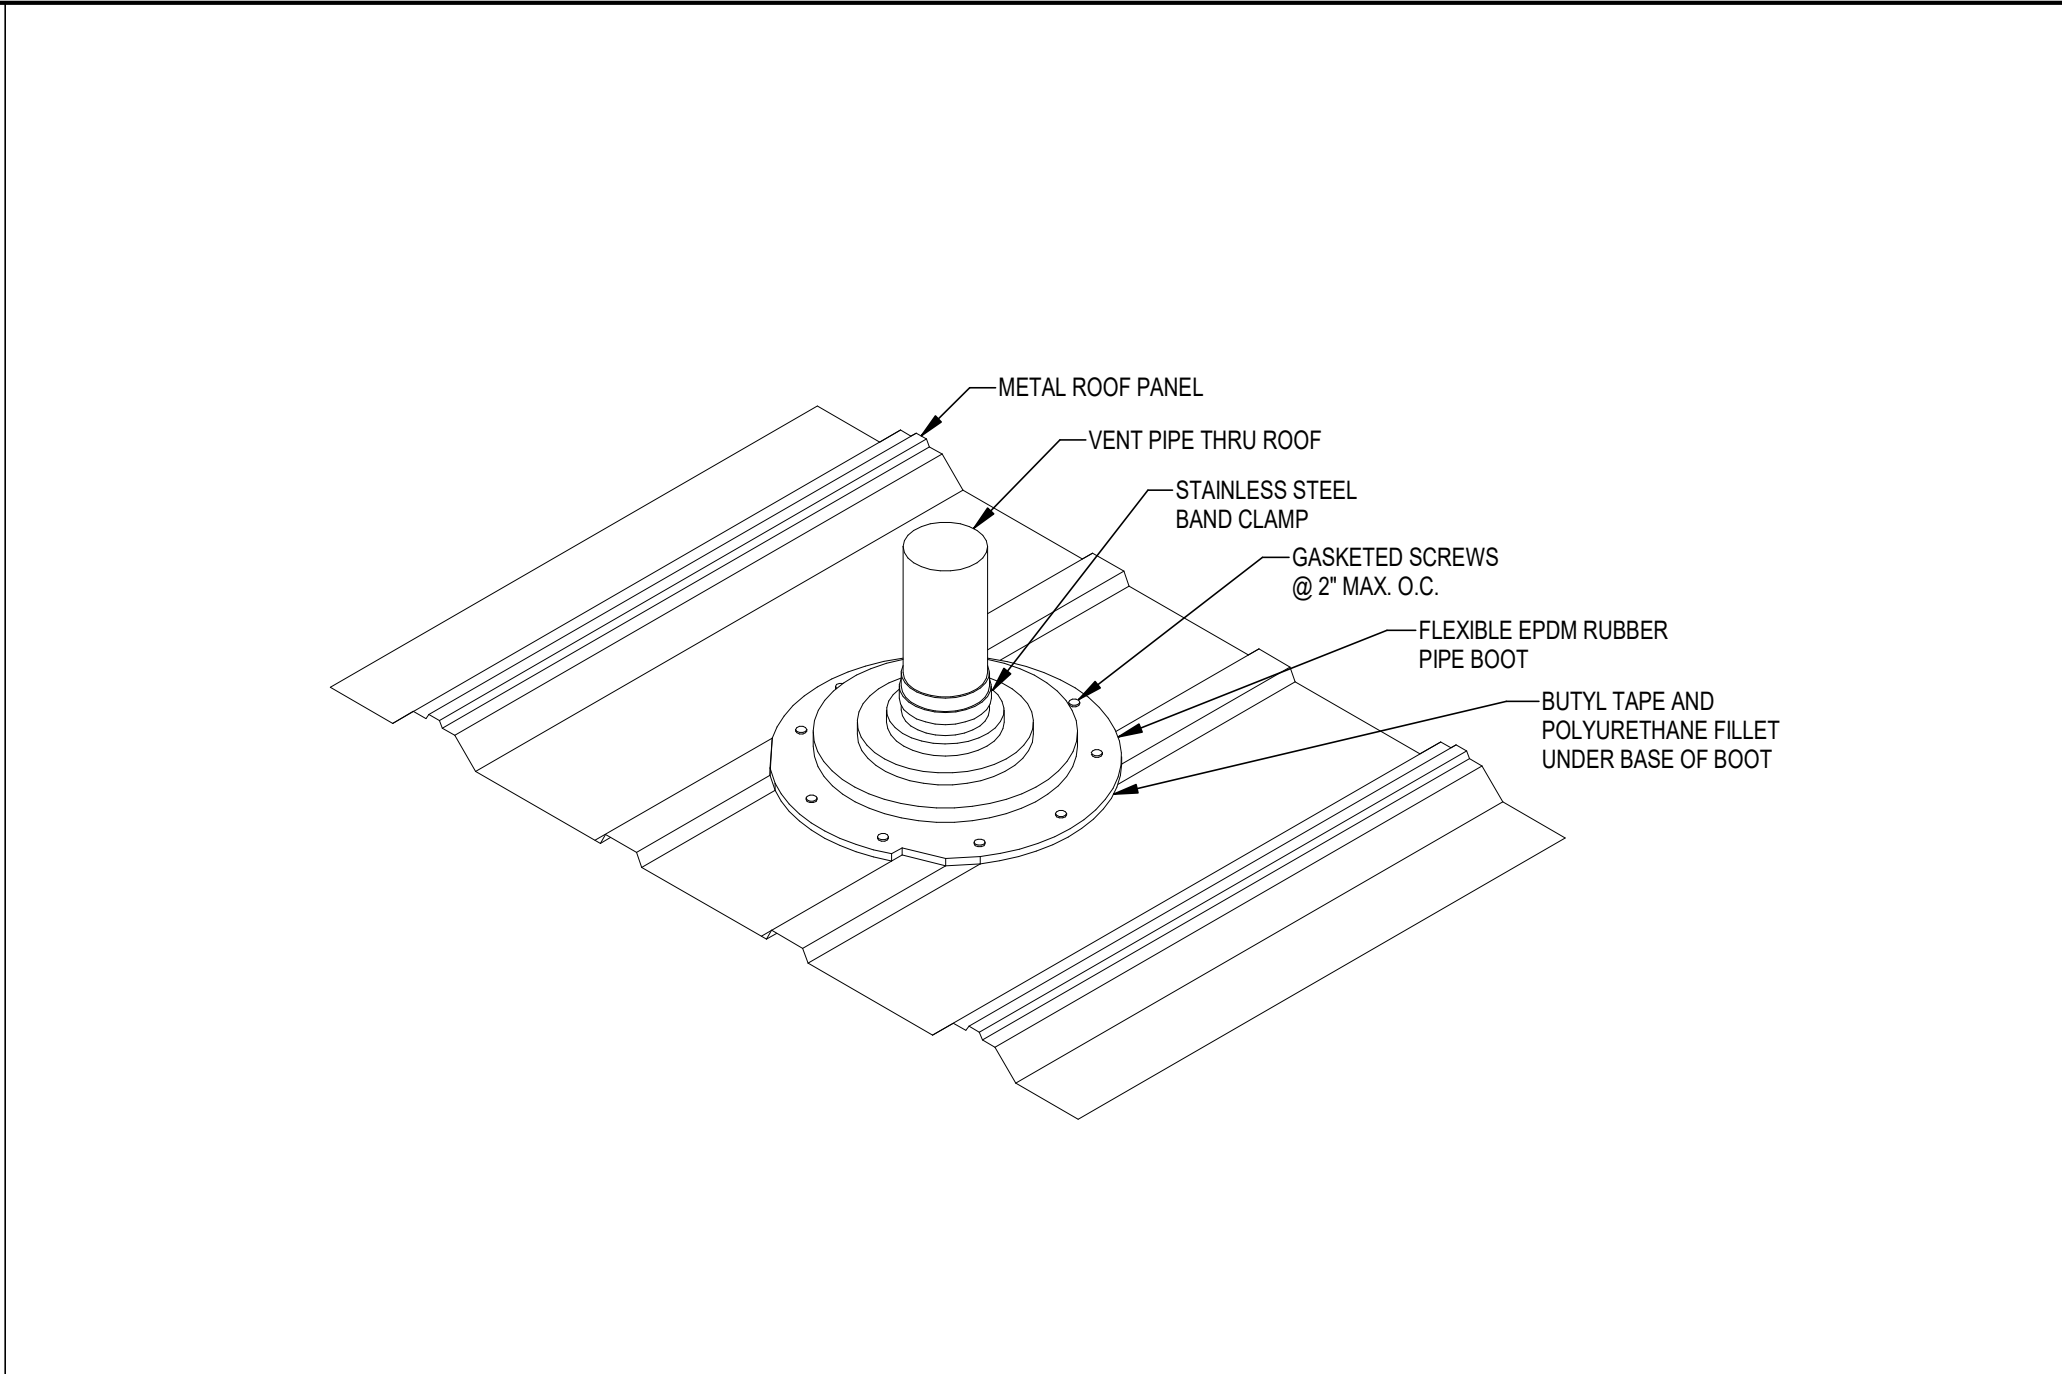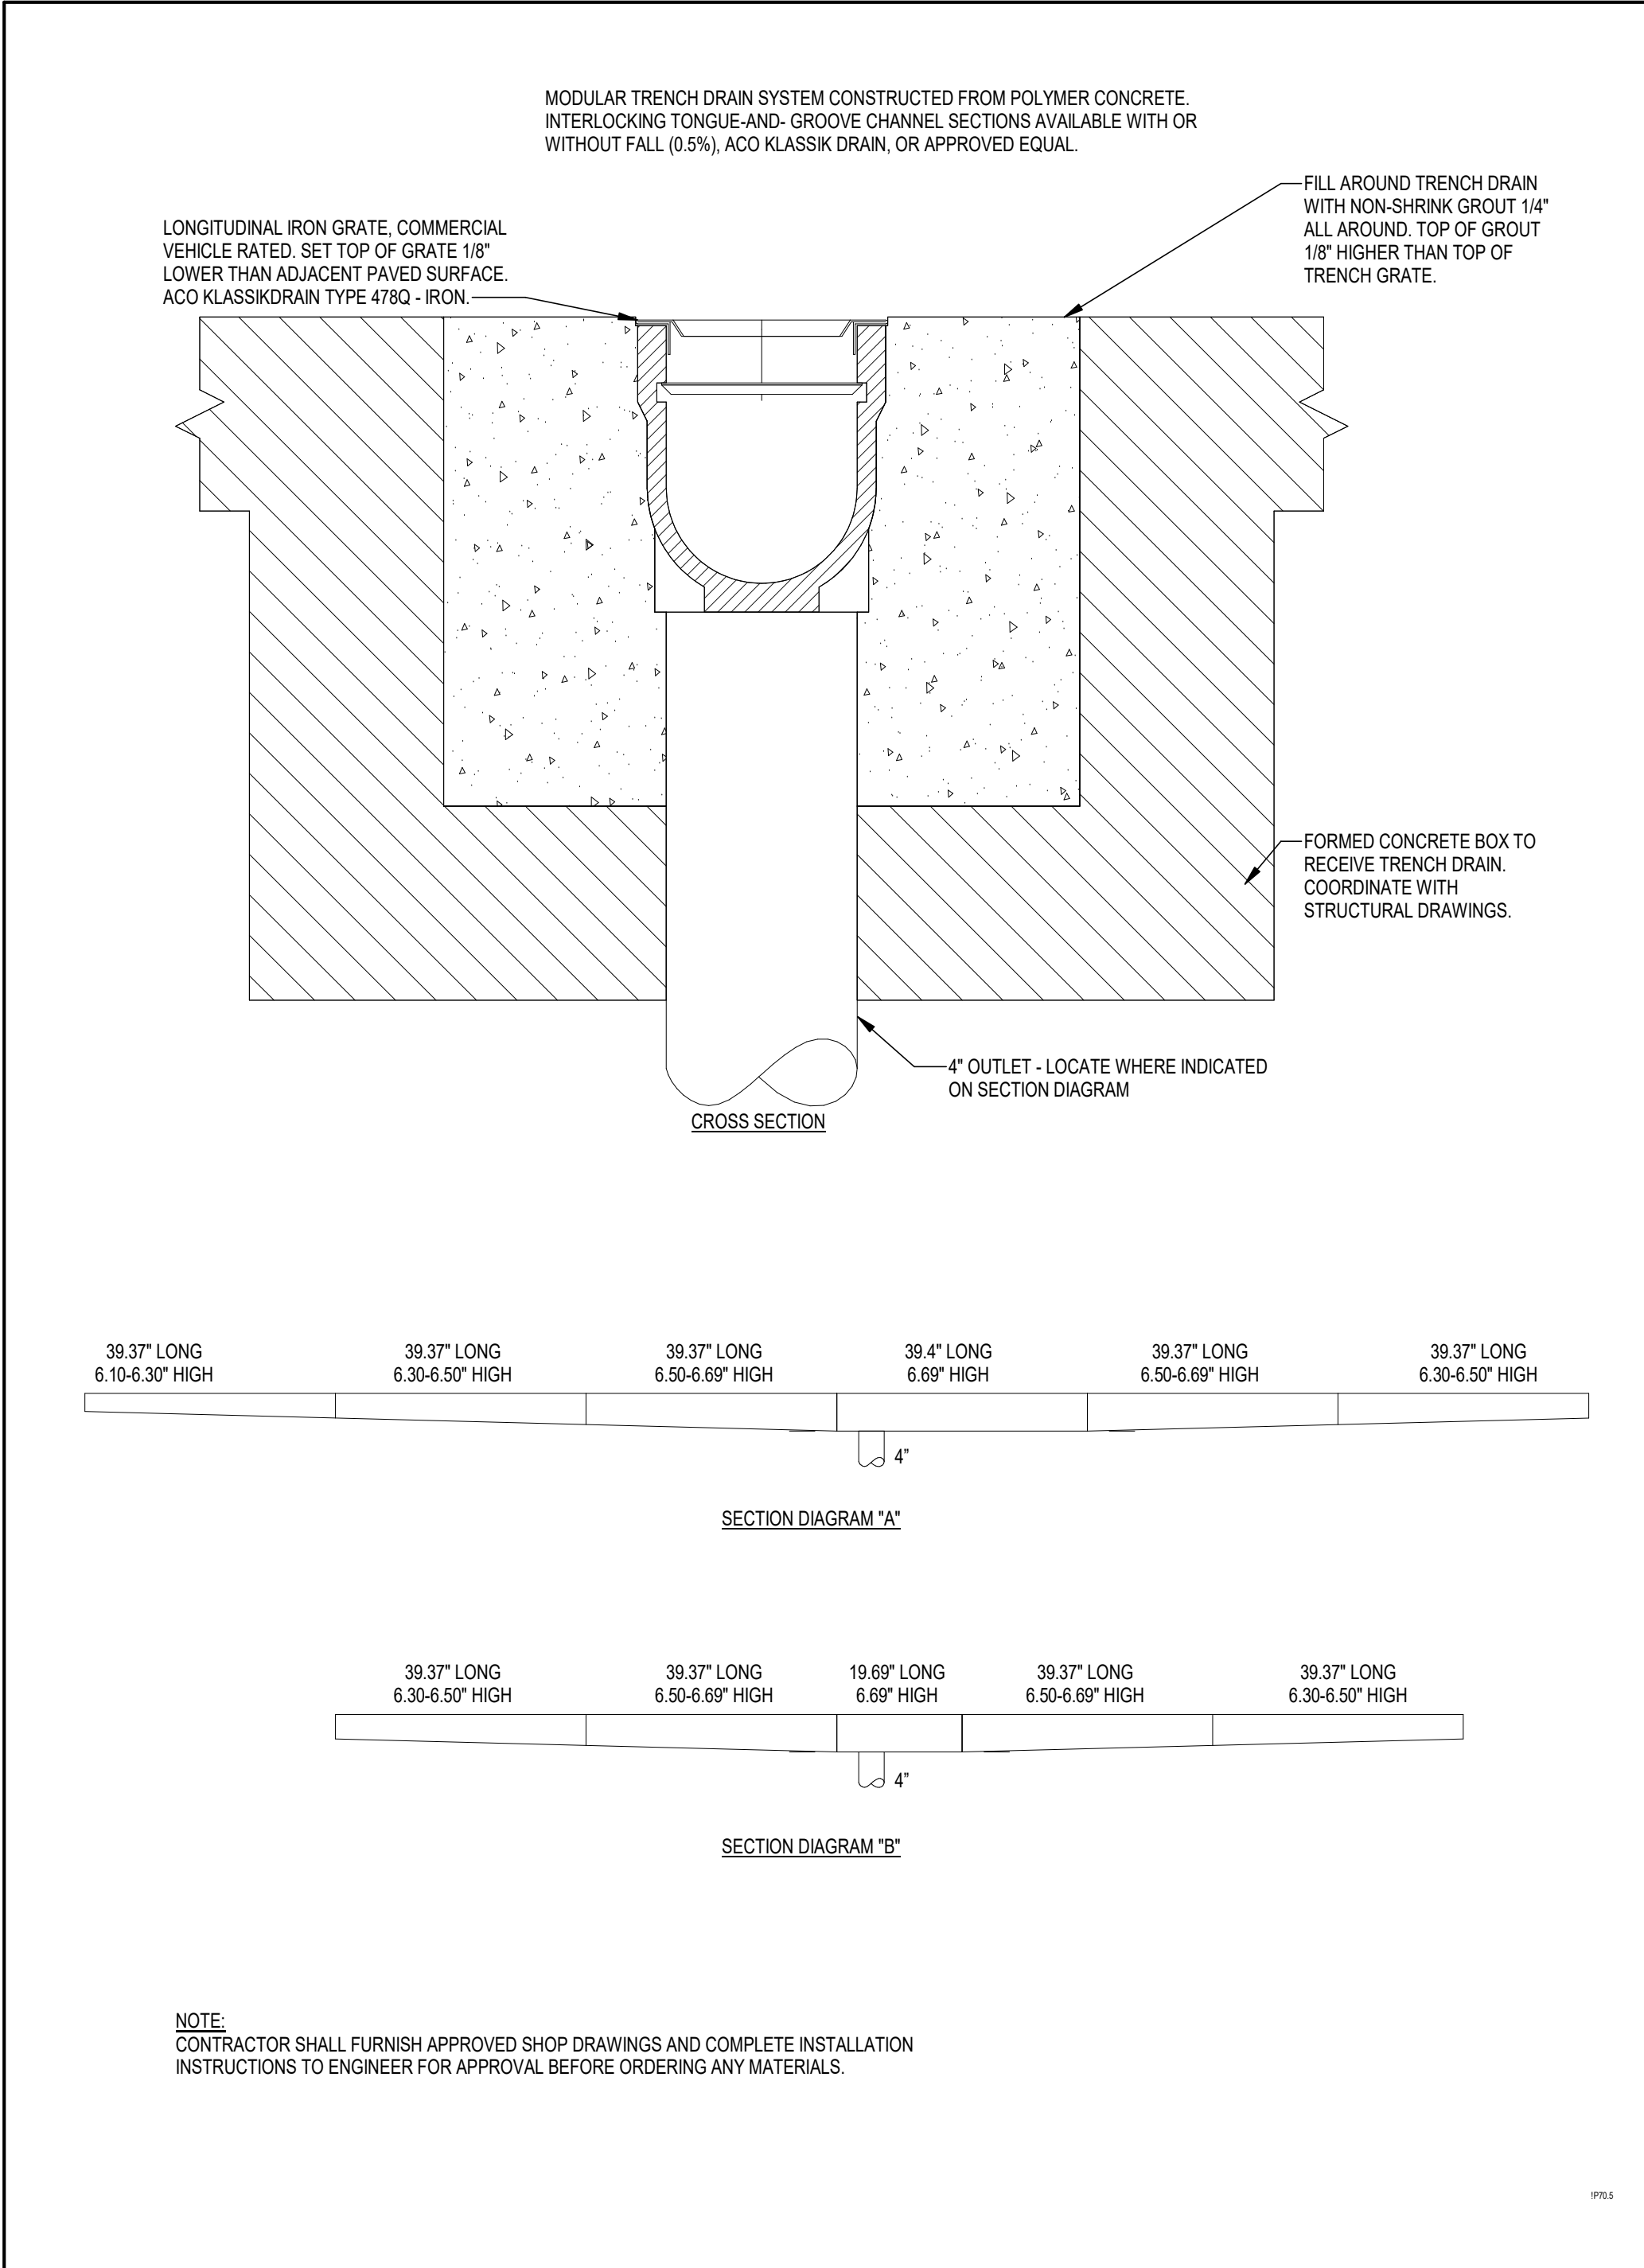

bki
ARCHITECTURE

8KJ, Inc., Architecture
1621 Physicians Dr.
Tallahassee, Florida 32308
(P) 850.778.8007 | (F) 850.548.6150
www.8karchitecture.com
FL Architecture Corporation AA260002280

SEAL:

PROJECT TITLE:
**UUPI - LBR Relocation
Support Structures For
City of Tallahassee**
1900 RANKIN AVE, Tallahassee, FL 32310

JOB NO.: 21.130
DESIGNED: FPH
DRAWN: FPH
CHECKED: MPP

THIS DRAWING AND ANY REPRODUCTIONS ARE THE PROPERTY AND COPYRIGHT OF 8KJ, INC. AND MAY NOT BE REPRODUCED, PUBLISHED, OR USED IN ANY MANNER WITHOUT WRITTEN PERMISSION OF THE ARCHITECT

REVISIONS:
2 01/09/26 Addendum 02

DRAWING PHASE:
100% Construction Documents

DRAWING TITLE:
Details

SHEET NO.:
P-501

DATE:
October 03, 2025


H2
ENGINEERING

114 EAST 5th AVENUE, TALLAHASSEE, FL 32303
PHONE 850.234.7102
www.H2Engineering.com

H2E PROJECT No. 24194

THIS DOCUMENT IS THE PROPERTY OF H2Engineering AND IS PREPARED AS AN INSTRUMENT OF SERVICE. ITS USE, REUSE OR REPRODUCTION, EXCEPT BY WRITTEN AGREEMENT WITH H2Engineering, IS PROHIBITED.

Florida Registry #2485
Mark P. Poindexter, P.E. #90615

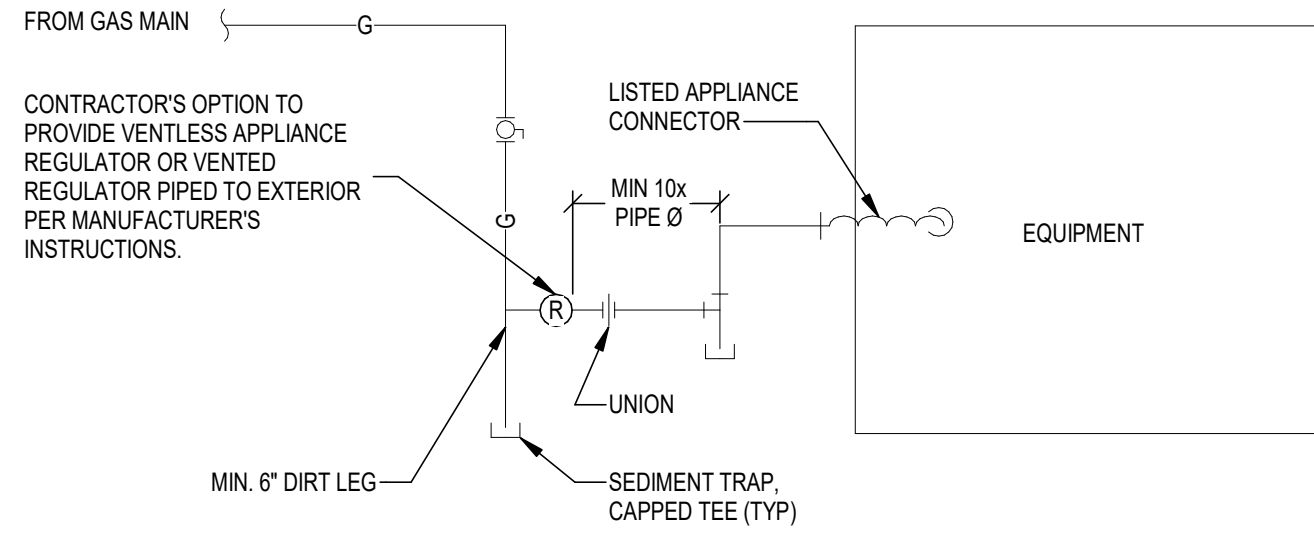

A	GAS APPLIANCE CONNECTION
----------	---------------------------------

COORDINATION NOTES

1. CONTRACTOR TO COORDINATE THE LOCATION, ALIGNMENT, ELEVATION AND/OR SPACING OF ANY EXPOSED DEVICE, FIXTURE, AND/OR PIECE OF EQUIPMENT WITH THE ARCHITECTURAL FLOOR PLANS, ELEVATIONS, AND/OR REFLECTED CEILING PLANS. DISCREPANCIES AND/OR CONFLICTS CONTAINED WITHIN THE CONTRACT DOCUMENTS SHALL BE BROUGHT TO THE ATTENTION OF THE ARCHITECT. IF AN EXPOSED ITEM IS NOT INDICATED ON THE ARCHITECTURAL DOCUMENTS NOTIFY THE ARCHITECT FOR CLARIFICATION OF PLACEMENT PRIOR TO INSTALLATION.
2. REFER TO ARCHITECTURAL REFLECTED CEILING PLANS FOR SPECIFIC LOCATIONS OF CEILING MOUNTED DEVICES. DEVICES SHALL BE INSTALLED IN THE CENTER OF CEILING TILES WHERE ADJUSTABLE CEILING SYSTEMS ARE SPECIFIED AND ON THE SAME CENTERLINES WITH OTHER ADJACENT CEILING MOUNTED DEVICES IN THE SAME AREA. IF A DEVICE LOCATION IS NOT CLEARLY INDICATED OR THERE IS A CONFLICT WITHIN THE CONTRACT DOCUMENTS NOTIFY ARCHITECT FOR CLARIFICATION PRIOR TO INSTALLATION.
3. LOCATION OF WALL AND FLOOR MOUNT DEVICES IS DIAGRAMMATIC AND SHOWN FOR CLARITY. REFER TO ARCHITECTURAL ELEVATIONS FOR EXACT LOCATION OF DEVICES. WHERE NOT INDICATED ON ARCHITECT'S PLAN COORDINATE WITH ARCHITECT PRIOR TO INSTALLATION.
4. AT EXTERIOR LOCATIONS AND IN SPACES WITH EXPOSED STRUCTURE EXPOSED UTILITIES (INCLUDING PIPING, DUCTWORK, RACEWAYS, ETC.) SHALL BE INSTALLED NEATLY, BUNDLED TOGETHER TO EXTEND POSSIBLE AND RUN AT RIGHT ANGLES TO BUILDING LINES. THESE UTILITIES SHALL BE PAINTED TO MATCH ADJACENT SURFACE OR AS DIRECTED BY ARCHITECT. HANGERS, STEEL SHAPES AND SLOTTED STEEL SUPPORTS SHALL BE PAINTED TO MATCH RACEWAY OR AS DIRECTED BY ARCHITECT. TO EXTEND POSSIBLE CONTRACTOR SHALL AVOID EXPOSED RACEWAYS BY INSTALLING UTILITIES BELOW GRADE, IN WALL, OR ABOVE ADJACENT CONCEALED CEILING SPACES.
5. PROVIDE ACCESS PANELS IN CEILING WHERE ANY DEVICE OR EQUIPMENT REQUIRING SERVICE (INCLUDING DAMPERS, VALVES, JUNCTION BOXES, CONTROLLERS, SMOKE DETECTORS, ETC.) IS LOCATED ABOVE OR BEHIND AN INACCESSIBLE CEILING OR WALL. ACCESS PANELS IN RATED CONSTRUCTION SHALL BEAR APPROPRIATE UL LABEL. COORDINATE LOCATION AND TYPE OF ACCESS PANEL WITH ARCHITECT PRIOR TO INSTALLATION.
6. PROVIDE SELF-ADHESIVE IDENTIFICATION LABELS (CLEAR WITH BLACK LETTERS) ON CEILING WHERE VESSEL, MECHANICAL, ELECTRICAL, OR STRUCTURAL EQUIPMENT ARE LOCATED ABOVE CEILINGS. AT ACCESSIBLE CEILINGS APPLY LABEL TO CEILING GRID WITHIN REACH OF DEVICE; AT INACCESSIBLE CEILINGS APPLY LABEL TO ACCESS PANEL.
7. PROVIDE CONCRETE HOUKEEPING PAD FOR ALL FLOOR, HANGER, MOUNTED EQUIPMENT WITH #4 REBAR @ 0.2' EACH WAY AND 1" COMPACTED TOP EDGE. PADS ON CONCRETE SLAB SHALL BE 4" HIGH AND 24" INTO CONCRETE. PADS ON GRAVEL OR GRADE SHALL BE 6" HIGH AND 24" SLAB AND EXPOSED IN PLACE AND SPACED 12" @ 0.2' AROUND PERIMETER. PADS ON EARTH SHALL BE MINIMUM 6" THICK AND LAYED OUT TO EXTEND A MINIMUM OF 4" ABOVE GRADE AT HIGHEST GRADE LEVEL. COMPACT EARTH BELOW PAD PRIOR TO PAD CONSTRUCTION.

COORDINATION AND/OR SHOP DRAWING NOTES

1. COORDINATION AND SHOP DRAWINGS, INCLUDING ANY BIM MODEL CREATED BY THE CONTRACTOR AND OR A THIRD PARTY FOR COORDINATION PURPOSES ARE NOT CONSTRUCTION DOCUMENTS AND DO NOT SUPERCEDE ANY REQUIREMENTS WITHIN THE CONSTRUCTION DOCUMENTS.
2. CHANGES TO EQUIPMENT OR SYSTEM LAYOUTS FROM THAT DEPICTED IN THE CONSTRUCTION DOCUMENTS THAT REQUIRE OR PROHIBIT REVISIONS, OR OTHERWISE SHALL BE BROUGHT TO THE ATTENTION OF THE ENGINEER FOR APPROVAL.
3. CHANGES SHALL BE CLOUDED AND NOTED ON THE COORDINATION OR SHOP DRAWING IN RED OR OTHER COLOR THAT CLEARLY DIFFERENTIATES THE NOTE FROM THE REMAINDER OF THE SUBMITTED DOCUMENT.
4. ONLY NOTED CHANGES SPECIFICALLY CALLED OUT WILL BE REVIEWED BY THE ENGINEER DURING THE SUBMITTAL PROCESS. THE ENGINEER WILL NOT REVIEW ANY DETAIL OF THE ENTIRE PROJECT TO LOCATE UNNOTED CHANGES MADE BY THE CONTRACTOR. CHANGES NOT SPECIFICALLY NOTED ARE AUTOMATICALLY "NOT APPROVED" REGARDLESS OF APPROVAL STATUS ON THE RETURNED SUBMITTAL.
5. CHANGES TO THE CONSTRUCTION DOCUMENTS MADE BY THE CONTRACTOR THAT ARE NOT NOTED AND BROUGHT TO THE ATTENTION OF THE ENGINEER AND THUS "NOT APPROVED" WHICH RESULT IN A COST OR SCHEDULE CHANGE TO THE PROJECT SHALL BE BURDENED TO THE CONTRACTOR WHO MADE THE CHANGE WITHOUT ANY REMUNERATION FROM THE OWNER.
6. CHANGES TO THE CONSTRUCTION DOCUMENTS MADE BY THE CONTRACTOR OR BY THE INSTALLING CONTRACTOR IS NOT A CONSTRUCTION DOCUMENT AND DOES NOT INCLUDE ALL NOTES AND DETAILS NECESSARY FOR A COMPLETE PROJECT. THE CONTRACTOR IS RESPONSIBLE FOR PROVIDING INSTALLERS WITH A COMPLETE SET OF APPROVED COORDINATION DRAWINGS INCLUDING ALL NOTES, DETAILS, ETC. INCLUDED IN THE CONSTRUCTION DOCUMENTS.

APPLICABLE CODES

PERFORM WORK IN ACCORDANCE WITH THE FOLLOWING CODES AND ANY APPLICABLE STATUTES, ORDINANCES, CODES, AND REGULATIONS OF GOVERNMENTAL AUTHORITIES HAVING JURISDICTION.

1. **ASHRAE**
 - a. STANDARD 15 SAFETY STANDARD FOR REFRIGERATION SYSTEMS - 2019
 - b. STANDARD 90.1 ENERGY STANDARD FOR BUILDINGS EXCEPT LOW RISE RESIDENTIAL BUILDINGS - 2019
2. OCCUPATIONAL SAFETY AND HEALTH REGULATIONS (OSHA).
3. **NATIONAL FIRE CODES**
 - a. NFPA 1 UNIFORM FIRE CODE - 2021 (FLORIDA EDITION)
 - b. NFPA 30 FLAMMABLE AND COMBUSTIBLE LIQUIDS CODE - 2021
 - c. NFPA 52 VEHICULAR GASEOUS FUEL SYSTEMS CODE - 2019
 - d. NFPA 54 NATIONAL FUEL GAS CODE - 2021
 - e. NFPA 70 NATIONAL ELECTRICAL CODE - 2020
 - f. NFPA 101 LIFE SAFETY CODE - 2021 (FLORIDA EDITION)
4. **FLORIDA BUILDING CODE, 2023 EDITION**
 - a. BUILDING CODE
 - b. ENERGY CONSERVATION CODE
 - c. PLUMBING CODE
 - d. FUEL GAS CODE
 - e. ACCESSIBILITY CODE
5. **FLORIDA STATUTES**
 - a. CHAPTER 471 ENGINEERING
 - b. CHAPTER 533.80 BUILDING CONSTRUCTION STANDARDS; FLORIDA BUILDING CODE - ENFORCEMENT
6. **FLORIDA ADMINISTRATIVE CODE**
 - a. CHAPTER 9B-7 FLORIDA BUILDING COMMISSION HANDICAPPED ACCESSIBILITY STANDARDS
 - b. CHAPTER 61G15-34 RESPONSIBILITY RULES OF PROFESSIONAL ENGINEERS CONCERNING THE DESIGN OF MECHANICAL SYSTEMS
 - c. CHAPTER 69A-3 FIRE PREVENTION - GENERAL PROVISIONS
 - d. CHAPTER 69A-60 THE FLORIDA FIRE PREVENTION CODE

RESOLVE, IN WRITING, ANY CODE VIOLATION DISCOVERED IN CONTRACT DOCUMENTS WITH THE ENGINEER PRIOR TO BIDDING. AFTER AWARD OF THE CONTRACT, MAKE ANY CORRECTION OR ADDITION NECESSARY FOR COMPLIANCE WITH APPLICABLE CODES AT NO ADDITIONAL COST TO OWNER.

THE CONTRACTOR SHALL INCLUDE IN THE WORK, WITHOUT EXTRA COST TO THE OWNER, ANY LABOR, MATERIALS, SERVICES, APPARATUS, AND DRAWINGS REQUIRED TO COMPLY WITH ALL APPLICABLE LAWS, ORDINANCES, RULES, AND REGULATIONS.

WHERE THERE IS CONFLICT BETWEEN THE CONTRACT DOCUMENTS AND THE APPLICABLE CODES, THE CODES SHALL GOVERN, EXCEPT WHERE THE REQUIREMENTS OF THE CONTRACT DOCUMENTS ARE MORE STRINGENT.

PIPING AND FITTINGS

	CAP
	ELBOW TURNED UP
	ELBOW TURNED DOWN
	TEE, OUTLET UP
	TEE, OUTLET DOWN
	GAS PIPING

VALVES

		BALL VALVE (WITH QUARTER TURN HANDLE)
		BUTTERFLY VALVE (WITH QUARTER TURN HANDLE)
		PLUG VALVE

MEASUREMENTS AND CONTROLS

(R)	GAS REGULATOR
(M)	METER (WATER OR GAS)

ABBREVIATIONS

AC	ABOVE CEILING	BG	BELOW GRADE
AF	ABOVE FLOOR	DN	DOWN
AFF	ABOVE FINISHED FLOOR	N/A	NOT APPLICABLE
AHAP	AS HIGH AS POSSIBLE	NIS	NOT IN SCOPE
BF	BELOW FLOOR	TYP	TYPICAL

GENERAL NOTES

1. INSTALL ALL WORK IN ACCORDANCE WITH THE FLORIDA BUILDING CODE 2023, THE FLORIDA FIRE PREVENTION CODE, THE NATIONAL ELECTRICAL CODE 2020 EDITION, AND ALL CODES, ORDINANCES, RULES AND REGULATIONS OF AUTHORITIES HAVING JURISDICTION AT THIS SITE. WHERE CONFLICTS OCCUR BETWEEN THE SPECIFICATIONS AND THE CONSTRUCTION DOCUMENTS, THE MOST RESTRICTIVE REQUIREMENTS SHALL GOVERN.
2. DRAWINGS ARE DIAGRAMMATIC, INDICATIVE OF WORK TO BE FURNISHED AND INSTALLED UNDER THIS CONTRACT. REFER TO ARCHITECTURAL AND STRUCTURAL DRAWINGS FOR ALL DIMENSIONS.
3. FIELD VERIFY ALL DIMENSIONS AND ALL CONDITIONS. IF THE CONTRACTOR IS UNABLE TO INTERPRET THE CONTRACT DOCUMENTS, THE CONTRACTOR IS RESPONSIBLE FOR REQUEST CLARIFICATION IN WRITING TO THE ARCHITECT/ENGINEER. ANY WORK BEING DONE WITH ANY WORK BEFORE OBTAINING CLARIFICATION, CONTRACTOR SHALL BE HELD RESPONSIBLE FOR ALL DEFICIENCIES ASSOCIATED THEREWITH.
4. BEFORE SUBMITTING FOR THE WORK, EACH BIDDER WILL BE RESPONSIBLE TO EXAMINE THE PREMISES AND SATISFY HIMSELF AS TO THE EXISTING CONDITIONS UNDER WHICH CONTRACTOR WILL BE OBLIGED TO OPERATE AND COMPLETE THE WORK UNDER THIS CONTRACT. NO ALLOWANCE WILL SUBSEQUENTLY BE MADE FOR ANY DISCREPANCY OR CONNECTION ON BEHALF OF THE CONTRACTOR FOR ANY ERROR OR OMISSION ON CONTRACTOR'S PART.
5. THE CONTRACTOR SHALL PAY FOR ALL INSPECTION PERMITS, CERTIFICATES, CONNECTION FEES, SYSTEM DEMAND CHARGES AND LICENSE FEES IN CONNECTION WITH CONTRACTOR'S WORK.
6. GENERAL CONTRACTOR SHALL BE RESPONSIBLE FOR COORDINATING WORK OF ALL SUBCONTRACTORS AND TO INTERFERE WITH ANY OTHER TRADES.
7. ALL WORK SHALL COMPLY WITH APPLICABLE O.S.H.A. AND E.P.A. REGULATIONS AND GUIDELINES.
8. ERECT AND MAINTAIN ALL REASONABLE PRECAUTIONS FOR SAFETY AND HEALTH INCLUDING POSTING DANGER SIGNS AND OTHER WARNINGS AGAINST HAZARDS INCLUDING PROMULGATING SAFETY REGULATIONS. PROVIDE SAFETY PRECAUTIONS AND BARRICADES FOR PEDESTRIANS AT ALL TIMES ON THE WORK SITE. PROVIDE ACCESS AND EGRESS TO ALL AREAS.
9. COORDINATE AND SEQUENCE ALL DEMOLITION, CLEANING AND CONSTRUCTION WORK. SUBMIT A COMPLETELY DETAILED CONSTRUCTION SCHEDULE PRIOR TO PRE-CONSTRUCTION CONFERENCE.
10. THE CONTRACTOR SHALL STRICTLY BE HELD TO THE PROJECT SCHEDULE. CONTRACTOR SHALL PROVIDE SUFFICIENT MANPOWER AND EQUIPMENT TO FULLY MOBILIZE, PROCEED WITH AND COMPLETE THE WORK.
11. THE CONTRACTOR SHALL BE RESTRICTED TO AREAS SPECIFIED BY THE OWNER FOR ON-SITE STORAGE OF CONSTRUCTION MATERIALS. THE CONTRACTOR IS RESPONSIBLE FOR THE PROTECTION AND SECURITY OF ALL EQUIPMENT AND MATERIALS.
12. THE CONTRACTOR SHALL MAINTAIN A CLEAN WORK ENVIRONMENT AT ALL TIMES AND SHALL CLEAN UP ALL DEBRIS AND WASTE DURING AND AT THE COMPLETION OF THE JOB AND BEFORE FINAL PAYMENT IS MADE.
13. THE CONTRACTOR SHALL FURNISH "AS-BUILT" DRAWINGS TO THE OWNER AT COMPLETION OF CONSTRUCTION.
14. CONTRACTOR SHALL GUARANTEE THE WORK AND MATERIALS FOR A PERIOD OF ONE YEAR FROM DATE OF FINAL ACCEPTANCE. THIS GUARANTEE SHALL BE IN ADDITION TO THE WARRANTIES PROVIDED BY THE MANUFACTURER OF THE MATERIALS AND EQUIPMENT.
15. CONTRACTOR'S USE OF APPROVAL STAMP ON DOCUMENTS SUBMITTED AS SHOP DRAWINGS, PRODUCT DATA, SAMPLES AND SIMILAR SUBMITTALS CERTIFIES THAT THE CONTRACTOR HAS COMPLIED WITH THE CONTRACT DOCUMENT REQUIREMENTS RELATED TO "SHOP DRAWINGS, PRODUCT DATA AND SAMPLES".
16. THE CONTRACTOR SHALL NOT BE RELIEVED OF RESPONSIBILITY FOR DEVIATIONS FROM REQUIREMENTS OF THE CONTRACT DOCUMENTS BY THE ARCHITECT/ENGINEER'S APPROVAL OF SHOP DRAWINGS, PRODUCT DATA, SAMPLES OR SIMILAR SUBMITTALS UNLESS THE CONTRACTOR HAS SPECIFICALLY INFORMED THE ARCHITECT/ENGINEER IN WRITING OF SUCH DEVIATION AT THE TIME OF SUBMITTAL AND THE ARCHITECT/ENGINEER HAS GIVEN WRITTEN APPROVAL TO THE SPECIFIC DEVIATION. THE CONTRACTOR SHALL NOT BE RELIEVED OF RESPONSIBILITY FOR ERRORS OR OMISSIONS IN SHOP DRAWINGS, PRODUCT DATA, SAMPLES OR SIMILAR SUBMITTALS BY THE ARCHITECT/ENGINEER'S APPROVAL THEREOF.
17. PRIOR TO INSTALLATION, COORDINATE AND ADJUST THE FINAL LOCATION OF ALL WALL MOUNTED DEVICES AND EQUIPMENT WITH ALL CASEWORK, SHELVING, MARKER BOARDS, BULLETIN BOARDS OR OTHER WALL MOUNTED FURNISHINGS.
18. ALL EXTERIOR STRUCTURES INVOLVED IN INSTALLING THE EQUIPMENT IN THE BUILDING, DISMANTLING AND REASSEMBLING OF ANY EQUIPMENT SHALL BE DONE AS REQUIRED FOR ENTRY INTO THE BUILDING AND EQUIPMENT ROOMS.
19. PROTECT THE ROOF FROM DAMAGE WHENEVER ANY WORK ON THE ROOF IS REQUIRED.
20. SUPPORTS AND HANGERS SHALL PRESENT A NEAT, ORDERLY APPEARANCE.
21. ALL EXTERIOR STRUCTURES INCLUDED, BUT NOT LIMITED TO, THE GENERATOR AND GENERATOR FENCE/WALL, SHALL BE INSTALLED TO RESIST 120 MPH WIND LOAD.
22. BEAM AND FLOOR PENETRATIONS SHALL BE APPROVED BY THE STRUCTURAL ENGINEER. BEAM SLEEVES AND BEAM REINFORCING APPROVED BY STRUCTURAL ENGINEER SHALL BE FURNISHED AND INSTALLED BY THIS SUBCONTRACTOR.
23. CONSTRUCTION SHALL BE IN ACCORDANCE WITH THE "TRENCH SAFETY ACT" (FLORIDA STATUTE 553 PART II) AND OSHA STANDARD 29 CFR 1926.503 SUBPART C FOR ALL UTILITY TRENCHES IN EXCESS OF 5 FEET DEEP. CONTRACTOR SHALL INDICATE WITHIN HIS BID RESPONSE A REFERENCE TO THE TRENCH SAFETY STANDARD AND A SEPARATE LINE ITEM COST OF COMPLIANCE WITH STANDARD.

GAS FUEL NOTES

1. INSTALL ALL WORK IN ACCORDANCE WITH THE FLORIDA PLUMBING CODE, FLORIDA FUEL GAS CODE, AND LOCAL PLUMBING CODES. WHERE CONFLICTS OCCUR BETWEEN CODES AND BETWEEN THE CONSTRUCTION DOCUMENTS AND CODES, THE MOST RESTRICTIVE REQUIREMENTS SHALL GOVERN.
2. TEST, INSPECT, AND PURGE NATURAL GAS PIPING ACCORDING TO NFPA 54 AND AUTHORITIES HAVING JURISDICTION.
3. INSTALLATION OF EQUIPMENT AND PIPING SHALL PROVIDE CONVENIENT ACCESS FOR MAINTENANCE.
4. GRAVITY FLOW SYSTEMS HAVE SPACE PRIORITY FOR SLOPING PIPES, HOWEVER SLOPE MUST BE STARTED AT HIGHEST POINT POSSIBLE.
5. PAINT GAS PIPING EXPOSED TO VIEW YELLOW.

DRAWING INDEX

PG-001	General Notes & Legends
PG1-101	Vehicle Storage

SEAL:

PROJECT TITLE:

**UUPI - LBR Relocation
Support Structures For
City of Tallahassee**

JOB NO.: 21.130

DESIGNED: FPH

CHECKED: **MPF**

THIS DRAWING AND ANY REPRODUCTIONS
ARE THE PROPERTY AND COPYRIGHT
OF BKJ, INC. AND MAY NOT BE
REPRODUCED, PUBLISHED, OR USED IN ANY
MANNER WITHOUT WRITTEN
PERMISSION OF THE ARCHITECT

[illegible]

DRAWING PHASE:
100% Construction Documents

DRAWING TITLE:


**General Notes &
Legends**

 
SHEET NO.:

PG-001

DATE:

October 03, 2025

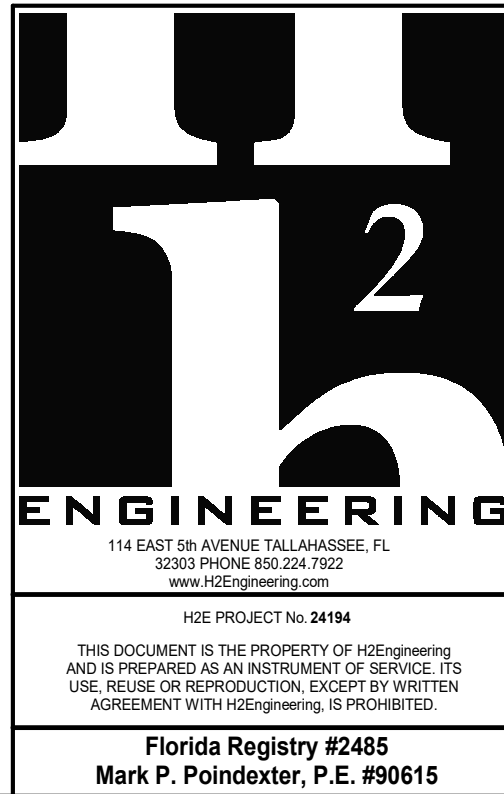



1. SEE RISER DIAGRAM AND GAS PIPING SCHEDULE ON SHEET PG101