


ANTHROPOLOGIE

WATERSOUND TOWN CENTER

19 PLAZA WAY

INLET BEACH, FL 32461

C-2- LANDLORD COORDINATION DRAWINGS

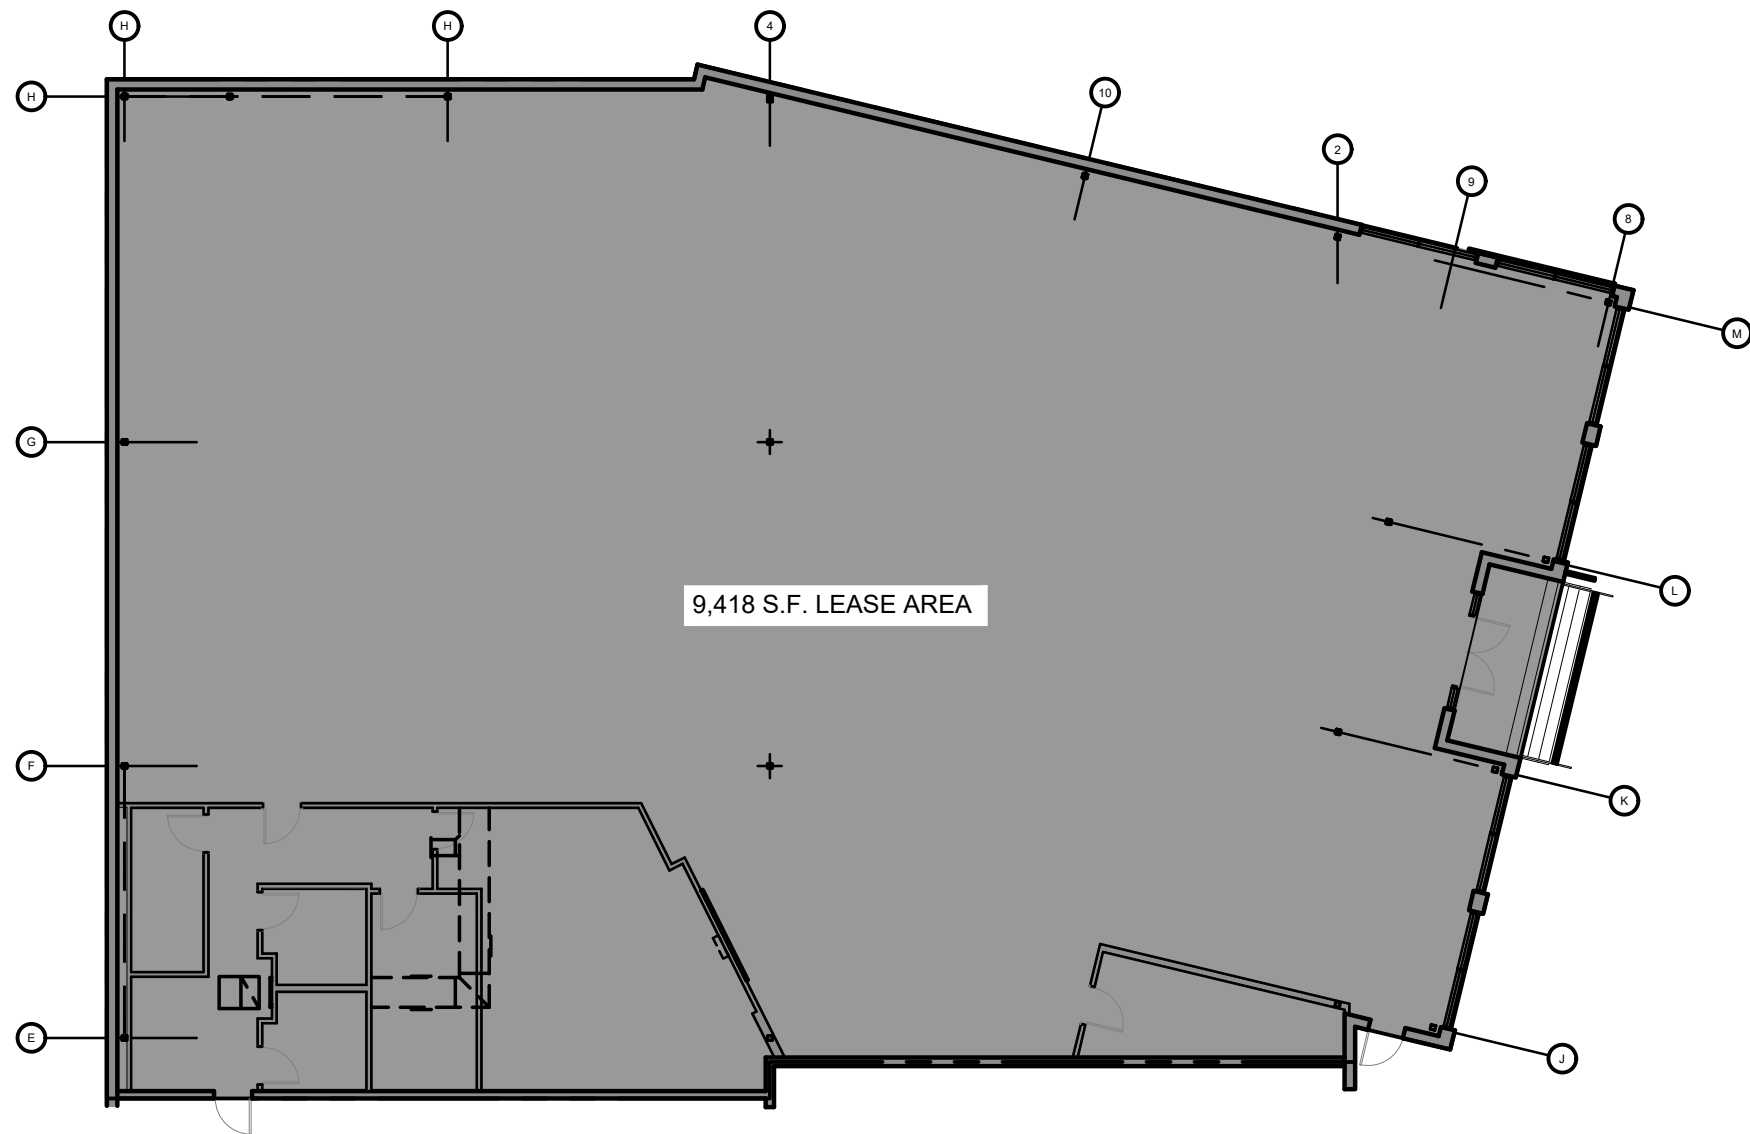

LOD PLAN
SCALE: 1/16" = 1'-0"




WATERSOUND TOWN CENTER MAP



TENANT LOCATION

WATERSOUND TOWN CENTER
19 PLAZA WAY, INLET BEACH, FL 32461

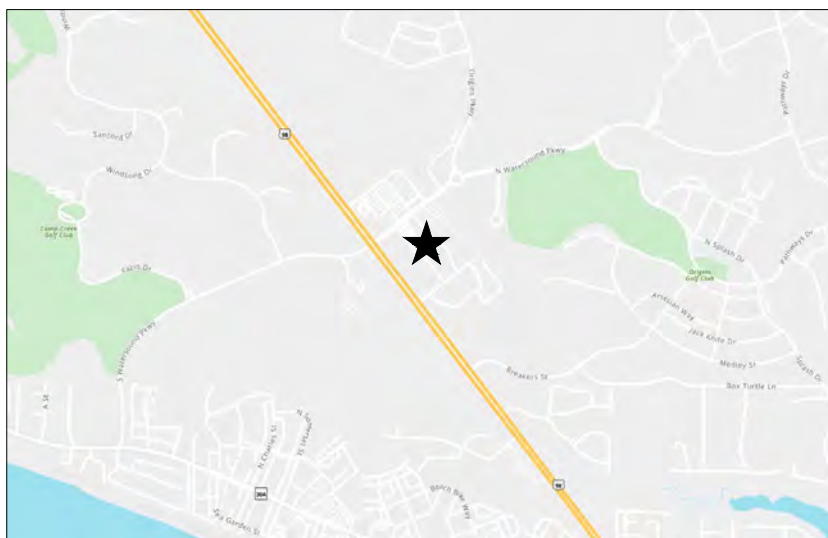

INDEX OF DRAWINGS- LANDLORD COORDINATION

ARCHITECTURAL		MECHANICAL	
GENERAL INFORMATION			
G104	FINISH & MATERIALS SCHEDULE	M100	MECHANICAL PLAN
		M200	MECHANICAL SYMBOLS, NOTES & SCHEDULES
		M300	MECHANICAL DETAILS
		M400	MECHANICAL SPECIFICATIONS
PLANS		ELECTRICAL	
A100	FLOOR PLAN	E100	ELECTRICAL SYMBOLS & FLAG NOTES
A101	ENLARGED BOH PLAN	E101	LIGHTING SCHEDULE
A102	ENLARGED TOILET ROOM PLAN & ELEVATIONS	E200	ELECTRICAL FLOOR PLAN
A130	ROOF PLAN	E201	POWER RISER DIAGRAM AND PANEL SCHEDULES
		E400	ELECTRICAL DETAILS
CEILING		E700	ELECTRICAL SPECIFICATIONS
A200	REFLECTED CEILING PLAN	E701	ELECTRICAL SPECIFICATIONS
A201	REFLECTED CEILING DIMENSION PLAN		
EXTERIOR ELEVATIONS		FIRE PROTECTION	
A300	ENLARGED STOREFRONT PLAN / ELEVATION	FP100	FIRE PROTECTION PLAN
EXTERIOR SECTIONS / DETAILS			
A450	SKYLIGHT SECTIONS / DETAILS		
DOORS & WINDOWS			
A600	DOOR SCHEDULE / TYPES & NOTES		
A601	DOOR DETAILS		
A602	THRESHOLD/ FLOORING DETAILS		
FIXTURE DETAILS			
A801	BOH CASEWORK		
WORKLETTER			
A900	WORKLETTER FROM EXECUTED LEASE		

ISSUE / DATE:

C-2 : LANDLORD COORDINATION-DRAFT

10-08-2026

C-2 : LANDLORD COORDINATION- FINAL

10-14-2026

**DAVID A. LEVY
& ASSOCIATES**
 > Retail Design & Development

345 SPRINGSIDE DRIVE TEL 330 / 666-6767
AKRON, OHIO 44333-2434 FAX 330 / 666-8334